
 


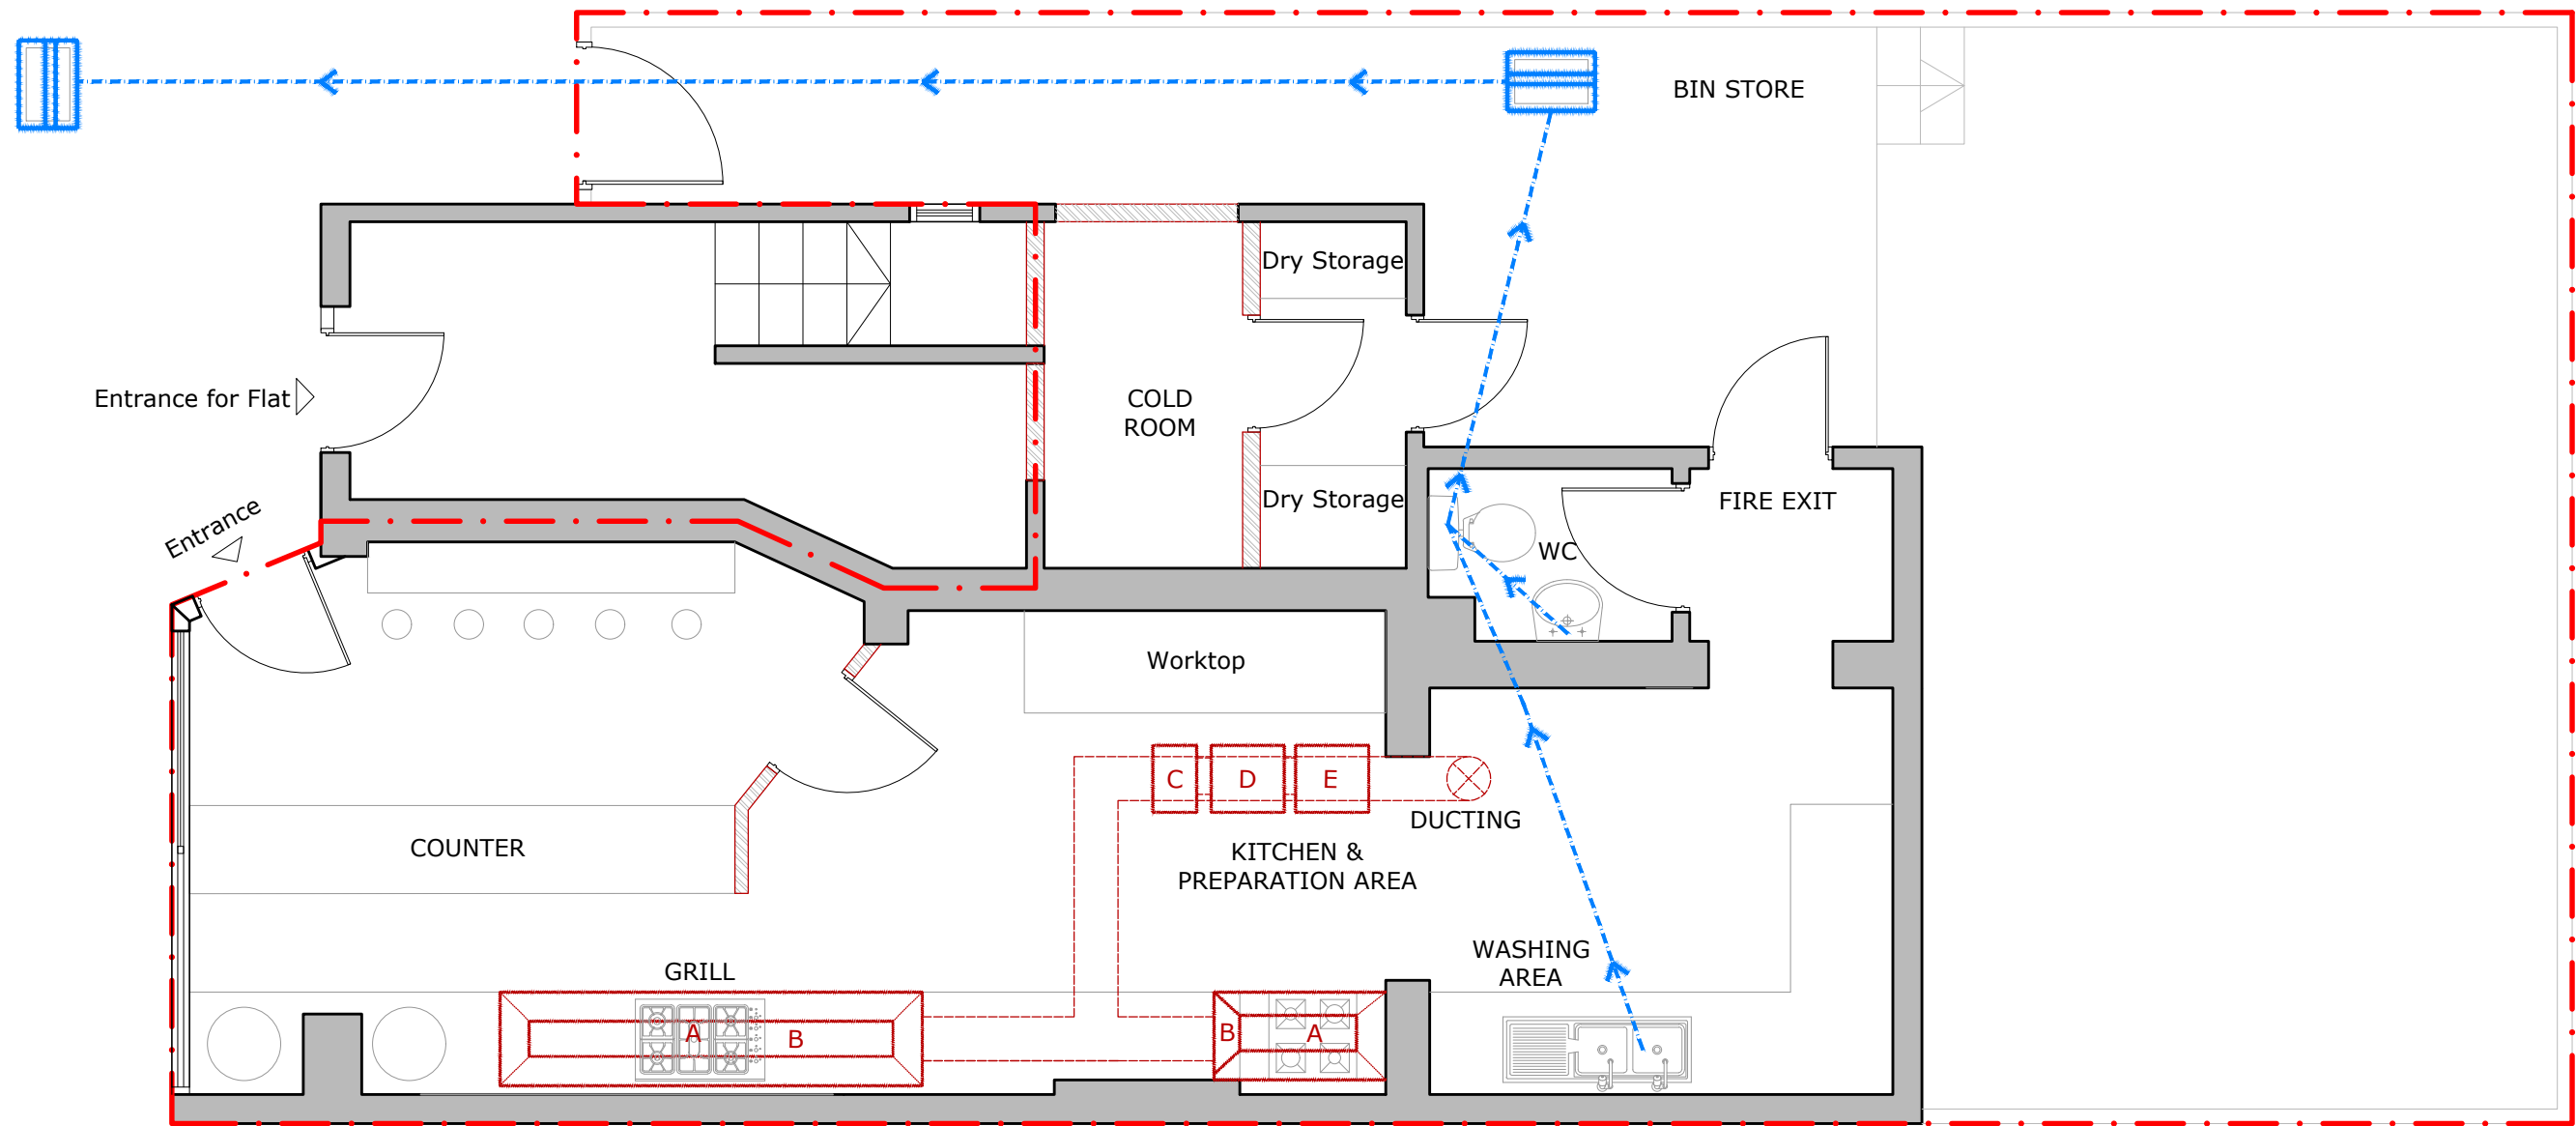

SCHEMATIC DIAGRAM OF A KITCHEN VENTILATION SYSTEM LEGEND

- A. COOKING AREA
- B. CANOPY
GFBE JASUN BAFFLE GREASE FILTERS CODE:GFBEx-1818
SIZE:445X445X45MM.
RATED AIRFLOW M3/HR :1069 FILTERS TO BE INSTALLED AT ANGLE
OF NOT LESS THAN 45° AT FROM HORIZONTAL
- C. ACTIVATED CARBON FILTERS
WIRE MESH SUPPORTED PLEATED SYNTHETIC MEDIA (EU4)
PREFILTER MUST BE REPLACED EVERY 2-4 WEEKS
- D. FAN/ MOTOR UNIT
MODEL NO : GBW500.1.1
HELIOS CENTRIFUGAL FAN
- E. SOUND ATTENUATORS

PLEASE NOTE
1. All dimensions to be verified on site.
2. All dimensions are in millimeters.
3. No work shall commence until all approvals
and agreements have been obtained.
These include, Planning, Building
Regulations, Water and party Wall.
4. The Copyright of this drawing belong to
Adv Planning Limited T/A Advance Architecture.



Drawn By IE
Checked By KK

PROJECT
STATUS

PLANNING
PROPOSED GROUND
FLOOR PLAN

PROJECT

91 Hawthorn Rd,
Bognor Regis,
PO21 2BE

SHEET
JOB No.

PLAN
22.001

DRAWING
NUMBER
DATE

P104

REV
R1

ADVANCE
ARCHITECTURE
ARCHITECTURE / PLANNING / LICENSING
352 Green Lanes, Palmers Green, London N13 5TJ - 020 8801 6601
www.advancearchitecture.co.uk
info@advancearchitecture.co.uk