


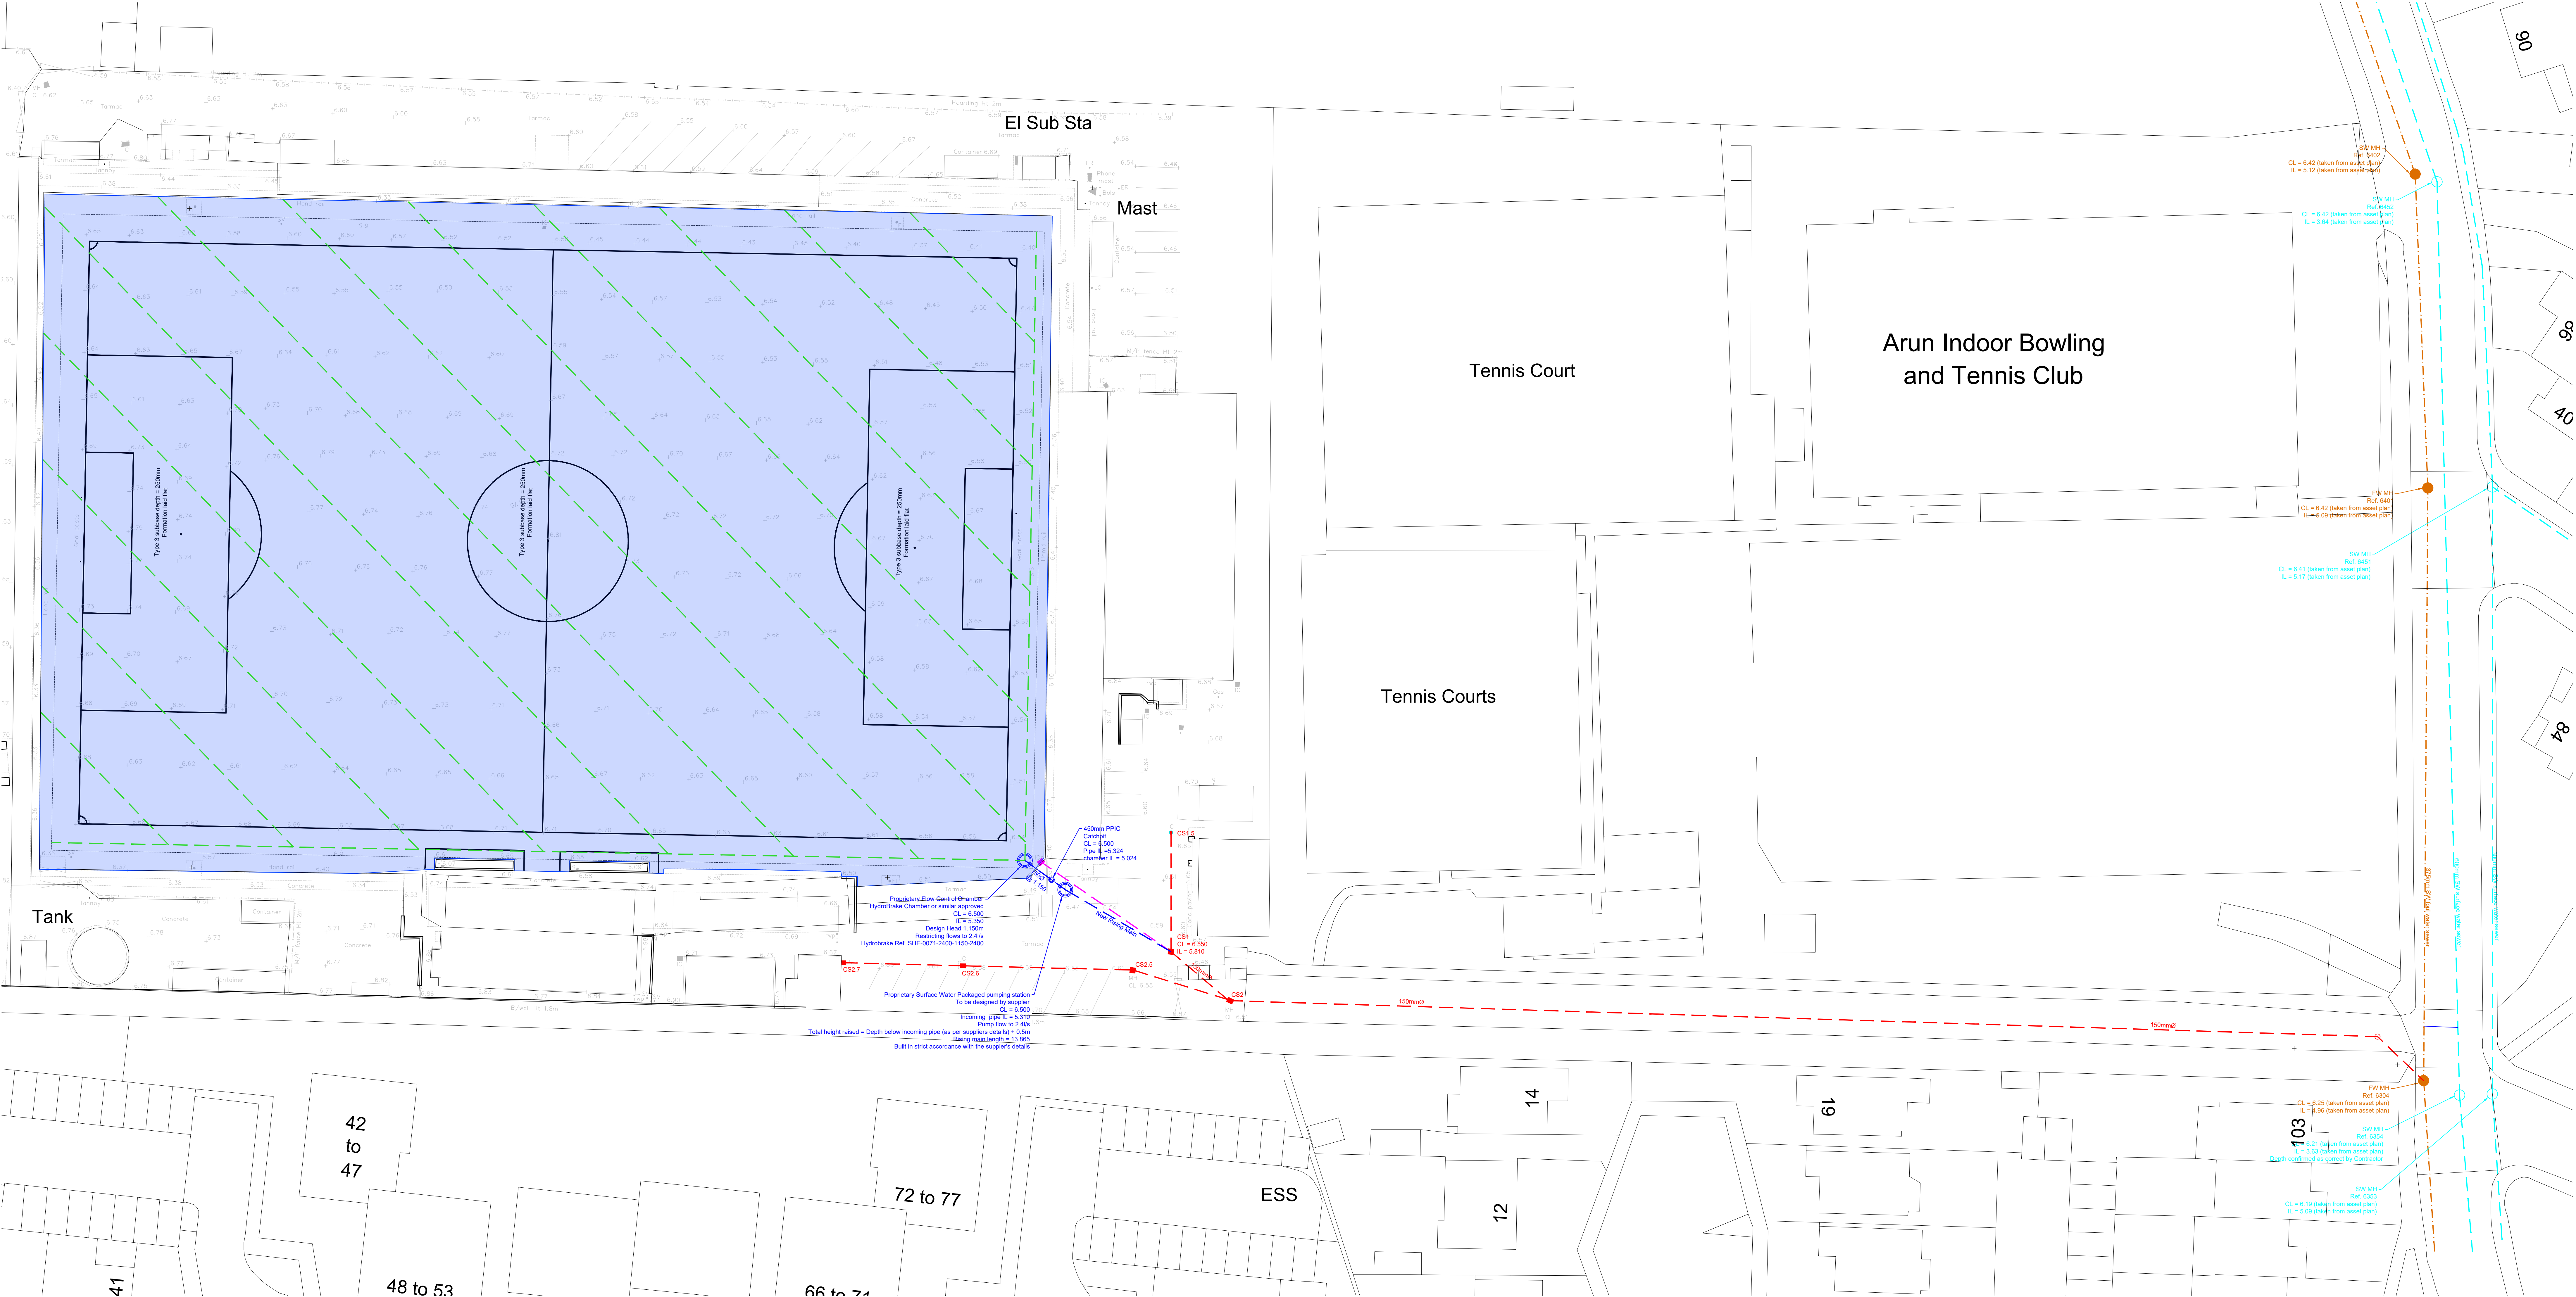

GENERAL

Do not scale from this drawing.

All dimensions are in millimetres unless noted otherwise.

All setting out to architects drawings.

Drawing to be read in conjunction with all other SEA drawings and architects drawings.

This scheme has been designed using the survey information provided by others. It shall be the responsibility of the contractor to verify levels, boundaries etc prior to commencing any works on site. SEA Structural Engineers Ltd. shall not accept any responsibility for errors resulting from the survey.

All setting to be in accordance with the Architect's drawings, the Contractor is to check all dimensions and levels prior to commencement of work and report any discrepancies to the Engineer, including any encountered during construction works.

All dimensions should be checked on site prior to construction. Please notify the Engineer of any discrepancies before commencing or continuing any work.

HEALTH, SAFETY & THE ENVIRONMENT

In accordance with the Health and Safety at Work etc Act 1973 and the Construction (Design and Management) Regulations 2015, designs and details on this drawing have been the subject of a Designers Risk Assessment, to identify risks in construction, use, or demolition of the scheme.

It is not considered necessary for Designers to highlight obvious and/or common risks (such as deep excavations, manual handling and working around heavy plant) which Contractors should be familiar with.

So far as is reasonably practicable, risks inherent in the design have been eliminated. Where it has been considered that elimination of a risk (or part of a risk) is not reasonably practicable, it has been reduced.

Significant unusual residual risks are identified below, beside the measures which have been adopted to eliminate and/or reduce them:

None identified.

DRAWING KEY:

- Existing combined private drainage, as per CCTV report
- - - Existing pitch outfall pump and pipework to be abandoned
- - - Approximate position of existing southern water foul sewers
- - - Approximate position of existing southern water surface water sewers
- - - Proposed perforated lateral drains beneath pitch as per pitch contractors design.
- - - Proposed pitch surface water outfall, 150mm pipe, UPVC
- Proposed permeable type 3 subbase extends beneath pitch, depth as indicated, providing attenuation for the 1 in 100 year storm event. In the 1 in 100 year + 45% event water will be stored within the surfacing layers of the pitch up to 55mm (assumed 15% void ratio).

Pumping Station Notes

The packaged pumping station shall be fully automatic with provision for remote monitoring. Plant and equipment shall be capable of operating between the manufacturers recommended service intervals without attention or inspection.

The packaged pumping station shall meet the requirements of BS EN 752 and shall be installed strictly in accordance with the manufacturers requirements.

The packaged pumping station shall be supplied by a specialist manufacturer to meet the drainage details indicated on this drawing.

The location of the control kiosk and alarm system supplied with the packaged pumping station shall be in accordance with the Client's requirements.

Draft operating instructions and maintenance manuals shall be submitted to the contractors for approval prior to installation. Working operating instructions and maintenance manuals shall be provided within 3 months of instruction.

Pumping Station Specification - General

P51 The pumping station shall be designed to accommodate the following: liquid - Surface water
P52 The pumping station shall remain in private ownership.
P53 Pump discharge restriction is 2.4m.
P54 Pumping station shall be a packaged pumping station.
P55 Number of pumps required = twin
P56 Control panel to be located adjacent to the pumping station.
P57 Control panel distance from pump chamber = approx. 5m.
P58 Weather proof kiosk - Required
P59 Electric supply to be single phase (TBC by supplier)
P511 Access cover loading to be 5 tonne
P512 Incoming flow rate = 2.4cfs
P513 Cover level of pumping station = 6.500
P514 Incoming pipe invert level = 5.310 (150mmØ)
P515 Length of rising main = 13.865
No bends = 0
Outfall level = 5.810

1 22.05.25 WRA Catchup chamber added upstream of pump
2 14.03.25 WRA Allocated to get discussions with Southern Water, new pump added
3 10.09.25 WRA Man inserted to control chambers to suit SW sewer levels
4 17.08.25 WRA Design updated to provide outfall to SW surface water sewer
5 05.06.25 WRA Updated to suit conditions

Rev	Date	By	Description
1	22.05.25	WRA	Catchup chamber added upstream of pump
2	14.03.25	WRA	Allocated to get discussions with Southern Water, new pump added
3	10.09.25	WRA	Man inserted to control chambers to suit SW sewer levels
4	17.08.25	WRA	Design updated to provide outfall to SW surface water sewer
5	05.06.25	WRA	Updated to suit conditions

SEA
CONSULTING ENGINEERS
[CONSULTING CIVIL & STRUCTURAL ENGINEERS]
E: warren@seae.co.uk
T: 07976310054

PROJECT
NEW AGP
BOGNOR REGIS FC

REVISIONS
PROPOSED DRAINAGE LAYOUT

SCALE: 1:250WRA1 DATE: 10.10.2024
DRAWN BY: WRA REV: E
STATUS: FOR APPROVAL

DWG No: 00223/E02 E