



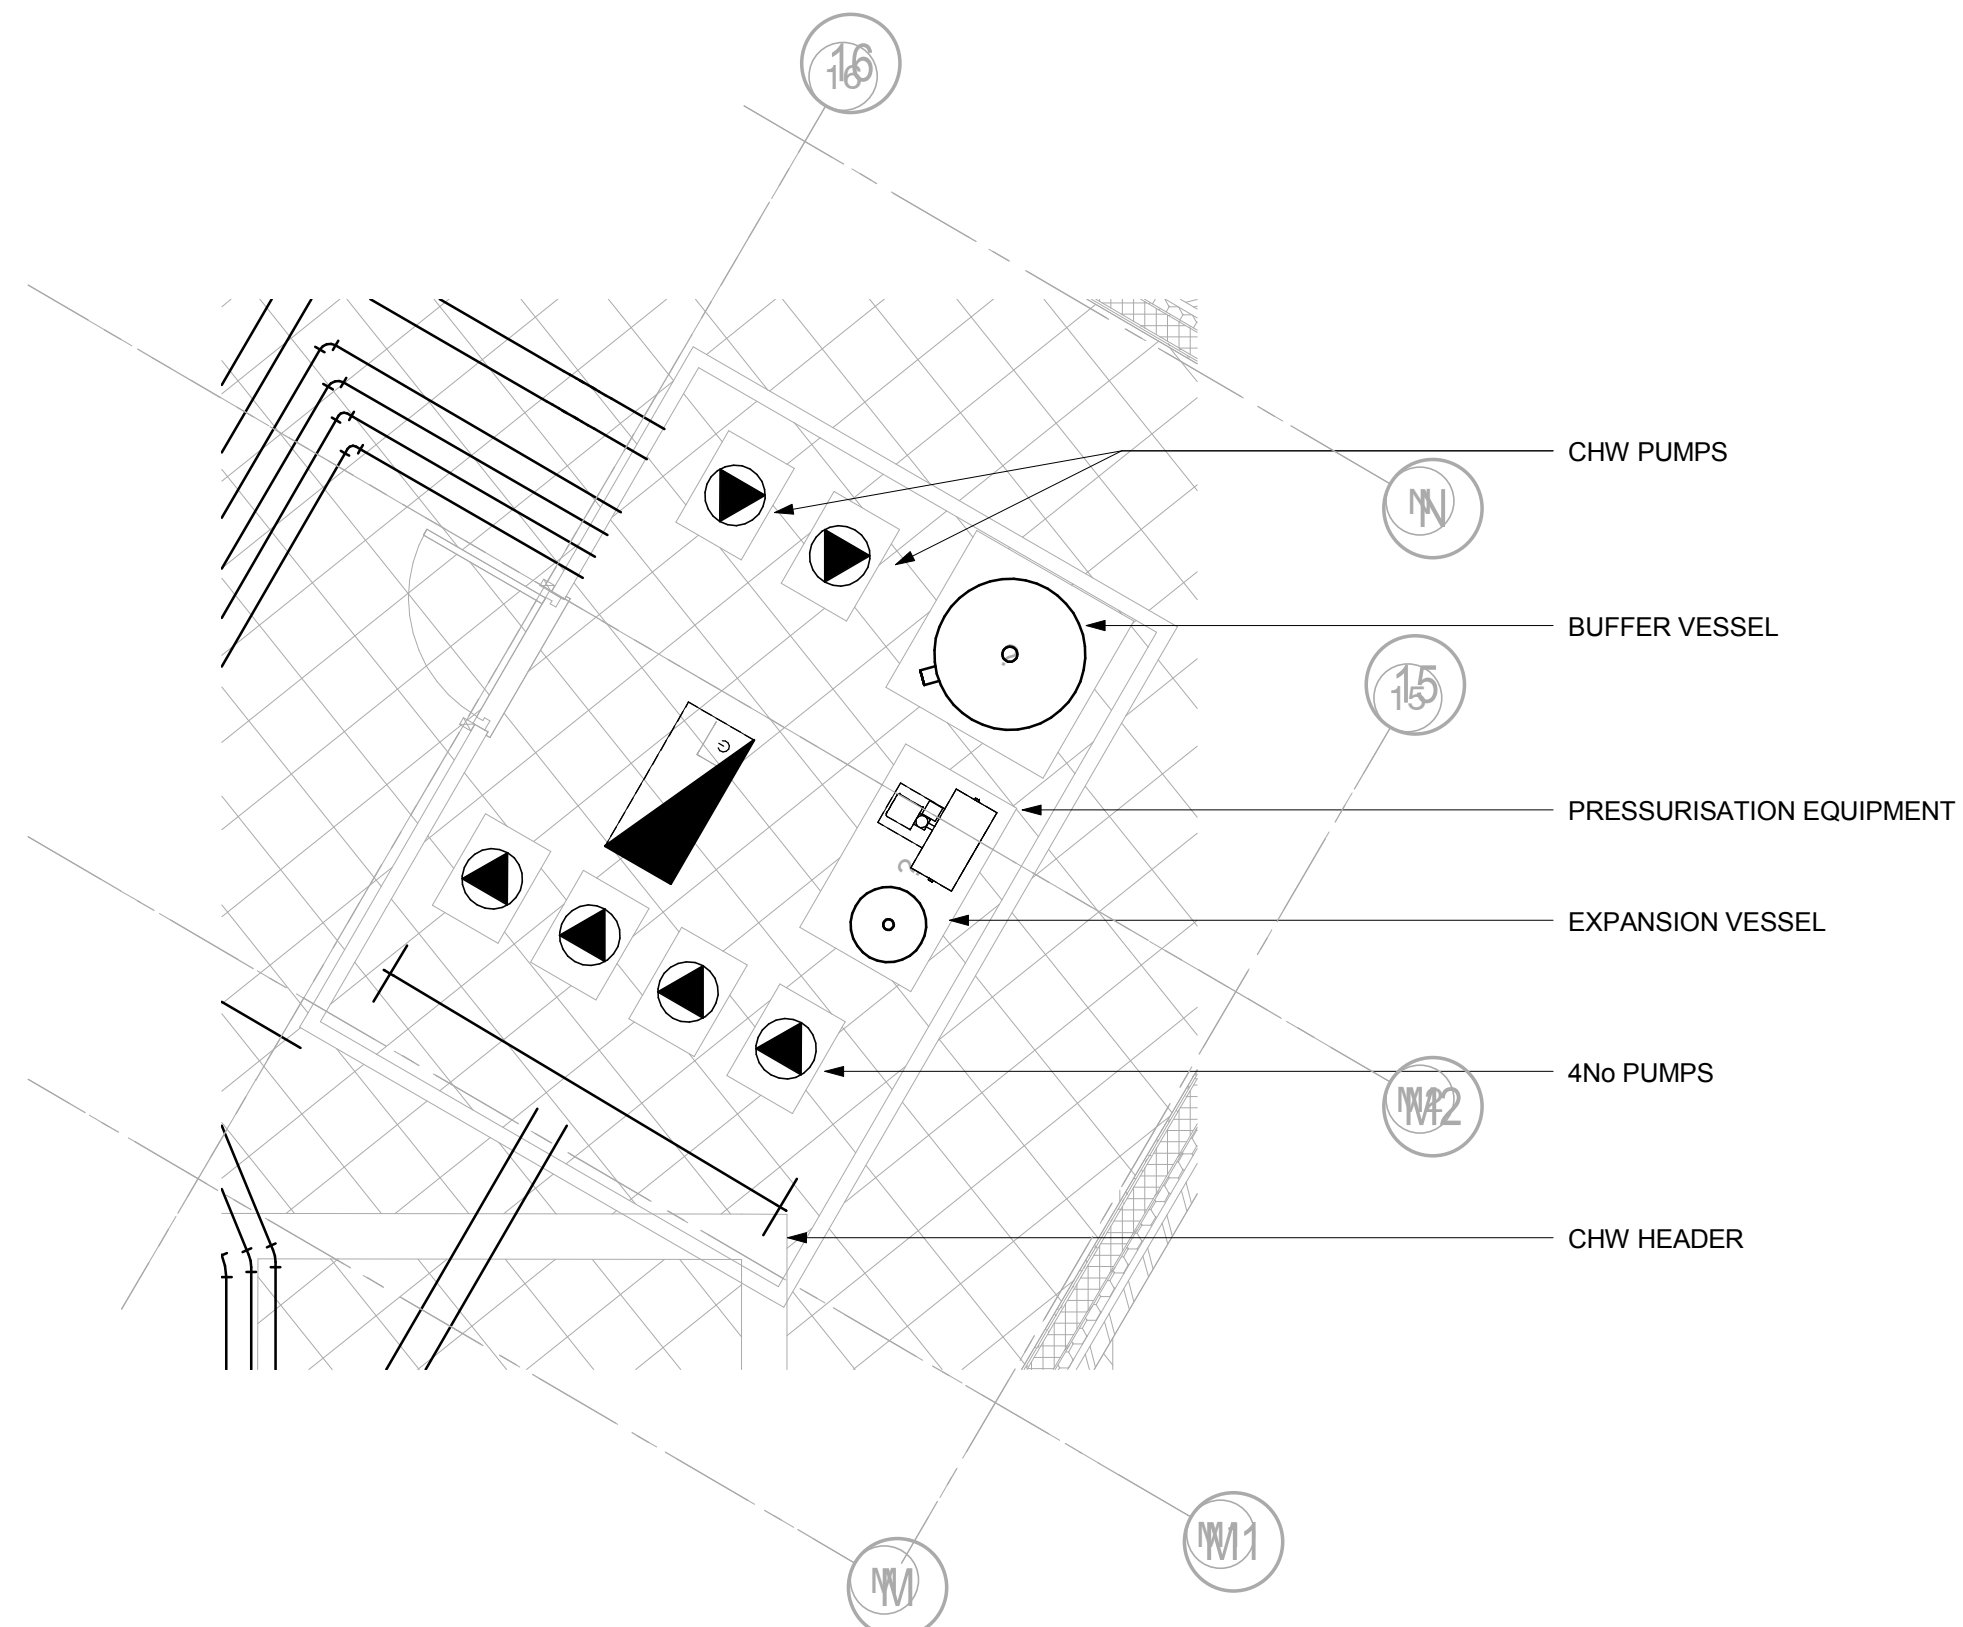

ROOF PLANTROOM

SCALE 1:50

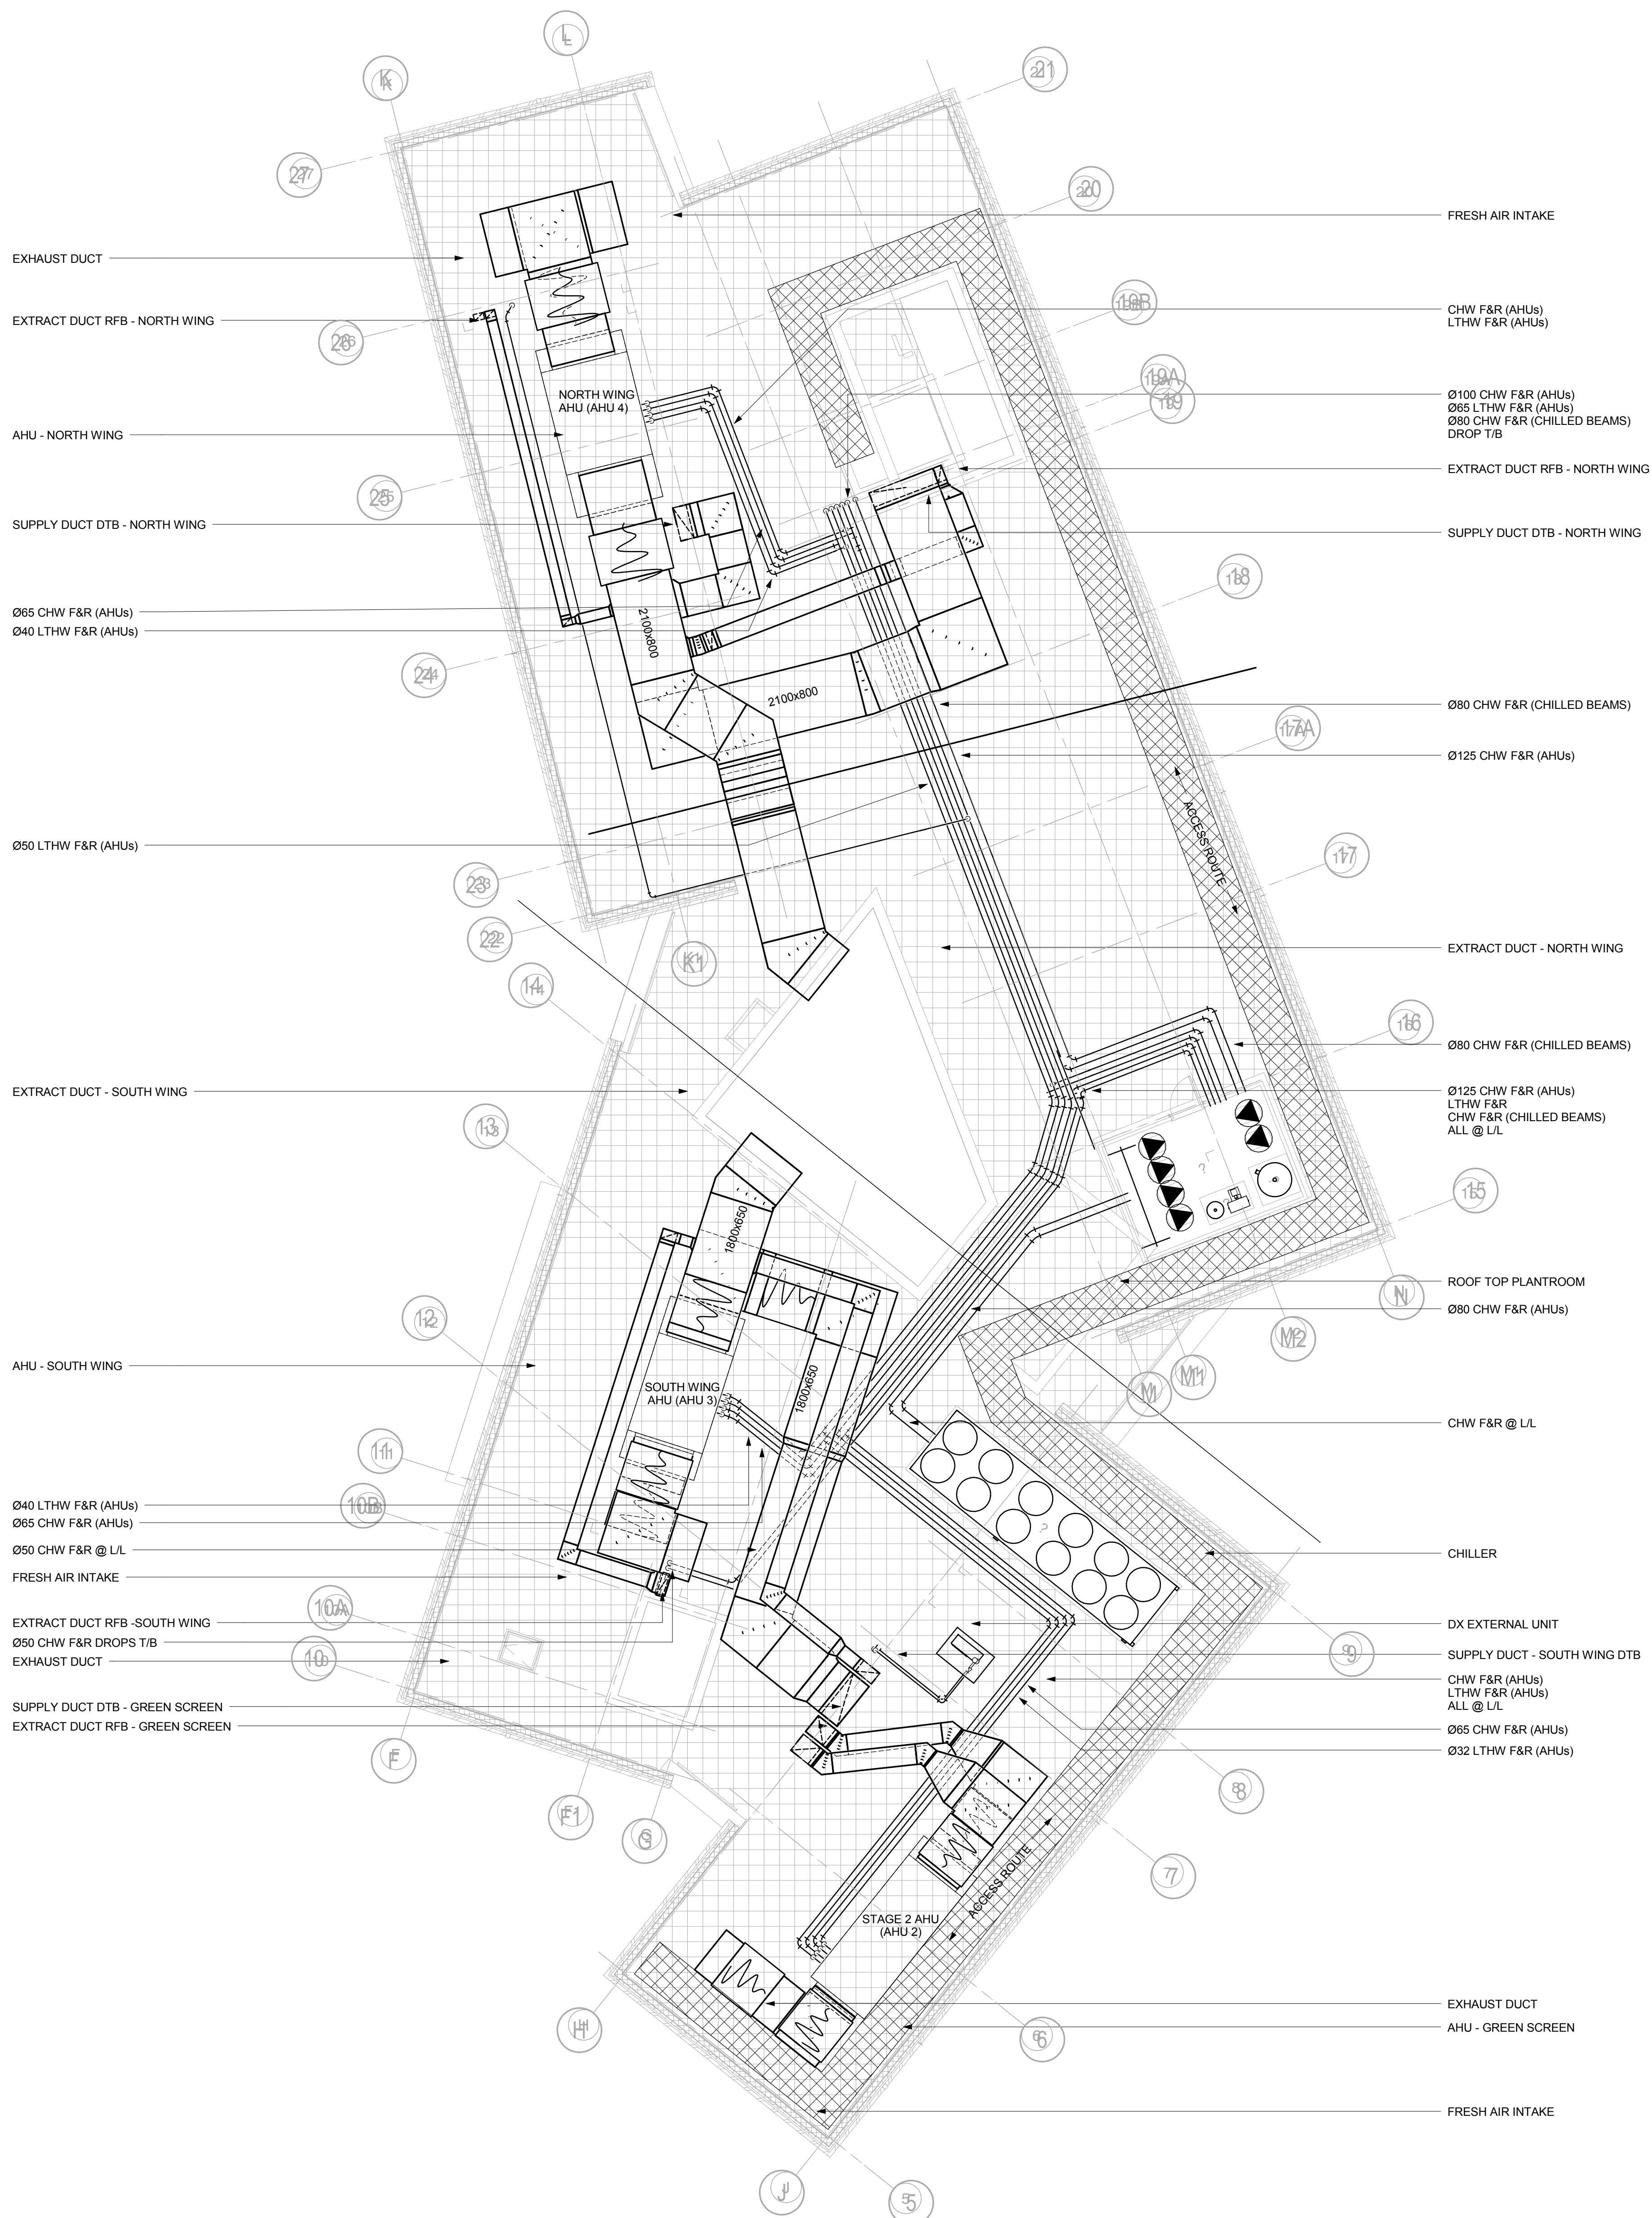

LEGEND

LTHW - LOW TEMPERATURE HOT WATER
CHW - CHILLED WATER
BOWS - BOOSTED COLD WATER SUPPLY
HWS - HOT WATER SUPPLY
FS - FIRE SLEEVE
FC - FLEXIBLE CONNECTION
AP - ACCESS PANEL
ATT - ATTENUATOR
VCD - VOLUME CONTROL DAMPER
MVCD - MOTORISED VOLUME CONTROL DAMPER
FD - FIRE DAMPER
FSD - FIRE SMOKE DAMPER
HL - HIGH LEVEL
LL - LOW LEVEL
F/A - FROM ABOVE
T/A - TO ABOVE
F/B - FROM BELOW
T/B - TO BELOW