




GROUND FLOOR
PLAN

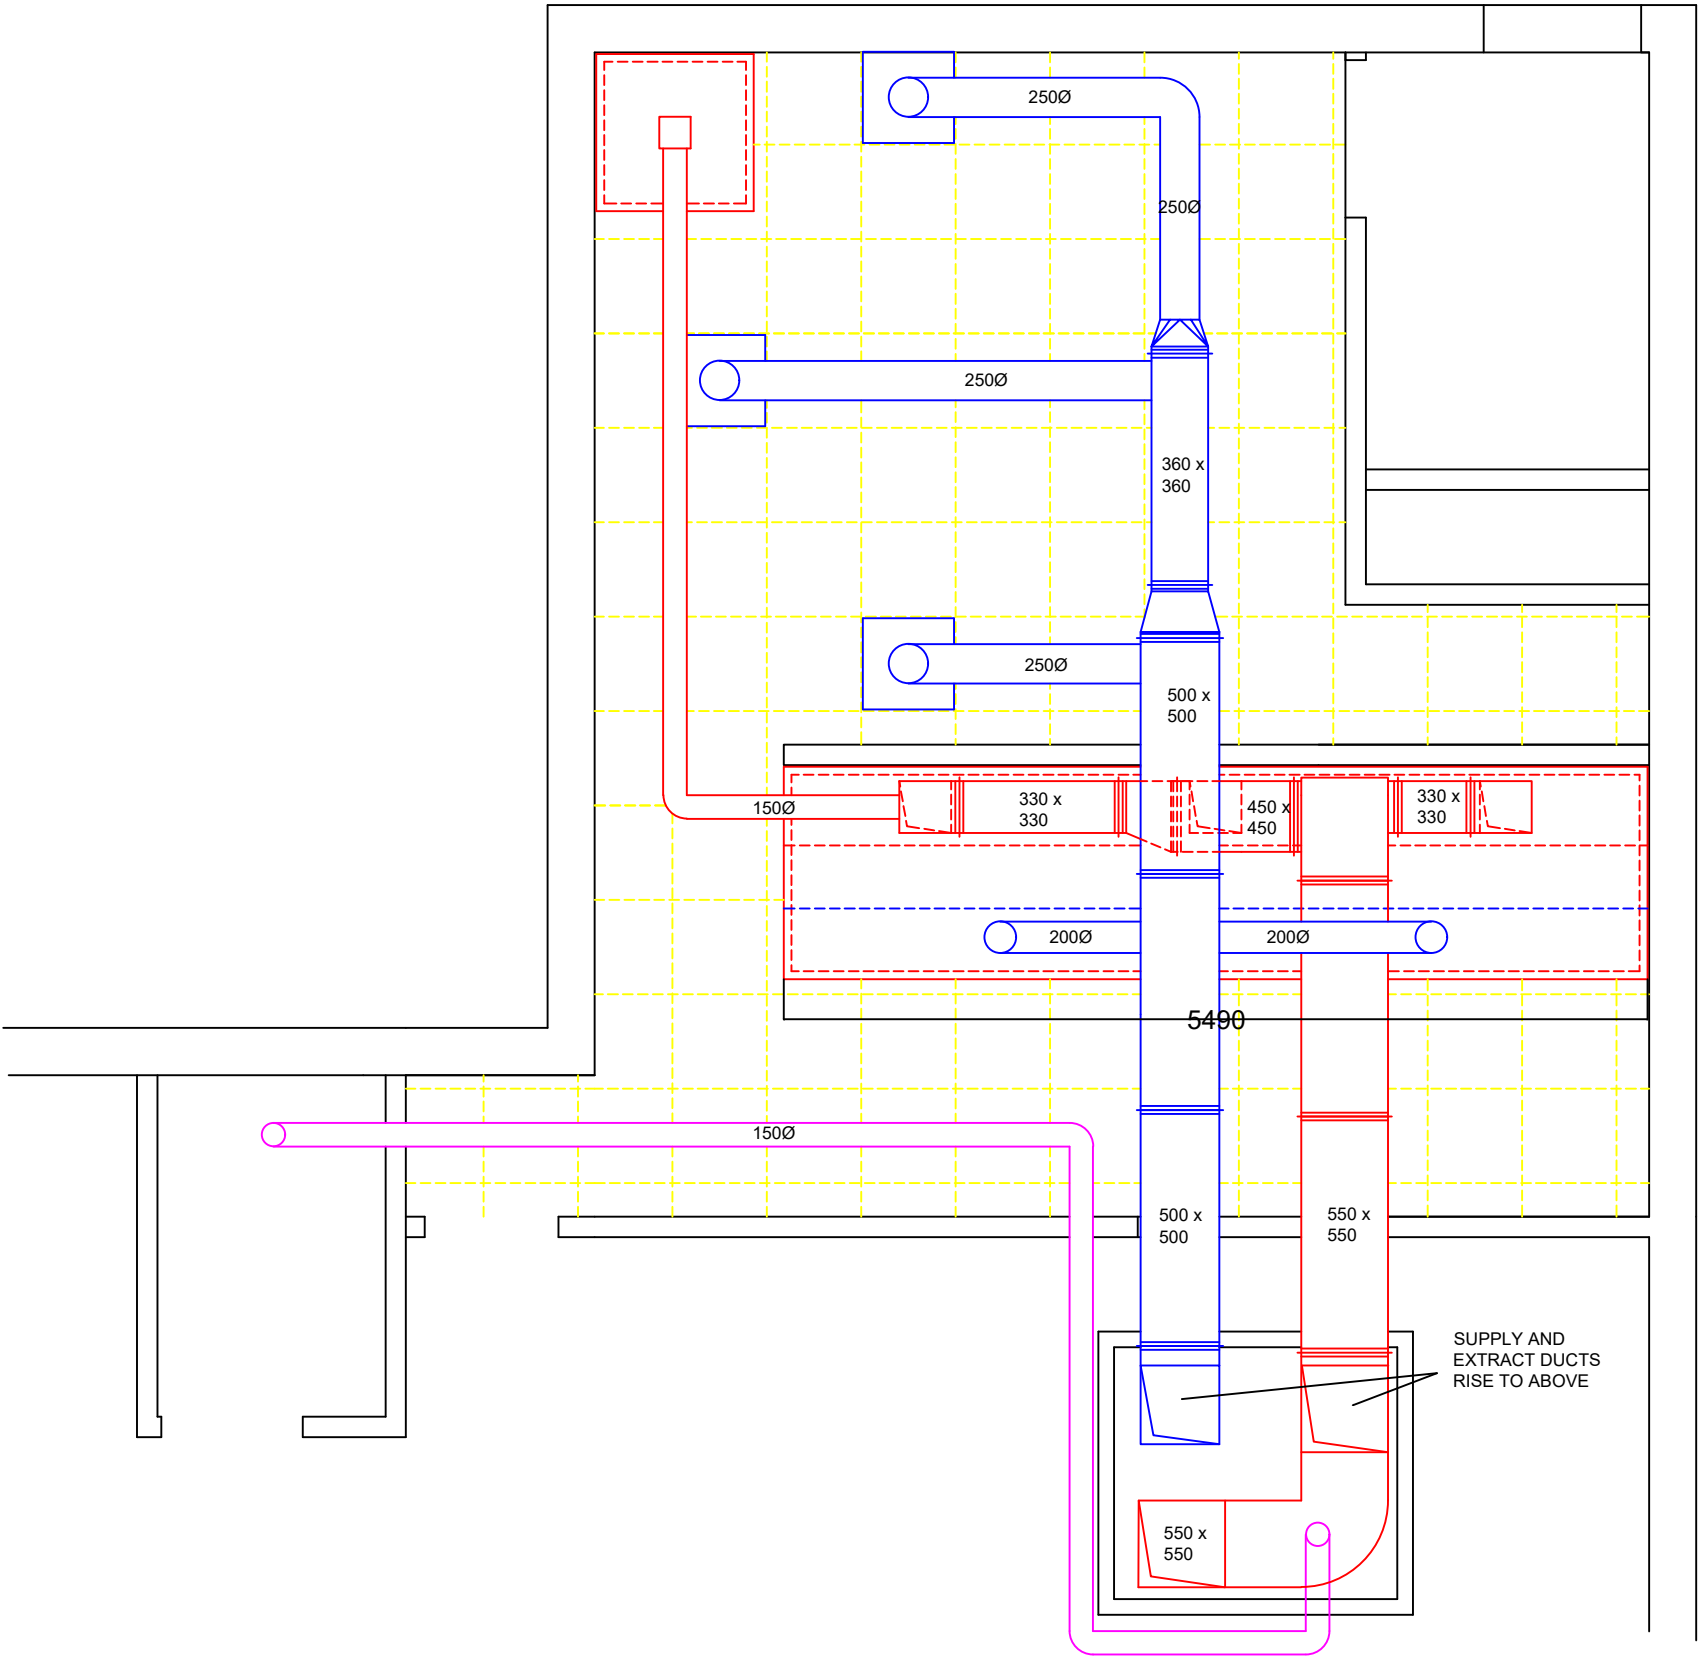


1ST FLOOR PLAN

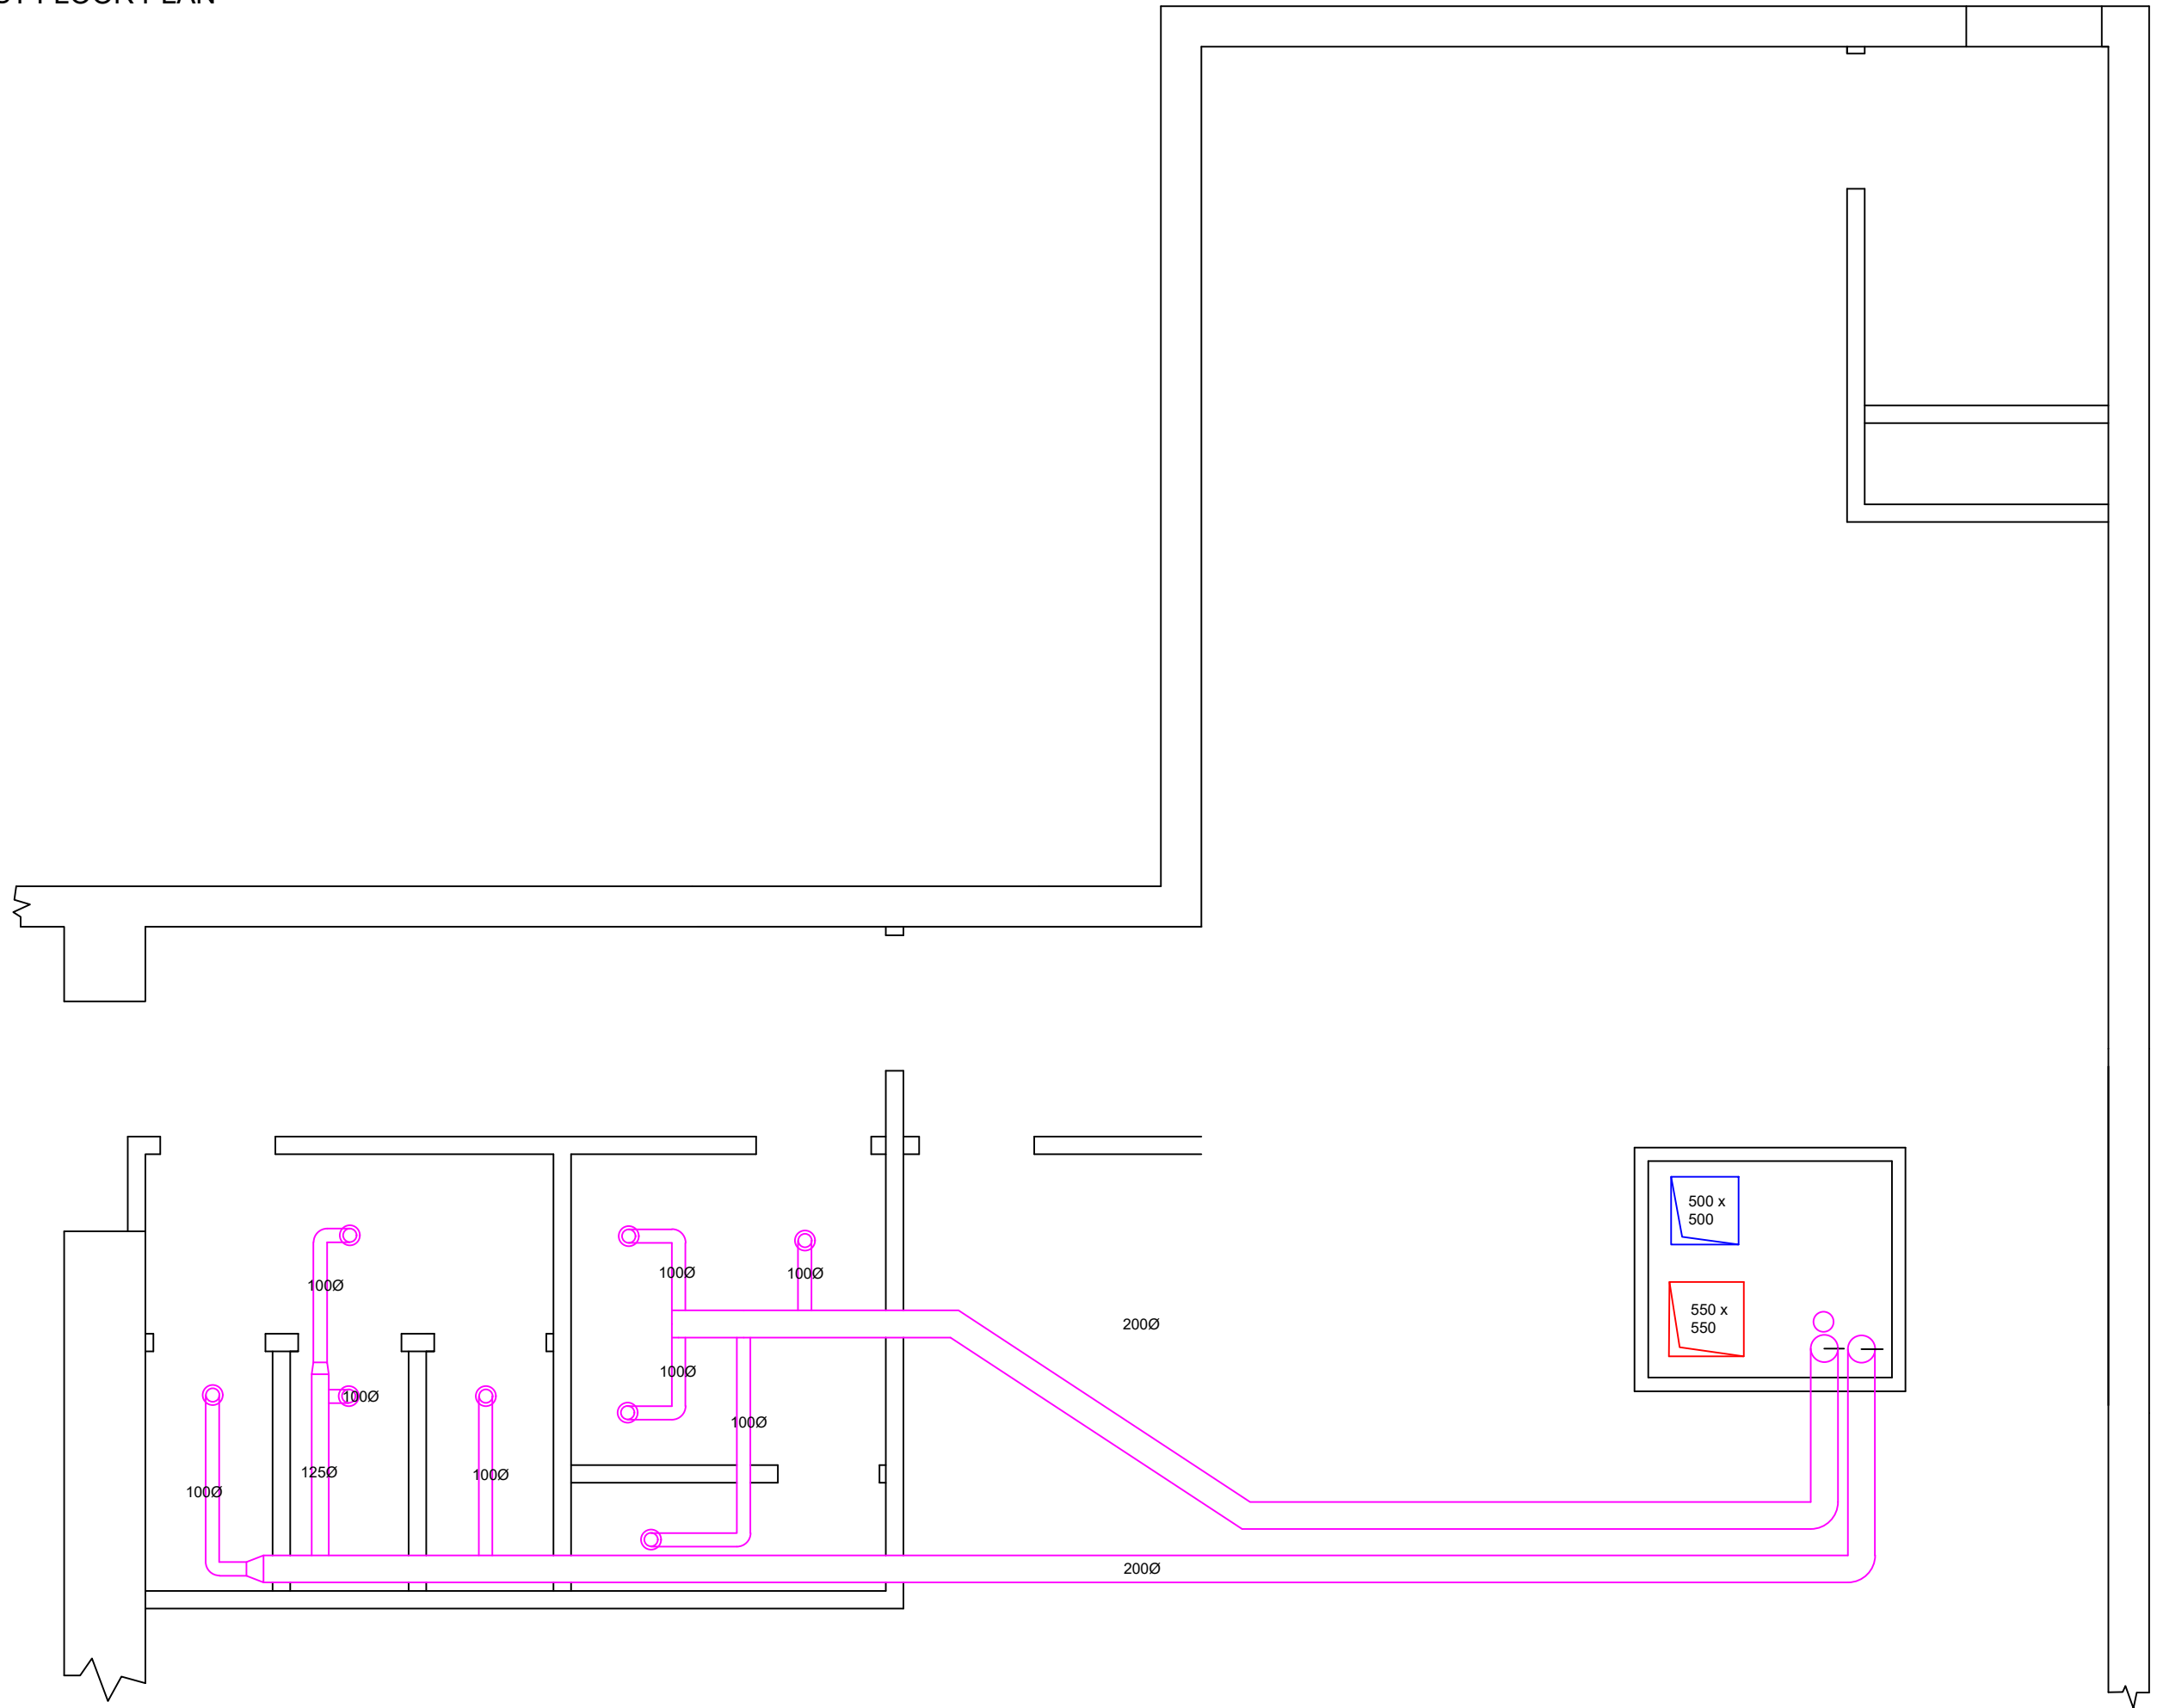

2ND FLOOR PLAN

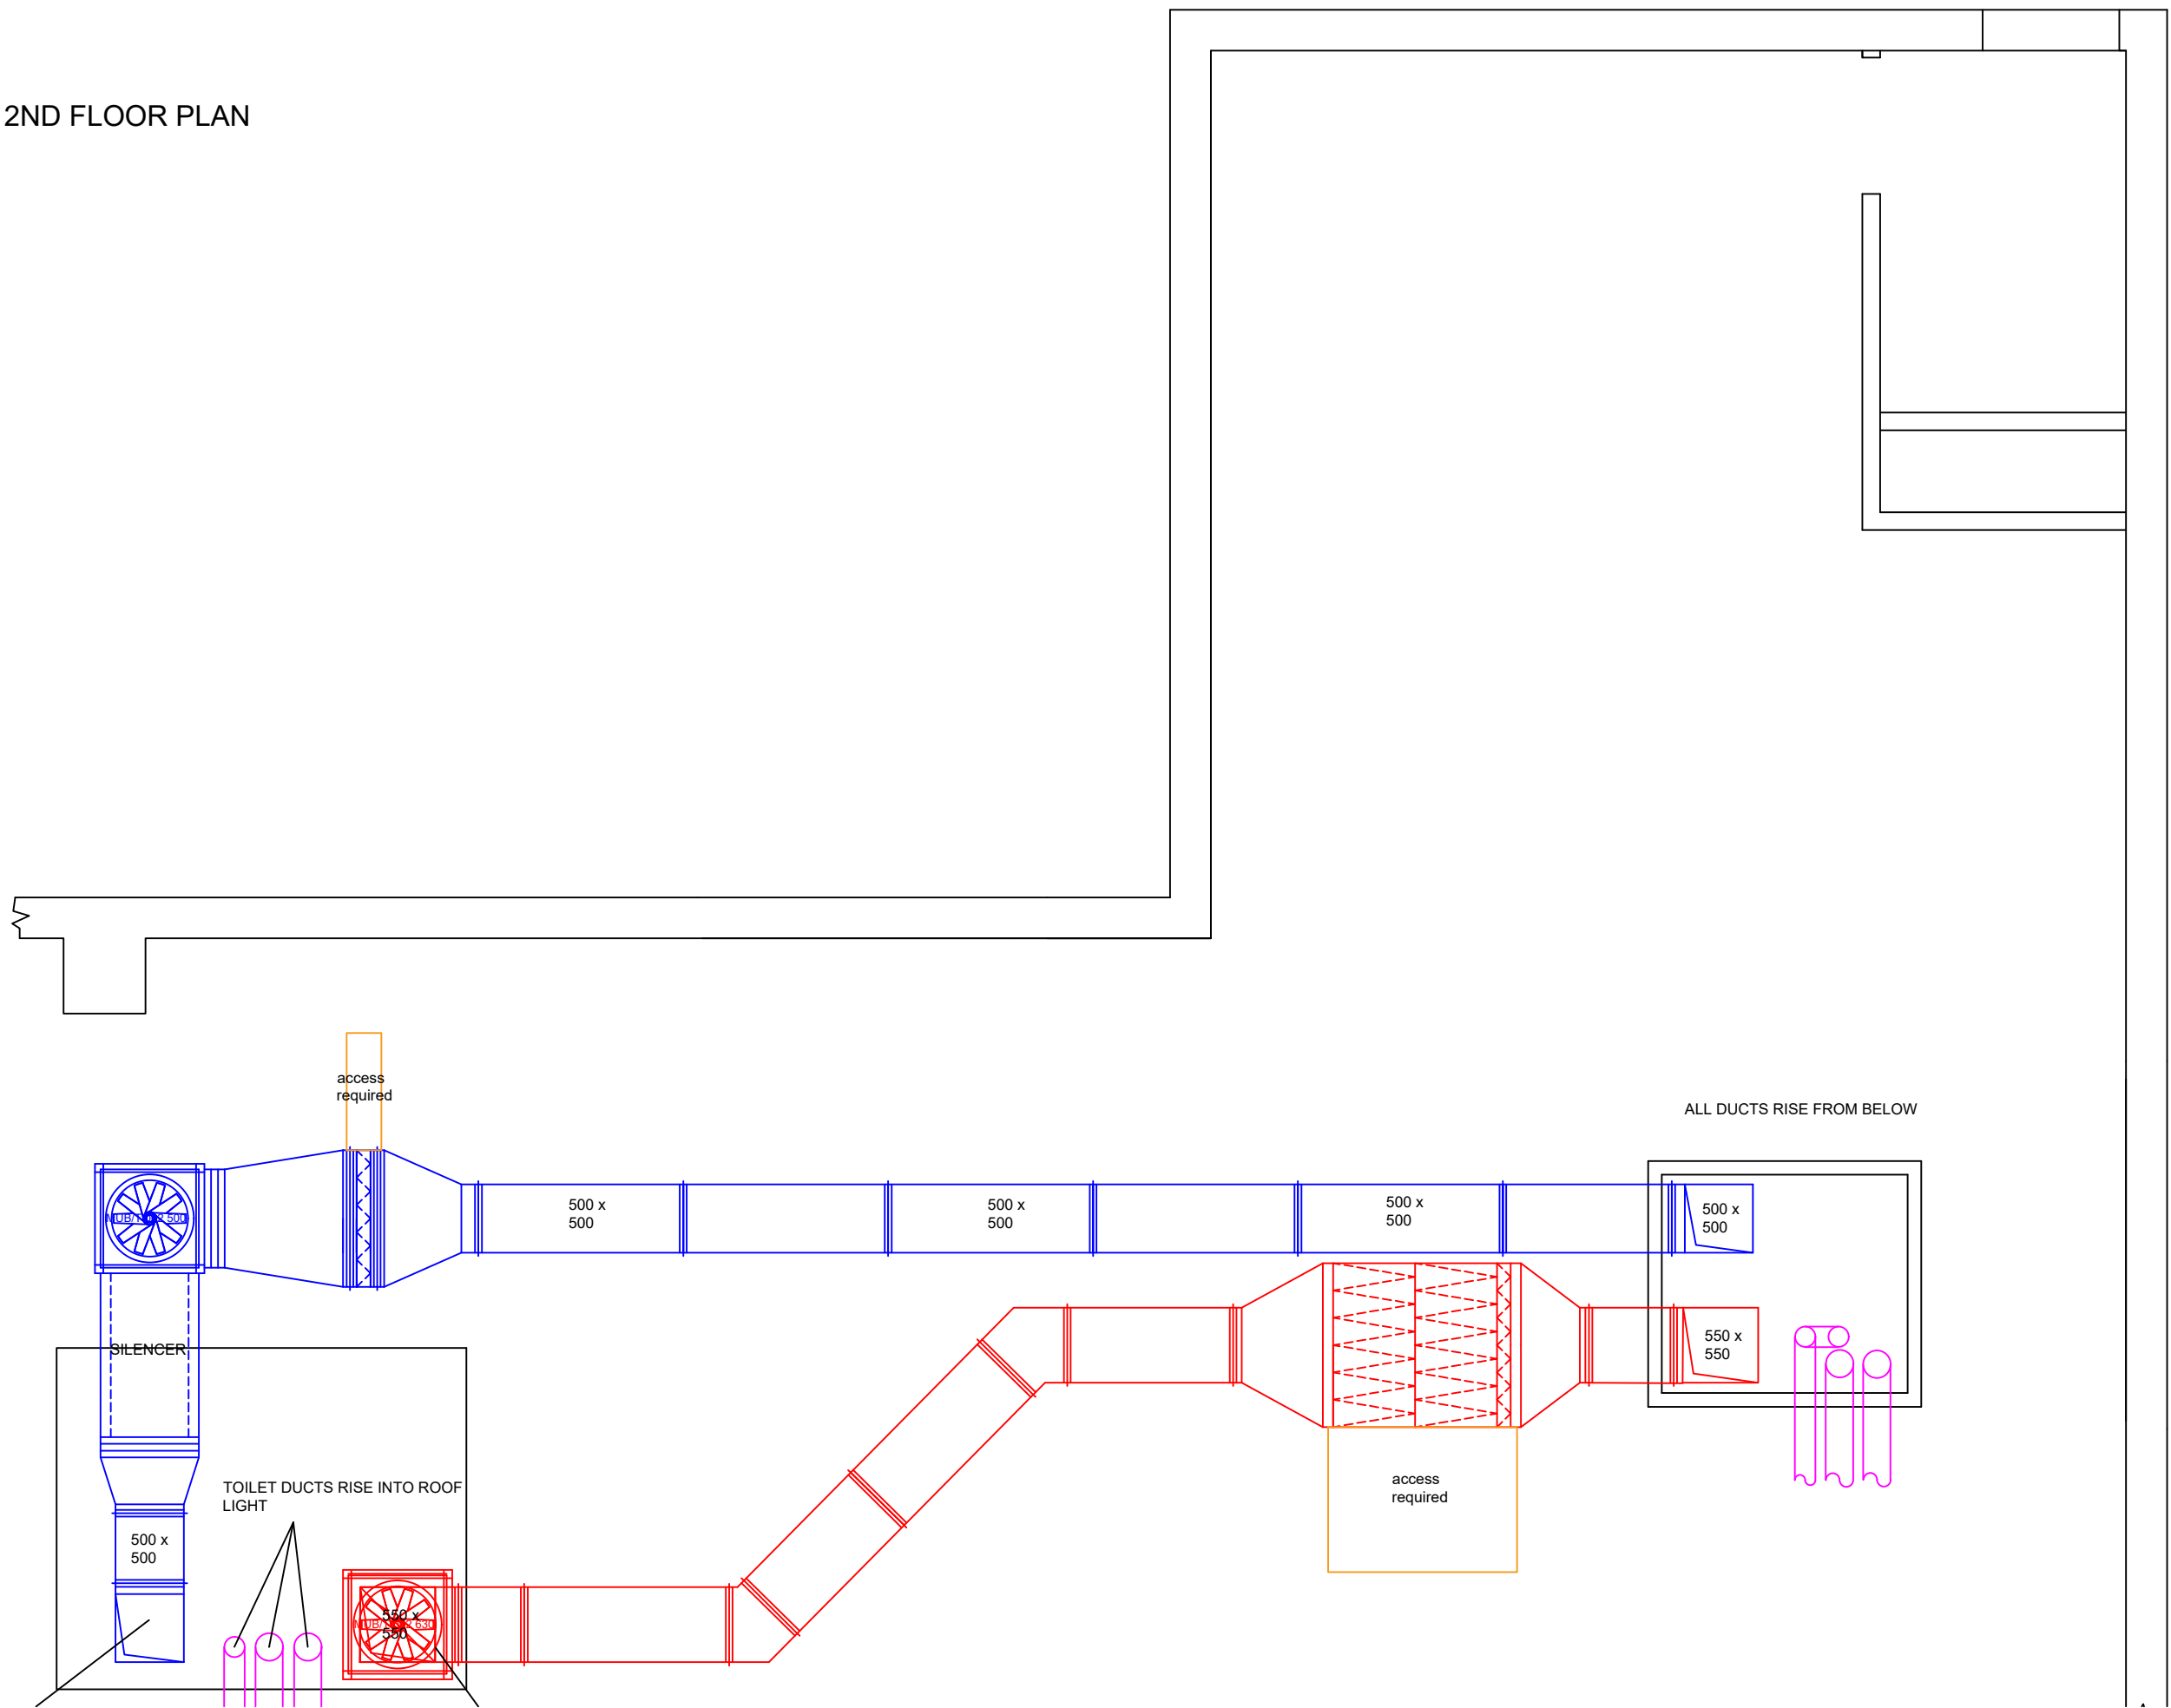

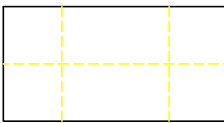-  TOILET EXTRACT SYSTEMS
-  KITCHEN EXTRACT SYSTEM
-  KITCHEN MAKE UP AIR SYSTEM
-  KITCHEN CEILING GRID

BOGNOR REGIS LOUNGE

FOR APPROVAL

DO NOT SCALE FROM THIS DRAWING !

ALL MEASUREMENTS IN MILLIMETRES
GENERAL TOLERANCE +/- 1mm
CANOPY TO BE MANUFACTURED FROM
18G (1.2MM) DULL POLISHED STAINLESS
STEEL GRADE 304.
FOLDED CONSTRUCTION

FAN INFO:

EXTRACT FAN = MUB/T062 630
F.L.C = 8.12 AMPS 3PH
SOUND LEVEL =
EXTRACT CONTROLLER =

EXTRACT FLOW RATE = 2m³/sec

SUPPLY FAN = MUB500
F.L.C = 3.7AMPS
SOUND LEVEL =
SUPPLY CONTROLLER =

SUPPLY FLOW RATE = 1.7M³/SEC

APPROX CANOPY WEIGHT =

APPROX DUCT WEIGHT =

LIGHTS = YES

HEATER BATTERY = NO

FINE FILTRATION = YES

ESP FILTRATION = NO

U.V. = YES

CARBON FILTRATION = YES

REVISIONS:

PROJECT:
BOGNOR REGIS LOUNGE

CLIENT:
LOUNGERS

SCALE : A1 1-50
DATE : 30-9-21
DRAWN BY: RP
DRAWING NO: RP34455
REVISION: A



Cardrew Industrial Estate, Redruth, Cornwall TR15 1SS
Tel: 01209 204700 Fax: 01209 204701
email enquiries@partridge-ventilation.co.uk

I hereby confirm my acceptance of all information
on this drawing and understand that any subsequent
changes to this plan may be subject to additional charges

Customers Signature: