


- RESULTS OF PROPOSED DRAINAGE HYDRAULIC MODEL:
1. NO FLOODING FOR THE 10 YEAR EVENT.

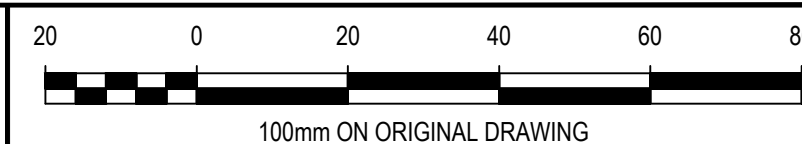

NOTES

1. ALL DIMENSIONS ARE IN MILLIMETRES UNLESS NOTED OTHERWISE.
2. ALL LEVELS ARE IN METRES ABOVE ORDNANCE DATUM UNLESS NOTED OTHERWISE.
3. ALL DIMENSIONS AND LEVELS SHALL BE CHECKED ON SITE PRIOR TO ANY WORKS BEING PUT IN HAND.
4. THE CONTRACTOR IS RESPONSIBLE FOR THE STABILITY OF THE EXISTING STRUCTURE AT ALL TIMES DURING THE WORKS.
5. THIS DRAWING SHALL BE READ IN CONJUNCTION WITH ALL OTHER CONTRACT DRAWINGS AND RELEVANT SPECIFICATIONS.
6. ANY DISCREPANCIES BETWEEN THE INFORMATION GIVEN SHALL BE BROUGHT TO THE ATTENTION OF THE ENGINEER AS SOON AS POSSIBLE.
7. ALL MATERIALS USED IN THE WORKS SHALL BE TO BRITISH STANDARDS OR OTHER APPLICABLE SPECIFICATIONS.
8. ALL WORK IS TO BE CARRIED OUT TO B.S. CODES OF PRACTICE AND IN ACCORDANCE WITH GOOD WORKMANSHIP PRACTICE.
9. ALL PROPRIETARY MATERIALS USED IN THE WORKS SHALL BE USED IN COMPLETE ACCORDANCE WITH THE MANUFACTURERS RECOMMENDATIONS.
10. ALL BURIED, SURFACE AND OVERHEAD SERVICE INFORMATION CONTAINED WITHIN THIS DRAWING IS SHOWN INDICATIVELY. THE SERVICES SHOWN MAY NOT REPRESENT THE ENTIRETY OF ALL SERVICES THAT MAY BE ENCOUNTERED. ALL SOURCE INFORMATION SHOULD BE REFERRED TO PRIOR TO UNDERTAKING WORKS ON SITE. CROUCH WATERFALL ACCEPT NO RESPONSIBILITY FOR OMISSIONS OR ERRORS IN THE POSITIONING OF THE SERVICES PRESENT ON SITE. REFER TO ALL RELATED ENGINEERING DRAWINGS, FORMS AND SPECIFICATIONS FOR FURTHER INFORMATION. REFER TO THE RESIDUAL/DESIGNERS RISK ASSESSMENT FOR ACTIONS TO MINIMISE AND MITIGATE RISK ASSOCIATED WITH KNOWN AND UNKNOWN WORKS ON SITE

KEY:



PROPOSED SURFACE WATER DRAINAGE

EXISTING SURFACE WATER DRAIN

EXISTING SURFACE WATER DRAIN TO BE


EXISTING SURFACE WATER SEWER (SOUTHERN
WATER ASSET)

— PROPOSED FOUL WATER DRAINAGE

EXISTING FOUL WATER DRAIN

EXISTING FOUL WATER DRAIN TO B

EXISTING FOUL WATER SEWER (SOUTHERN
WATER ASSET)

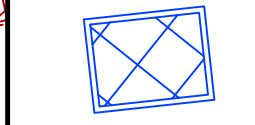

PROPOSED FILTER DRAIN WITH PERFORATED PIPE

PLANNING

A	ISSUED FOR LLFA COMMENTS	RP	RP	MGB	24/01/20
REV	AMENDMENT	DRN	CHK	APP	DATE

Crouch Waterfall
Suite 5.01
Network House
Basing View
Basingstoke
RG21 4HG

Tel 01256 479203
office@crouchwaterfall.co.uk

CLIENT

BOURNE LEISURE

PROJECT TITLE

BUTLINS BOGNOR
TEMPORARY VENUE

DRAWING TITLE

PROPOSED DRAINAGE LAYOUT SHEET 1

DRAWN RP	CHK RP	APP MGB	DATE JAN '21	SCALE 1:250 AT A1
JOB NUMBER 20074G		DRAWING NUMBER 500-P		REVISION A

