
 


SITE LOCATION

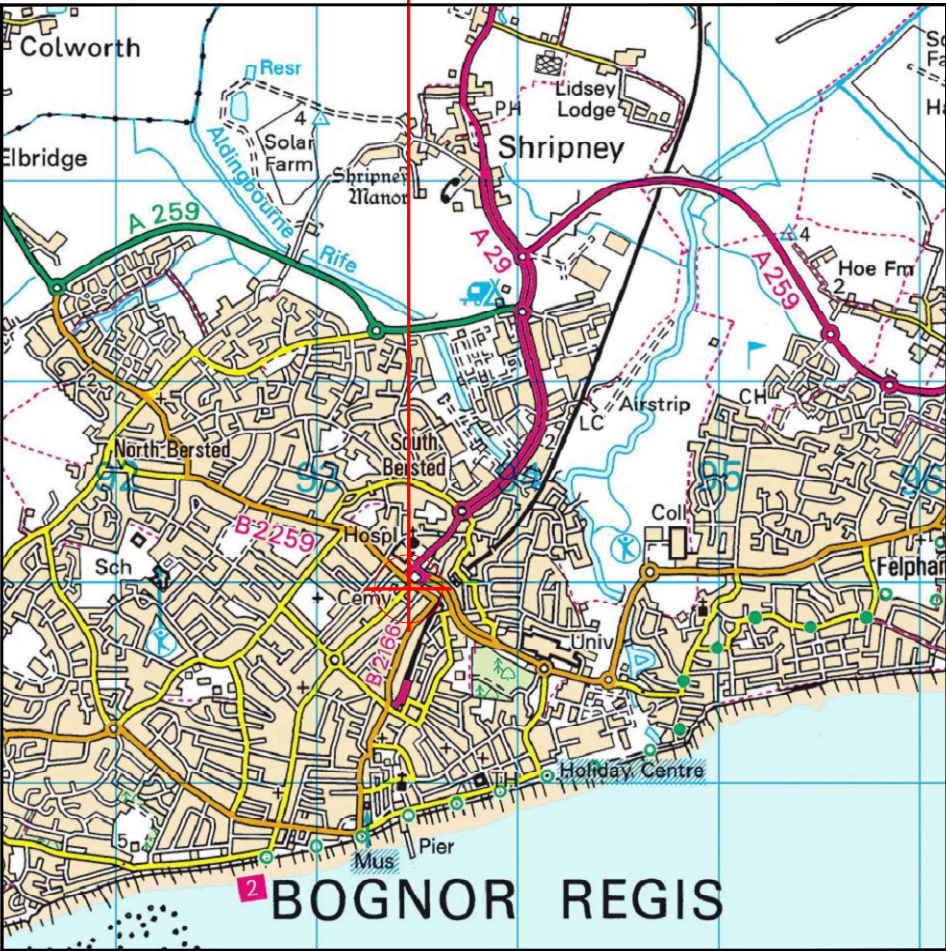


Reproduced by permission of Ordnance Survey on behalf of the Controller of Her Majesty's Stationery Office
All rights reserved. © Crown Copyright licence no.100022432

SITE AREA PLAN




SITE PHOTOGRAPH

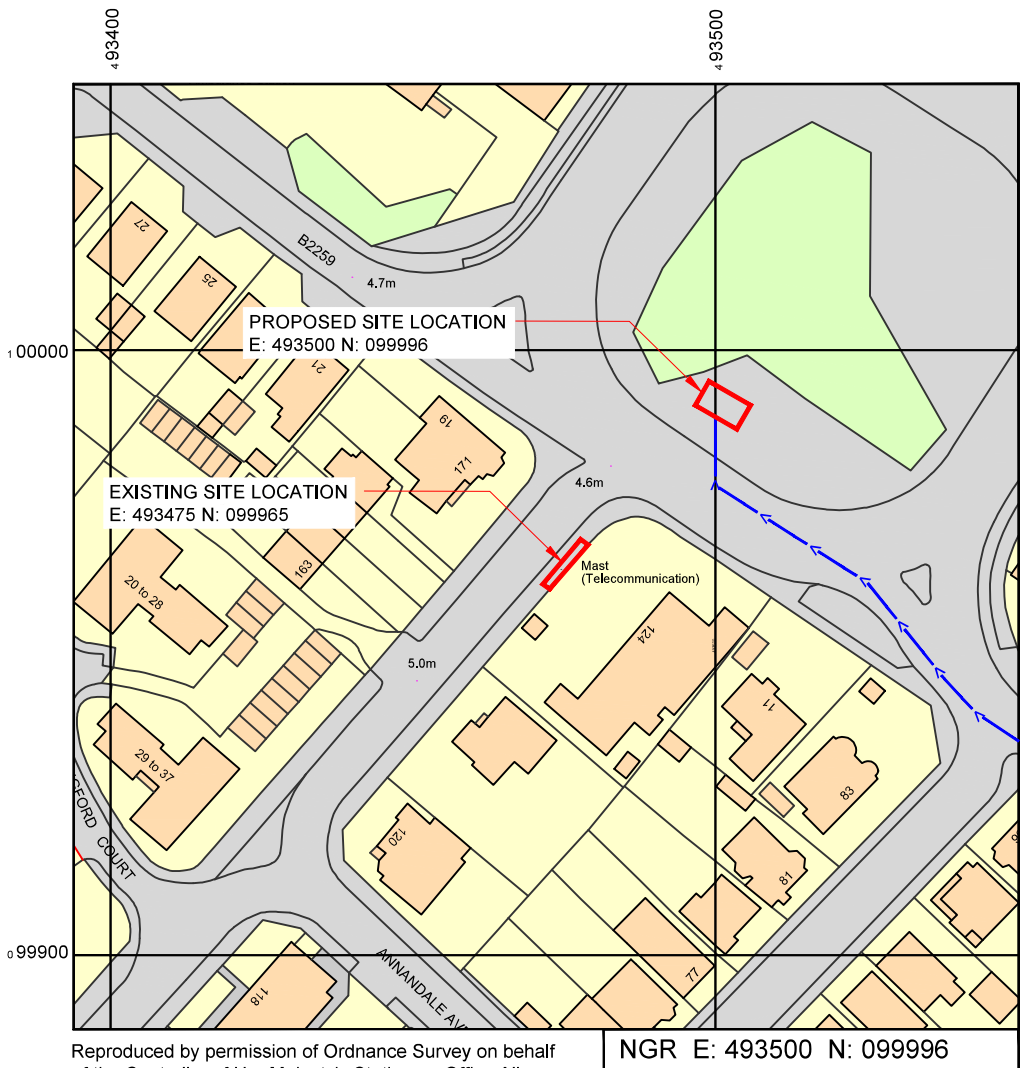

Reproduced by permission of Ordnance Survey on behalf of the Controller of Her Majesty's Stationery Office All rights reserved. © Crown Copyright licence no.100022432

NGR E: 493500 N: 099996

 SITE LOCATION PLAN



GOOGLE MAPS QR CODE

GOOGLE MAPS - [Hyperlink to map of the site](#)

GOOGLE STREETVIEW - [Hyperlink to streetview of the site](#)

NOTES:

1. ALL DIMENSIONS IN MM UNLESS OTHERWISE NOTED.

DIRECTIONS TO SITE:



Master	MBNL / EE / H3G	Project	Purpose of Issue	Issue
M006	MBNL	H3G UNILATERAL SW	Construction	D2
Date:	04/01/2021	Revision / Upgrade Description: Existing underground services revised		
Drawn:	M.Williams			
Checked:	A. Dobson			
Approved:	A. Dobson			
Master	MBNL / EE / H3G	Project	Purpose of Issue	Issue
M005	MBNL	H3G UNILATERAL SW	Construction	D1
Date:	18/12/2020	Revision / Upgrade Description: Issued for construction		
Drawn:	M.Williams			
Checked:	A. Dobson			
Approved:	A. Dobson			



Hutchison 3G UK Limited
Star House, 20 Grenfell Road
Maidenhead, SL6 1EH
Tel: 01628 785 000
Fax: 01628 785 001



Hatfield Business Park
Hatfield
Hertfordshire
AL10 9BW
Tel: 01707 315000
Fax: 01707 319001



Mobile Broadband Network Limited
Sixth Floor, Thames Tower, Station Road, Reading, RG1 1LX

Design Consultant & Principal Contractor:



Unit E, Madison Place, Northampton Road,
Manchester, M40 5AG
Tel: 0161 785 4500 Fax: 0161 785 4501
Web: www.clarke-telecom.com

Site Name:
VICTORIA ROAD/ CHICHESTER ROAD

Site ID:
1060182

Address:
VICTORIA DRIVE
CHICHESTER ROAD
BOGNOR REGIS
WEST SUSSEX
PO22 9LQ

Title:
002 SITE LOCATION PLAN

Project:
H3G UNILATERAL S.W.

Purpose of Issue:
CONSTRUCTION

EE Cell ID: 55841	MBNL Cell ID: ARN004	3UK Cell ID: PO0196
----------------------	-------------------------	------------------------

Master Drawing No: 1060182_ARN004_55841_PO0196_M006	Issue: D2
--	--------------

100mm

50mm

10mm



3G / 4G Antenna ID	Existing 3G Bearing
EA1	330°
EB1	90°
EC1	210°

NOTES:

1. ALL DIMENSIONS IN MM UNLESS OTHERWISE NOTED.

100mm

50mm

10mm

VICTORIA ROAD (30mph)
ONE WAY

ELEVATION A

EXISTING DROPPED KERB
C/W TACTILE PAVING

EXISTING 9M LAMP POST

APPROX TREE LEVEL
+8.0m AGL

EXISTING KOMODO CABINET ON CONCRETE BASE

EXISTING 17m HIGH PHASE 5 MONOPOLE ON
ROOT FOUNDATION.

EXISTING SECURE FLEXI CABINET
CONTAINING 3G EQUIPMENT, UCU'S,
TX EQUIPMENT AND DISTRIBUTION
BOARD


EXISTING 1.6M HIGH BRICK
WALL

EXISTING DORSET CABINET
CONTAINING 2G & 4G
EQUIPMENT

GROUND LEVEL ±0.00m

APPROX TREE LEVEL
+8.0m AGL

 EXISTING SITE PLAN



Hutchison 3G UK Limited
Star House, 20 Grenfell Road
Maidenhead, SL6 1EH
Tel: 01628 785 000
Fax: 01628 785 001

H3G Base Station Information Line
0845 6043000
Available 8am-6pm Monday to Friday



Hatfield Business Park
Hatfield
Hertfordshire
AL10 9BW

Tel: 01707 315000
Fax: 01707 319001



Mobile Broadband Network Limited
Sixth Floor, Thames Tower, Station Road, Reading, RG1 1LX

Design Consultant & Principal Contractor:



Unit E, Madison Place, Northampton Road,
Manchester, M40 5AG
Tel: 0161 785 4500 Fax: 0161 785 4501
Web: www.clarke-telecom.com

Site Name:
VICTORIA ROAD/ CHICHESTER ROAD

Site ID:
1060182

Address:
VICTORIA DRIVE
CHICHESTER ROAD
BOGNOR REGIS
WEST SUSSEX
PO22 9LQ

Title:
100 EXISTING SITE PLAN

Project:
H3G UNILATERAL S.W.


Purpose of Issue:
CONSTRUCTION

EE Cell ID: 55841	MBNL Cell ID: ARN004	3UK Cell ID: PO0196
----------------------	-------------------------	------------------------

Master Drawing No: 1060182_ARN004_55841_PO0196_M006	Issue: D2
--	--------------

3G / 4G Antenna ID	Existing 3G Bearing
EA1	330°
EB1	90°
EC1	210°

- NOTES:
- ALL DIMENSIONS IN MM UNLESS OTHERWISE NOTED.

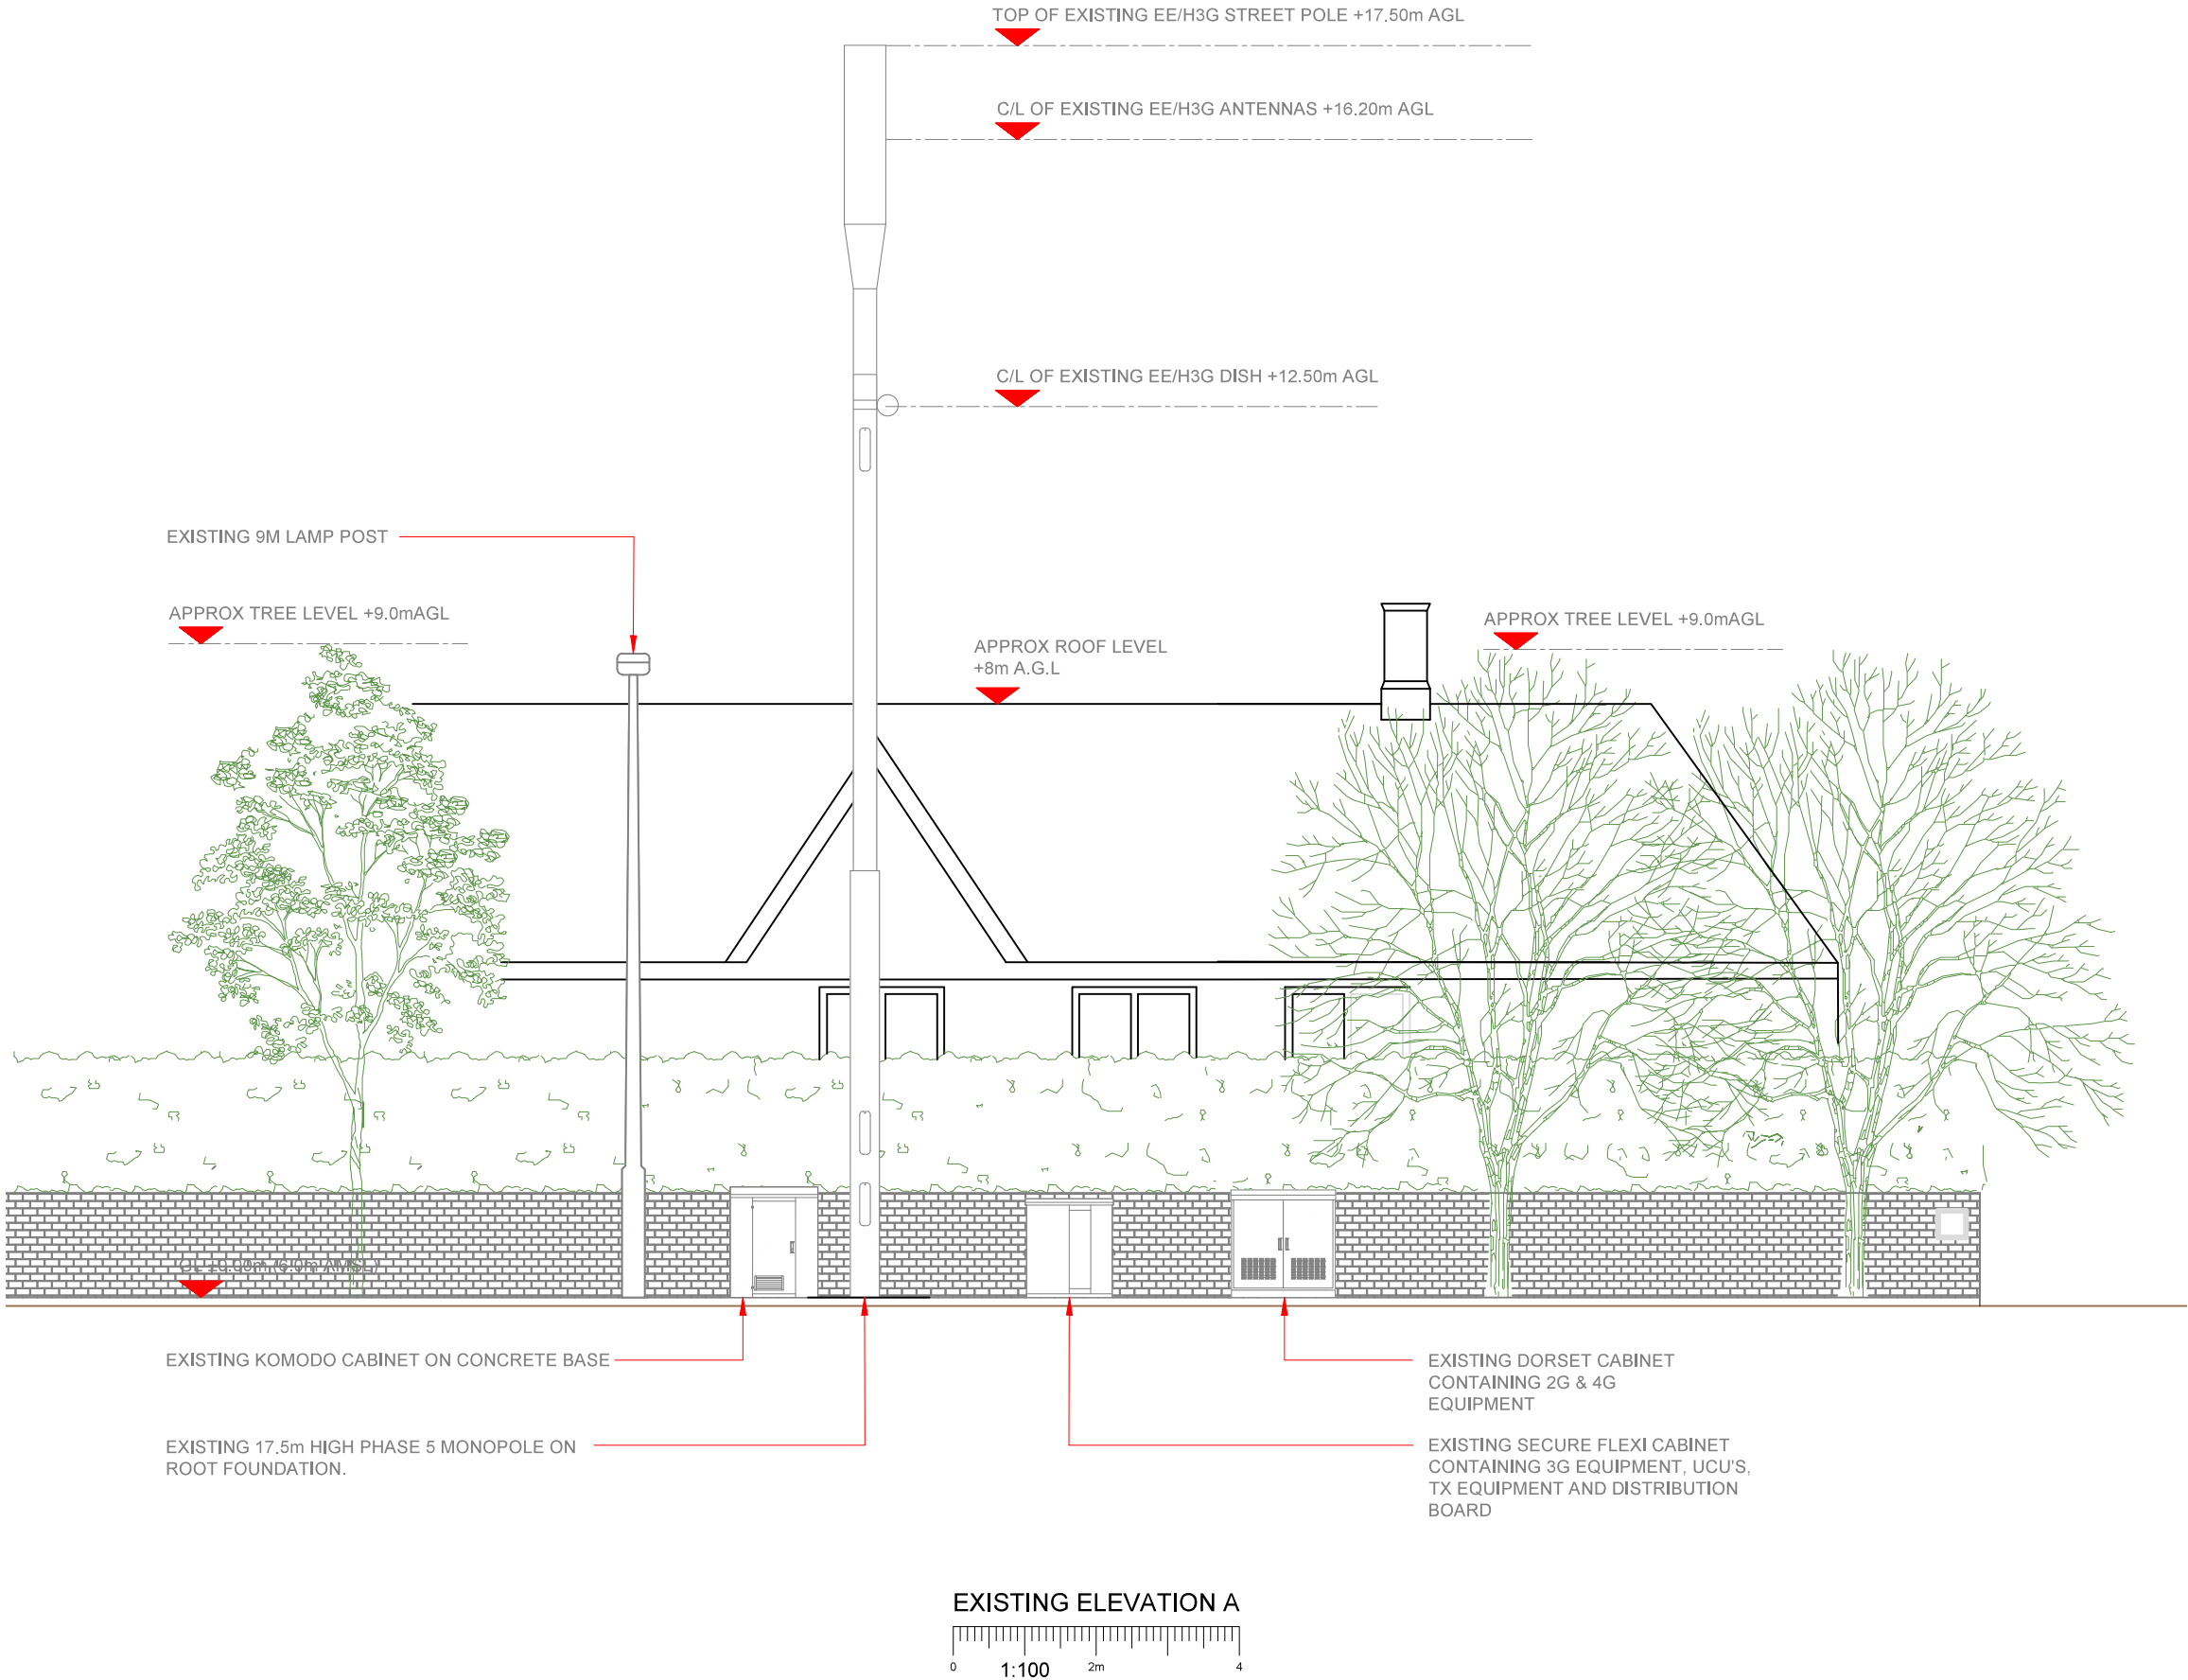

Hutchison 3G UK Limited
Star House, 20 Grenfell Road
Maidenhead, SL6 1EH
Tel: 01628 785 000
Fax: 01628 785 001
H3G Base Station Information Line
0845 6043000
Available 8am-6pm Monday to Friday



Hatfield Business Park
Hatfield
Hertfordshire
AL10 9BW
Tel: 01707 315000
Fax: 01707 319001



Mobile Broadband Network Limited
Sixth Floor, Thames Tower, Station Road, Reading, RG1 1LX

Design Consultant & Principal Contractor:



Site Name:
VICTORIA ROAD/ CHICHESTER ROAD

Site ID:
1060182

Address:
**VICTORIA DRIVE
CHICHESTER ROAD
BOGNOR REGIS
WEST SUSSEX
PO22 9LQ**

Title:
150 EXISTING ELEVATION A

Project:
H3G UNILATERAL S.W.

Purpose of Issue:
CONSTRUCTION

EE Cell ID: 55841	MBNL Cell ID: ARN004	3UK Cell ID: PO0196
-----------------------------	--------------------------------	-------------------------------


Master Drawing No: 1060182_ARN004_55841_PO0196_M006	Issue: D2
---	---------------------




Antenna Aperture ID	Proposed 4G/5G Bearing	Operator: Shared/ EE/H3G
A1	330°	H3G
A2	330°	H3G/EE
B1	90°	H3G
B2	90°	H3G/EE
C1	210°	H3G
C2	210°	H3G/EE

NOTES:

1. ALL DIMENSIONS IN MM UNLESS OTHERWISE NOTED.

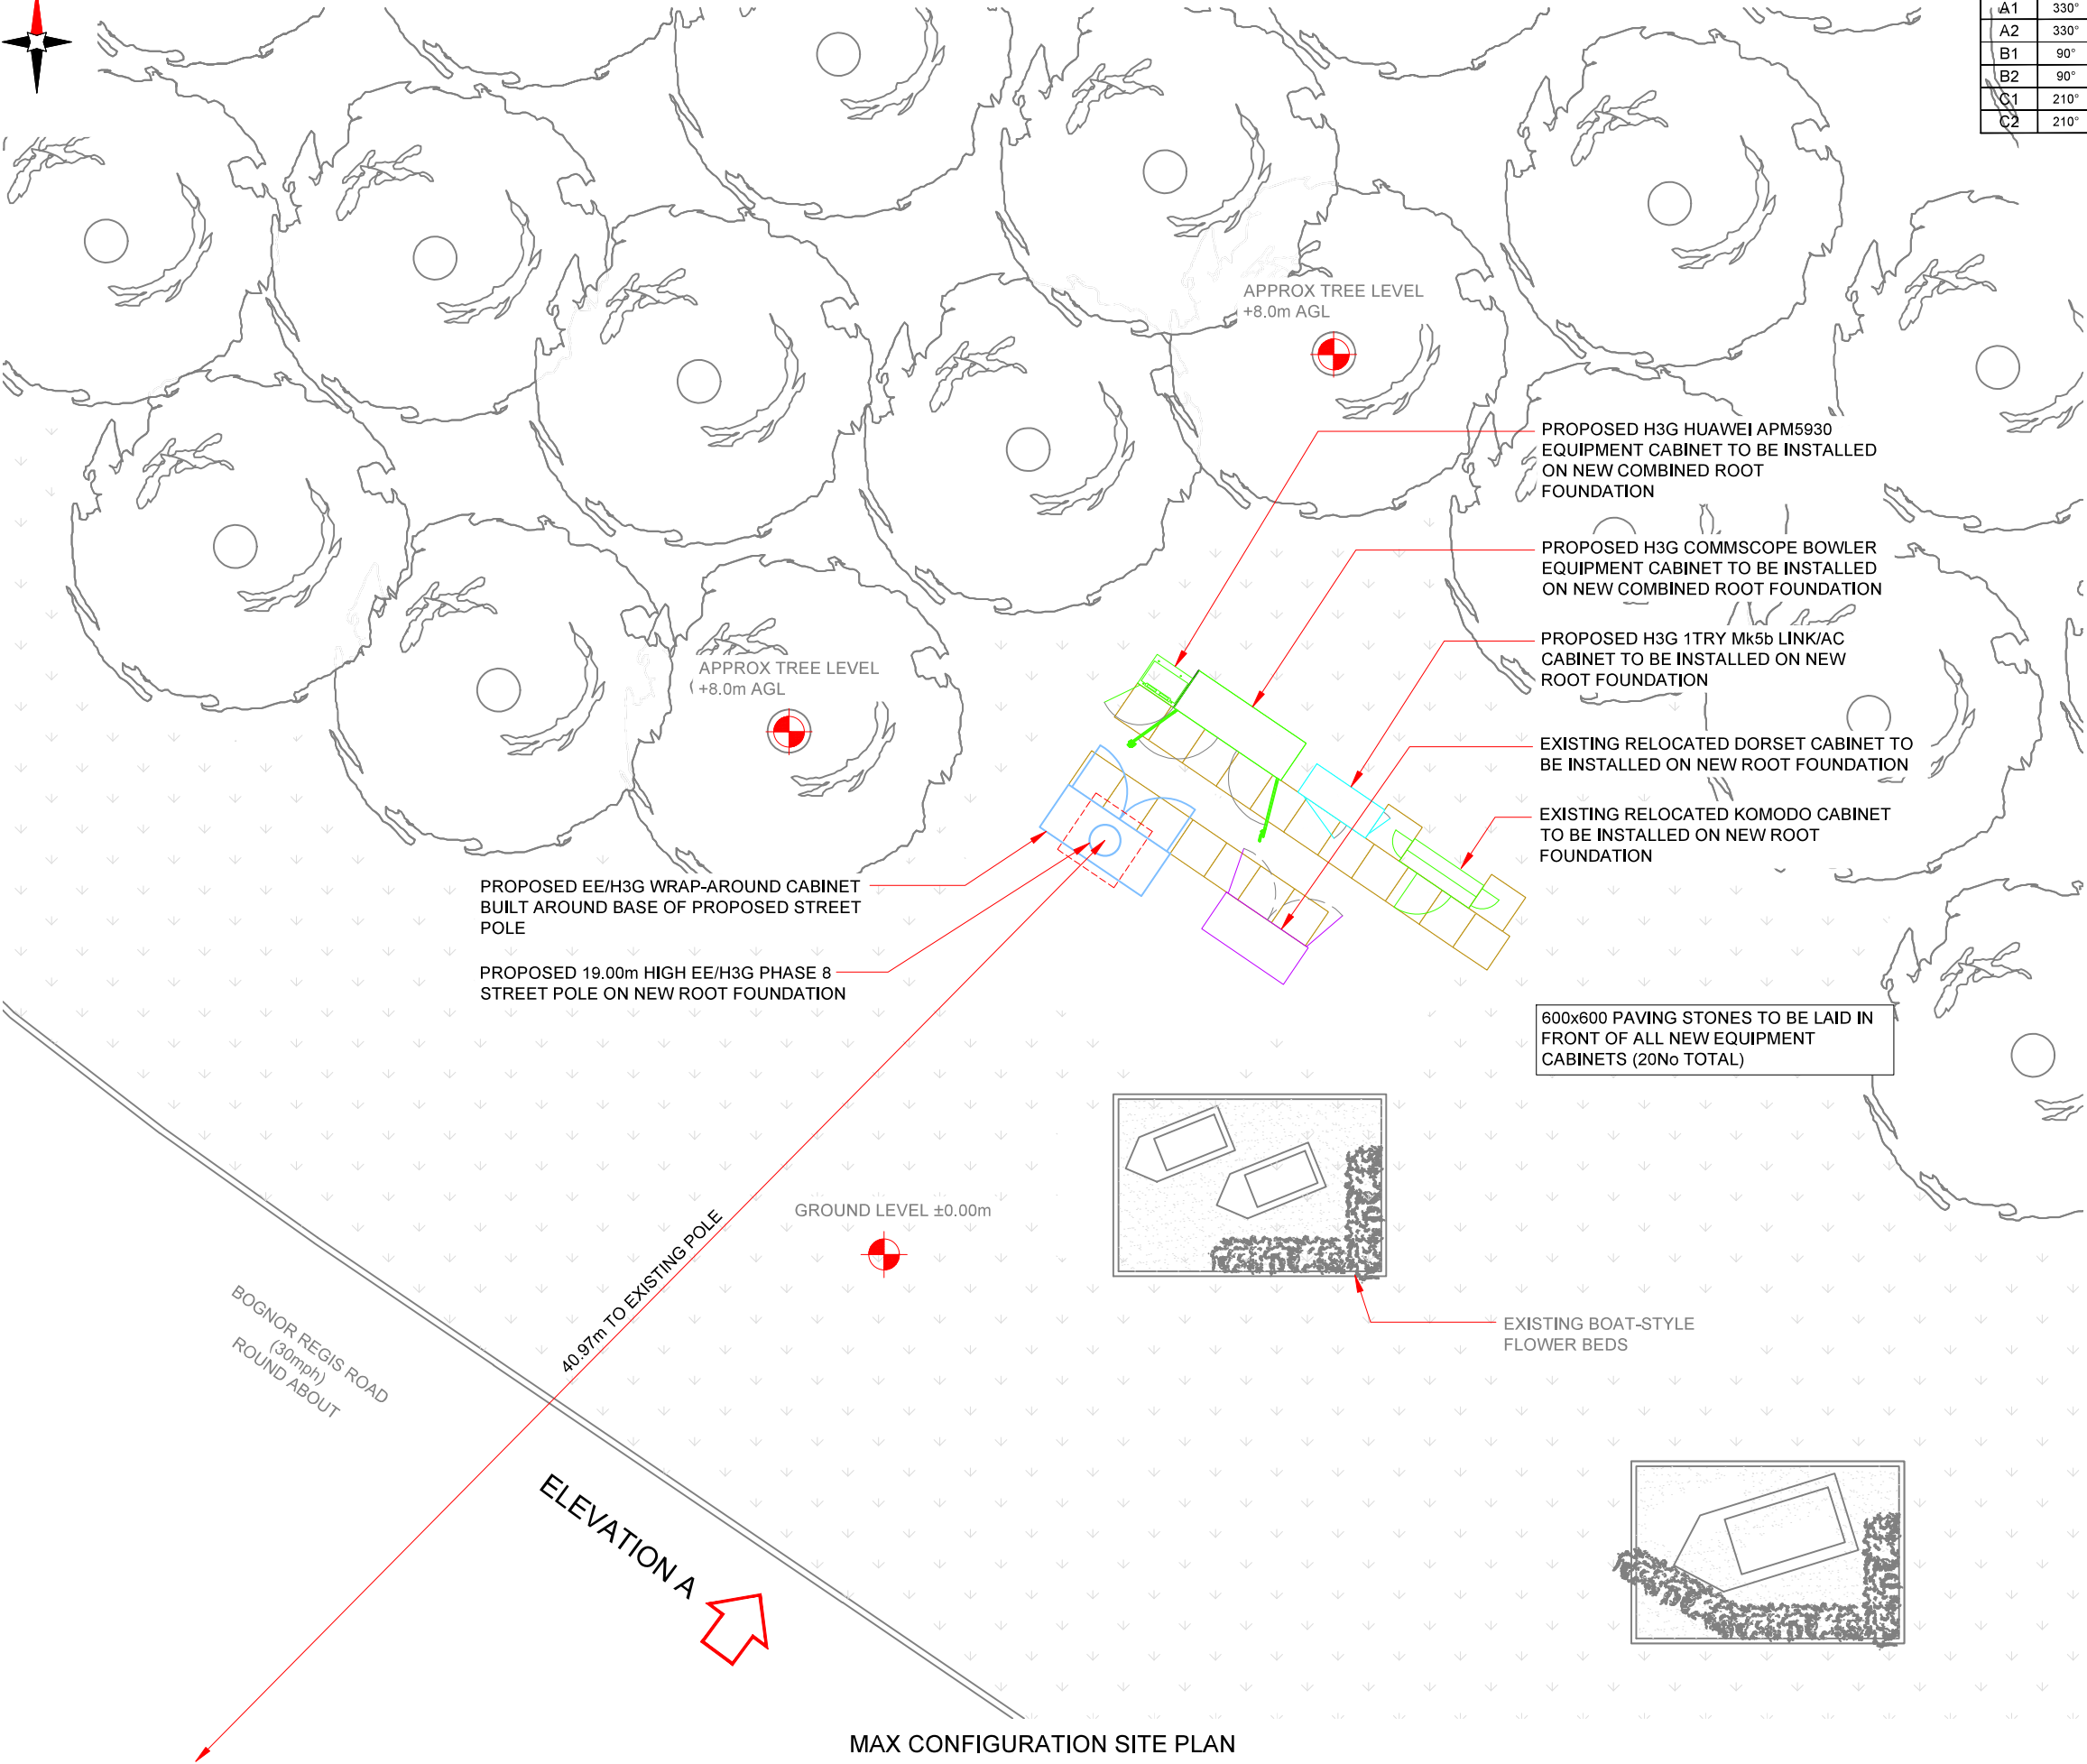

MAX CONFIGURATION SITE PLAN

 

Master:	MBNL / EE / H3G	Project:	H3G UNILATERAL SW	Purpose of Issue:	Construction	Issue:	D2
M006	MBNL	Revision / Upgrade Description:					
Date:	04/01/2021	Existing underground services revised					
Drawn:	M.Williams						
Checked:	A. Dobson						
Approved:	A. Dobson						
Master:	MBNL / EE / H3G	Project:	H3G UNILATERAL SW	Purpose of Issue:	Construction	Issue:	D1
M005	MBNL	Revision / Upgrade Description:					
Date:	18/12/2020	Issued for construction					
Drawn:	M.Williams						
Checked:	A. Dobson						
Approved:	A. Dobson						



Hutchison 3G UK Limited
Star House, 20 Grenfell Road
Maidenhead, SL6 1EH
Tel: 01628 765 000
Fax: 01628 765 001



Hatfield Business Park
Hatfield
Hertfordshire
AL10 9BW
Tel: 01707 315000
Fax: 01707 319001



Mobile Broadband Network Limited
Sixth Floor, Thames Tower, Station Road, Reading, RG1 1LX

Design Consultant & Principal Contractor:



Unit E, Madison Place, Northampton Road,
Manchester, M40 5AG
Tel: 0161 785 4500 Fax: 0161 785 4501
Web: www.clarke-telecom.com

Site Name:
VICTORIA ROAD/ CHICHESTER ROAD

Site ID:
1060182

Address:
VICTORIA DRIVE
CHICHESTER ROAD
BOGNOR REGIS
WEST SUSSEX
PO22 9LQ

Title:
215 MAX CONFIGURATION SITE PLAN

Project:
H3G UNILATERAL S.W.


Purpose of Issue:
CONSTRUCTION

EE Cell ID: 55841	MBNL Cell ID: ARN004	3UK Cell ID: PO0196
Master Drawing No: 1060182_ARN004_55841_PO0196_M006		Issue: D2

100mm

50mm

10mm

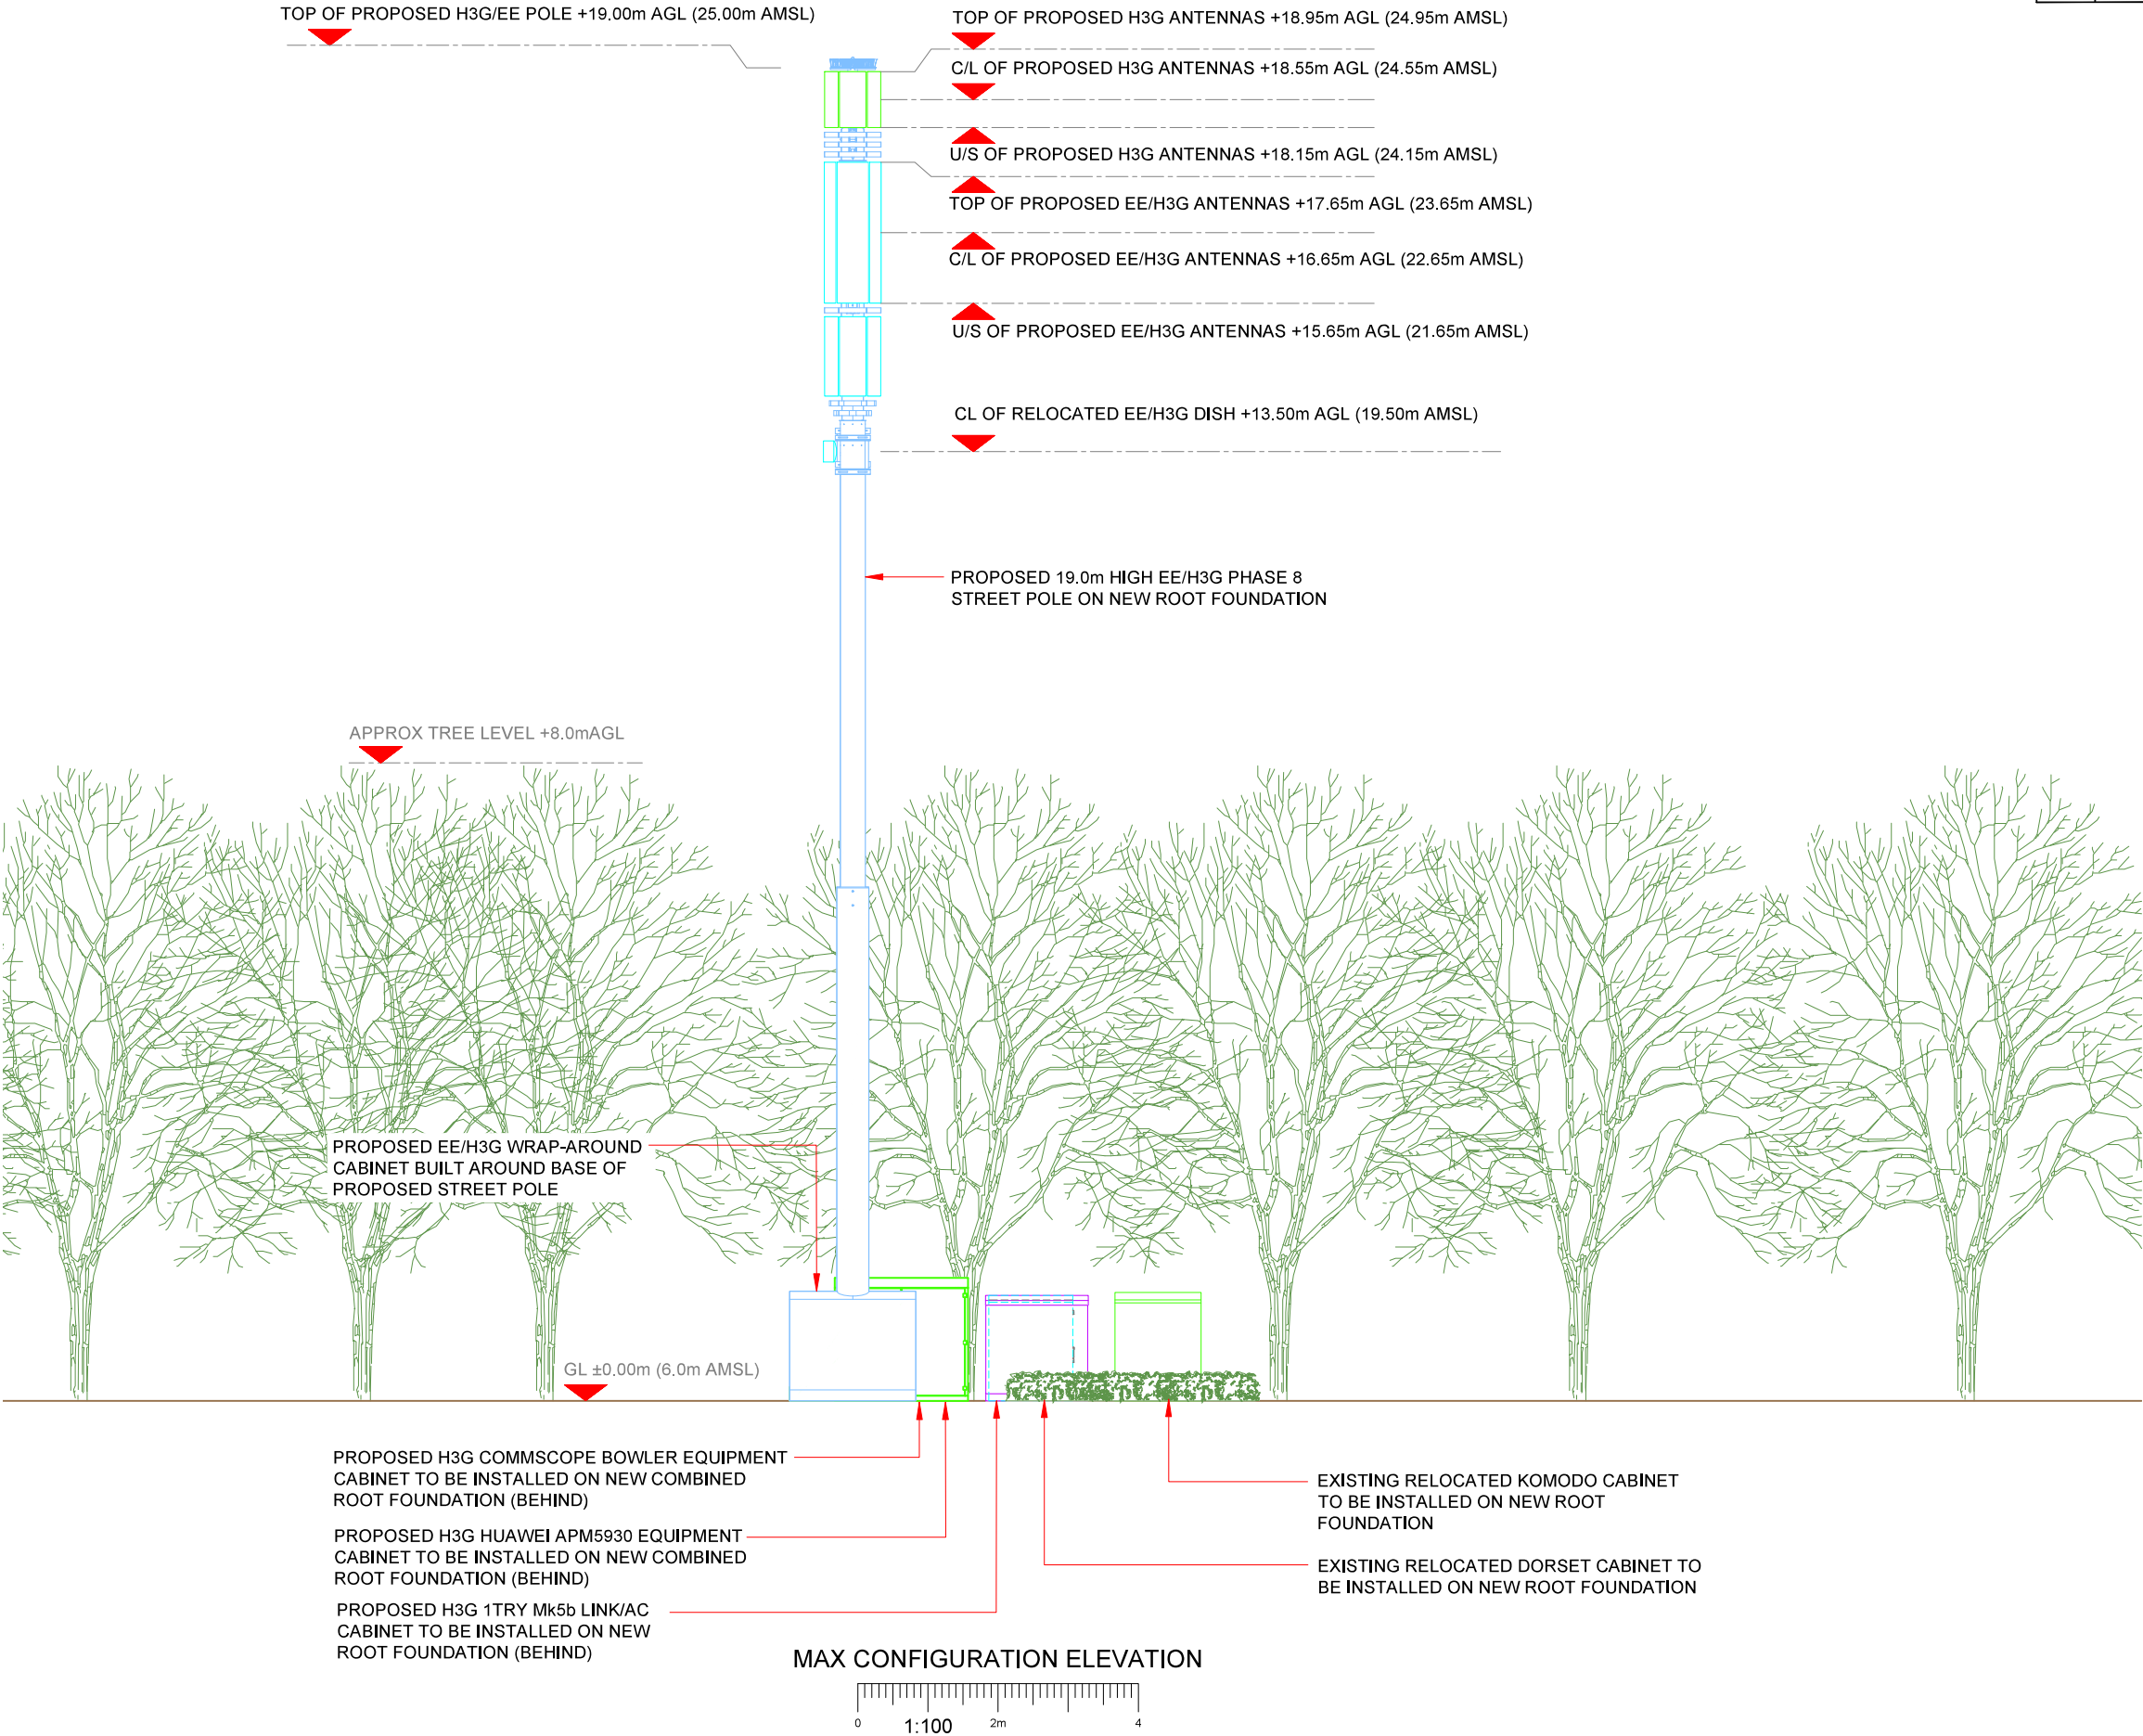

Antenna Aperture ID	Proposed 4G/5G Bearing	Operator: Shared/ EE/H3G
A1	330°	H3G
A2	330°	H3G/EE
B1	90°	H3G
B2	90°	H3G/EE
C1	210°	H3G
C2	210°	H3G/EE

NOTES:

1. ALL DIMENSIONS IN MM UNLESS OTHERWISE NOTED.

Master:	MBNL / EE / H3G	Project:	Purpose of Issue:	Issue:
M006	MBNL	H3G UNILATERAL SW	Construction	D2
Date:	04/01/2021	Revision / Upgrade Description:		
Drawn:	M.Williams	Existing underground services revised		
Checked:	A. Dobson			
Approved:	A. Dobson			
Master:	MBNL / EE / H3G	Project:	Purpose of Issue:	Issue:
M005	MBNL	H3G UNILATERAL SW	Construction	D1
Date:	18/12/2020	Revision / Upgrade Description:		
Drawn:	M.Williams	Issued for construction		
Checked:	A. Dobson			
Approved:	A. Dobson			



Hutchison 3G UK Limited
Star House, 20 Grenfell Road
Maidenhead, SL6 1EH
Tel: 01628 785 000
Fax: 01628 785 001



Hatfield Business Park
Hatfield
Hertfordshire
AL10 9BW
Tel: 01707 315000
Fax: 01707 319001



Mobile Broadband Network Limited
Sixth Floor, Thames Tower, Station Road, Reading, RG1 1LX

Design Consultant & Principal Contractor:

CLARKE telecom

Unit E, Madison Place, Northampton Road,
Manchester, M40 5AG
Tel: 0161 785 4500 Fax: 0161 785 4501
Web: www.clarke-telecom.com

Site Name:
VICTORIA ROAD/ CHICHESTER ROAD

Site ID:
1060182

Address:
**VICTORIA DRIVE
CHICHESTER ROAD
BOGNOR REGIS
WEST SUSSEX
PO22 9LQ**

Title:
265 MAX CONFIGURATION ELEVATION

Project:
H3G UNILATERAL S.W.

Purpose of Issue:
CONSTRUCTION

EE Cell ID: 55841	MBNL Cell ID: ARN004	3UK Cell ID: PO0196
-----------------------------	--------------------------------	-------------------------------

Master Drawing No: 1060182_ARN004_55841_PO0196_M006	Issue: D2
---	---------------------