
 


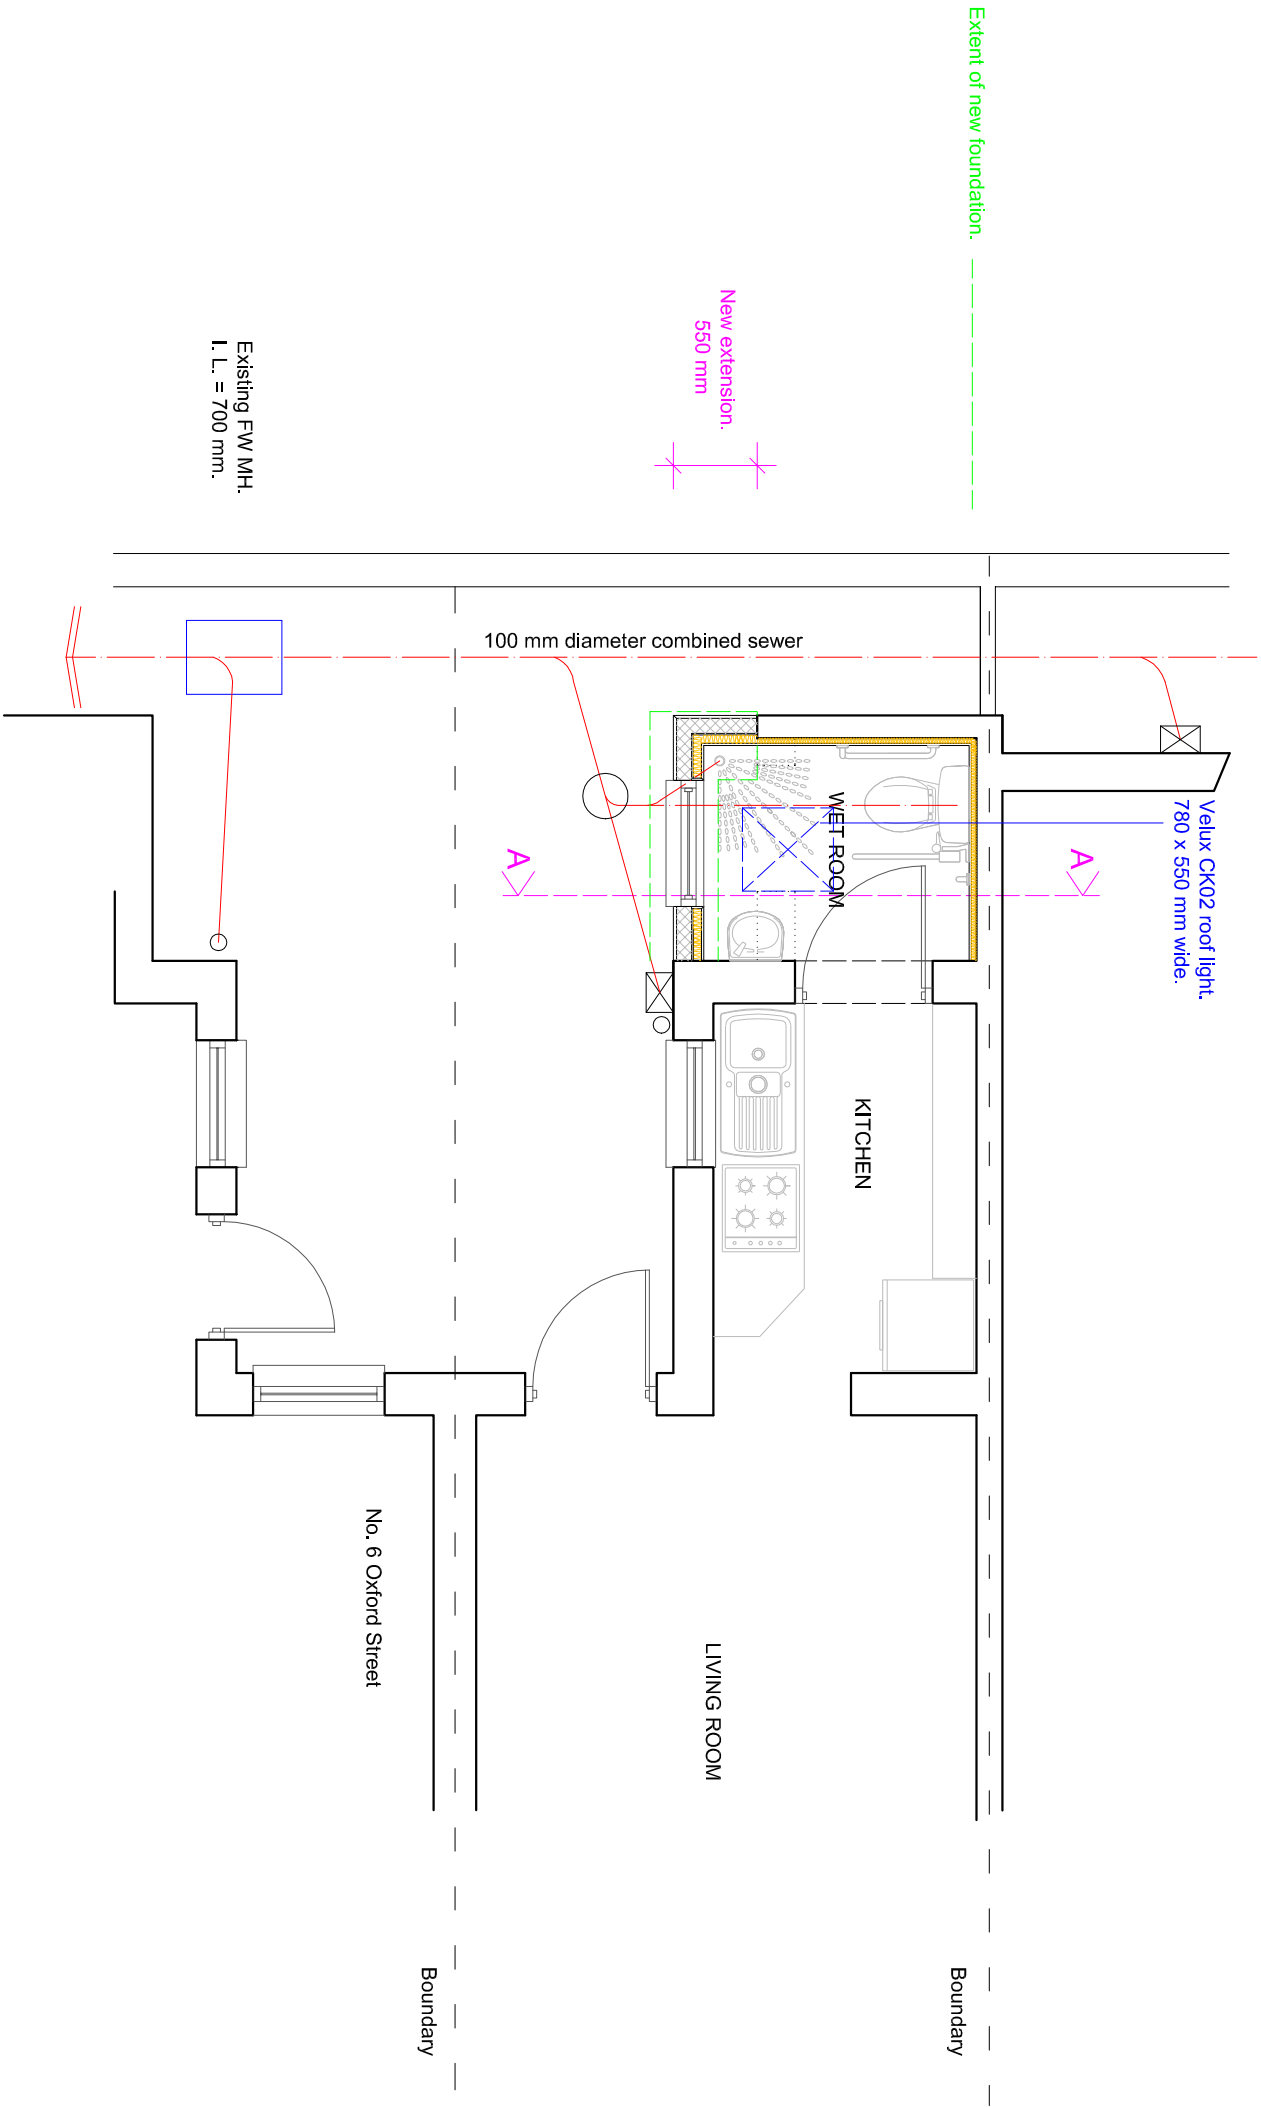

PROPOSED GROUND FLOOR PLAN



Note that the plotted foul water drain runs are taken from limited survey access - the exact position and direction of run of the drains are to be determined on site by the contractor prior to commencement of works and agreed with Building Control and if necessary, SWS themselves.

Scale 1:50 on A3

SUSSEX BUILDING CONSULTANCY LIMITED	
5 OXFORD STREET, BOGNOR REGIS, WEST SUSSEX.	partner LABC
SCALE - 1/50 REV - A DATE - 04/01/2022	3 NORTHCOTE ROAD BOGNOR REGIS PO21 9LZ TEL/FAX - (01243) 861379