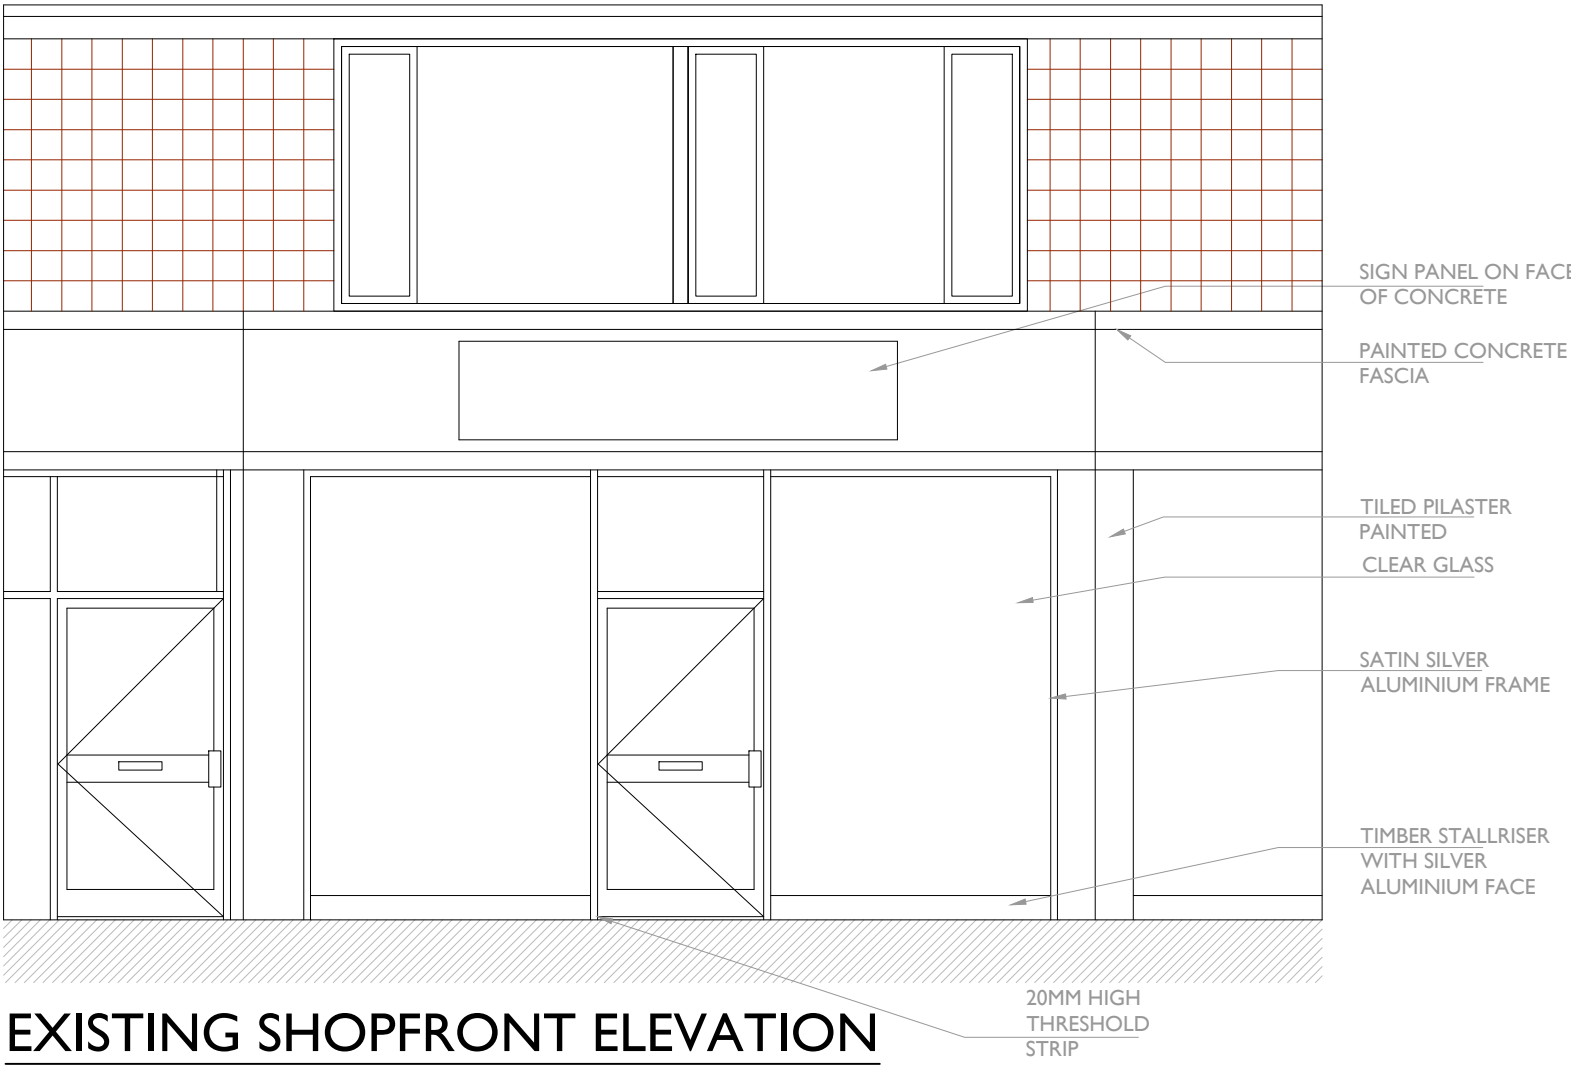




EXISTING SHOPFRONT ELEVATION

CeX Ltd

11 Northburgh Street, London EC1V OAH

e-mail: cexdesign@webuy.com

Contractors must verify all dimensions on site before commencing work. Only work to given dimensions DO NOT SCALE DRAWINGS. The copyright of this drawing is reserved and the drawing must not be disclosed without the authority of CeX Ltd.

Notes

EXISTING CONDITION

Revision

Info.

FLOOR AREAS:

Existing

EXISTING GROUND FLOOR -70.00m²

Proposed

RETAIL GROUND FLOOR - 00m²

SUSPENDED CEILING AREA:

GROUND FLOOR - 00m²

GROUND FLOOR - 00m²

SLAT WALL PERIMETER LENGTH:

GROUND FLOOR - 00m²

GROUND FLOOR - 00m²

VINYL FLOOR AREA:

GROUND FLOOR - 00m²

GROUND FLOOR - 00m²

Store Name

CeX-Bognor Regis

Address:

3 Water Tower Buildings, London Road,
Bognor Regis, PO21 1PN

Drawing Title:

EXISTING FRONT ELEVATION

Scale:

1:50 @A1

Drawn:

AS

Date:

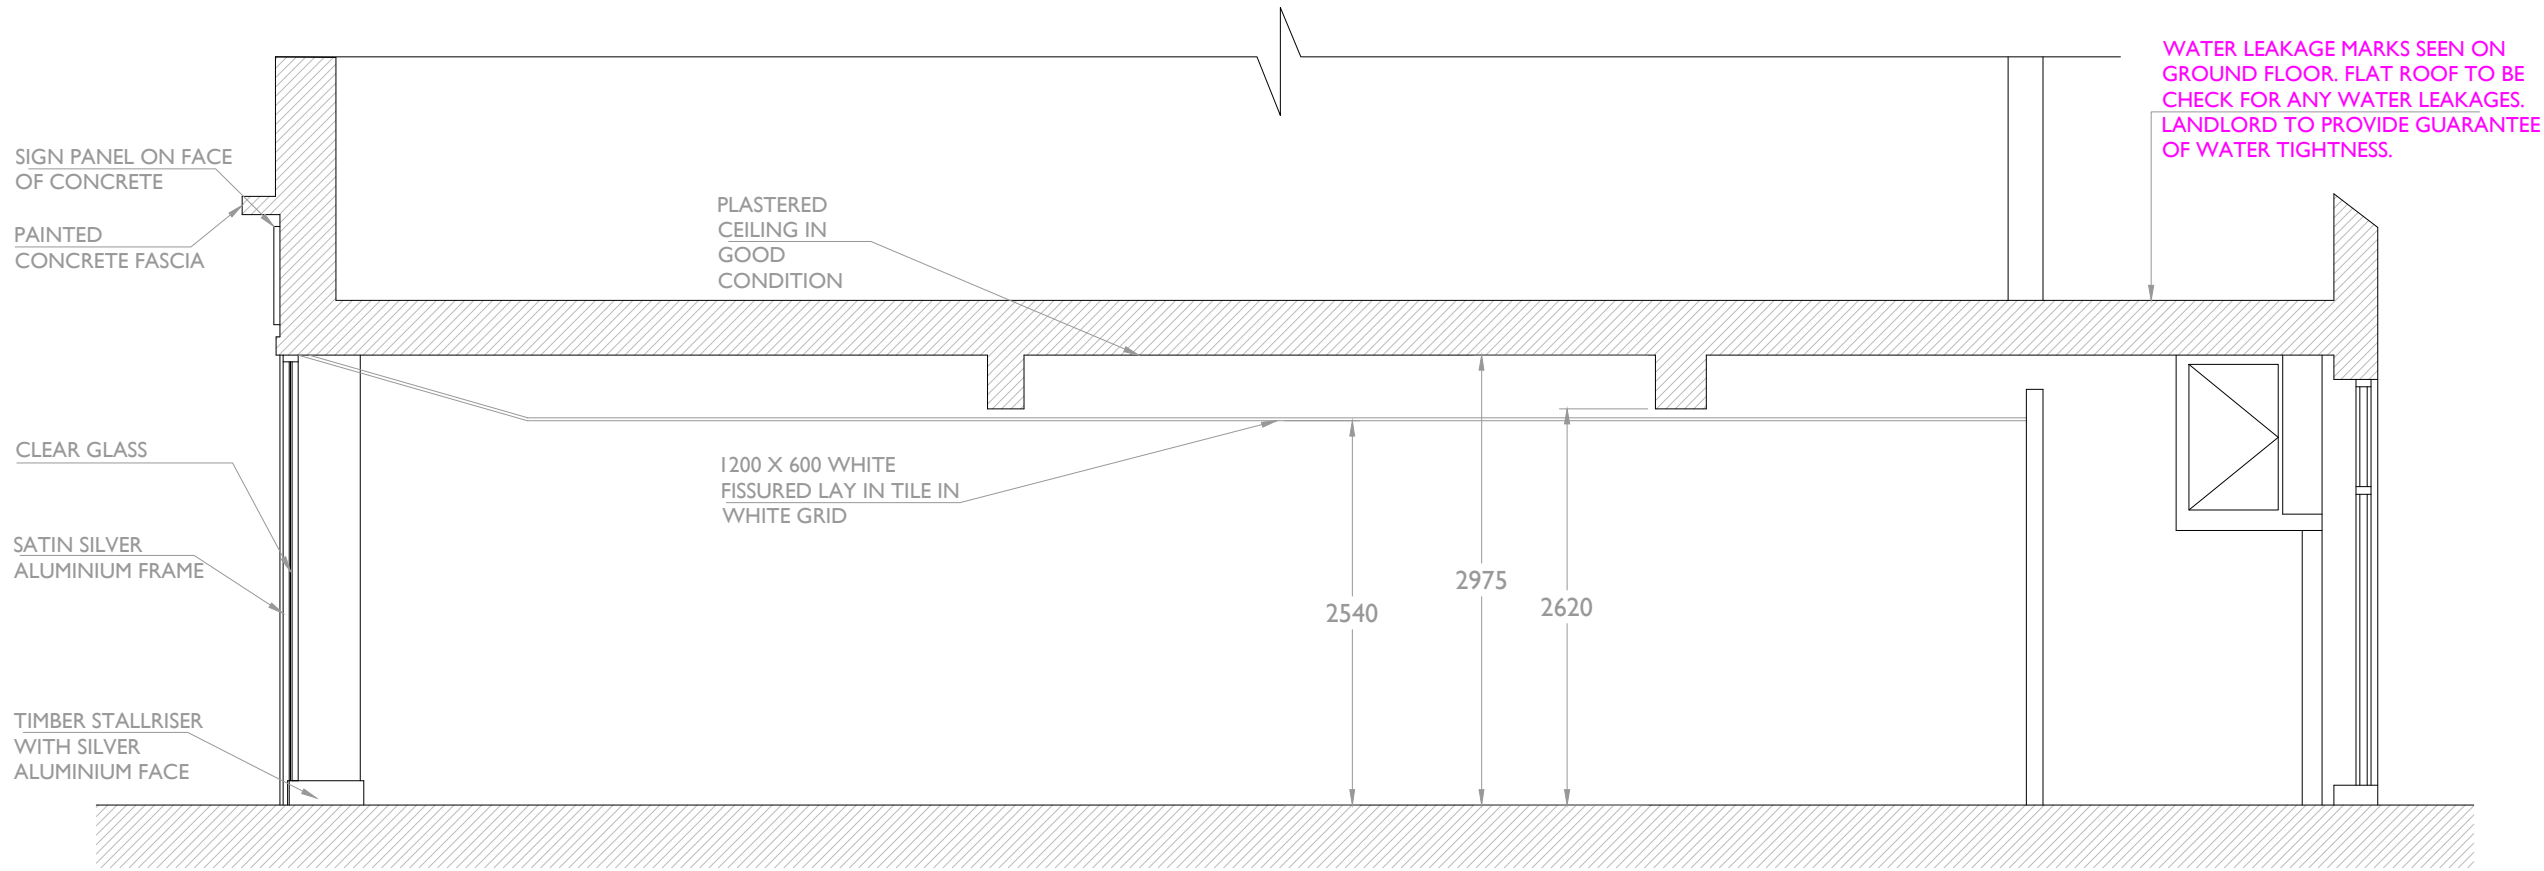
14-10-07

Drawing No.:


CeX-BOG-01

Revision:

-



EXISTING SECTION A-A

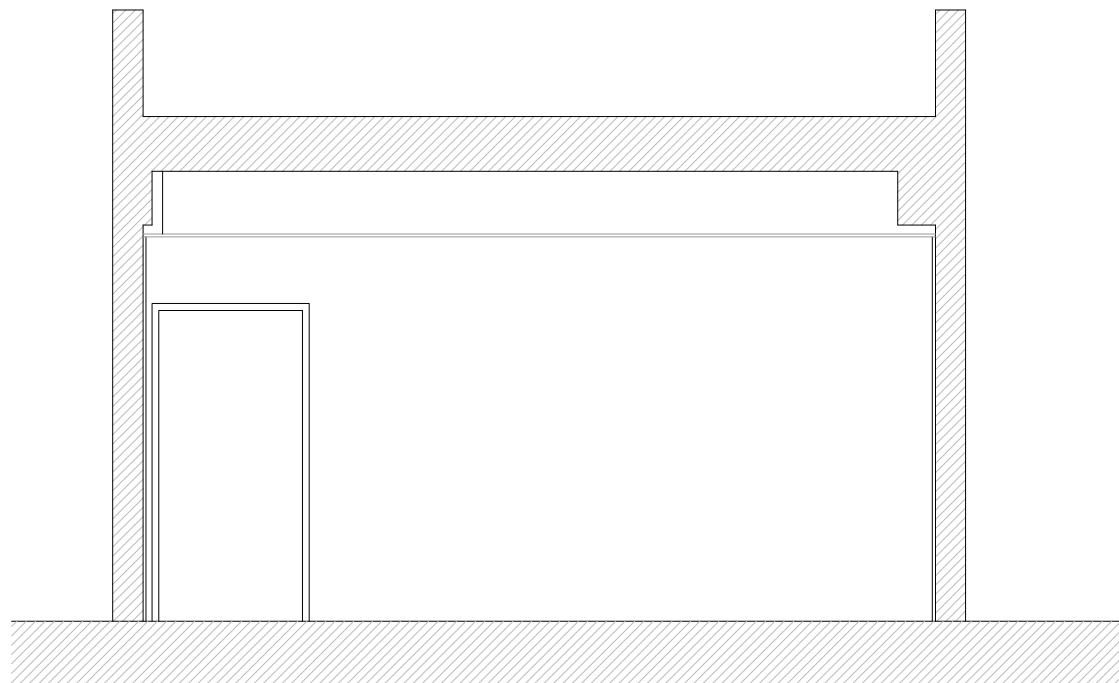

EXISTING SECTION B-B

CeX Ltd

11 Northburgh Street, London EC1V OAH
e-mail: cexdesign@webuy.com

Contractors must verify all dimensions on site before commencing work. Only work to given dimensions DO NOT SCALE DRAWINGS. The copyright of this drawing is reserved and the drawing must not be disclosed without the authority of CeX Ltd.

Notes

EXISTING CONDITION

Revision

Info.

FLOOR AREAS:

Existing

EXISTING GROUND FLOOR - 70.00m²

Proposed

RETAIL GROUND FLOOR - 00m²

Store Name

CeX-Bognor Regis

Address:

3 Water Tower Buildings, London Road,
Bognor Regis, PO21 1PN

Drawing Title:

EXISTING SECTION AT A-A & B-B

Scale:

1:50 @A1

Drawn:

AS

Date:

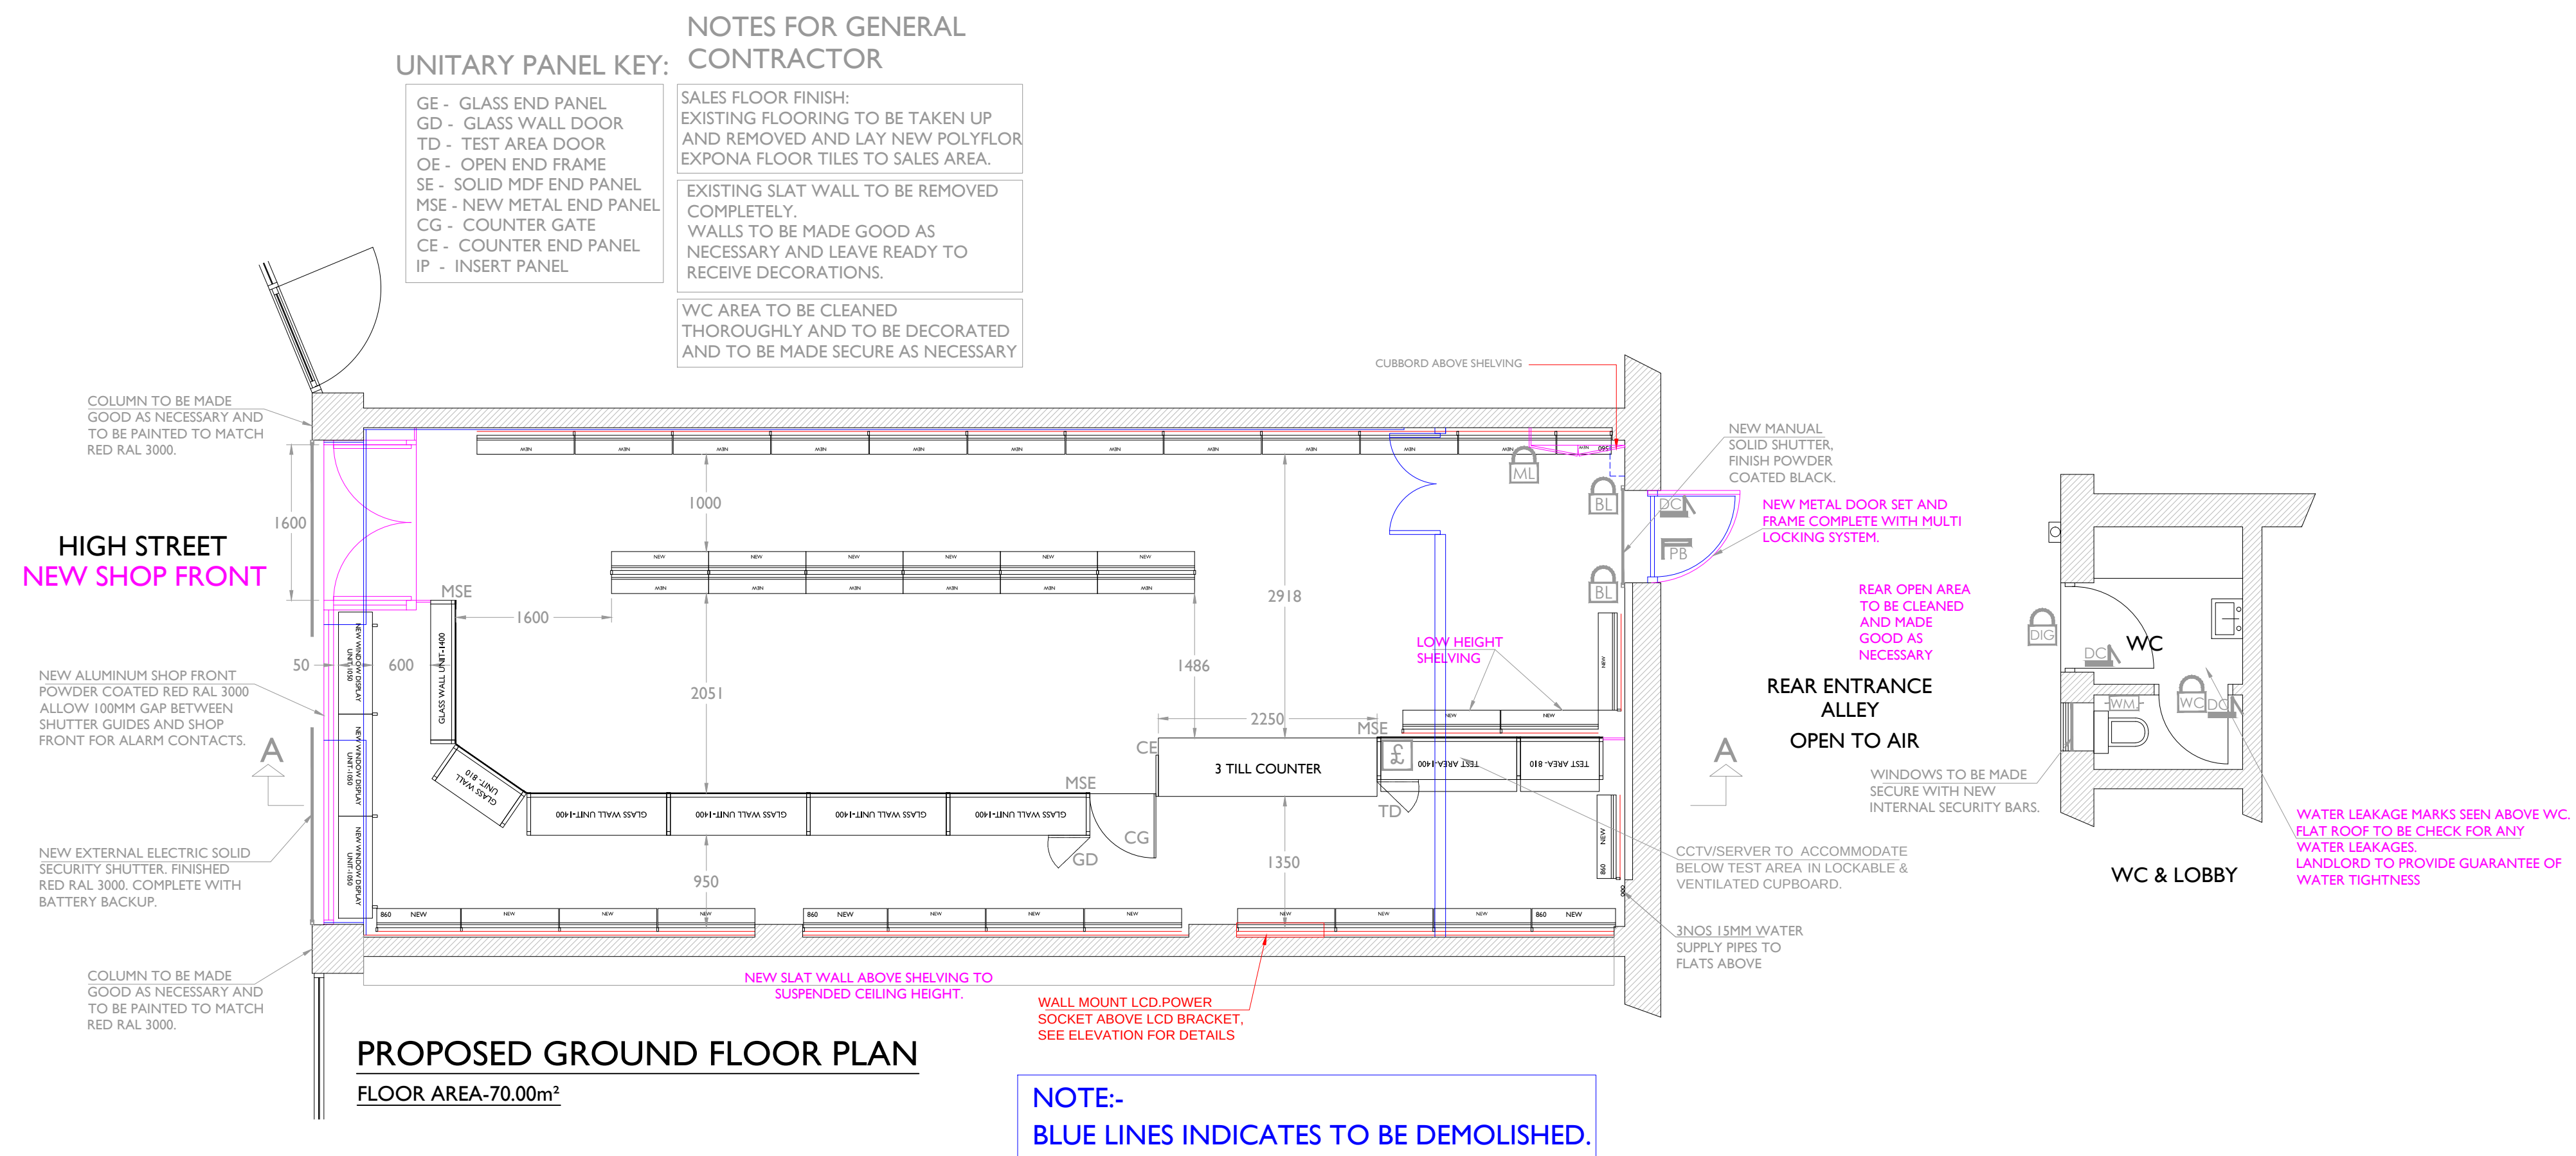
14-10-07

 
 
 
 
 
 
 
 
 
 
 
 
 
 
 
 
 
 
Drawing No.:

CeX-BOG-02

Revision:

-




AIR CONDITIONING KEY		FIRE PRECAUTIONS KEY		LIGHTING KEY		ELECTRICAL KEY		SECURITY KEY		UTILITIES KEY	
	Heated Door Curtain		Fire Alarm-Control Panel		Dextra Asymmetric RAXT 1232 x 55 HF LUMIN 1180x295x100 2x Osram TRI 840, 55W / 4000K		Electric Meter		Intruder Alarm Key/Fob Panel		Gas Meter
	Thermostat-Aircon		Fire Alarm-Break Glass Point		Dextra Asymmetric RAXT 631 x 55 HF LUMIN 580x295x100 1x Osram TRI 840, 55W / 4000K		Consumer Unit/Fuse box		Intruder Alarm-Internal bell/sounder		Water Meter
	Control Panel-Aircon		Smoke Detector				RCD-Residual Current Device		Intruder Alarm-External bell/sounder		
	Ceiling Mounted Heat Exchange Inverter Air Conditioning Cassette Unit		Fire Alarm bell/sounder		1200x600x100 LED LIGHTING Specification to be Agreed.		Unswitched Fused Spur		Ground Bolt		
	External Condenser		Non-Maintained Emergency Surface Light Fitting				Single Outlet		Bullet Lock		
			Emergency Escape Route Sign		600x600x100 LED LIGHTING Specification to be Agreed.		Double Outlet		Double Outlet Clean Supply Counter/Server		Digital lock
			Final Fire Exit Sign				Dedicated Outlet		Single Light Switch		Magi lock
			Extinguisher-Foam, 6 Litres		Recessed 42W PL downlighter		Double Light Switch		Last Man Out switch		Mortise Lock
			Extinguisher-CO2, 2 Kilograms		Tamlite TMH 2455 x 70W HQI SPOTLIGHT		Doorbell Push Button		Electric Extractor Fan		WC Lock
			SPRINKLER		Spotlight-7W-LED		Electric Water Heater		Incoming Data Point		Overhead Door Closer
					Fluorescent Light Fitting, 1500mm, 58W		Double Data Point		Speaker-arrow showing direction		Safe
					Hacel Altimo - 1505 X 502 3 X 80W - 4000K		Hi-Fi & Amplifier		CCTV Flat Scren Door Monitor		
					Compton 1200 X 300 4 X 80W PLL - 4000K				CCTV camera-arrow showing direction		
					Twin T5 Fluorescent fitting with Reflector				Smoke Bandit		

CAMERA LOCATION, SMOKE BANDIT AND SECURITY ISSUES ON GROUND FLOOR SUBJECT TO SAM MILLEN'S APPROVAL.
EXISTING CEILING GRID TO REMAIN & TO BE EXTENDED AS NECESSARY. INCLUDE FOR NEW TILES THROUGHOUT.
AC CONDENSER LOCATION TO BE CONFIRMED.
NEW RECESSED LED LIGHTING.



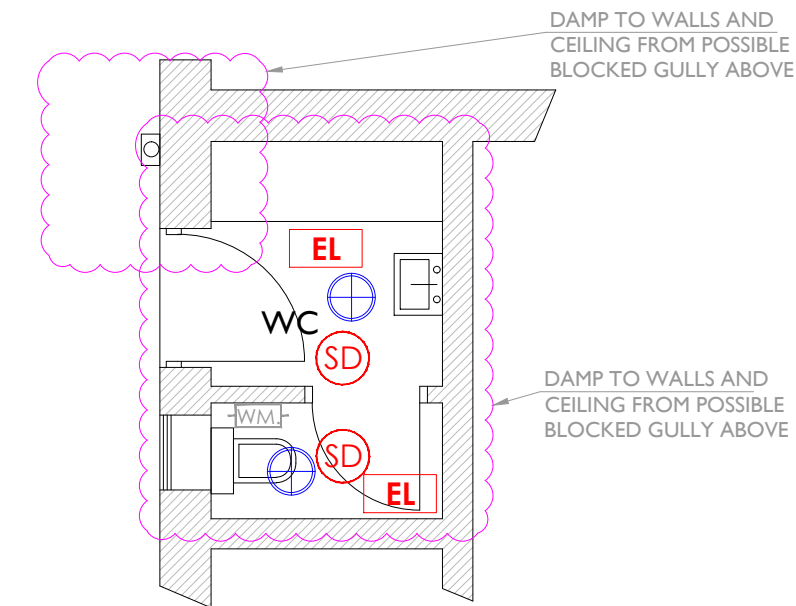FLOOR AREA-70.00m²



WC & LOBBY

	Heated Door Curtain
	Thermostat-Aircon
	Control Panel-Aircon
	Ceiling Mounted Heat Exchange Inverter Air Conditioning Cassette Unit
	External Condenser

	Fire Alarm-Control Panel
	Fire Alarm-Break Glass Point
	Smoke Detector
	Fire Alarm bell/sounder
	Non-Maintained Emergency Surface Light Fitting
	Emergency Escape Route Sign
	Final Fire Exit Sign
	Extinguisher-Foam, 6 Litres
	Extinguisher-CO2, 2 Kilograms
	SPRINKLER

S = SURFACE FITTING

 Dextra Asymmetric
RAXT 1232 x 55 HF LUMIN
1180x295x100 2x Osram TRI 840, 55W / 4000K

 Dextra Asymmetric
RAXT 631 x 55 HF LUMIN
580x295x100 1x Osram TRI 840, 55W / 4000K

 1200x600x100 LED LIGHTING
Specification to be Agreed.

 600x600x100 LED LIGHTING
Specification to be Agreed.

 Recessed 42W PL downlighter

 Pendant fitting, twin 42W PL

 Tamlite TMH 2455 x 70W HQI SPOTLIGHT

 Spotlight-7W-LED

 Fluorescent Light Fitting, 1500mm, 58W

 Hacel Altimo - 1505 X 502
3 X 80W - 4000K

 Compton 1200 X 300
4 X 80W PLL - 4000K


 Twin T5 Fluorescent fitting
with Reflector

- Electric Meter
- Consumer Unit/Fuse box
- RCD-Residual Current Device
- Unswitched Fused Spur
- Single Outlet
- Double Outlet
- Double Outlet Clean Supply Counter/Server
- Dedicated Outlet
- Single Light Switch
- Double Light Switch
- Last Man Out switch
- Doorbell Push Button
- Electric Extractor Fan
- Electric Water Heater
- Incoming Data Point
- Double Data Point
- Speaker-arrow showing direction
- Hi-Fi & Amplifier

	Intruder Alarm Key/Fob Panel
	Intruder Alarm-Internal bell/sounder
	Intruder Alarm-External bell/sounder
	Ground Bolt
	Bullet Lock
	Digital lock
	Magi lock
	Mortise Lock
	WC Lock
	Panic Bar
	Overhead Door Closer
	Safe
	CCTV Flat Screen Door Monitor
	CCTV camera-arrow showing direction
	Smoke Bandit

 Gas Meter

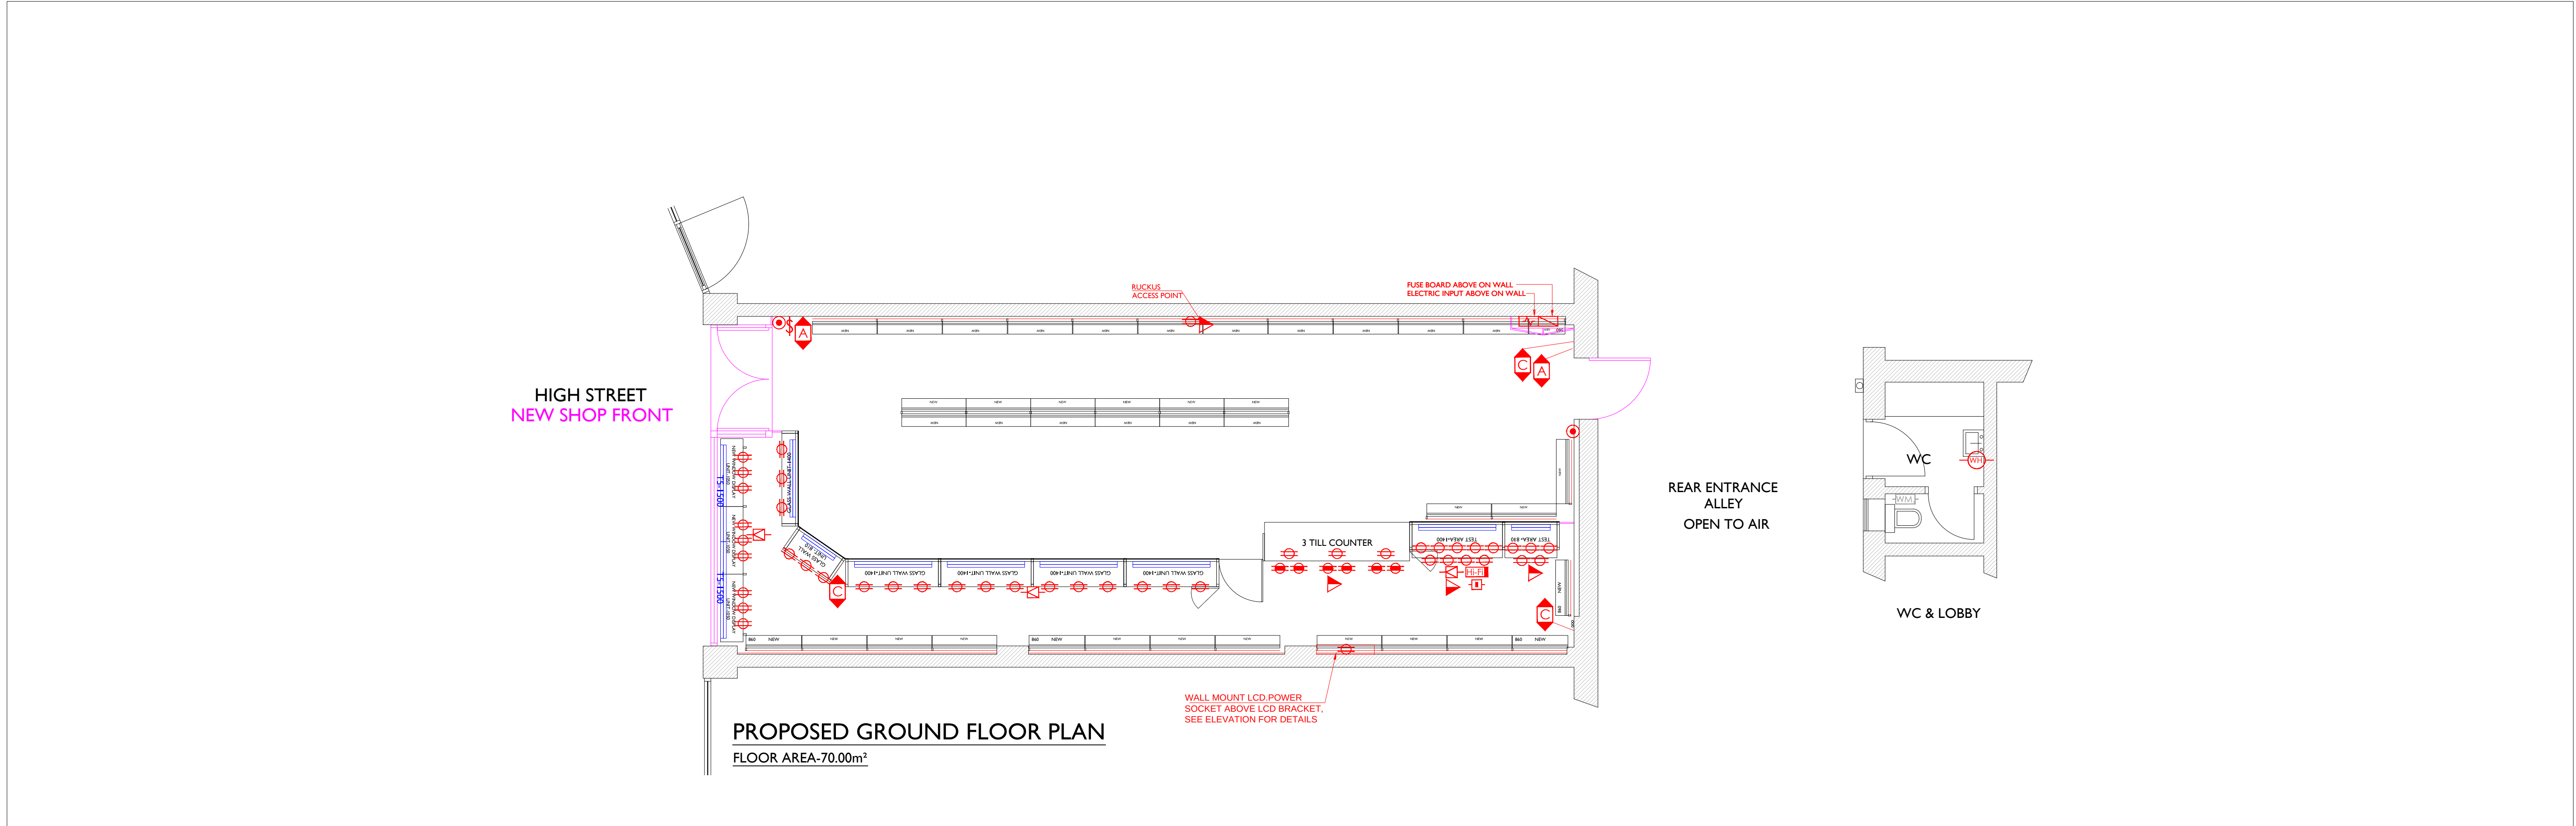
 Water Meter



AIR CONDITIONING KEY	FIRE PRECAUTIONS KEY	LIGHTING KEY	ELECTRICAL KEY	SECURITY KEY	UTILITIES KEY
Heated Door Curtain	Fire Alarm-Control Panel	S S = SURFACE FITTING	Electric Meter	Intruder Alarm Key/Fob Panel	Gas Meter
Thermostat-Aircon	Fire Alarm-Break Glass Point	Dextra Asymmetric RAXT 1232 x 55 HF LUMIN 1180x295x100 2x Osram TRI 840, 55W / 4000K	Consumer Unit/Fuse box	Intruder Alarm-Internal bell/sounder	Water Meter
Control Panel-Aircon	Smoke Detector	Dextra Asymmetric RAXT 631 x 55 HF LUMIN 580x295x100 1x Osram TRI 840, 55W / 4000K	RCD-Residual Current Device	Intruder Alarm-External bell/sounder	
Ceiling Mounted Heat Exchange Inverter Air Conditioning Cassette Unit	Fire Alarm bell/sounder	1200x600x100 LED LIGHTING Specification to be Agreed.	Unswitched Fused Spur	Ground Bolt	
External Condenser	Non-Maintained Emergency Surface Light Fitting	600x600x100 LED LIGHTING Specification to be Agreed.	Single Outlet	Bullet Lock	
	Emergency Escape Route Sign	Recessed 42W PL downlighter	Double Outlet	Digital lock	
	Final Fire Exit Sign	Pendant fitting, twin 42W PL	Double Outlet Clean Supply Counter/Server	Magi lock	
	Extinguisher-Foam, 6 Litres	Tamlite TMH 2455 x 70W HQI SPOTLIGHT	Dedicated Outlet	Mortise Lock	
	Extinguisher-CO2, 2 Kilograms	Spotlight-7W-LED	Single Light Switch	WC Lock	
	SPRINKLER	Fluorescent Light Fitting, 1500mm, 58W	Double Light Switch	Panic Bar	
		Hacel Altimo - 1505 X 502 3 X 80W - 4000K	Last Man Out switch	Overhead Door Closer	
		Compton 1200 X 300 4 X 80W PLL - 4000K	Doorbell Push Button	Safe	
		Twin T5 Fluorescent fitting with Reflector	Electric Extractor Fan	CCTV Flat Screen Door Monitor	
			Electric Water Heater	CCTV camera-arrow showing direction	
			Incoming Data Point	Smoke Bandit	
			Double Data Point		
			Speaker-arrow showing direction		
			Hi-Fi & Amplifier		

CeX Ltd 11 Northburgh Street, London EC1V OAH e-mail: cexdesign@webuy.com Contractors must verify all dimensions on site before commencing work. Only work to given dimensions DO NOT SCALE DRAWINGS. The copyright of this drawing is reserved and the drawing must not be disclosed without the authority of CeX Ltd.	Notes DRAFT	Revision	Info.	Existing	Proposed	Store Name					
			FLOOR AREAS:	EXISTING GROUND FLOOR	- 70.00m²	RETAIL GROUND FLOOR - 70.00m²	CeX-Bognor Regis				
			SUSPENDED CEILING AREA:	GROUND FLOOR - 00m²	GROUND FLOOR - 00m²	Address:					
			SLAT WALL PERIMETER LENGTH:	GROUND FLOOR - 00m²	GROUND FLOOR - 00m²	Bognor Regis, PO21 1PN					
			VINYL FLOOR AREA:	GROUND FLOOR - 00m²	GROUND FLOOR - 00m²	Drawing Title:					
						PROPOSED GROUND FLOOR POWER LAYOUT					
			Scale:	Drawn:	Date:	Drawing No.:	Revision:				
			1:50 @A1	AS	15-01-27	CeX-BOG-06	-				

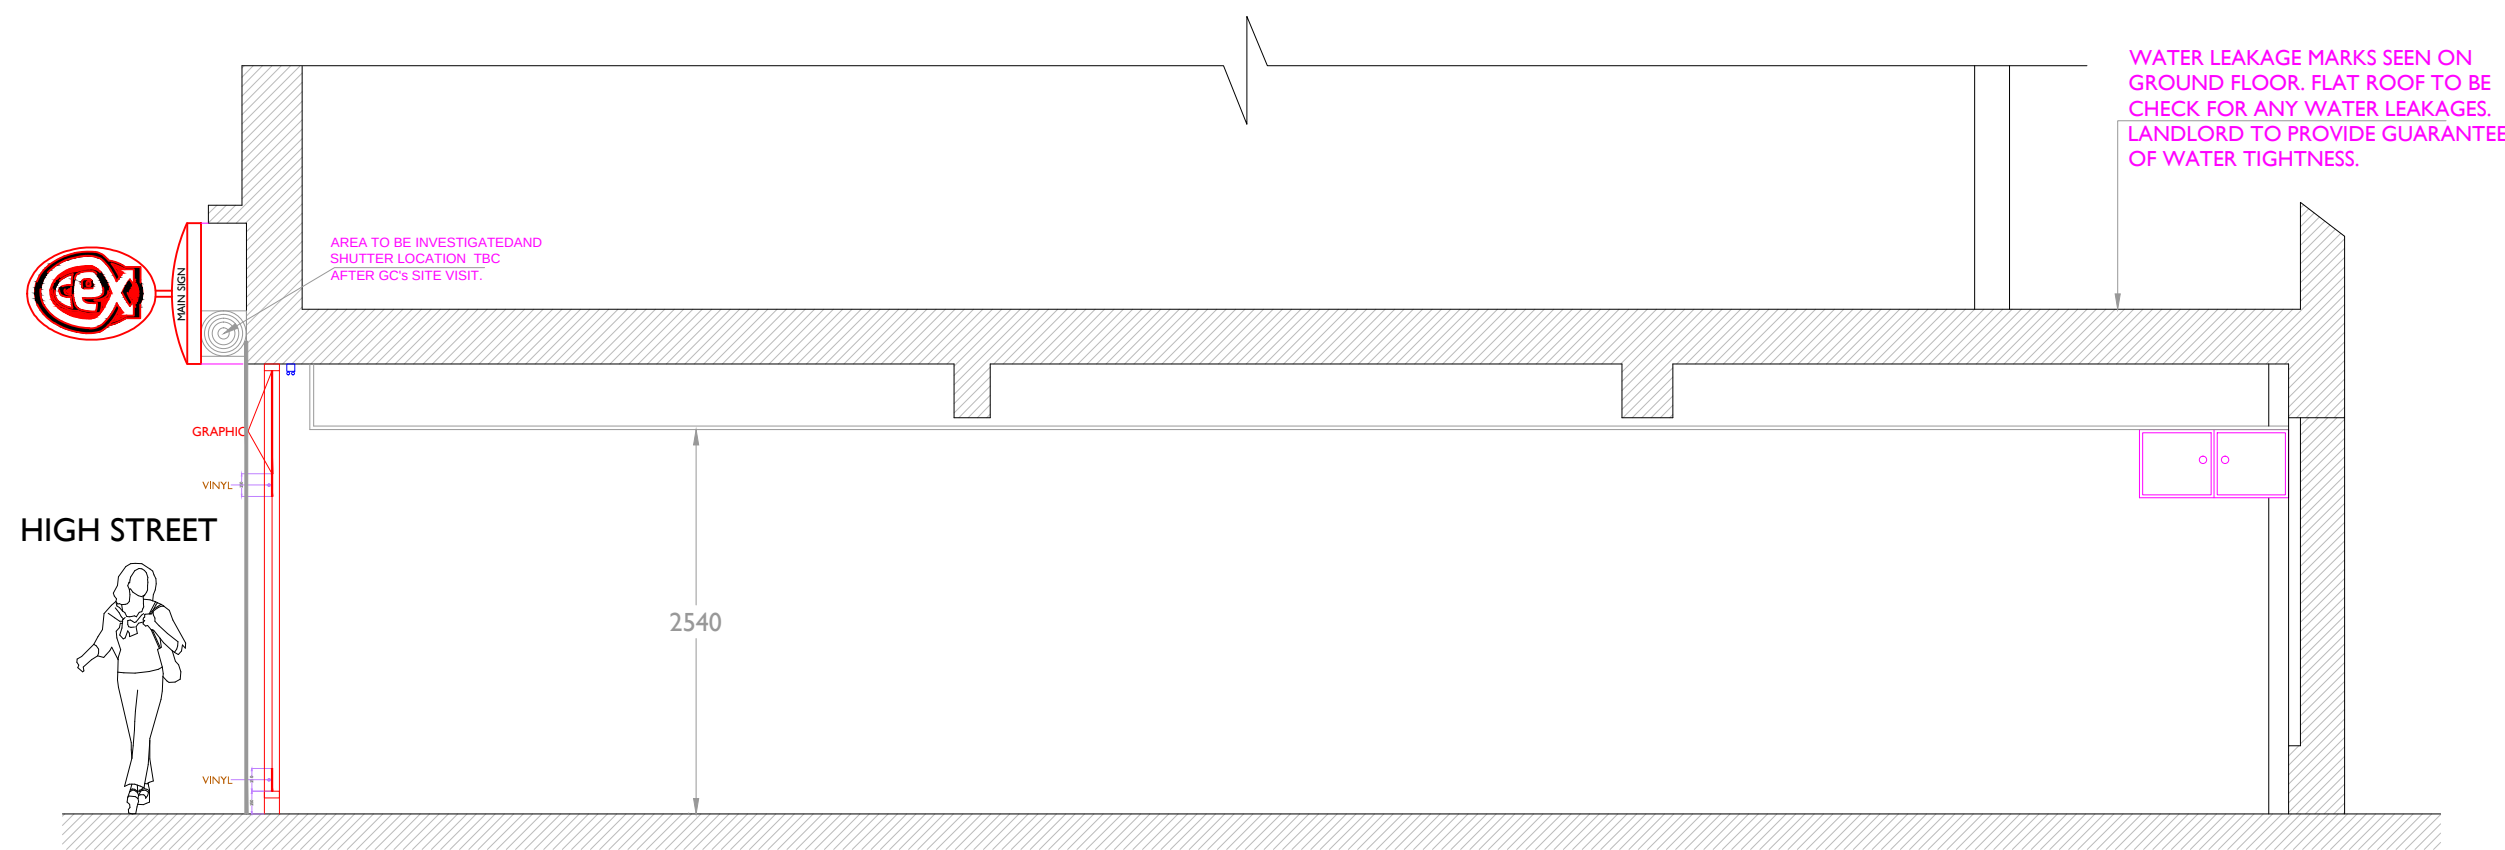DRAFT



PROPOSED SECTION A-A

CeX Ltd

11 Northburgh Street, London EC1V OAH

e-mail: cexdesign@webuy.com

Contractors must verify all dimensions on site before commencing work. Only work to given dimensions DO NOT SCALE DRAWINGS. The copyright of this drawing is reserved and the drawing must not be disclosed without the authority of CeX Ltd.


Notes

DRAFT


Revision

Info.	Existing	Proposed
FLOOR AREAS:	EXISTING GROUND FLOOR -70.00m²	RETAIL GROUND FLOOR - 70.00m²
SUSPENDED CEILING AREA:	GROUND FLOOR - 00m²	GROUND FLOOR - 00m²
SLAT WALL PERIMETER LENGTH:	GROUND FLOOR - 00m²	GROUND FLOOR - 00m²
VINYL FLOOR AREA:	GROUND FLOOR - 00m²	GROUND FLOOR - 00m²

Store Name				
CeX-Bognor Regis				
Address:				
3 Water Tower Buildings, London Road, Bognor Regis, PO21 1PN				
Drawing Title:				
PROPOSED SECTION A-A				
Scale:	Drawn:	Date:	Drawing No.:	Revision:
1:50 @A1	AS	15-01-27	CeX-BOG-07	-

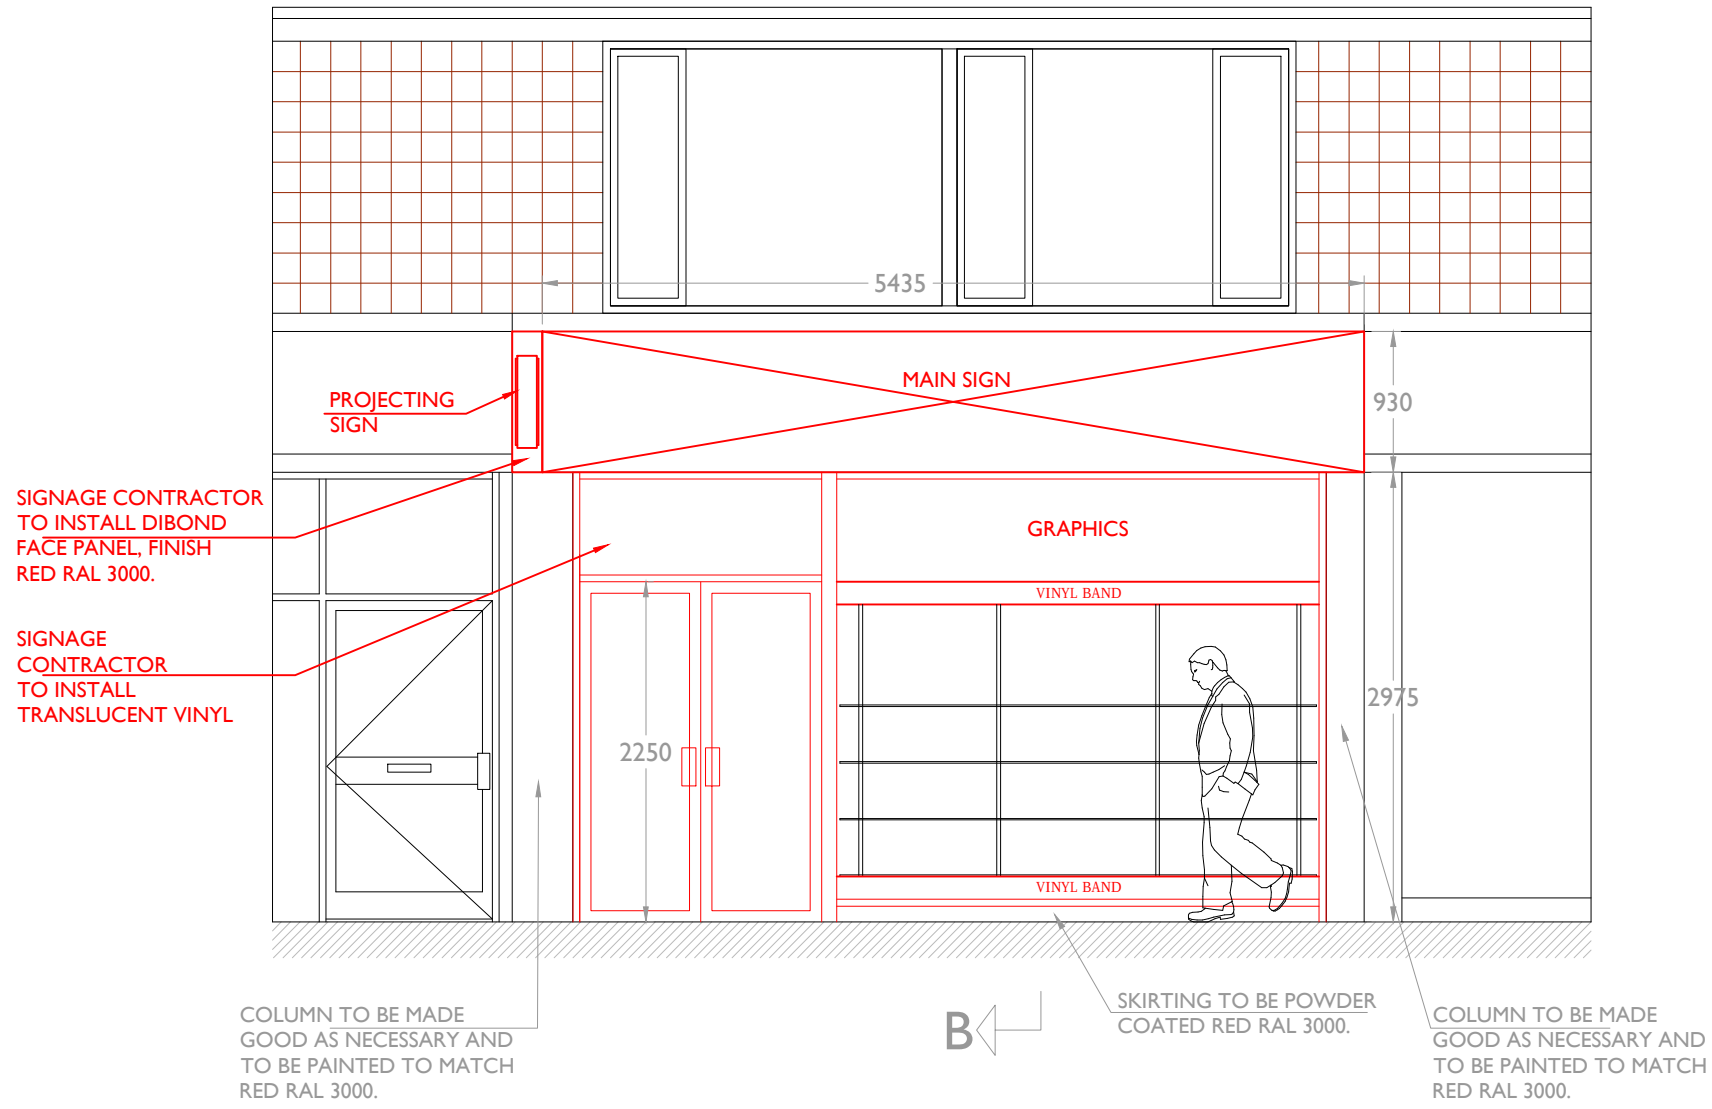

PROPOSED FRONT ELEVATION

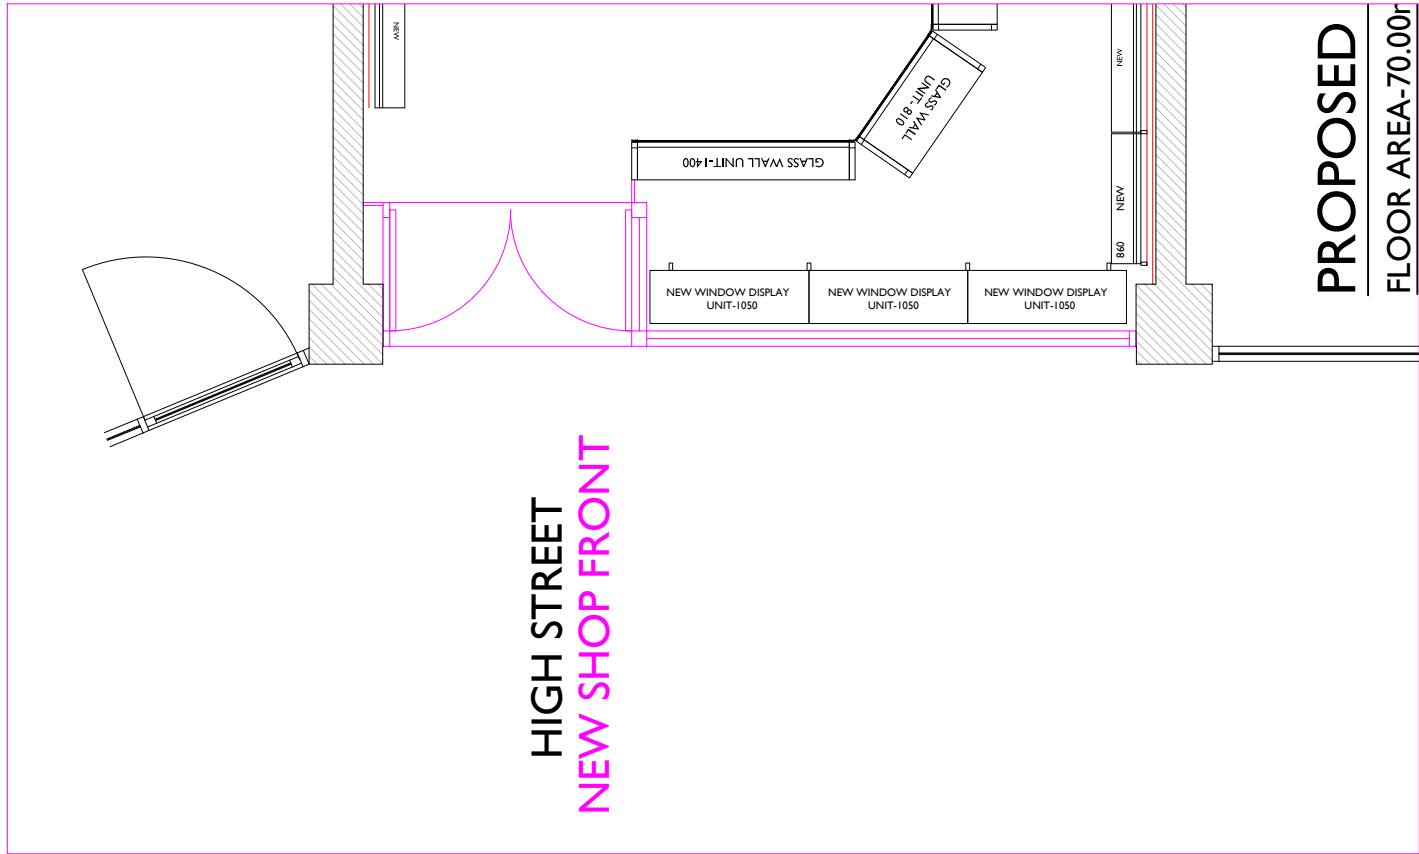

PROPOSED SHOP FRONT KEY PLAN

SIGN SPECIFICATION

Fascia Sign:

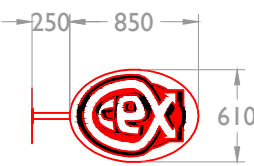
Aluminium Casing - powder coated Red RAL 3000
Acrylic Letters and Logo pushed through curved Acrylic face panel.
Lettering to be in Tahoma Bold
Panel to be internally illuminated using LED lamps.

Logo:


Cast Acrylic with applied Vinyl in Strawberry Red, white & black.

Projecting Sign:


Bracket - Mild steel powder coated Red RAL 3000
Aluminium Casing - powder coated Red RAL 3000
Acrylic Panels - with applied Vinyl in Strawberry Red, White & Black.




HIGH STREET

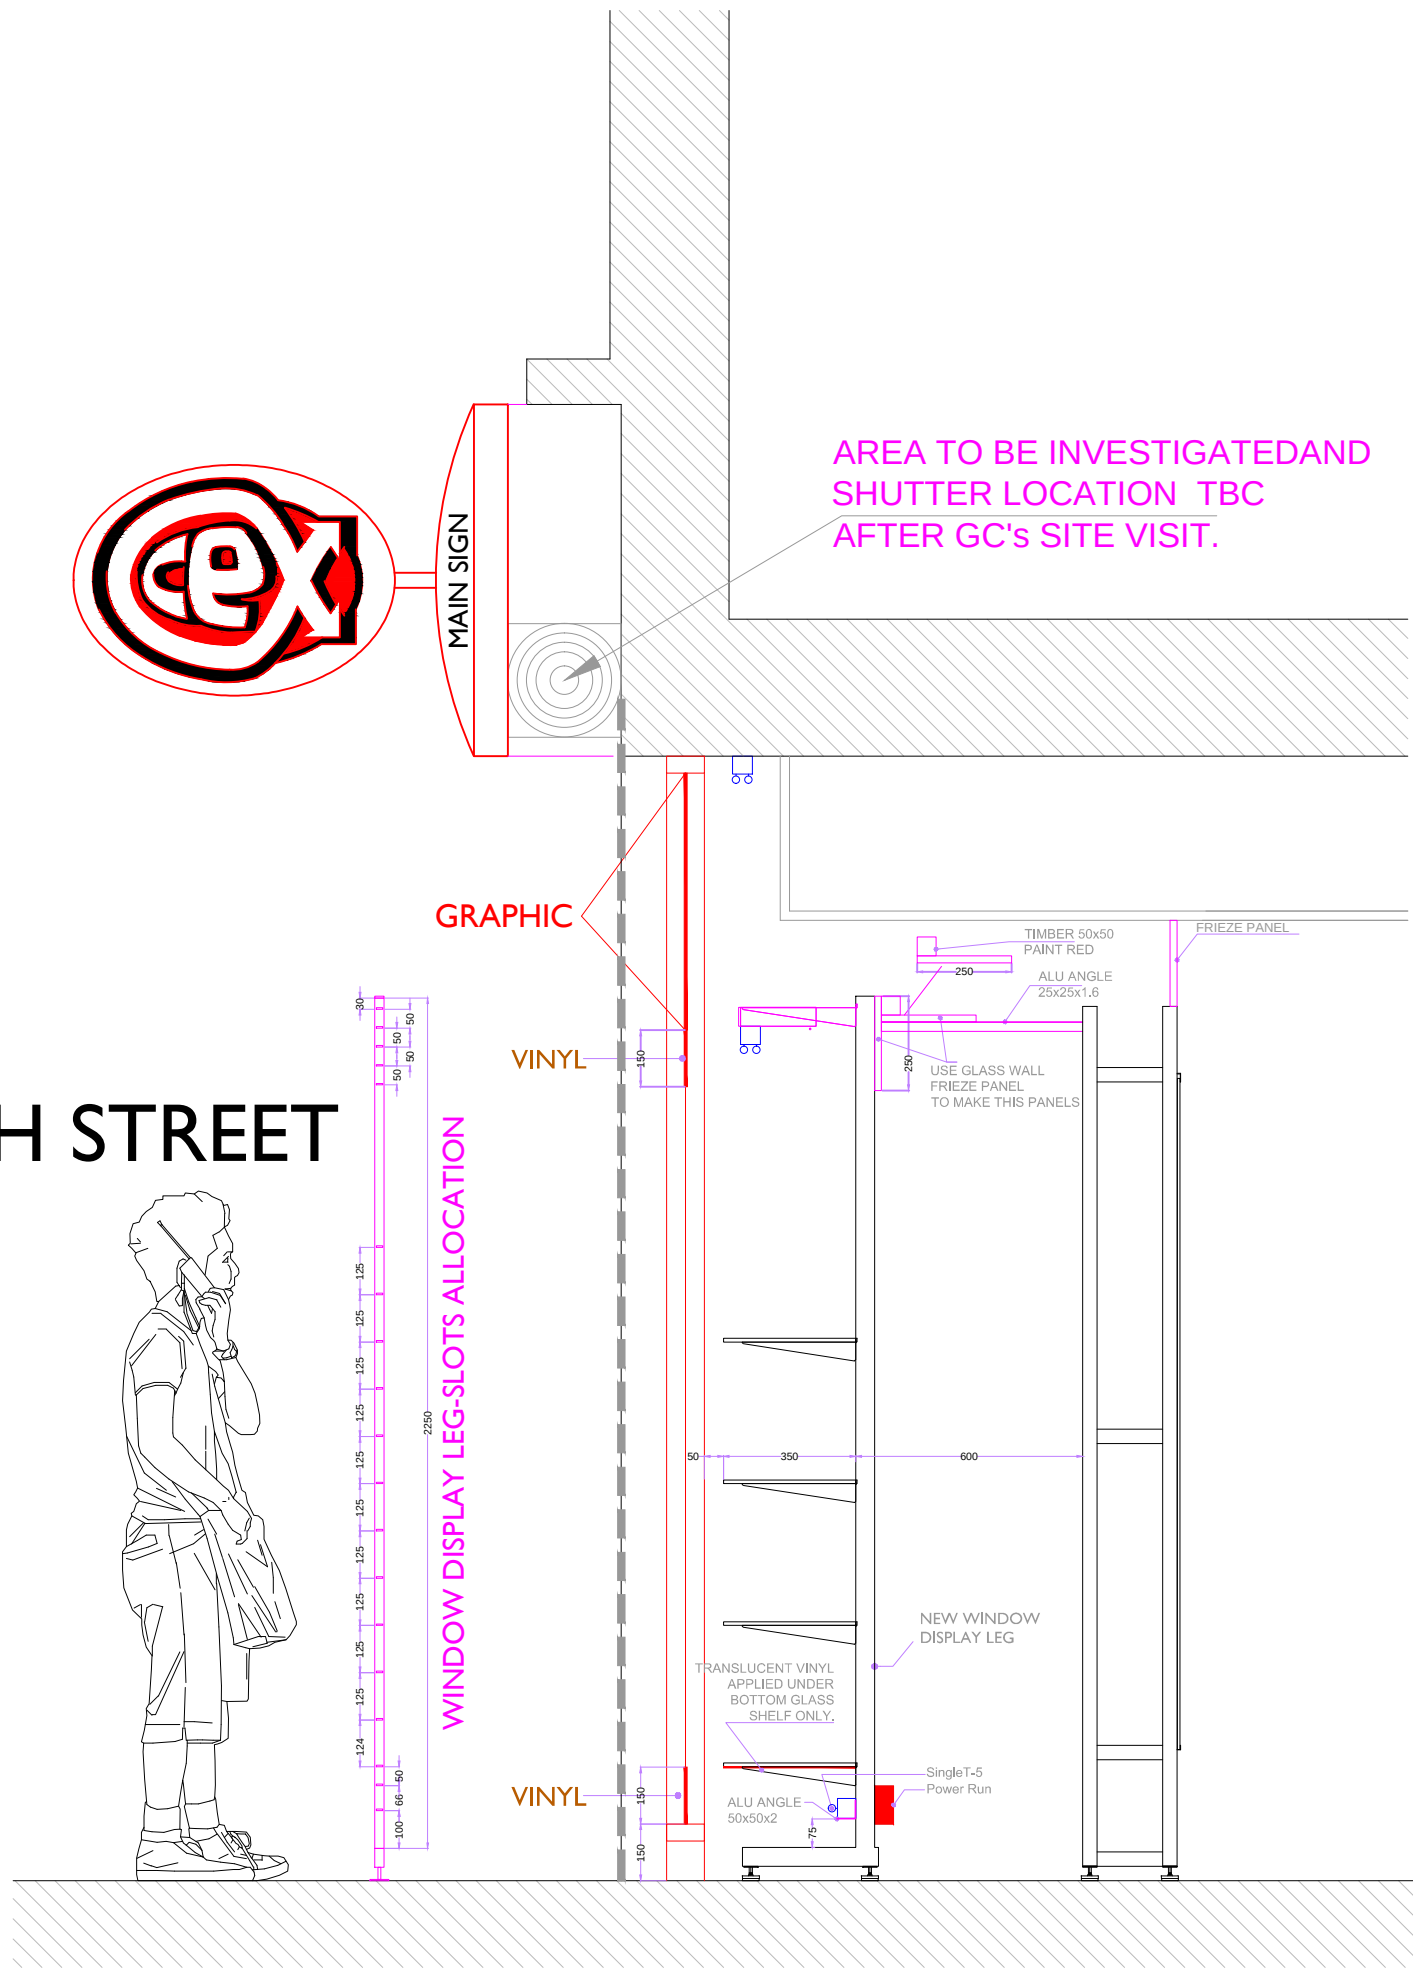


PROPOSED SECTION B'-B'
SCALE 1:20 @ AI

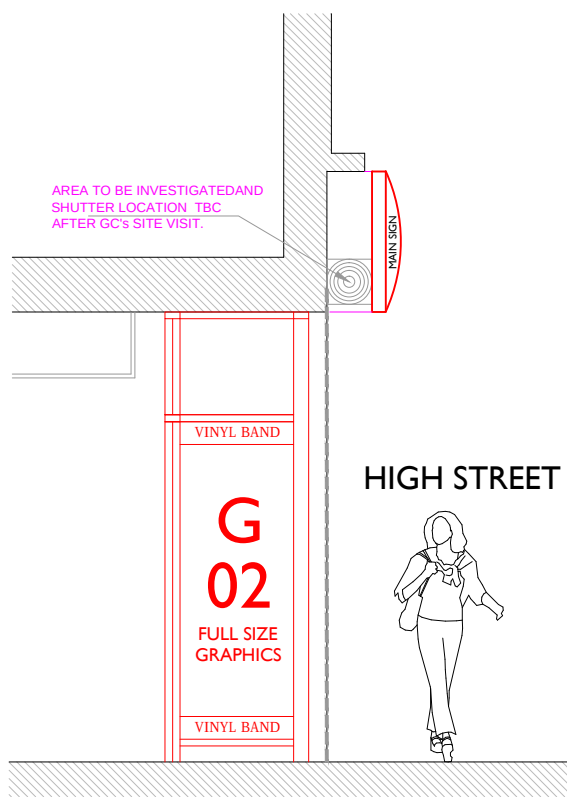

PROPOSED ENTRANCE RIGHT
SIDE ELEVATION

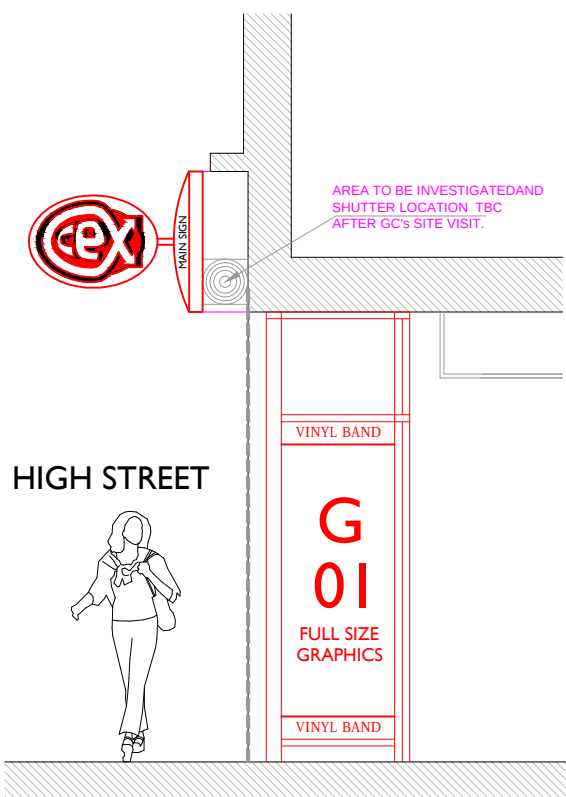

PROPOSED ENTRANCE LEFT
SIDE ELEVATION

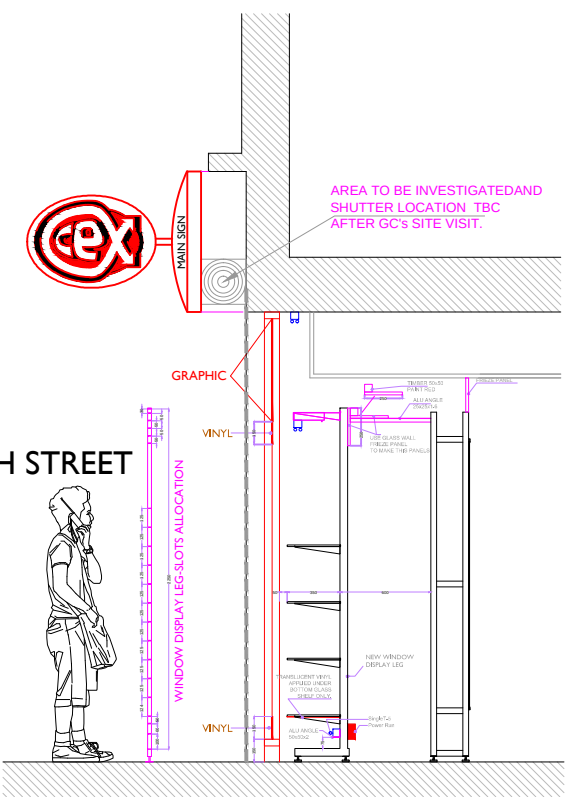

PROPOSED SECTION B'-B'

CeX Ltd
11 Northburgh Street, London EC1V OAH
e-mail: cexdesign@webuy.com
Contractors must verify all dimensions on site before commencing work. Only work to given dimensions DO NOT SCALE DRAWINGS. The copyright of this drawing is reserved and the drawing must not be disclosed without the authority of CeX Ltd.

Notes

DRAFT

Revision

Info.	Existing	Proposed
FLOOR AREAS:	EXISTING GROUND FLOOR - 70.00m²	RETAIL GROUND FLOOR - 70.00m²
SUSPENDED CEILING AREA:	GROUND FLOOR - 00m²	GROUND FLOOR - 00m²
SLAT WALL PERIMETER LENGTH:	GROUND FLOOR - 00m²	GROUND FLOOR - 00m²
VINYL FLOOR AREA:	GROUND FLOOR - 00m²	GROUND FLOOR - 00m²

Store Name	CeX-Bognor Regis			
Address:	3 Water Tower Buildings, London Road, Bognor Regis, PO21 1PN			
Drawing Title:	PROPOSED SHOP FRONT ELEVATION			
Scale:	1:50 @A1	Drawn:	AS	Date:
			15-01-27	Drawing No.:
				CeX-BOG-08
				Revision:
				-