


COPYRIGHT: ALL RIGHTS RESERVED.
THIS DRAWING MUST NOT BE REPRODUCED WITHOUT PERMISSION.
DO NOT SCALE FROM THIS DRAWING.
DIMENSIONS ARE IN MILLIMETRES UNLESS OTHERWISE STATED.

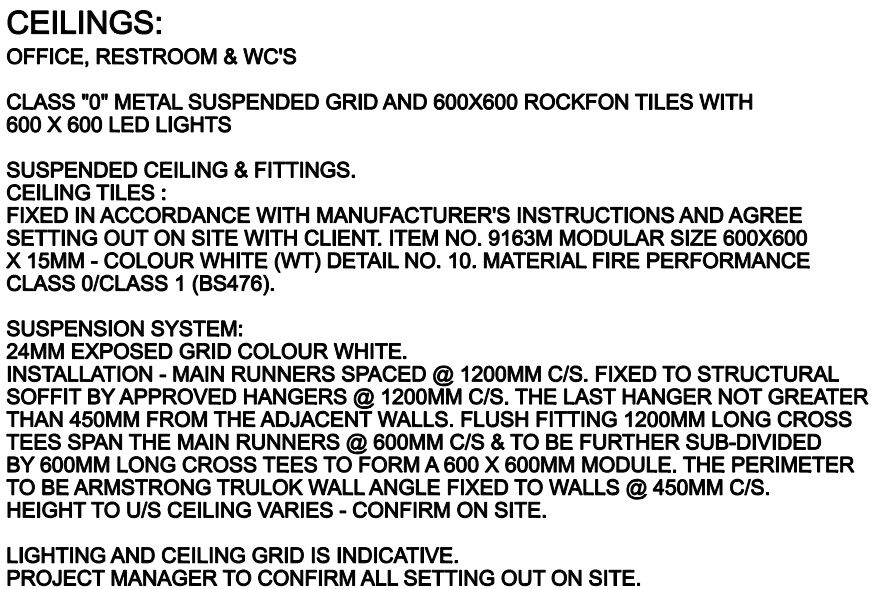

GROUND FLOOR PLAN (1:100)

CEILING/LIGHTING LAYOUT

ELECTRICAL:

1. ALL ELECTRICAL WORK REQUIRED TO MEET THE REQUIREMENTS OF PART P (ELECTRICAL SAFETY) WILL BE DESIGNED, INSTALLED, INSPECTED AND TESTED, IN ACCORDANCE WITH THE REQUIREMENTS OF THE COMPETENT TO DO SO & IN ACCORDANCE WITH M&E SPECIFICATION.
2. THE COUNCIL WILL BE NOTIFIED PRIOR TO ANY COVERING UP OF ANY ELECTRICAL CABLES OR FITTINGS SO THAT AN INSPECTION MAY BE MADE WHILE THEY ARE STILL VISIBLE. IN ADDITION, THE COUNCIL MUST BE ADVISED OF ANY WORK WHICH COULD BE CONSIDERED TO BE A BREACH OF THE ELECTRICAL SAFETY ACT 1991. THE COUNCIL WILL BE ADVISED OF ANY INSPECTION AND TESTING OF THE FIXED ELECTRICAL INSTALLATION WORK.
3. PRIOR TO COMPLETION THE COUNCIL WILL BE PROVIDED WITH AN ELECTRICAL INSTALLATION CERTIFICATE (COMPLETE WITH A SCHEDULE OF INSPECTIONS AND TESTS) AND A SIGNATURE OF THE ELECTRICIAN BY PART 7 OF BS 7671) SIGNED BY A COMPETENT QUALIFIED ELECTRICIAN.
4. SUFFICIENT INFORMATION WILL BE PROVIDED TO THE BUILDING OWNER, ON COMPLETION, SO THAT PERSONS WISHING TO OPERATE, MAINTAIN OR ALTER THE INSTALLATION IN THE FUTURE CAN DO SO REASONABLY SAFELY.
5. ALL SWITCHES & SOCKETS TO BE IN ACCORDANCE WITH APPROVED DOCUMENTATION AND TO BE LOCATED AT A MINIMUM HEIGHT OF 400MM & MAXIMUM HEIGHT OF 1200MM ABOVE FINISHED FLOOR LEVEL.

INTRUDER ALARM TO BE DESIGNED, INSTALLED, COMMISSIONED AND CERTIFIED BY THE APPOINTED CONTRACTOR IN ACCORDANCE WITH ALL CURRENT STANDARDS AND REQUIREMENTS INCLUDING, BUT NOT LIMITED TO A DESIGN RISK ASSESSMENT.

THIS DRAWING IS PRODUCED FROM
SUPPLIED INFORMATION

C	LAYOUT AMENDED TO ALIGN WITH AP01 'D' REVISIONS & AC'S REPOSITIONED	04.11.19	RPR
B	CEILING/LIGHTING LAYOUT AMENDED TO ALIGN WITH AP01 'C' REVISIONS	01.11.19	RPR
A	NOTES AMENDED AS SUSPENDED CEILING/CAVITY BARRIER NOW BY DEVELOPER	29.10.19	RPR
Rev	Amendment	Date	Initials

MATERIALS SHOULD COMPLY WITH THE APPROPRIATE BRITISH STANDARDS OF AGREEMENT CERTIFICATES AND RELEVANT NUMBERS SHOULD BE QUOTED IN THE MAIN SPECIFICATION. ALTERNATIVELY, THE MATERIALS SHOULD BE MARKED, STAMPED, INDEPENDENTLY CERTIFIED OR OTHERWISE JUSTIFIED BY TEST OR CALCULATION TO SHOW THEIR SUITABILITY.

WORKMANSHIP SHOULD GENERALLY BE IN ACCORDANCE WITH THE BS8000 SERIES OF DOCUMENTS AND OTHER ACCEPTED GOOD PRACTICE.

TEST CERTIFICATES FOR INTUMESCENT MATERIALS, AIR CONDITIONING
LIFTS, EMERGENCY LIGHTING & FIRE ALARMS WILL BE SUBMITTED
PRIOR TO COMPLETION.

ALL LIGHT FITTINGS ARE LED WITH NO DIFFUSERS			
KEY TO LIGHTING		TABLE OF FITTINGS ON SALES FLOOR	TABLE OF FITTINGS TO BACK OF HOUSE
	FLUORESCENT STRIP LIGHT FITTING	1 (1 NO. EMERGENCY)	15 X 1800 (5 NO. EMERGENCY) 4 X 1200 (2 NO. EMERGENCY)
	600 x 600 RECESSED 30W LED PANEL COOL WHITE - 1 X LED 30W/2900LM	53 (8 NO. EMERGENCY)	5 (2 NO. EMERGENCY)
	800 x 600 RECESSED 30W LED PANEL COOL WHITE - 1 X LED 30W/2900LM	0 (0 NO. EMERGENCY)	5 (2 NO. EMERGENCY)
	COMPACT FLUORESCENT LIGHTS	4	0
	24W LED COMMERCIAL DOWNLIGHT - COOL WHITE - 1 X LED 24W/1800LM	49	0
	TRACK SPOT LIGHTS	12	0
	SPOT LIGHT TRACK - 2.4M SPOT LIGHT TRACK - 1.8M SPOT LIGHT TRACK - 1.2M	3 0 0	0


EMERGENCY LIGHTING TO COMPLY WITH BS5266 PART 1 2016 (TYPE NM1) TO BE DESIGNED & INSTALLED BY SHOPFITTER COMPLETE WITH FIRE EXIT DIRECTION LIGHTS ABOVE DOORS & TO ACHIEVE AN AVERAGE OF 1 LUX.
EMERGENCY ESCAPE LIGHTING TO BE INSTALLED IN ACCORDANCE WITH BS 5266

**PART 1 & TABLE 9 FOR ALL WINDOWLESS ACCOMMODATION INCLUDING WC'S
ESCAPE LIGHTING SYSTEM TO BE DESIGNED & INSTALLED BY SPECIALIST & TO CONFORM
TO BS5266:PT1:2016 & BS EN 1838**

KEY TO SYMBOLS

FIRE GRAPHICS SYMBOLS

	WATER EXTINGUISHER		FIRE ACTION NOTICE AT EVERY BREAK GLASS POINT
	CO2 EXTINGUISHER		DIRECTIONAL FIRE EXIT SIGN - RUNNING MAN
	BREAK GLASS POINT		FIRE EXIT SIGN - RUNNING MAN
	FAIL SAFE DOOR RELEASE MANUAL OVERRIDE	VP	VISION PANEL
		PB	PANIC BAR
		SC	SELF CLOSER
			AUDIBLE/VISUAL ALARM INDICATOR

 

Edinburgh Woollen Mills
Global House
5 Castle Street
Carlisle
CA3 8SY

RRDS LTD
Studio 1, 1st Floor The Ffwrwm,
High Street, Caerleon, Newport NP18 1AG
Email: design@rrds.net
Telephone: 01873 881165 Fax: 01873 881343

Project: Proposed Edinburgh Woollen Mill
9-11 Water Tower Building,
Bognor Regis,
East Sussex. PO21 1PN

Title: **Ground Floor Ceiling/Lighting Layout
As Proposed**

Scale: 1:100 @ A1 Date: October 2019

RPR Ref. No. EWM070/AP02 C

Drawn by: RRDS