


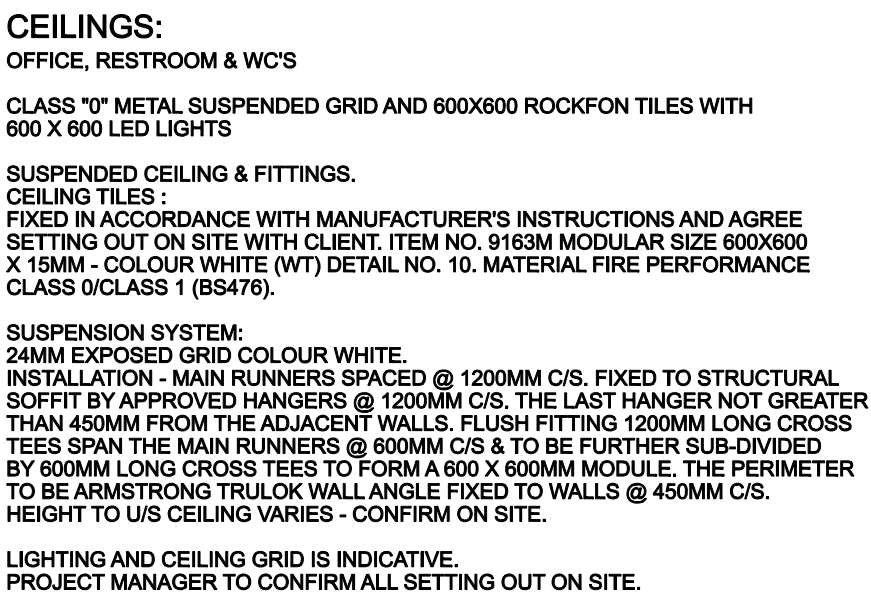

GROUND FLOOR PLAN (1:100)

CEILING/LIGHTING LAYOUT

EMERGENCY LIGHTING:

EMERGENCY LIGHTING TO BE DESIGNED, INSTALLED, COMMISSIONED AND CERTIFIED BY THE APPOINTED CONTRACTOR IN ACCORDANCE WITH ALL CURRENT STANDARDS AND REQUIREMENTS INCLUDING, BUT NOT LIMITED TO A DESIGN RISK ASSESSMENT.

PROPOSALS TO BE SUBMITTED TO THE PROJECT MANAGER PRIOR TO THE WORKS BEING UNDERTAKEN.

EMERGENCY LIGHTING TO COMPLY WITH BS5266 PART 1 2016 (TYPE NM) TO BE DESIGNED & INSTALLED BY SHOPFITTER COMPLETE WITH FIRE EXIT DIRECTOR LIGHTS ABOVE DOORS & TO ACHIEVE AN AVERAGE OF 1 LUX.

EMERGENCY ESCAPE LIGHTING TO BE INSTALLED IN ACCORDANCE WITH BS 5266:

PART 1 & 2 REQUIRE FOR ALL WINDOWLESS ACCOMMODATION INCLUDING WC'S

EMERGENCY ESCAPE LIGHTING SYSTEM TO BE DESIGNED & INSTALLED BY SPECIALIST & TO CONFORM TO BS5266:PART1:2011 EN 1838

ELECTRICAL:

1. ALL ELECTRICAL WORK REQUIRED TO MEET THE REQUIREMENTS OF PART P (ELECTRICAL SAFETY) WILL BE DESIGNED, INSTALLED, INSPECTED AND TESTED, IN ACCORDANCE WITH THE REQUIREMENTS OF THE COMPETENT TO DO SO & IN ACCORDANCE WITH M&E SPECIFICATION.

2. THE COUNCIL WILL BE NOTIFIED PRIOR TO ANY COVERING UP OF ANY ELECTRICAL CABLES OR FITTINGS SO THAT AN INSPECTION MAY BE MADE WHILE THEY ARE STILL VISIBLE. IN ADDITION, THE COUNCIL MUST BE ADVISED OF ANY CHANGES TO THE OPPORTUNITY TO WITNESS, THE 7671 INSPECTION AND TESTING OF THE FIXED ELECTRICAL INSTALLATION WORK.

3. PRIOR TO COMPLETION THE COUNCIL WILL BE PROVIDED WITH AN ELECTRICAL INSTALLATION CERTIFICATE (COMPLETE WITH A SCHEDULE OF INSPECTIONS AND TESTS) SIGNED BY A COMPETENT ELECTRICIAN BY PART 7 OF BS 7671) SIGNED BY A COMPETENT QUALIFIED ELECTRICIAN.

4. SUFFICIENT INFORMATION WILL BE PROVIDED TO THE BUILDING OWNER, ON COMPLETION, SO THAT PERSONS WISHING TO OPERATE, MAINTAIN OR ALTER THE INSTALLATION IN THE FUTURE CAN DO SO REASONABLY SAFELY.

5. ALL SWITCHES & SOCKETS TO BE IN ACCORDANCE WITH APPROVED DOCUMENTATION. MINIMUM HEIGHT OF 400MM & MAXIMUM HEIGHT OF 1200MM ABOVE FINISHED FLOOR LEVEL.

INTRUDER ALARM TO BE DESIGNED, INSTALLED, COMMISSIONED AND CERTIFIED BY THE APPOINTED CONTRACTOR IN ACCORDANCE WITH ALL CURRENT STANDARDS AND REQUIREMENTS INCLUDING, BUT NOT LIMITED TO A DESIGN RISK ASSESSMENT.

C	LAYOUT AMENDED TO ALIGN WITH AP01 'D' REVISIONS & AC'S REPOSITIONED	04.11.19	RPR
B	CEILING/LIGHTING LAYOUT AMENDED TO ALIGN WITH AP01 'C' REVISIONS	01.11.19	RPR
A	NOTES AMENDED AS SUSPENDED CEILING/CAVITY BARRIER NOW BY DEVELOPER	29.10.19	RPR
Rev	Amendment	Date	Initials

MATERIALS SHOULD COMPLY WITH THE APPROPRIATE BRITISH STANDARDS OF AGREEMENT CERTIFICATES AND RELEVANT NUMBERS SHOULD BE QUOTED IN THE MAIN SPECIFICATION. ALTERNATIVELY, THE MATERIALS SHOULD BE MARKED, STAMPED, INDEPENDENTLY CERTIFIED OR OTHERWISE JUSTIFIED BY TEST OR CALCULATION TO SHOW THEIR SUITABILITY.

WORKMANSHIP SHOULD GENERALLY BE IN ACCORDANCE WITH THE BS8000 SERIES OF DOCUMENTS AND OTHER ACCEPTED GOOD PRACTICE.

TEST CERTIFICATES FOR INTUMESCENT MATERIALS, AIR CONDITIONING, LIFTS, EMERGENCY LIGHTING & FIRE ALARMS WILL BE SUBMITTED PRIOR TO COMPLETION.

0.5 0 1.0 2.0 3.0 4.0 5.0

SCALE BAR 1:100

Edinburgh Woollen Mills
Global House
5 Castle Street
Carlisle
CA3 8SY

RRDS LTD
Studio 1, 1st Floor The Ffrwm,
High Street, Caerleon, Newport NP18 1AG
Email: design@rrds.net
Telephone: 01873 881165 Fax: 01873 881343

Project: Proposed Edinburgh Woollen Mill
9-11 Water Tower Building,
Bognor Regis,
East Sussex. PO21 1PN

Title: **Ground Floor Ceiling/Lighting Layout
As Proposed**

Scale: 1:100 @ A1 Date: October 2019

RPR Ref. No. EWM070/AP02 C

Drawn by: **RRDS**