

- KEY TO ELECTRICAL SYMBOLS
- 

Twin socket outlet
- 

Heat detector
- 

5 amp lightoutlet
- 

30 amp supply for oven unit
- 

external waterproof socket
- 

TV socket outlet
- 

Telephone socket outlet
- 

Extract fan ducted to outside air
- 


Plain light switch
- 

Dimmer light switch
- 

Wall Light
- 

Low energy recessed light fitting
- 

Tungsten pendant light fitting

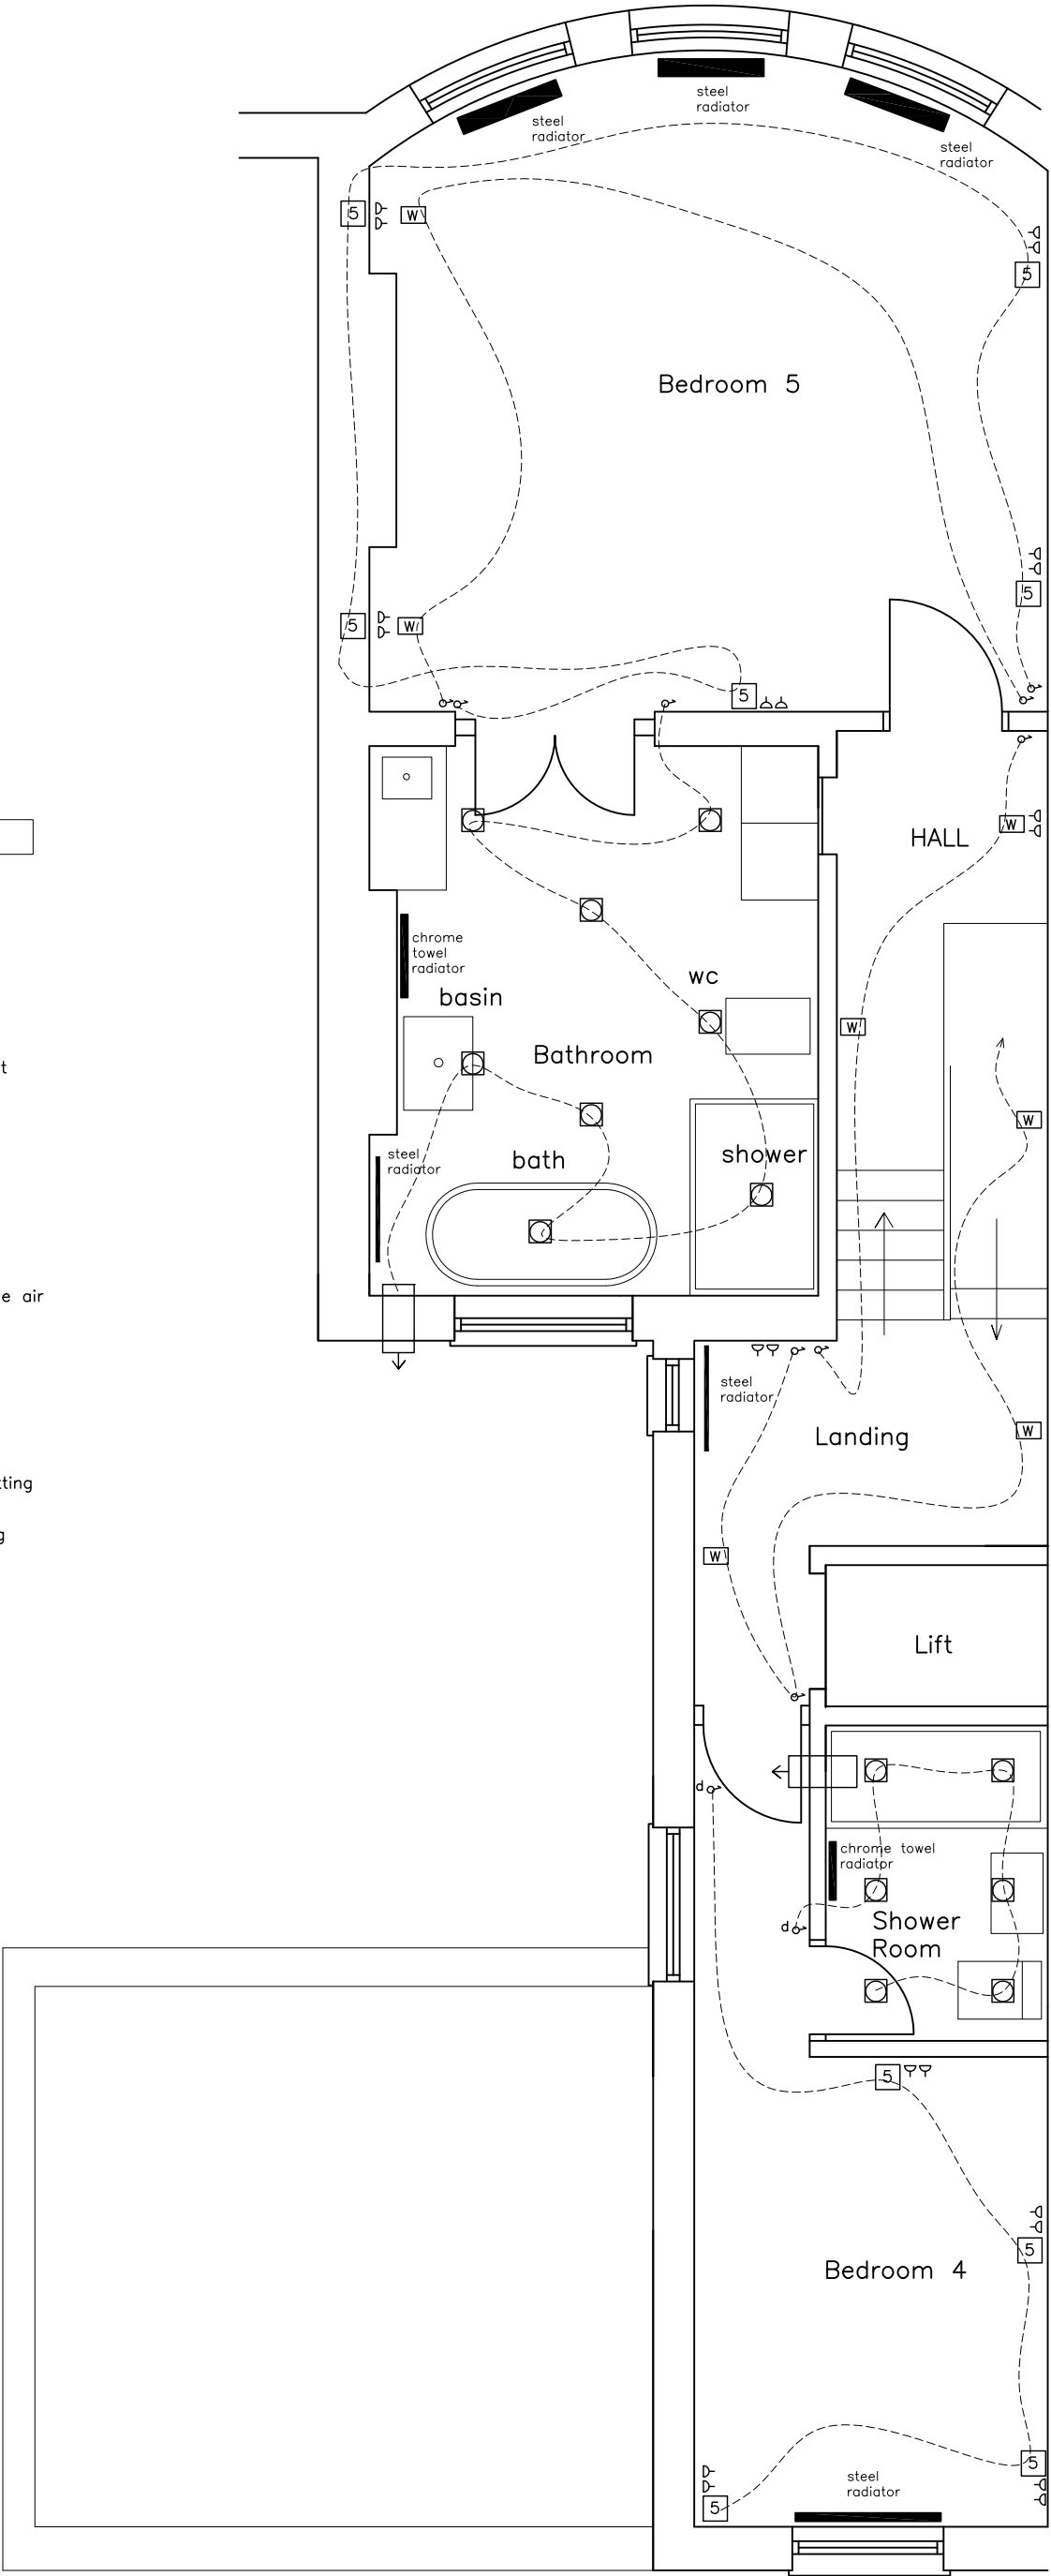

SECOND FLOOR PLAN AS PROPOSED

COOMBS DAVIES BICKLEY
Architects

43 STROUD ROAD
LONDON
SW19 8DQ
Tel/Fax : 020 8947 8625

Project

ALTERATIONS TO
3 MARINE PARADE
BOGNOR REGIS

Drawing Title

PROPOSED ELECTRICAL &
RADIATOR LAYOUT TO SECOND
FLOOR

Scale

NTS

Drawing No.

3MAR.P1.07

Revision:

Date

Nov
2014