

- KEY TO ELECTRICAL SYMBOLS
- 

Twin socket outlet
- 

Heat detector
- 

5 amp lightoutlet
- 

30 amp supply for oven unit
- 

external waterproof socket
- 

TV socket outlet
- 

Telephone socket outlet
- 

Extract fan ducted to outside air
- 


Plain light switch
- 

Dimmer light switch
- 

Wall Light
- 

Low energy recessed light fitting
- 

Tungsten pendant light fitting

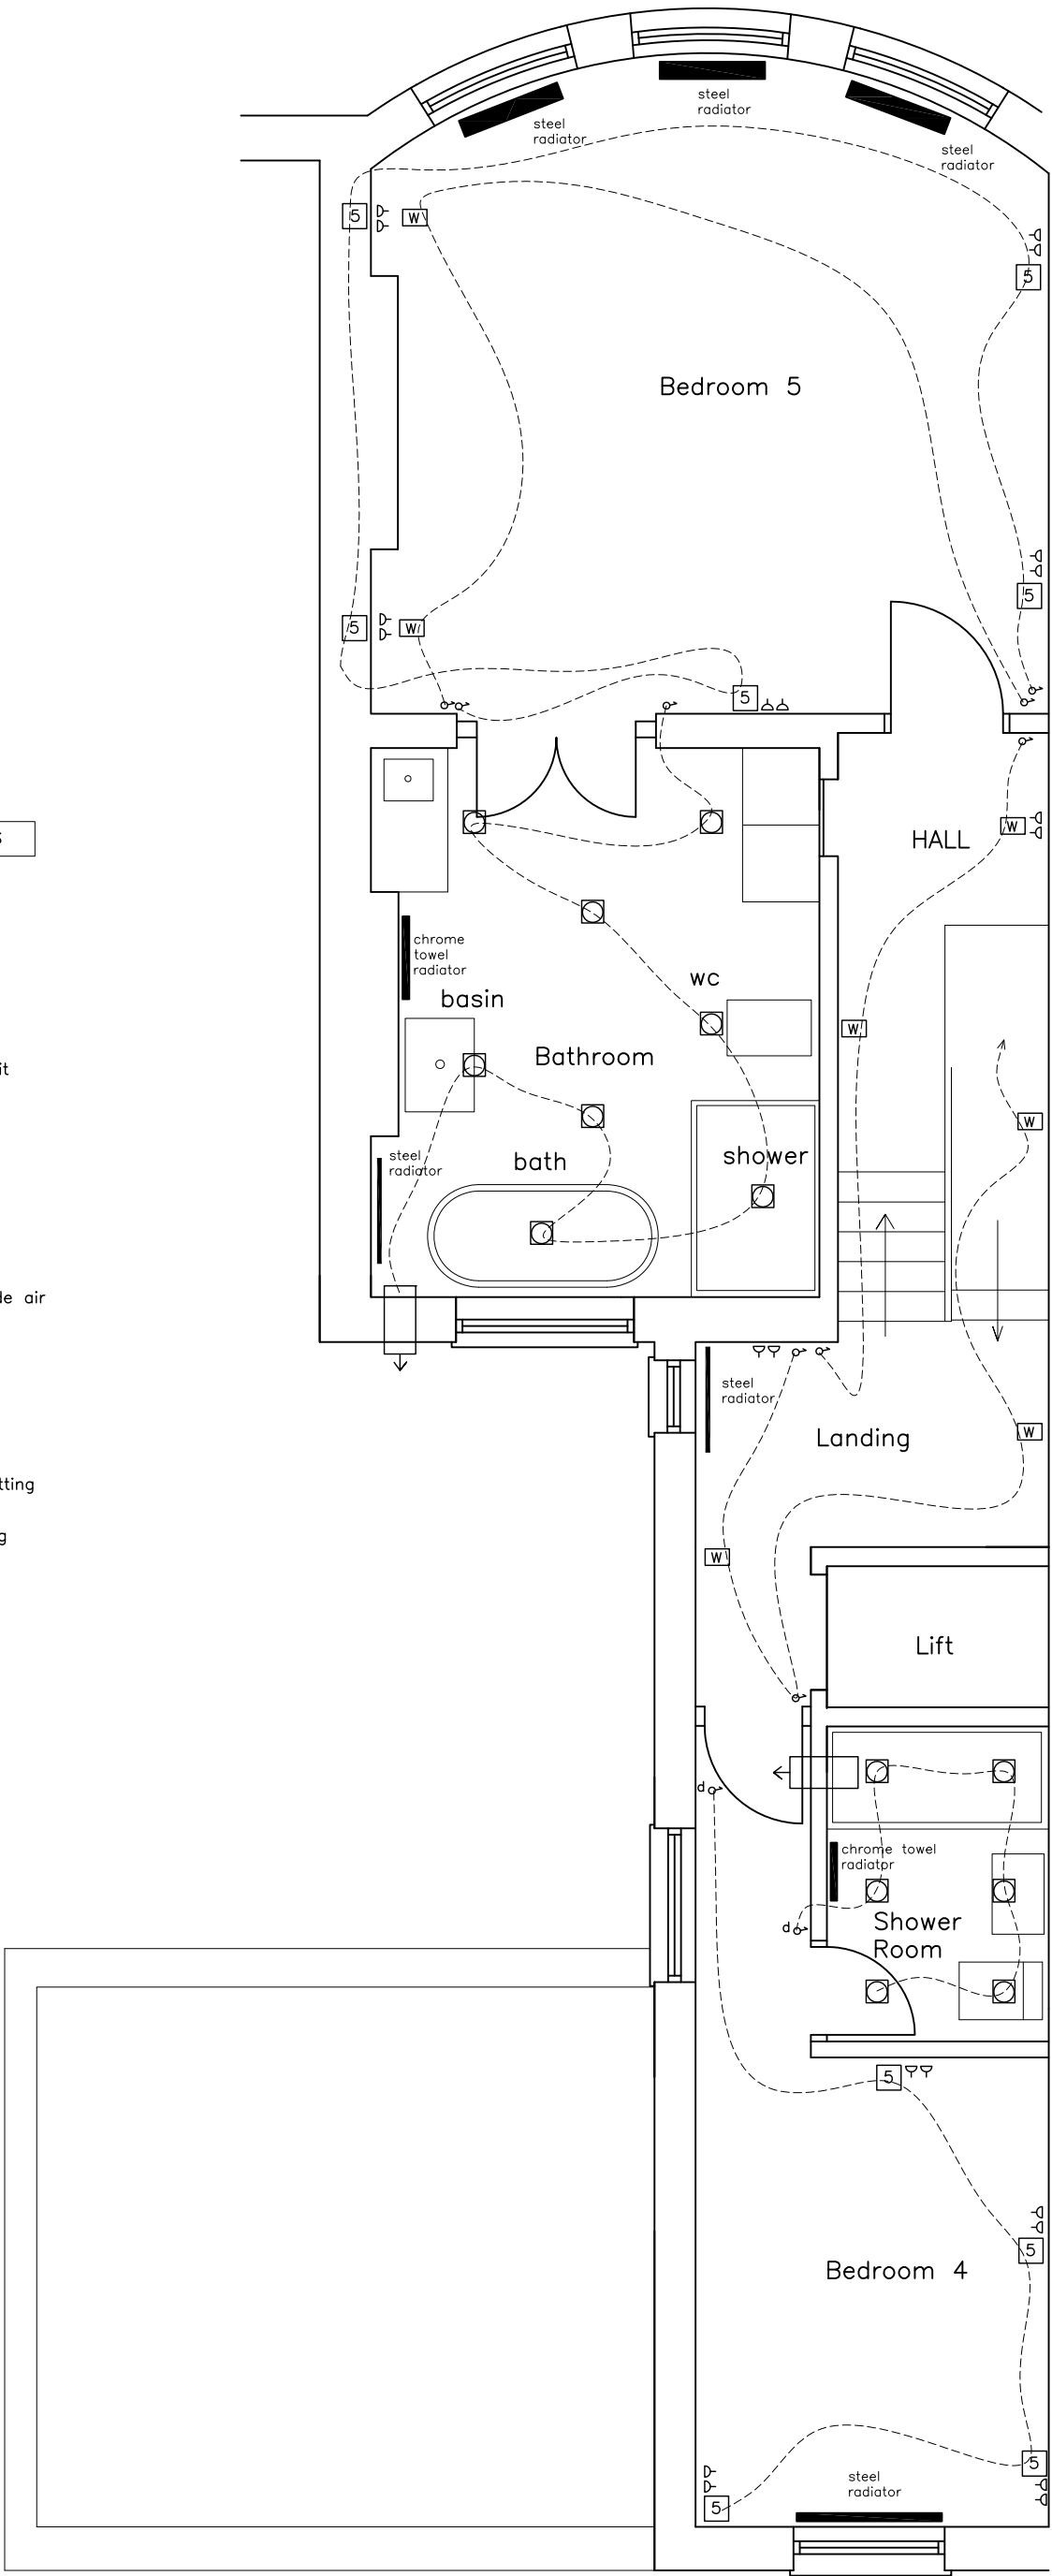

SECOND FLOOR PLAN AS PROPOSED

COOMBS DAVIES BICKLEY Architects	43 STROUD ROAD LONDON SW19 8DQ Tel/Fax : 020 8947 8625	Project ALTERATIONS TO 3 MARINE PARADE BOGNOR REGIS	Drawing Title PROPOSED ELECTRICAL & RADIATOR LAYOUT TO SECOND FLOOR	Scale NTS	Drawing No. 3MAR.P1.07	Date Nov 2014
					Revision:	