


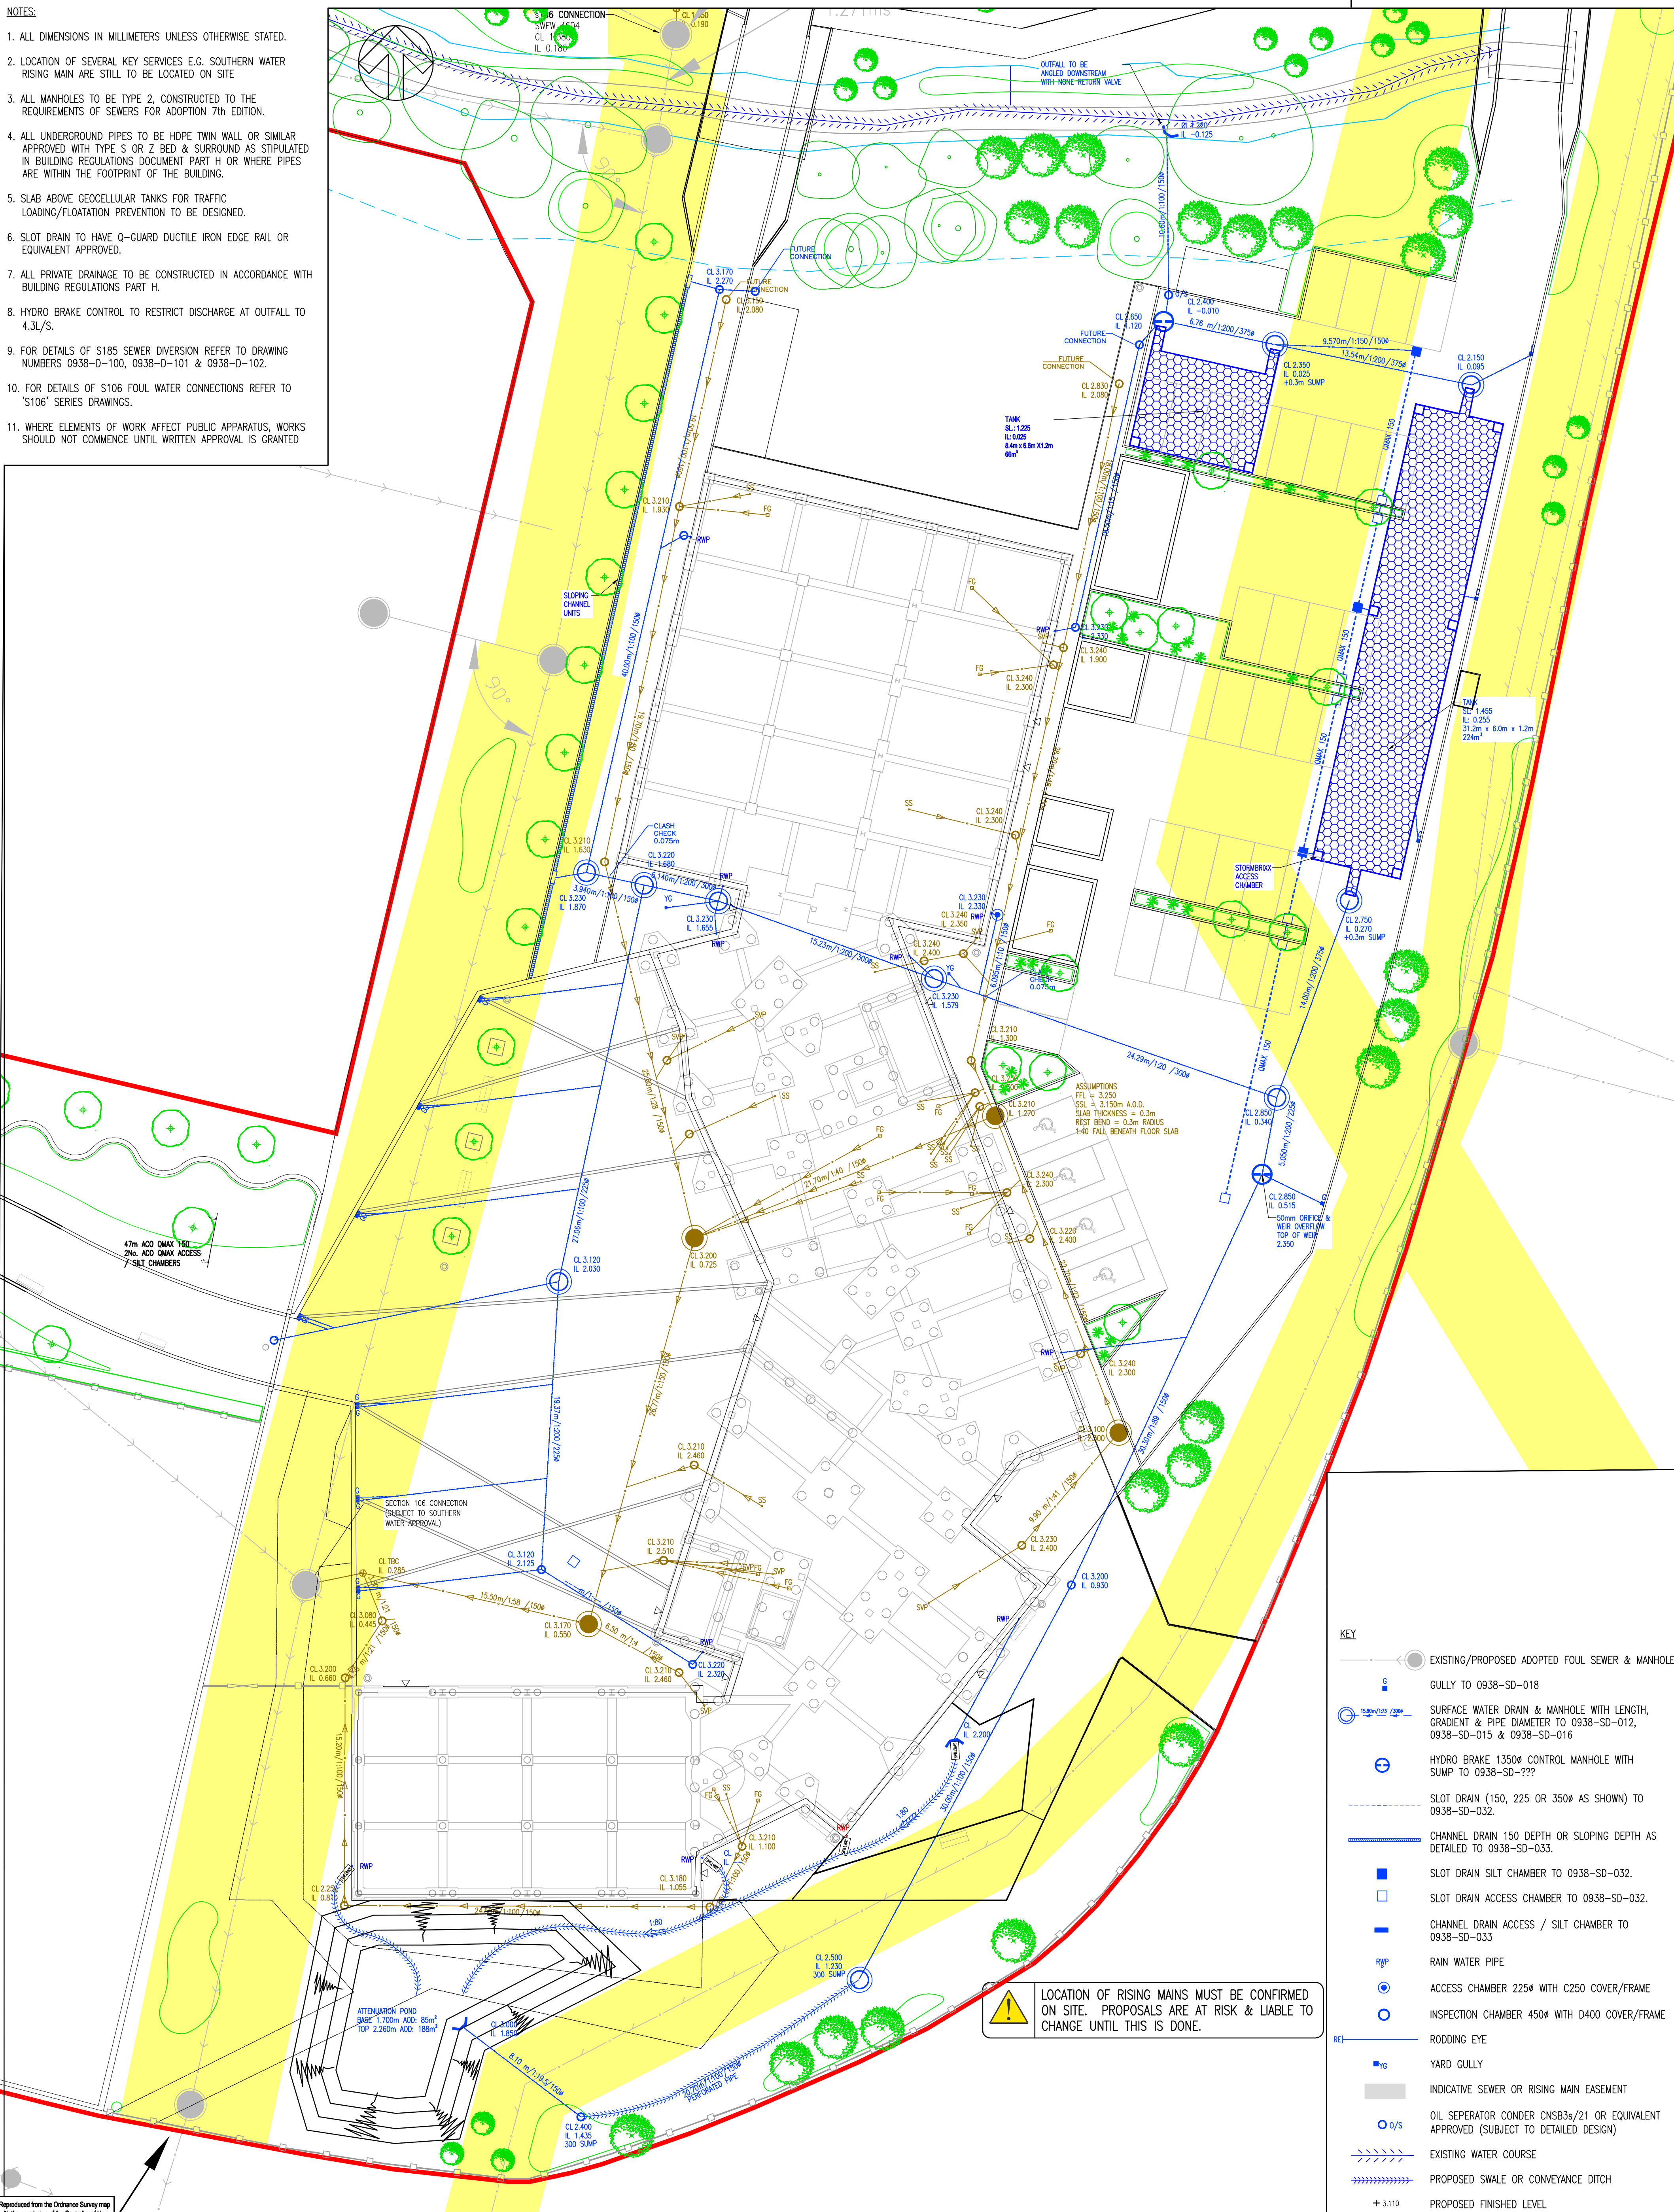

B	20/09/16	MJM	DRAINAGE RE-DESIGNED FOR ADDITIONAL DETAIL AND VALUE ENGINEERING. FOUL DRAINAGE ADDED AND TITLE AMENDED	OUT	MJM
A	28/06/16	MJM	FIRST ISSUE	FN	MJM
REV	DATE	BY	DESCRIPTION	CHK	APP

 **WSP** | **PARSONS
BRINCKERHOFF**

Regus House, Southampton International Business Park
George Curl Way, Southampton, Hampshire, SO18 2RZ
Tel: +44 (0)2380 302529 Fax: +44 (0)2380 302001
www.wspgroup.com www.pbworld.com

CLIENT:	UNIVERSITY OF CHICHESTER	PROJECT:	UNIVERSITY OF CHICHESTER EDT PARK BOGNOR REGIS
ARCHITECT:	STRIDE TREGLOWN LTD.	TITLE:	PROPOSED DRAINAGE LAYOUT EDT BUILDING

SCALE @ A1:	1:200	CHECKED:	FN	APPROVED:	—
CAD FILE:	0938-D-104.DWG	DESIGN-DRAWN:	GR	DATE:	September 16
PROJECT No:	70010938	DRAWING No:	0938-D-104	REV:	B
PROJECT DOCUMENT REF:		0938/D/104			