
 


SITE LOCATION

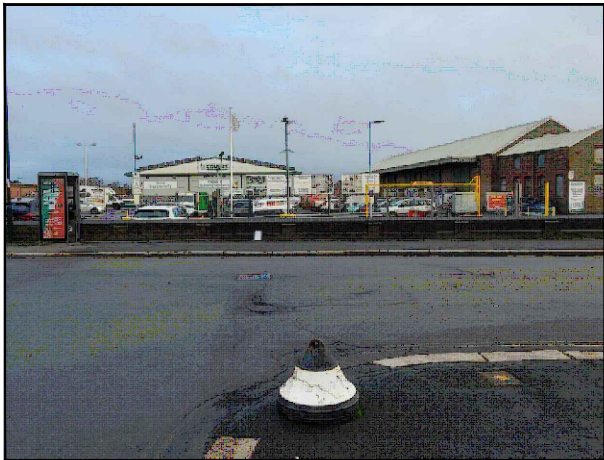


Reproduced by permission of Ordnance Survey on behalf of the Controller of Her Majesty's Stationary Office
All rights reserved. © Crown Copyright licence no. 100062043

SITE AREA PLAN




SITE PHOTOGRAPH

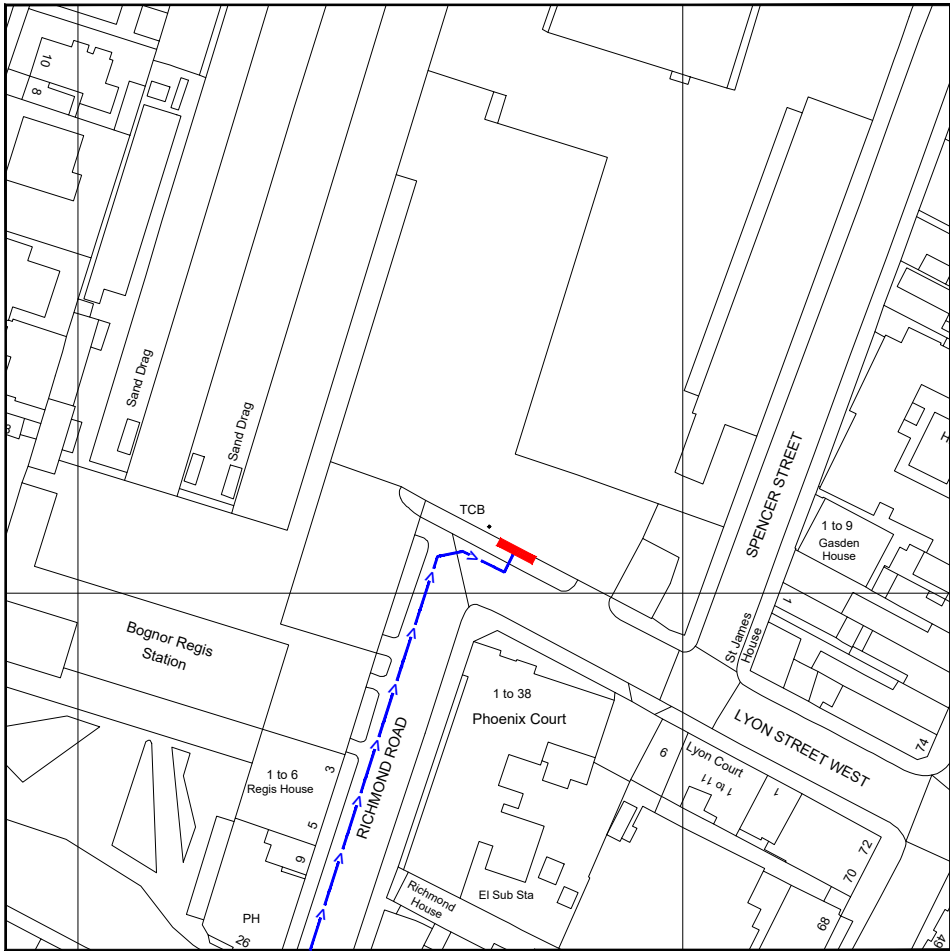

Reproduced by permission of Ordnance Survey on behalf of the Controller of Her Majesty's Stationary Office
All rights reserved. © Crown Copyright licence no. 100062043

NGR E: 493472 N: 099408

 SITE LOCATION PLAN



GOOGLE MAPS QR CODE

GOOGLE MAPS - <https://goo.gl/maps/1wZrJUVvpLbyKRFS8>

GOOGLE STREETVIEW - <https://goo.gl/maps/kaMzZ8TatQhfRtPF7>

NOTES:

1. ALL DIMENSIONS IN MM UNLESS OTHERWISE NOTED.

DIRECTIONS TO SITE:

Head south on A3(M). At junction 5, take the A27(E) exit to Brighton/Chichester/Havant/Hayling Is. At Bedhampton Roundabout, take the 2nd exit onto A27. Keep left. Merge onto Havant Bypass/A27. At Fishbourne Roundabout, take the 3rd exit onto Chichester Bypass/A27. At Stockbridge Roundabout, take the 2nd exit and stay on Chichester Bypass/A27. At Whyke Roundabout, take the 2nd exit and stay on Chichester Bypass/A27. At Bognor Rd Roundabout, take the 3rd exit onto Bognor Rd/A259. At Bognor Rd Roundabout, take the 3rd exit onto Bognor Rd/A259. At the roundabout, take the 3rd exit onto Chichester Rd/B2259. At the roundabout, take the 1st exit and stay on Chichester Rd/B2259. At the roundabout, take the 2nd exit and stay on Chichester Rd/B2259. At the roundabout, take the 3rd exit onto Chichester Rd/B2166. Turn left onto Station Rd. Turn left onto Richmond Rd. Turn right onto Lyon Street West and site location is on the left hand side.

Site Provider's

Property Boundary:



Access Route To Site:



Access Route:



Master:	MBNL / EE / H3G:	Project:	Purpose of Issue:	Issue:
M002	MBNL	H3G 5G UNILATERAL	Planning	B
Date:	01/04/2021	Revision / Upgrade Description:		
Drawn:	CDN	Pole Height reduced to 15m		
Checked:	DH			
Approved:	SD			
Master:	MBNL / EE / H3G:	Project:	Purpose of Issue:	Issue:
M001	MBNL	H3G 5G UNILATERAL	Planning	A
Date:	22/01/2021	Revision / Upgrade Description:		
Drawn:	CDN	First Issue - Site nomination dated: TBC		
Checked:	DH			
Approved:	SD			



Hutchison 3G UK Limited
Star House, 20 Grenfell Road
Maidenhead, SL6 1EH
Tel: 01628 765 000
Fax: 01628 765 001

H3G Base Station Information line:
0845 6043000
Available 8am-8pm Monday to Friday

Design Consultant & Principal Contractor:



WHP Telecoms
Unit 1 Maple Park,
Low Fields Avenue, Leeds
LS12 6HH

Tel: 01133023550
e-mail: info@whptelecoms.com

Site Name:
LYON STREET WEST STREETWORKS

Site ID:
ARN14860

Address:
LYON STREET WEST, BOGNOR REGIS,
FELPHAM,
ARUN, WEST SUSSEX,
SOUTH EAST,
PO21 1LF


Title:
002 SITE LOCATION PLAN

Project:
H3G 5G UNILATERAL

Purpose of Issue:
PLANNING

EE Cell ID:	MBNL Cell ID:	3UK Cell ID:
N/A	N/A	N/A

Master Drawing No:	Issue:
ARN14860_M002	B

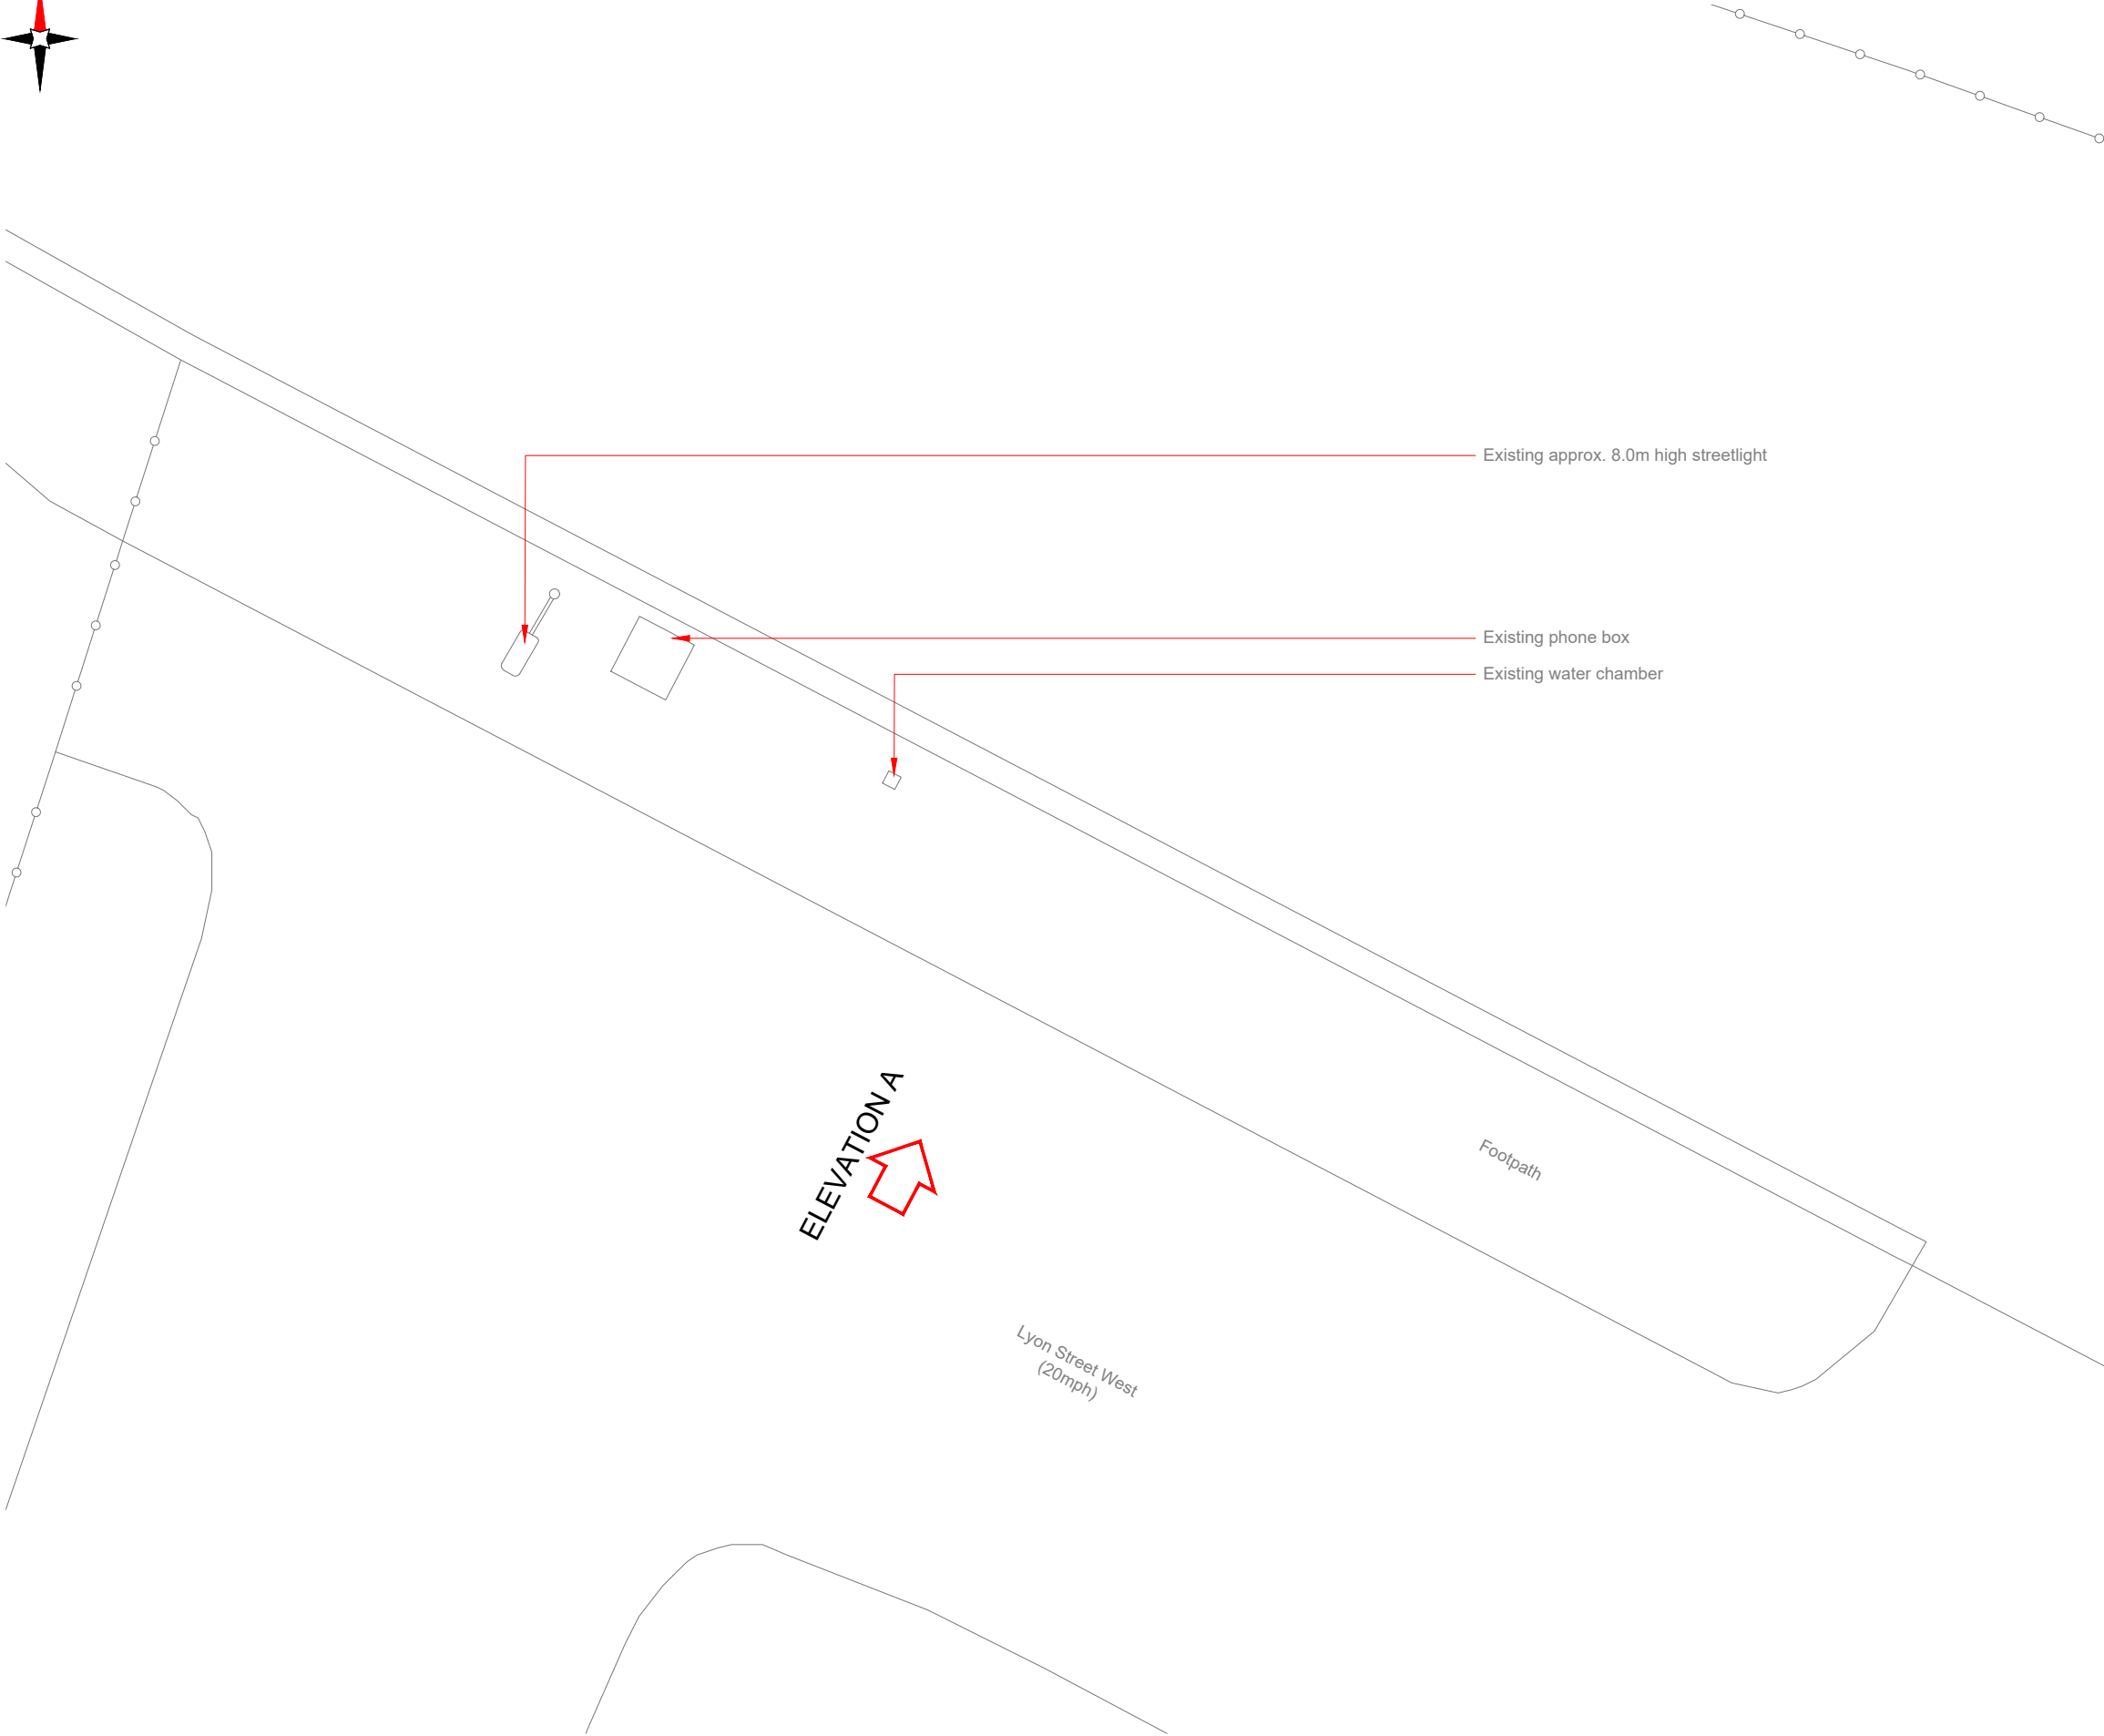

ELEVATION A

EXISTING SITE PLAN

- NOTES:
- ALL DIMENSIONS IN MM UNLESS OTHERWISE NOTED.

Master:	MBNL / EE / H3G:	Project:	Purpose of Issue:	Issue:
M002	MBNL	H3G 5G UNILATERAL	Planning	B
Date:	01/04/2021	Revision / Upgrade Description:		
Drawn:	CDN	Pole Height reduced to 15m		
Checked:	DH			
Approved:	SD			
Master:	MBNL / EE / H3G:	Project:	Purpose of Issue:	Issue:
M001	MBNL	H3G 5G UNILATERAL	Planning	A
Date:	22/01/2021	Revision / Upgrade Description:		
Drawn:	CDN	First Issue - Site nomination dated: TBC		
Checked:	DH			
Approved:	SD			



Hutchison 3G UK Limited
Star House, 20 Grenfell Road
Maidenhead, SL6 1EH
Tel: 01628 765 000
Fax: 01628 765 001

H3G Base Station Information line:
0845 6043000
Available 8am-8pm Monday to Friday

Design Consultant & Principal Contractor:



WHP Telecoms
Unit 1 Maple Park,
Low Fields Avenue, Leeds
LS12 6HH

Tel: 01133023550
e-mail: info@whptelecoms.com

Site Name:
LYON STREET WEST STREETWORKS

Site ID:
ARN14860

Address:
LYON STREET WEST, BOGNOR REGIS,
FELPHAM,
ARUN, WEST SUSSEX,
SOUTH EAST,
PO21 1LF

Title:
100 EXISTING SITE PLAN

Project:
H3G 5G UNILATERAL

Purpose of Issue:
PLANNING


EE Cell ID:	MBNL Cell ID:	3UK Cell ID:
N/A	N/A	N/A

Master Drawing No:	Issue:
ARN14860_M002	B


100mm

50mm

10mm

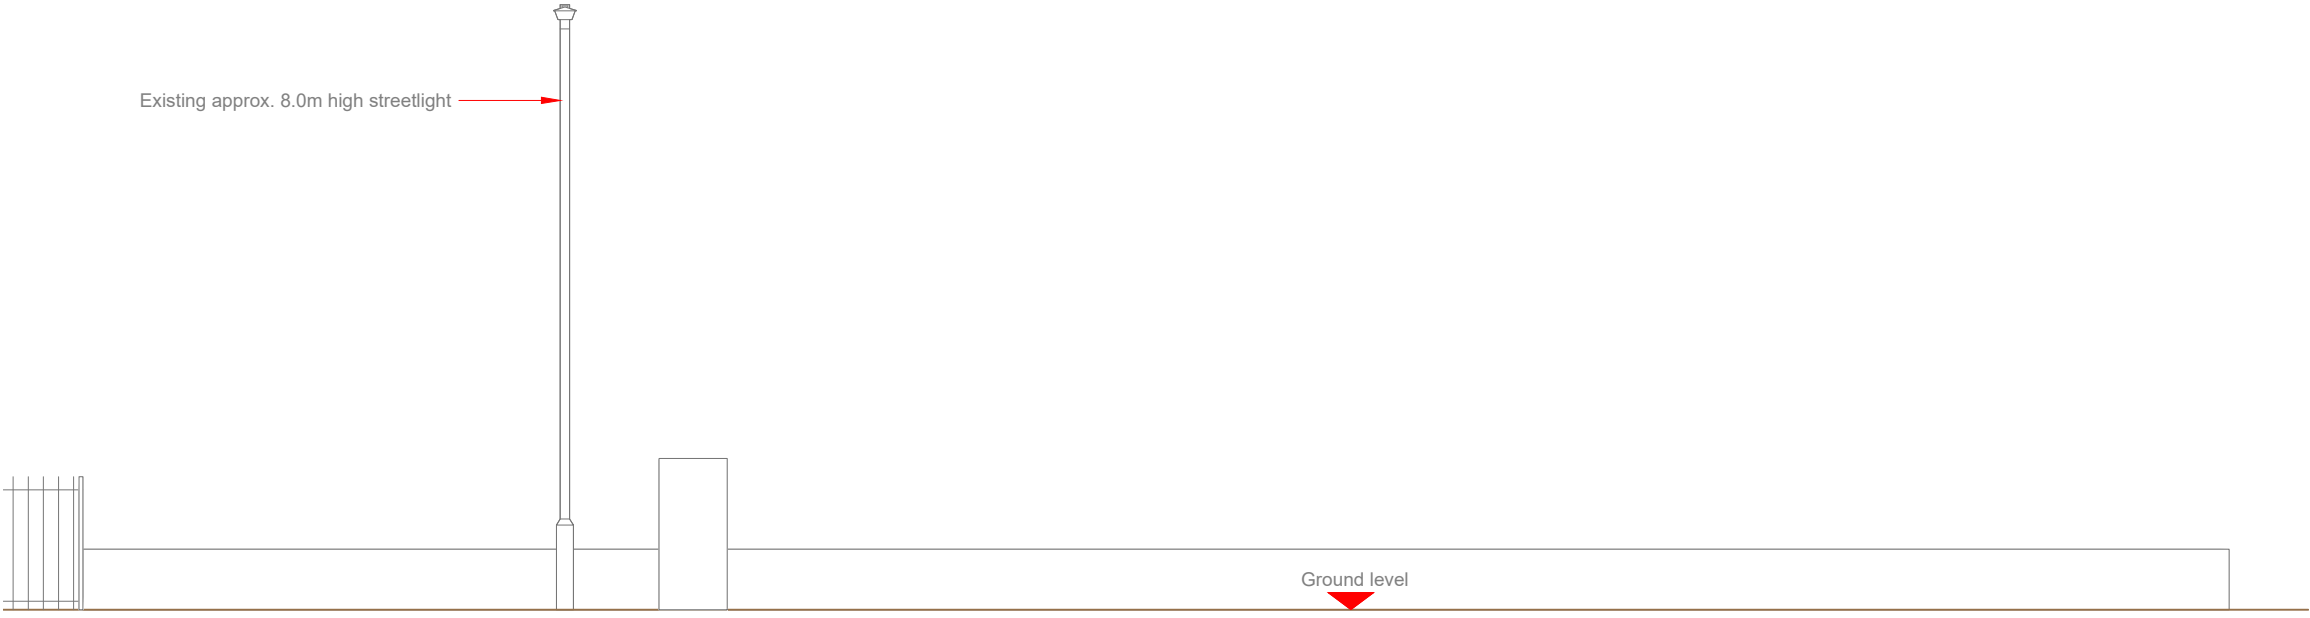

EXISTING ELEVATION A

 

- NOTES:
- ALL DIMENSIONS IN MM UNLESS OTHERWISE NOTED.

Master:	MBNL / EE / H3G:	Project:	Purpose of Issue:	Issue:
M002	MBNL	H3G 5G UNILATERAL	Planning	B
Date:	01/04/2021	Revision / Upgrade Description:		
Drawn:	CDN	Pole Height reduced to 15m		
Checked:	DH			
Approved:	SD			
Master:	MBNL / EE / H3G:	Project:	Purpose of Issue:	Issue:
M001	MBNL	H3G 5G UNILATERAL	Planning	A
Date:	22/01/2021	Revision / Upgrade Description:		
Drawn:	CDN	First Issue - Site nomination dated: TBC		
Checked:	DH			
Approved:	SD			



Hutchison 3G UK Limited
Star House, 20 Grenfell Road
Maidenhead, SL6 1EH
Tel: 01628 765 000
Fax: 01628 765 001

H3G Base Station Information line:
0845 6043000
Available 8am-8pm Monday to Friday



WHP Telecoms
Unit 1 Maple Park,
Low Fields Avenue, Leeds
LS12 6HH

Tel: 01133023550
e-mail: info@whptelecoms.com

Site Name:
LYON STREET WEST STREETWORKS

Site ID:
ARN14860

Address:
LYON STREET WEST, BOGNOR REGIS,
FELPHAM,
ARUN, WEST SUSSEX,
SOUTH EAST,
PO21 1LF

Title:
150 EXISTING ELEVATION A

Project:
H3G 5G UNILATERAL

Purpose of Issue:
PLANNING

EE Cell ID:	MBNL Cell ID:	3UK Cell ID:
N/A	N/A	N/A


Master Drawing No:	Issue:
ARN14860_M002	B




Antenna Aperture ID	Proposed 4G/5G Bearing	Operator: Shared/ EE/H3G
A1	20°	H3G
A2	20°	H3G
B1	140°	H3G
B2	140°	H3G
C1	260°	H3G
C2	260°	H3G

NOTES:

1. ALL DIMENSIONS IN MM UNLESS OTHERWISE NOTED.

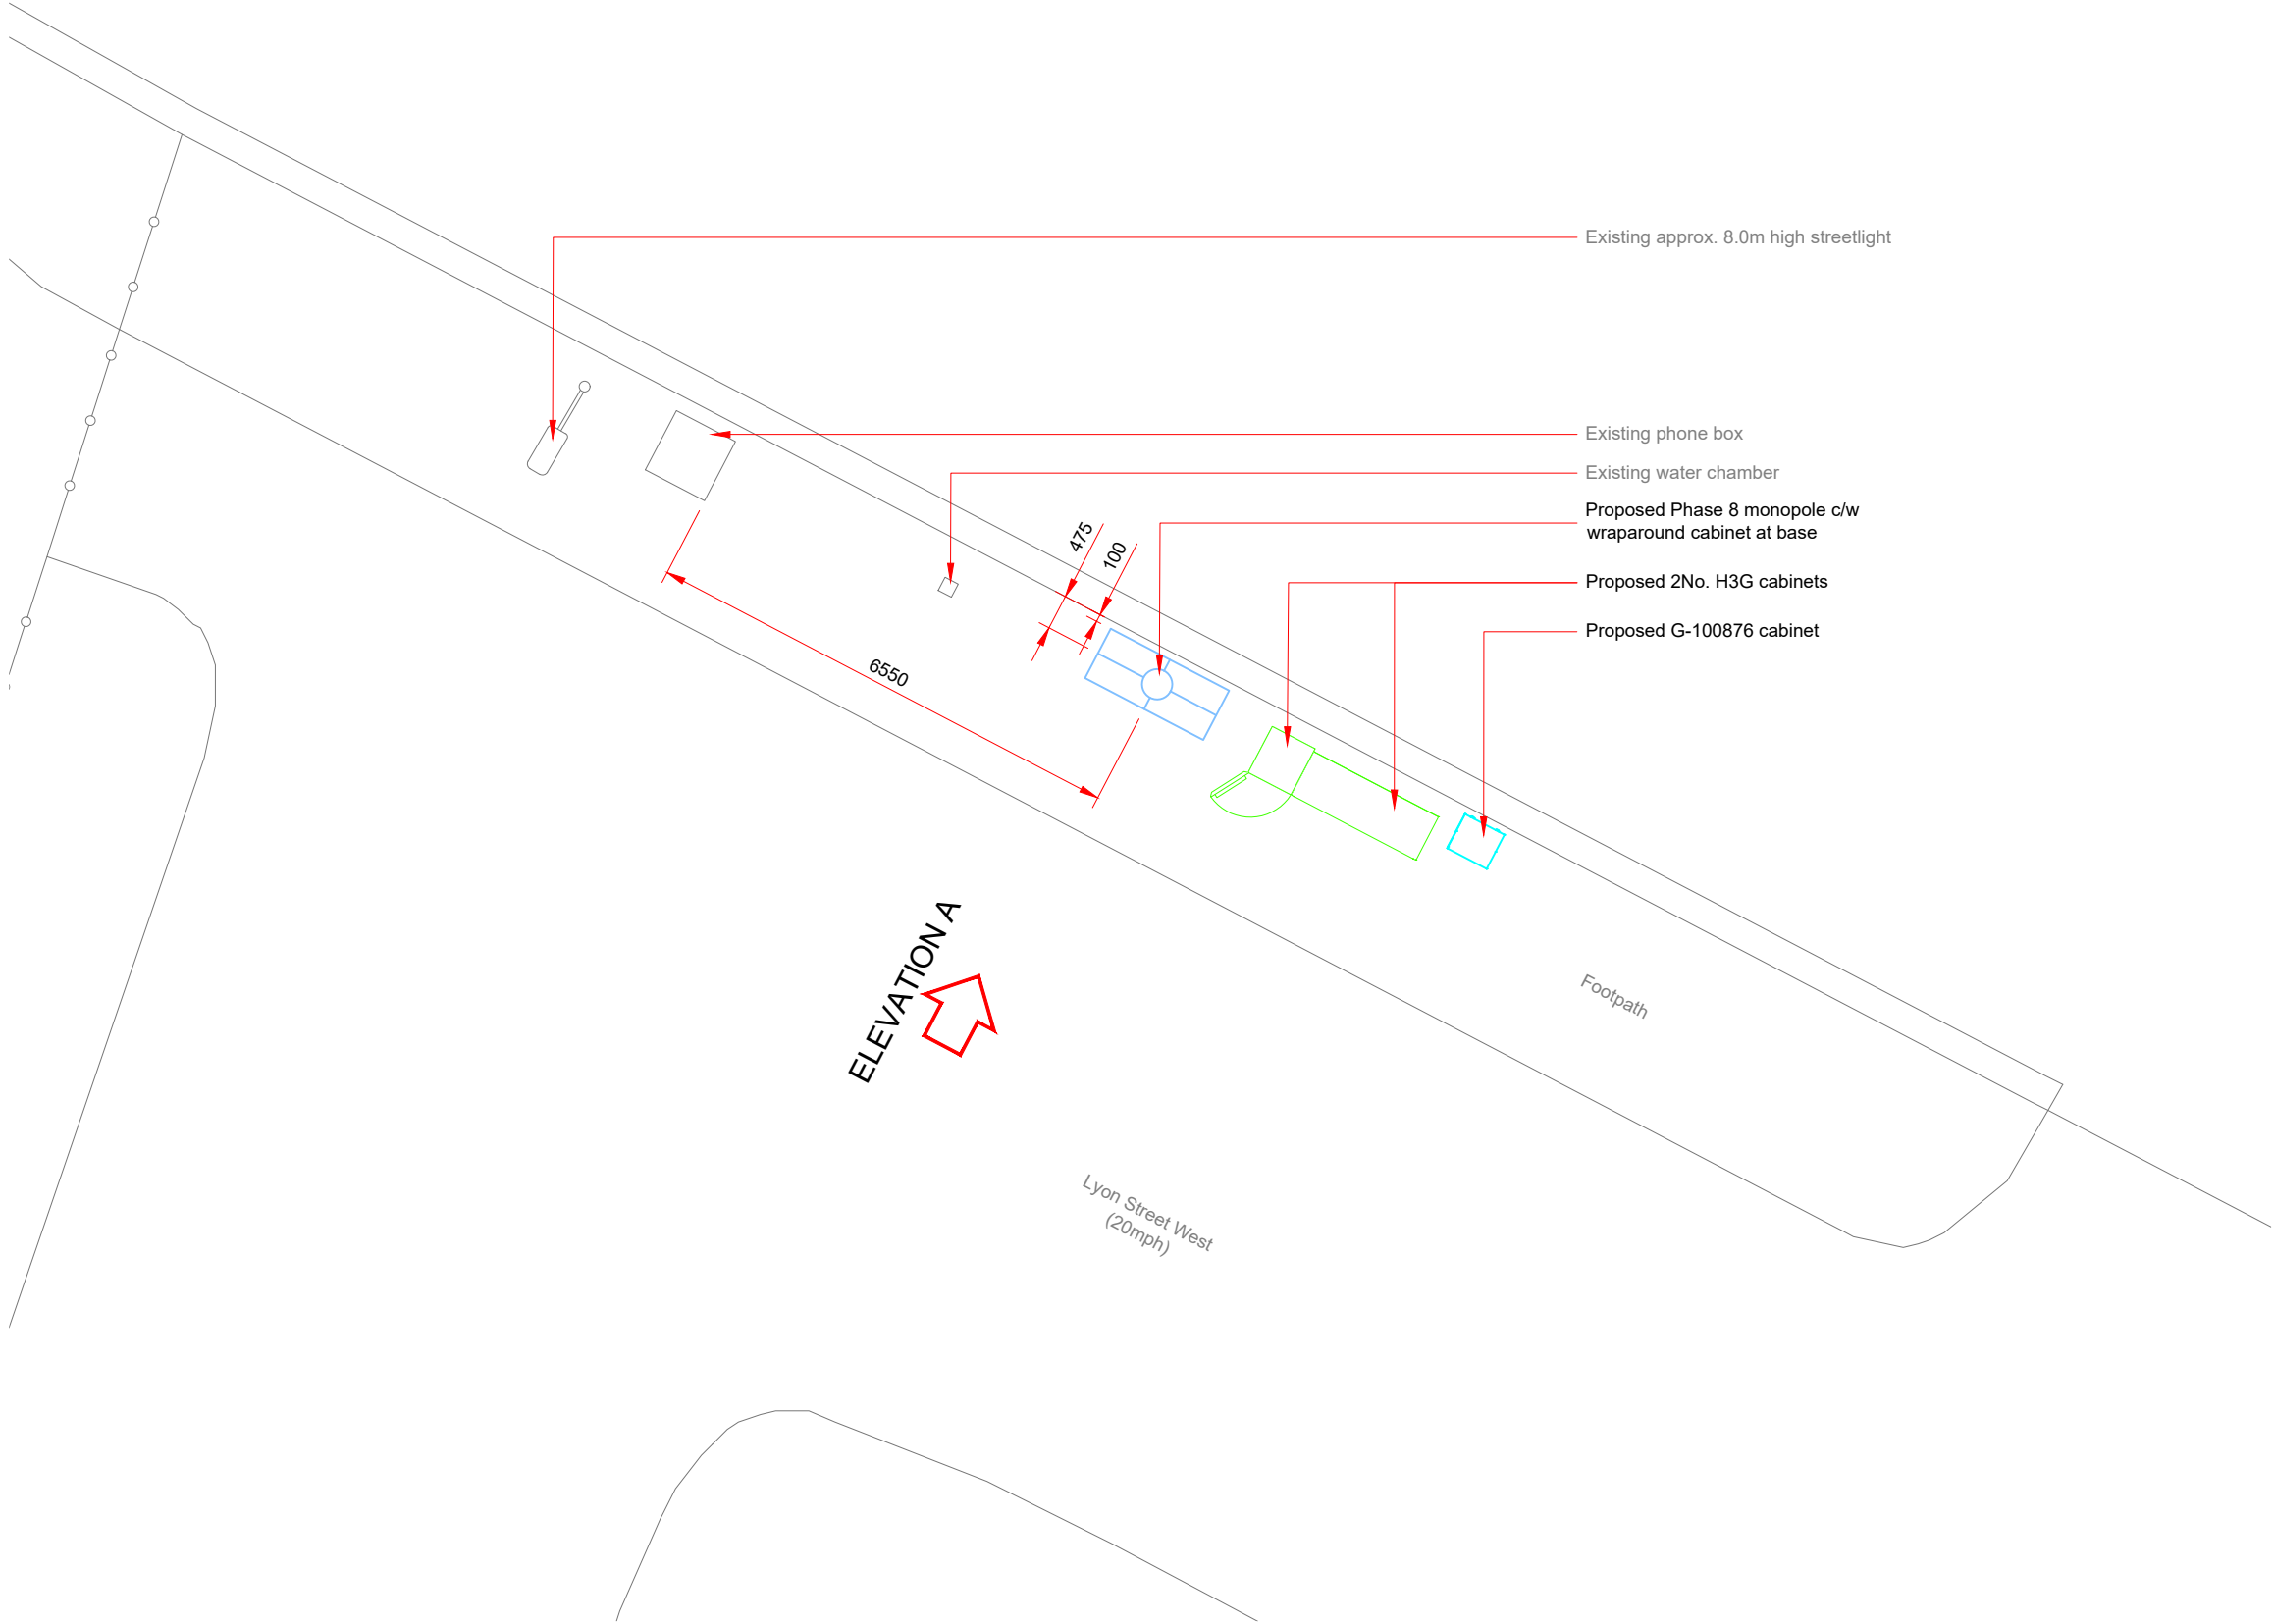

PROPOSED H3G SITE PLAN

 

Master:	MBNL / EE / H3G:	Project:	Purpose of Issue:	Issue:
M002	MBNL	H3G 5G UNILATERAL	Planning	B
Date:	01/04/2021	Revision / Upgrade Description:		
Drawn:	CDN	First Issue - Site nomination dated: TBC		
Checked:	DH			
Approved:	SD			
Master:	MBNL / EE / H3G:	Project:	Purpose of Issue:	Issue:
M001	MBNL	H3G 5G UNILATERAL	Planning	A
Date:	22/01/2021	Revision / Upgrade Description:		
Drawn:	CDN	First Issue - Site nomination dated: TBC		
Checked:	DH			
Approved:	SD			



Hutchison 3G UK Limited
Star House, 20 Grenfell Road
Maidenhead, SL6 1EH
Tel: 01628 765 000
Fax: 01628 765 001

H3G Base Station Information line:
0845 6043000
Available 8am-8pm Monday to Friday

Design Consultant & Principal Contractor:



WHP Telecoms
Unit 1 Maple Park,
Low Fields Avenue, Leeds
LS12 6HH

Tel: 01133023550
e-mail: info@whptelecoms.com

Site Name:
LYON STREET WEST STREETWORKS

Site ID:
ARN14860

Address:
LYON STREET WEST, BOGNOR REGIS,
FELPHAM,
ARUN, WEST SUSSEX,
SOUTH EAST,
PO21 1LF

Title:
210 PROPOSED H3G SITE PLAN

Project:
H3G 5G UNILATERAL

Purpose of Issue:
PLANNING


EE Cell ID:	MBNL Cell ID:	3UK Cell ID:
N/A	N/A	N/A

Master Drawing No:	Issue:
ARN14860_M002	B

Antenna Aperture ID	Proposed 4G/5G Bearing	Operator: Shared/ EE/H3G
A1	20°	H3G
A2	20°	H3G
B1	140°	H3G
B2	140°	H3G
C1	260°	H3G
C2	260°	H3G

NOTES:

1. ALL DIMENSIONS IN MM UNLESS OTHERWISE NOTED.

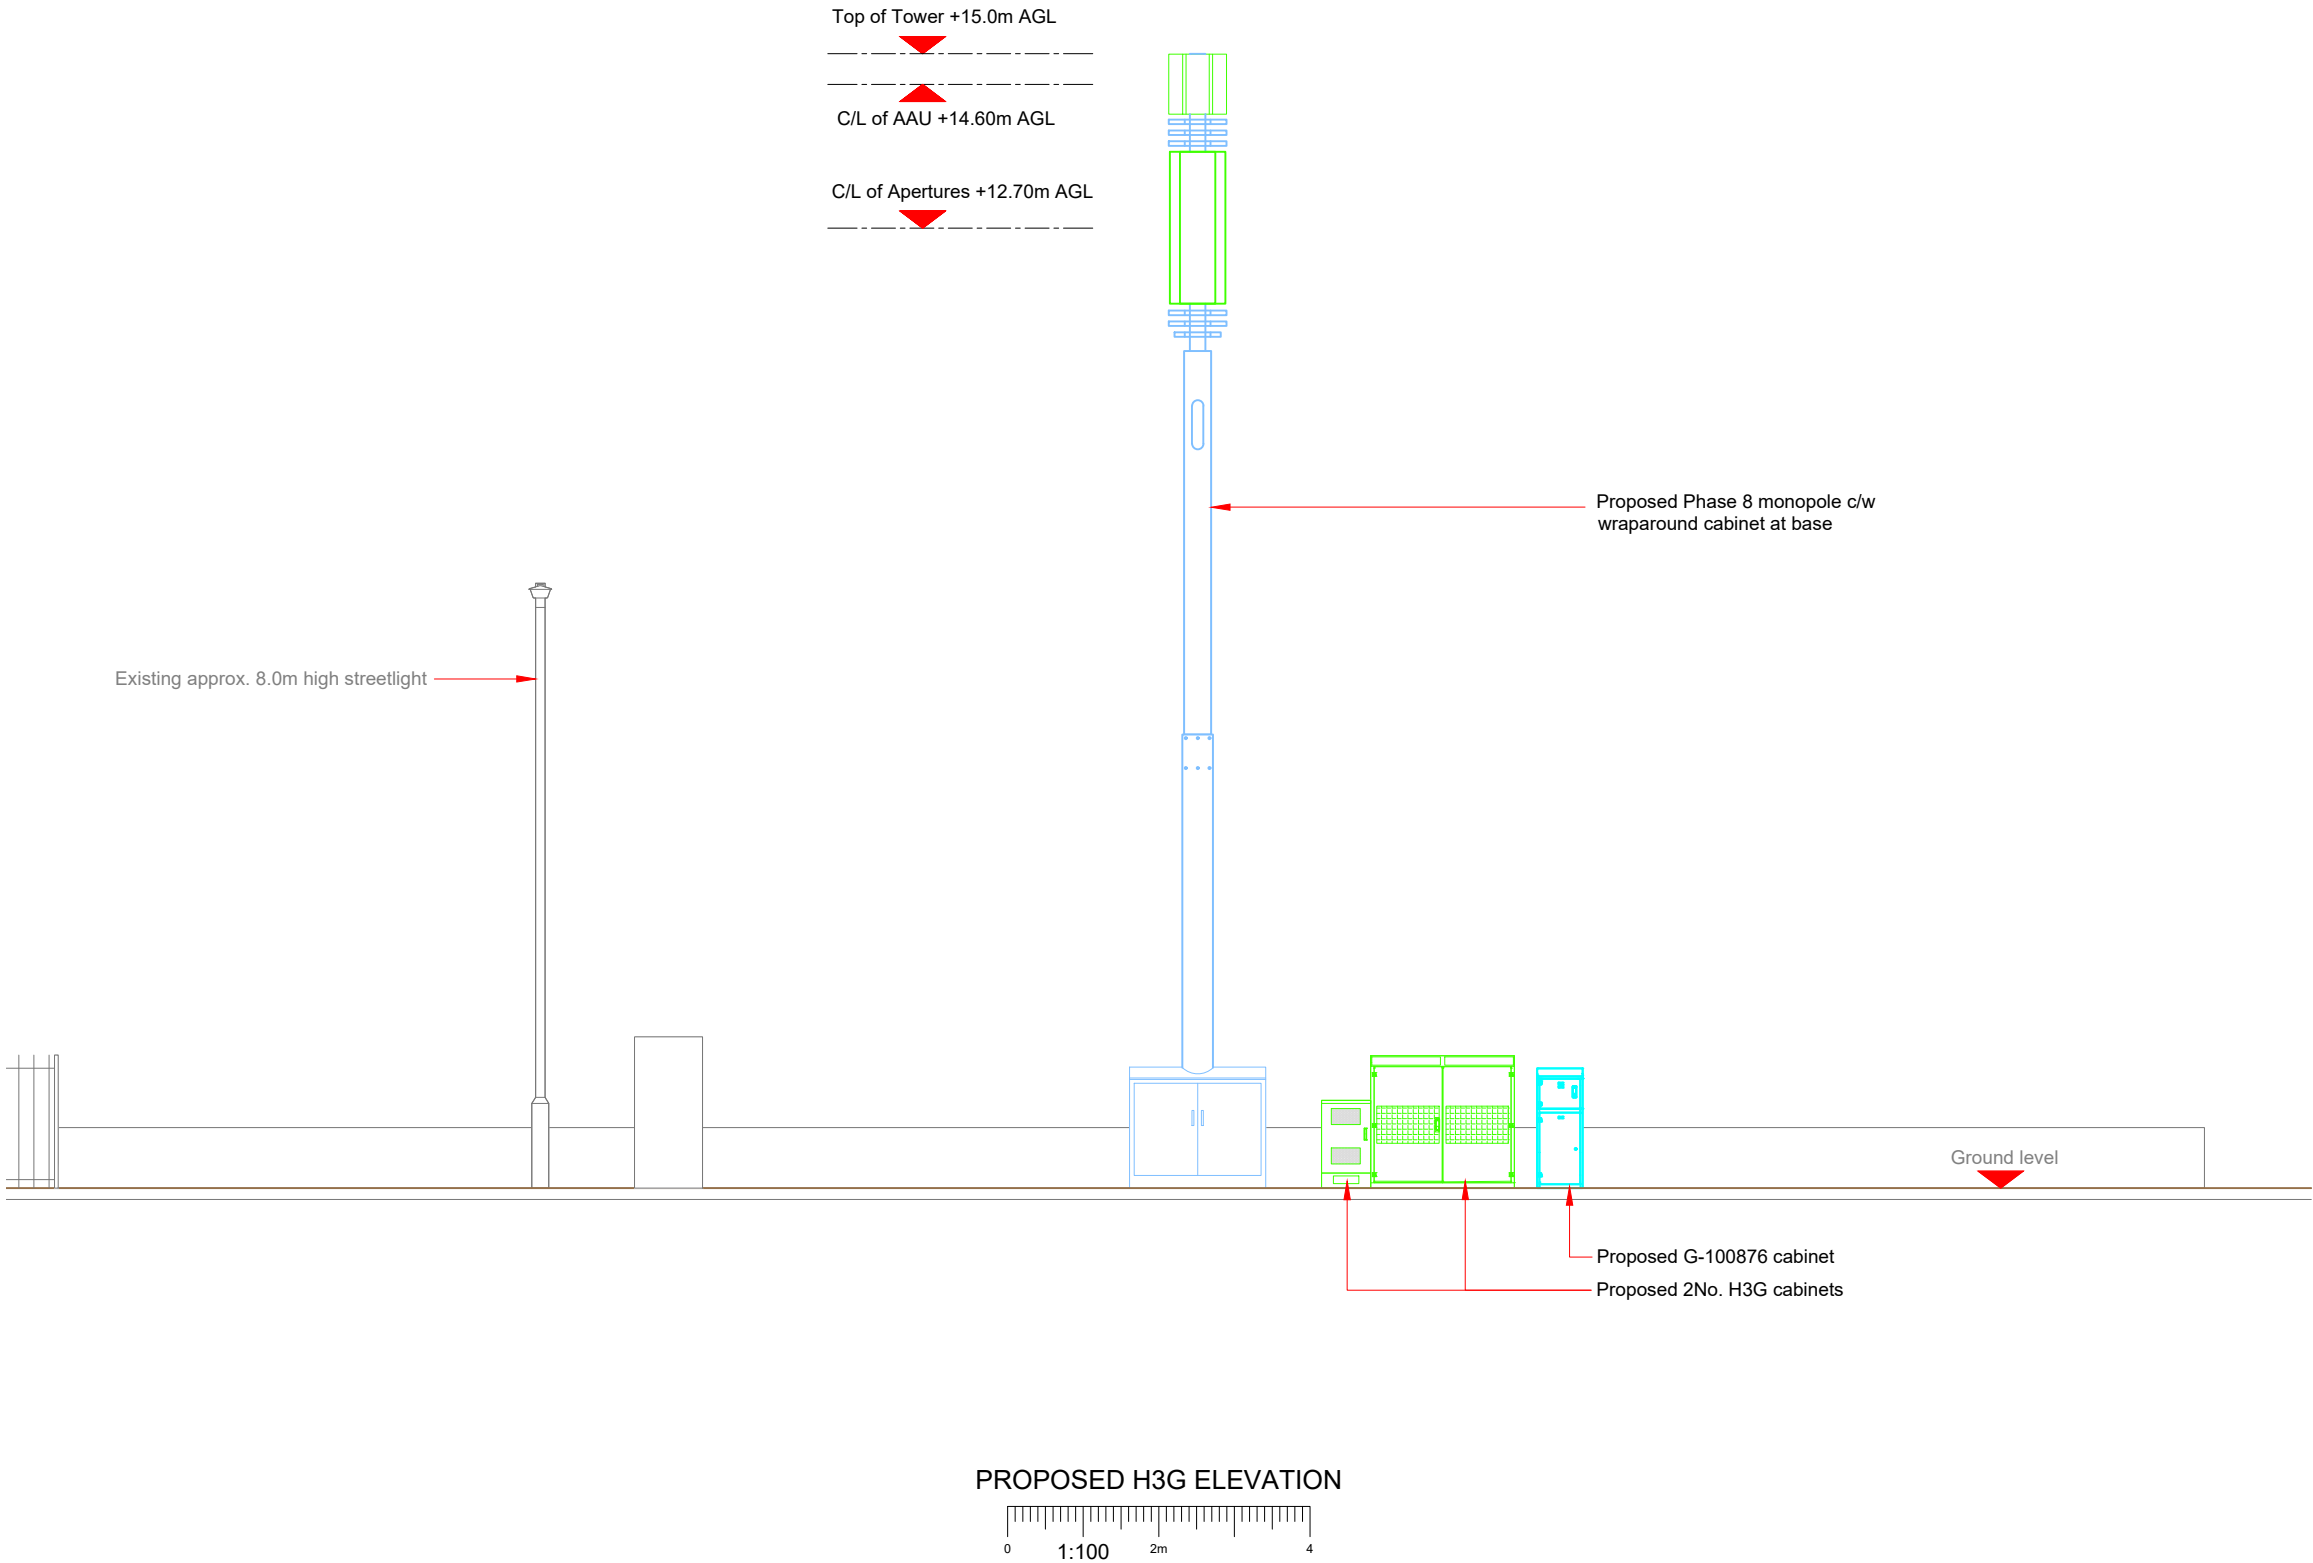

Master:	MBNL / EE / H3G:	Project:	Purpose of Issue:	Issue:
M002	MBNL	H3G 5G UNILATERAL	Planning	B
Date:	01/04/2021	Revision / Upgrade Description:		
Drawn:	CDN	First Issue - Site nomination dated: TBC		
Checked:	DH			
Approved:	SD			
Master:	MBNL / EE / H3G:	Project:	Purpose of Issue:	Issue:
M001	MBNL	H3G 5G UNILATERAL	Planning	A
Date:	22/01/2021	Revision / Upgrade Description:		
Drawn:	CDN	First Issue - Site nomination dated: TBC		
Checked:	DH			
Approved:	SD			



Hutchison 3G UK Limited
Star House, 20 Grenfell Road
Maidenhead, SL6 1EH
Tel: 01628 765 000
Fax: 01628 765 001

H3G Base Station Information line:
0845 6043000
Available 8am-8pm Monday to Friday

Design Consultant & Principal Contractor:

 **WHP Telecoms**
Unit 1 Maple Park,
Low Fields Avenue, Leeds
LS12 6HH

Tel: 01133023550
e-mail: info@whptelecoms.com

Site Name:
LYON STREET WEST STREETWORKS

Site ID:
ARN14860

Address:
**LYON STREET WEST, BOGNOR REGIS,
FELPHAM,
ARUN, WEST SUSSEX,
SOUTH EAST,
PO21 1LF**

Title:
260 PROPOSED H3G ELEVATION


Project:
H3G 5G UNILATERAL

Purpose of Issue:
PLANNING

EE Cell ID:	MBNL Cell ID:	3UK Cell ID:
N/A	N/A	N/A

Master Drawing No:	Issue:
ARN14860_M002	B

Proposed H3G Antenna Aperture Schedule & RF Equipment Capacity																	
Antenna Aperture ID	Antenna Aperture Size (Length x Width x Depth)	Aperture Height C/L	Aperture Max Weight (kg)	Proposed 4G/5G Bearing	Tech: 4G/5G	Operator: Shared/ EE/H3G	Antenna Aperture Coordinates		RRU No. Max Size & Weight L=320mm W=400mm D=150mm Weight=25kg	MHA No. Max Size & Weight L=300mm W=300mm D=150mm Weight=10kg	Main Feeder			BOB Max Size & Weight (300x300x250mm & 5kg)		Active Router No. Max Size & Weight (370x260x150mm & 10kg)	Passive Router No. Max Size & Weight (350x220x150mm & 10kg)
							Eastings	Northings			Size	Length	No.	No. Top	No. Bottom		
A1	795x395x220mm	14.60m	45kg	20°	5G	H3G	-	-	0	0	TBC	TBC	4	1	1	1	1
A2	2009x469x206mm	12.70m	TBC	20°	4G	H3G	-	-	3	0	TBC	TBC	4	1	1	1	1
B1	795x395x220mm	14.60m	45kg	140°	5G	H3G	-	-	0	0	TBC	TBC	4	1	1	1	1
B2	2009x469x206mm	12.70m	TBC	140°	4G	H3G	-	-	3	0	TBC	TBC	4	1	1	1	1
C1	795x395x220mm	14.60m	45kg	260°	5G	H3G	-	-	0	0	TBC	TBC	4	1	1	1	1
C2	2009x469x206mm	12.70m	TBC	260°	4G	H3G	-	-	3	0	TBC	TBC	4	1	1	1	1

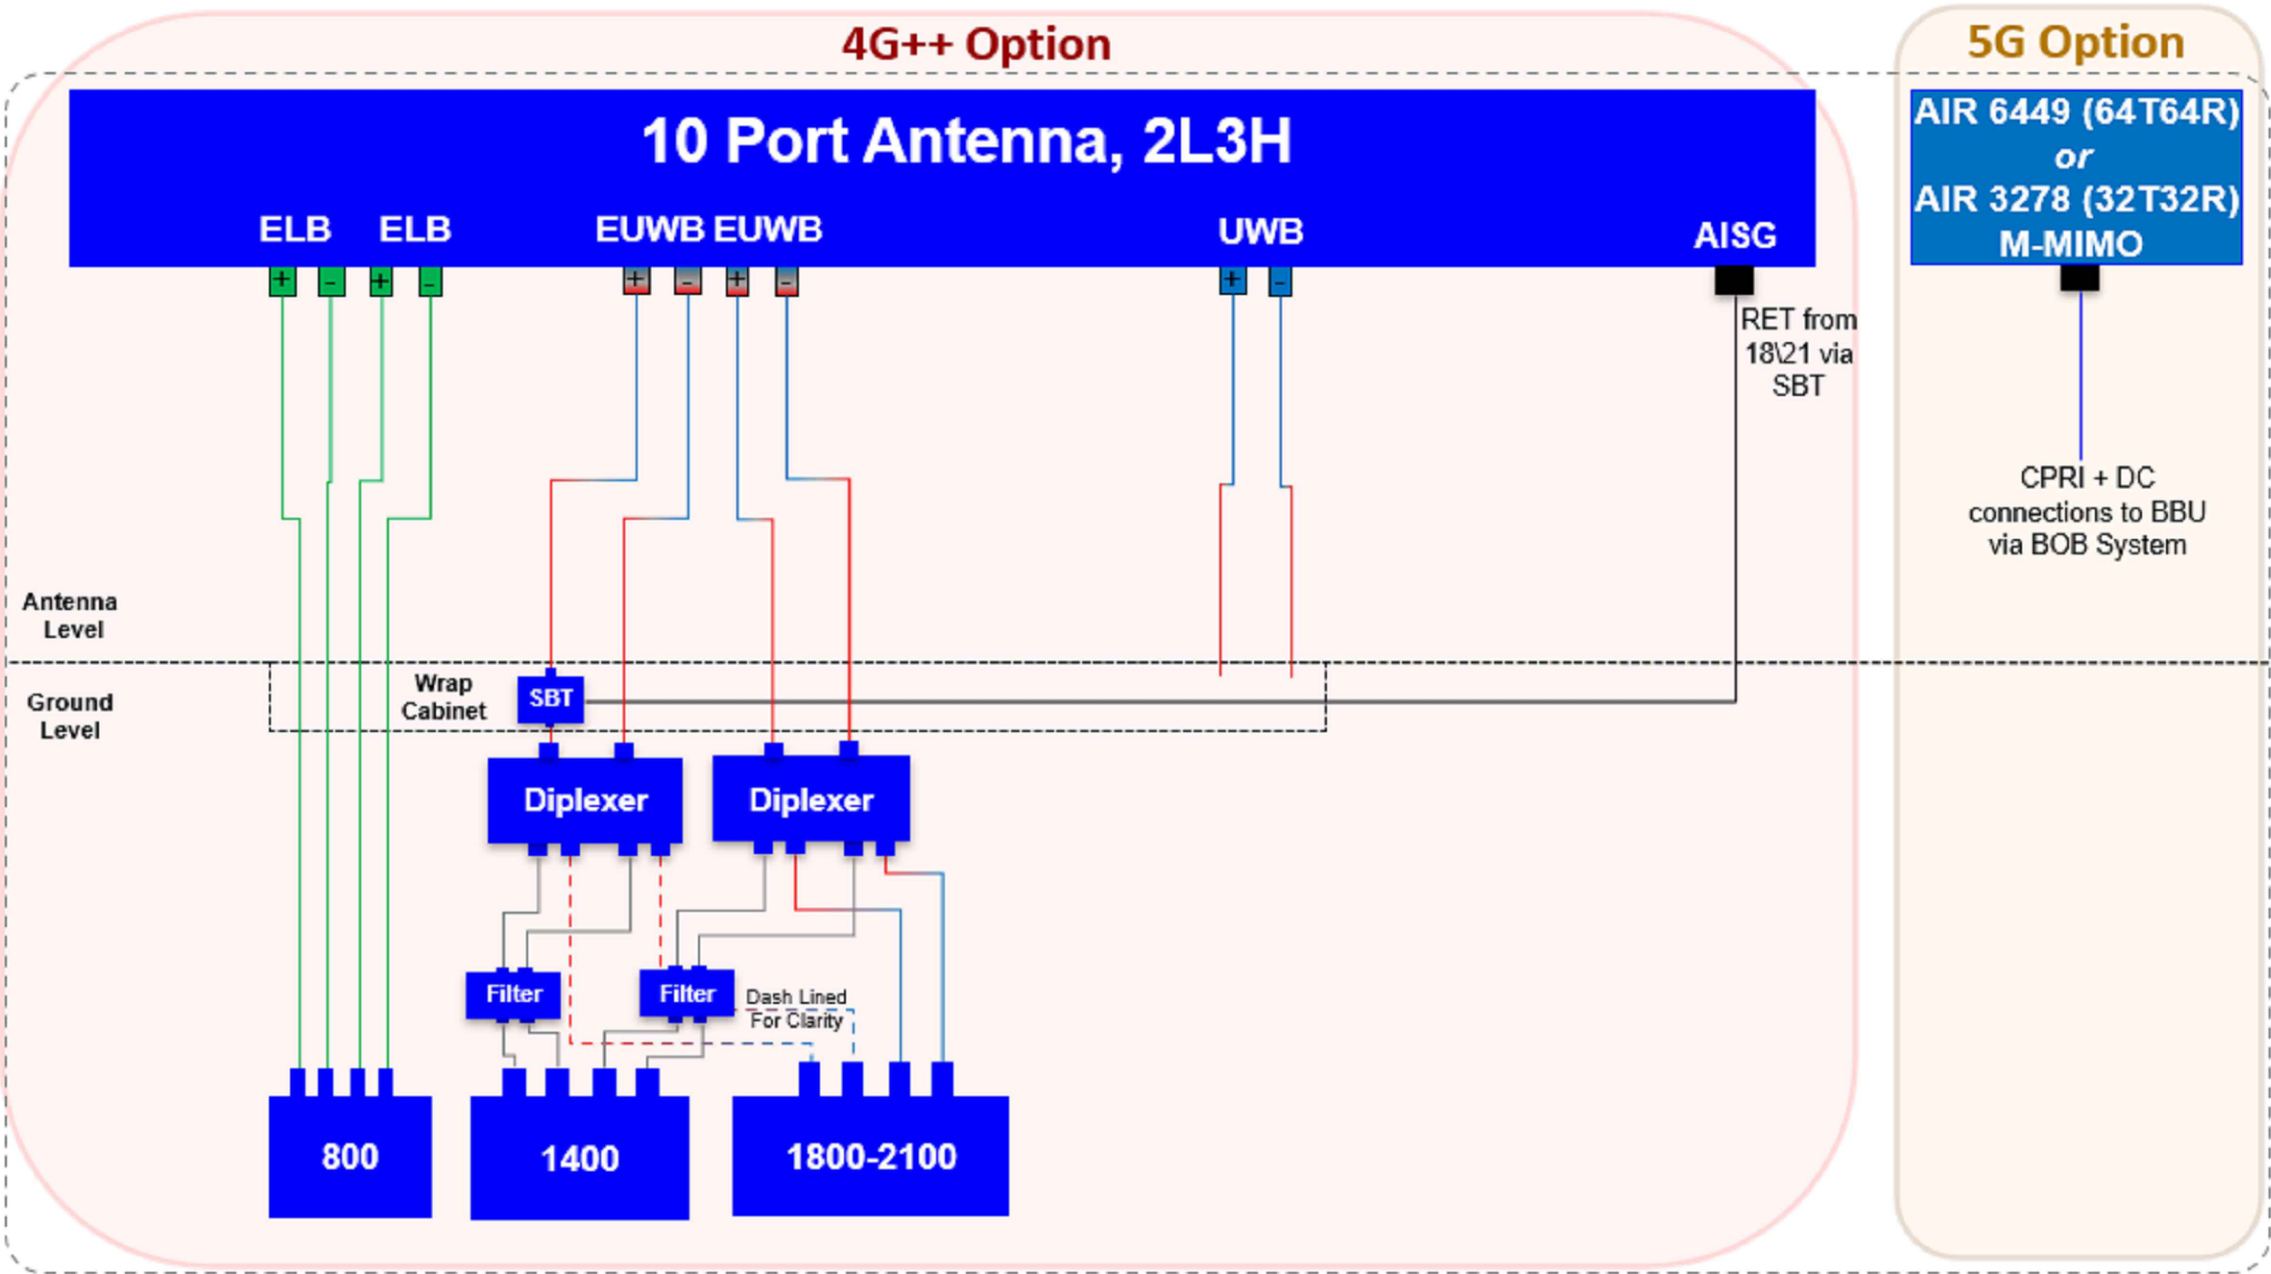

STATUS KEY:

Installed: Existing
Retain: Existing and to remain
Relocate: Existing and to be relocated
Remove: Existing to be removed from site
Proposed: New on site

Master:	MBNL / EE / H3G:	Project:	Purpose of Issue:	Issue:
M002	MBNL	H3G 5G UNILATERAL	Planning	B
Date:	01/04/2021	Revision / Upgrade Description:		
Drawn:	CDN	First Issue - Site nomination dated: TBC		
Checked:	DH			
Approved:	SD			
Master:	MBNL / EE / H3G:	Project:	Purpose of Issue:	Issue:
M001	MBNL	H3G 5G UNILATERAL	Planning	A
Date:	22/01/2021	Revision / Upgrade Description:		
Drawn:	CDN	First Issue - Site nomination dated: TBC		
Checked:	DH			
Approved:	SD			



Hutchison 3G UK Limited
Star House, 20 Grenfell Road
Maidenhead, SL6 1EH
Tel: 01628 765 000
Fax: 01628 765 001

H3G Base Station Information line:
0845 6043000
Available 8am-8pm Monday to Friday

Design Consultant & Principal Contractor:



WHP Telecoms
Unit 1 Maple Park,
Low Fields Avenue, Leeds
LS12 6HH

Tel: 01133023550
e-mail: info@whptelecoms.com

Site Name:
LYON STREET WEST STREETWORKS

Site ID:
ARN14860

Address:
**LYON STREET WEST, BOGNOR REGIS,
FELPHAM,
ARUN, WEST SUSSEX,
SOUTH EAST,
PO21 1LF**

Title:
**303 PROPOSED H3G ANTENNA
SCHEDULE & LINE CONFIGURATION**

Project:
H3G 5G UNILATERAL

Purpose of Issue:
PLANNING

EE Cell ID:	MBNL Cell ID:	3UK Cell ID:
N/A	N/A	N/A

Master Drawing No:	Issue:
ARN14860_M002	B

Support Structure Schedule													STATUS KEY: Installed: Existing Retain: Existing and to remain Relocate: Existing and to be relocated Remove: Existing to be removed from site Proposed: New on site				
----------------------------	--	--	--	--	--	--	--	--	--	--	--	--	--	--	--	--	--

LOCATION KEY:

Outdoor:

Located outside

Indoor:

Located within an equipment cabin or equipment room

Internal:

located inside a cabinet or item of equipment

100mm

150mm

10mm