


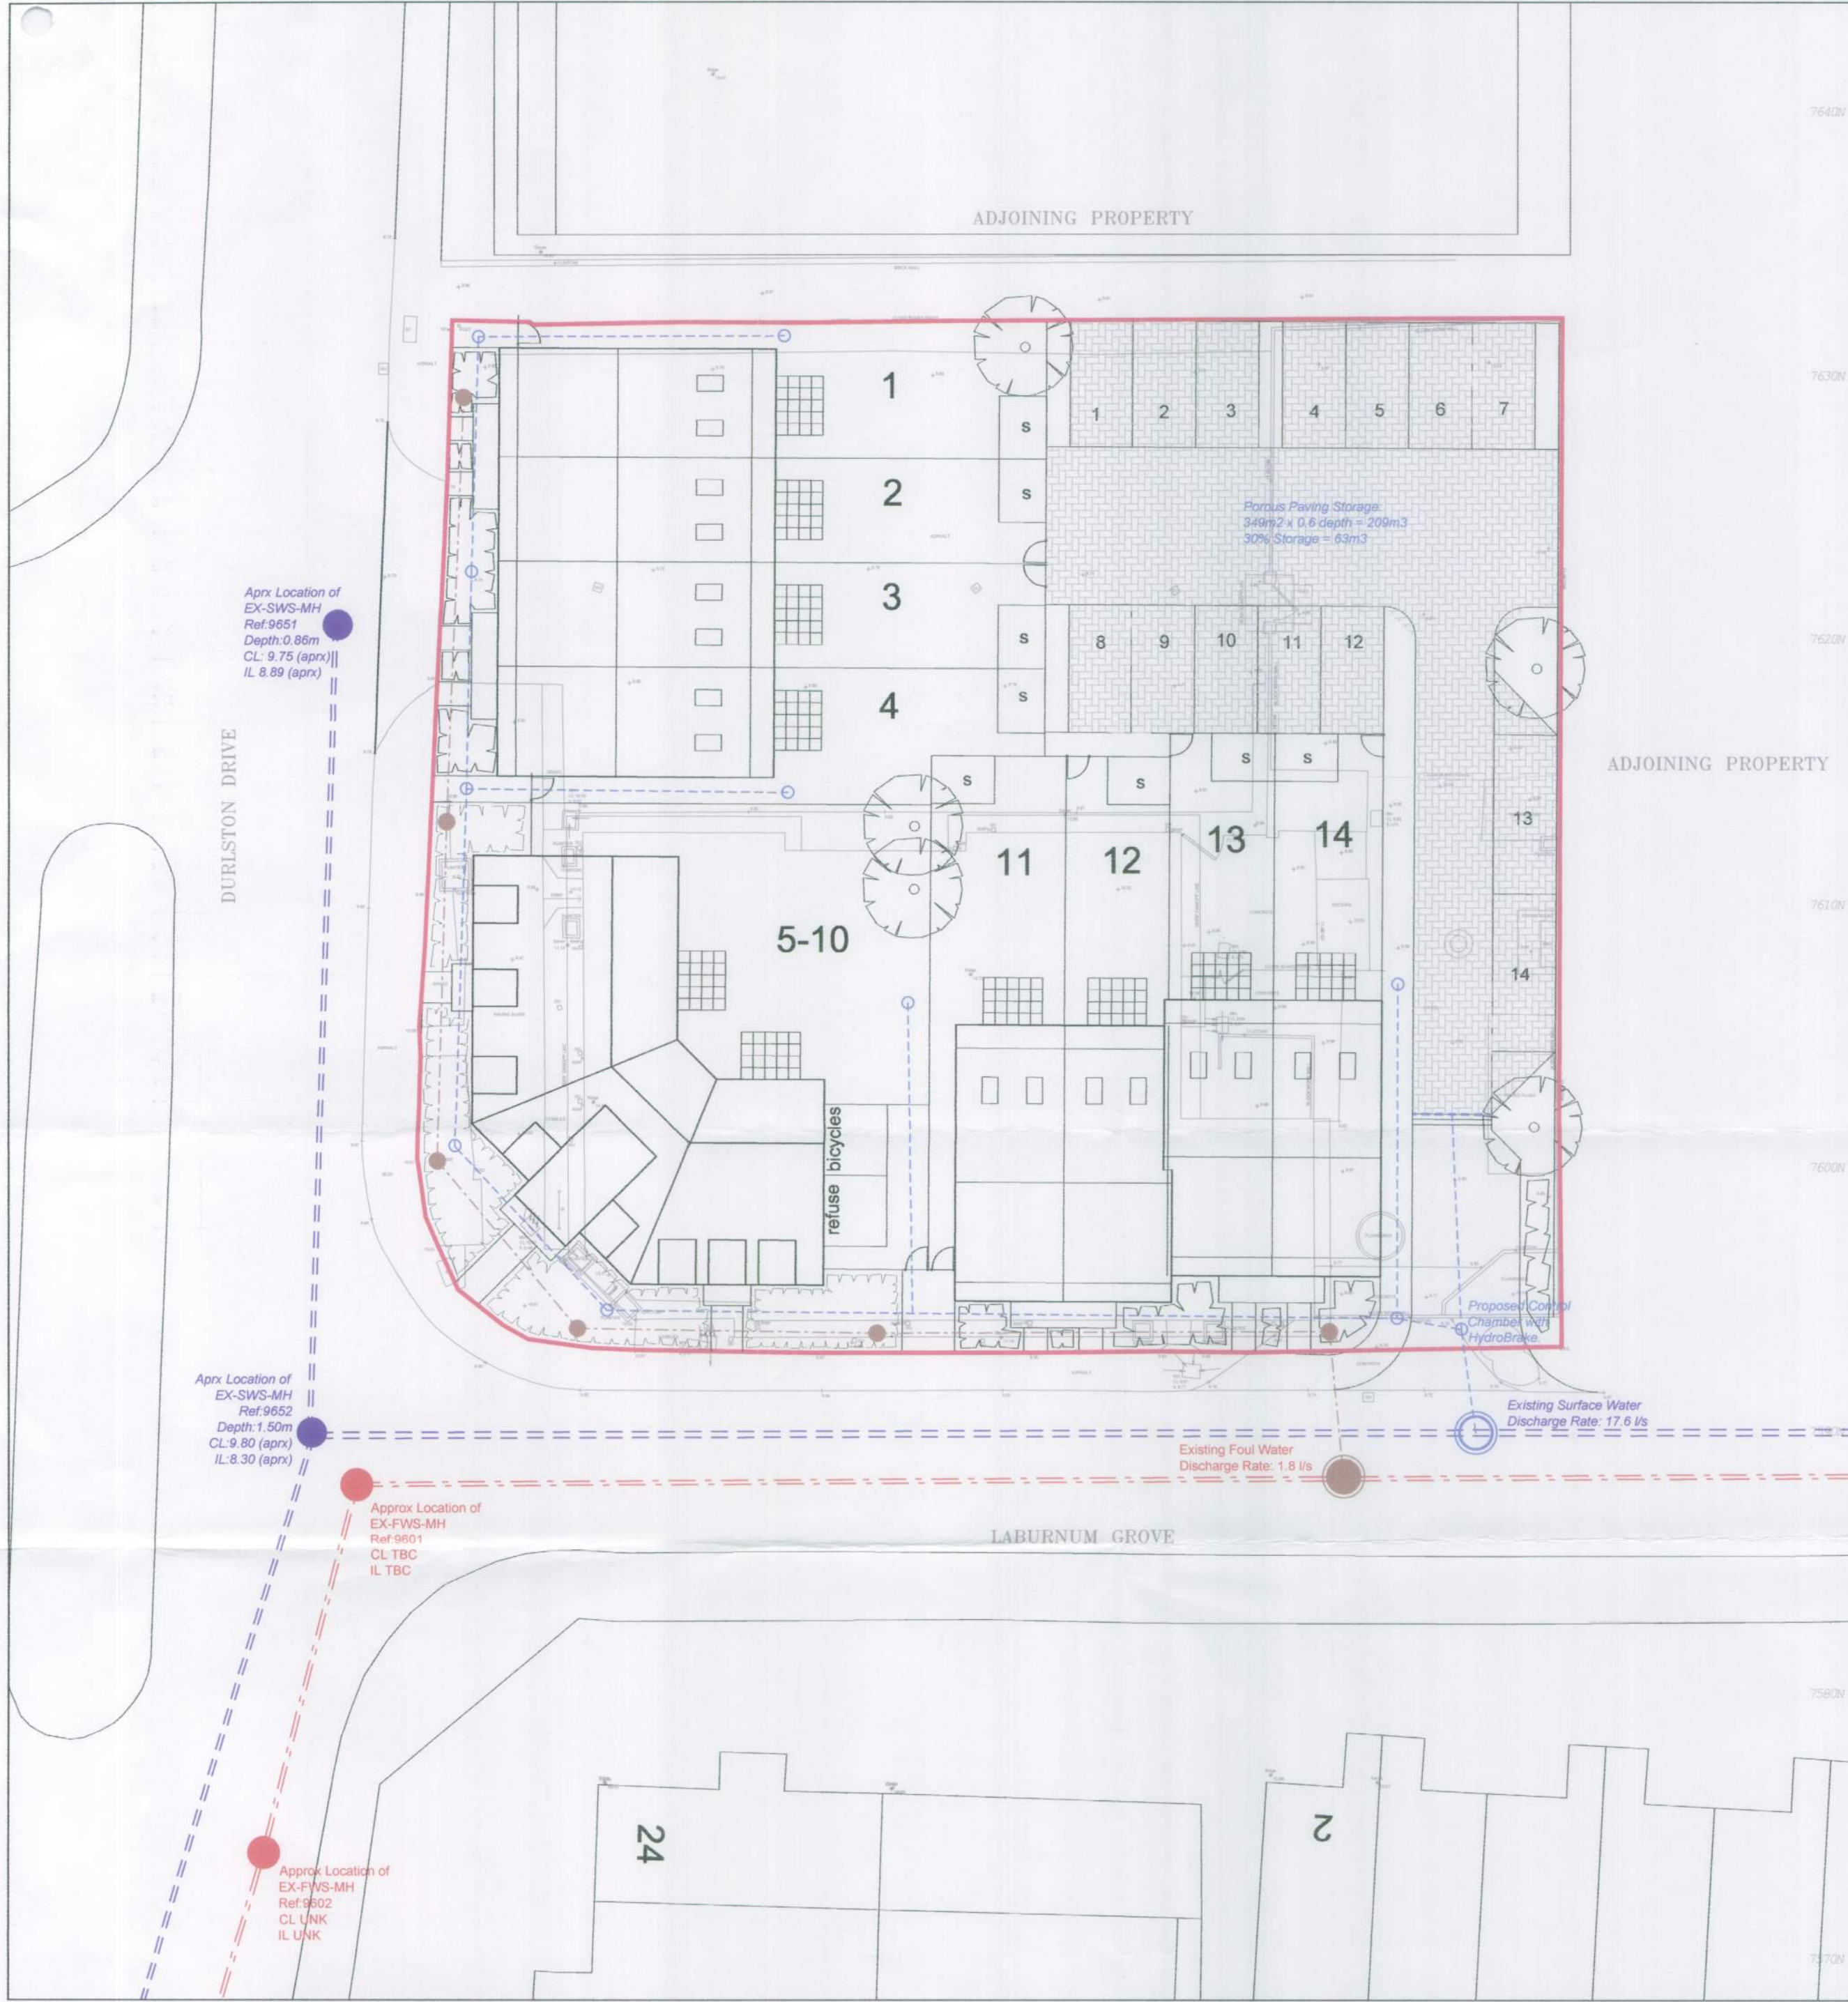

DRAWING LEGEND	
SURFACE WATER DRAINAGE	
CL##.## IL##.##	PRECAST CONCRETE RING MANHOLE, CP DENOTED CATCHPIT
RG	450x900 ROAD GULLY
CL##.## IL##.##	INSPECTION CHAMBER (MAX 1.2m DEPTH TO INVERT, CP DENOTES CATCHPIT)
CL##.## IL##.##	SHALLOW INSPECTION CHAMBER (MAX 0.6m DEPTH TO INVERT)
CL##.## IL##.##	BRICK OR PRECAST CONCRETE SECTION MANHOLE (1.2m - 1.5m DEPTH TO SOFFIT)
RE IL##.##	RODDING EYE
EX-SWS-MH CL##.## IL##.##	EXISTING SURFACE WATER MANHOLE
=====	EXISTING SURFACE WATER PIPE
	FORMPAVE POROUS BLOCK PAVING (STORAGE)
	TARMAC ROAD
FOUL WATER DRAINAGE	
CL##.## IL##.##	PRECAST CONCRETE RING MANHOLE (OVER 1.5m DEPTH TO SOFFIT)
CL##.## IL##.##	INSPECTION CHAMBER (MAX 1.2m DEPTH TO INVERT)
CL##.## IL##.##	SHALLOW INSPECTION CHAMBER (MAX 0.6m DEPTH TO INVERT)
CL##.## IL##.##	BRICK OR PRECAST CONCRETE SECTION MANHOLE (1.2m - 1.5m DEPTH TO SOFFIT)
EX-FWS-MH CL##.## IL##.##	EXISTING FOUL WATER MANHOLE
=====	EXISTING FOUL WATER SEWER

- NOTES:
- THIS DRAWING IS TO BE READ IN CONJUNCTION WITH ALL OTHER SWP DRAWINGS, AND WITH ALL RELEVANT ARCHITECT'S AND ENGINEER'S DRAWINGS AND SPECIFICATION AND ANY DISCREPANCIES FOUND ARE TO BE REPORTED IMMEDIATELY TO THE ENGINEER.
 - NO DIMENSIONS ARE TO BE SCALED FROM THIS DRAWING. UNLESS NOTED OTHERWISE ALL DIMENSIONS ARE IN MILLIMETERS AND ALL LEVELS ARE IN METRES FROM THE SITE DATUM.
 - ALL DIMENSIONS TO BE CHECKED ON SITE. ALL DETAILS AND DIMENSIONS RELATING TO SUB-CONTRACTORS WORK MUST BE CHECKED AND AGREED BETWEEN THE SUB-CONTRACTOR OR SUPPLIER AND THE GENERAL CONTRACTOR.
 - THE ELECTRONIC INFORMATION FROM THIS DRAWING CAN NOT BE GUARANTEED AS DIMENSIONALLY DRAWN EXACT. FIGURED DIMENSIONS MUST BE USED FOR SETTING OUT AND DETAILING. SWP LOGOS AND COMPANY INFORMATION MUST BE REMOVED FROM COPIES IF INFORMATION IS RE-USED.
 - THE MAIN CONTRACTOR IS RESPONSIBLE FOR THE DESIGN OF ALL TEMPORARY WORKS, AND IS ALSO RESPONSIBLE FOR THE SAFE MAINTENANCE AND STABILITY OF EXISTING BUILDINGS AT ALL TIMES.
 - THE MAIN CONTRACTOR IS RESPONSIBLE FOR ALL OCCURRENCES OF GROUND WATER DURING THE CONSTRUCTION PERIOD.
 - ANY INFORMATION GIVEN REGARDING EXISTING UNDERGROUND SERVICES IS GIVEN IN GOOD FAITH AFTER CONSULTATION WITH THE RELEVANT AUTHORITY, HOWEVER ACCURACY IS NOT CERTAIN. THE MAIN CONTRACTOR IS RESPONSIBLE FOR CHECKING ALL INFORMATION ON SITE PRIOR TO WORK COMMENCING AND TAKING DUE CARE AND ATTENTION WHILST UNDERTAKING THE WORKS.
 - THE CONTRACTOR MUST COMPLY WITH ALL CURRENT LEGISLATION RELATING TO HEALTH & SAFETY.
 - ALL PRODUCTS SPECIFIED SHALL BE INSTALLED IN STRICT ACCORDANCE WITH THE MANUFACTURERS RECOMMENDATIONS AND INSTRUCTIONS. IF THERE ARE DISCREPANCIES BETWEEN THAT INFORMATION AND THE DETAILS ON ANY SWP DRAWINGS, THE MANUFACTURERS INSTRUCTIONS MUST BE USED.

PRELIMINARY

REV.	DATE	DESCRIPTION

CLIENT	WILMINGTON HOMES
ARCHITECT	-
JOB TITLE	LABURNUM GROVE BOGNOR REGIS
DRAWING TITLE	PROPOSED DRAINAGE LAYOUT
SCALE AT A2	1:200
DATE	JUN 12
ENG.	JMB
DRAWN	JMB
CHECKED	-
JOB No.	E5634
DRAWING No.	200
REV.	-

SWP

**STEPHEN WILSON
PARTNERSHIP LTD.**

CONSULTING STRUCTURAL & CIVIL ENGINEERS

99, South Street, Eastbourne, Sussex, BN21 4LU
Telephone: 01323 412020, Facsimile: 01323 432129
E-Mail: info@swp-part.co.uk