


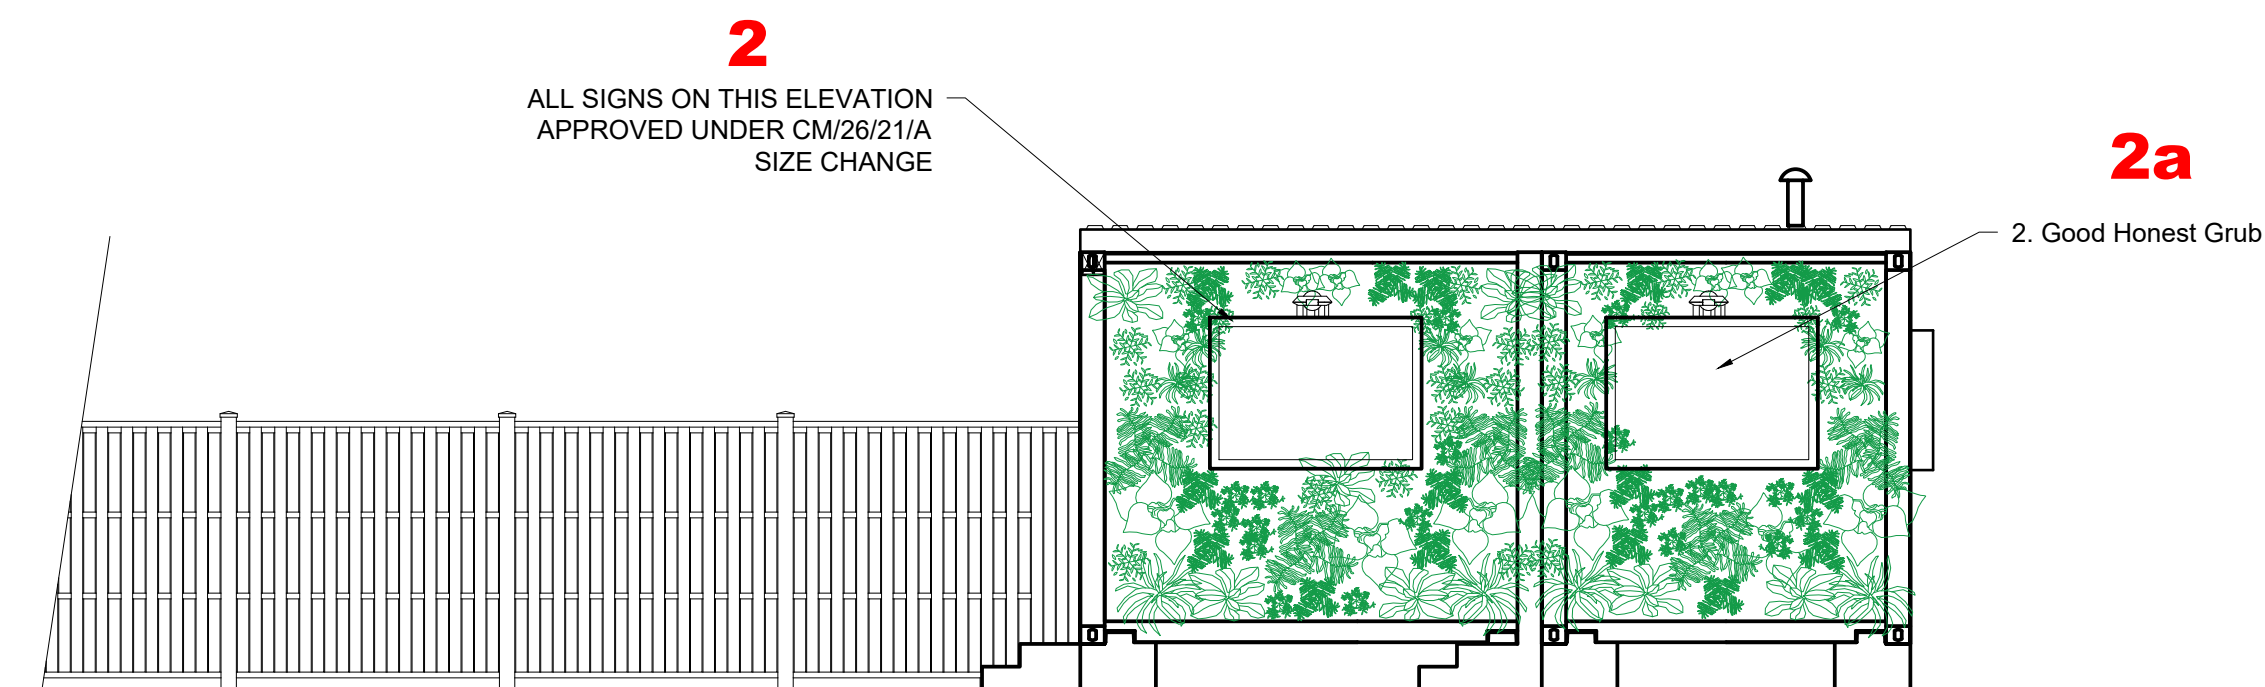


Proposed Front EAST Elevation
Scale: 1:50


Proposed Side NORTH Elevation
Scale: 1:50




Proposed Logo - Sign 1 Luminated Sign
Scale: 1:20

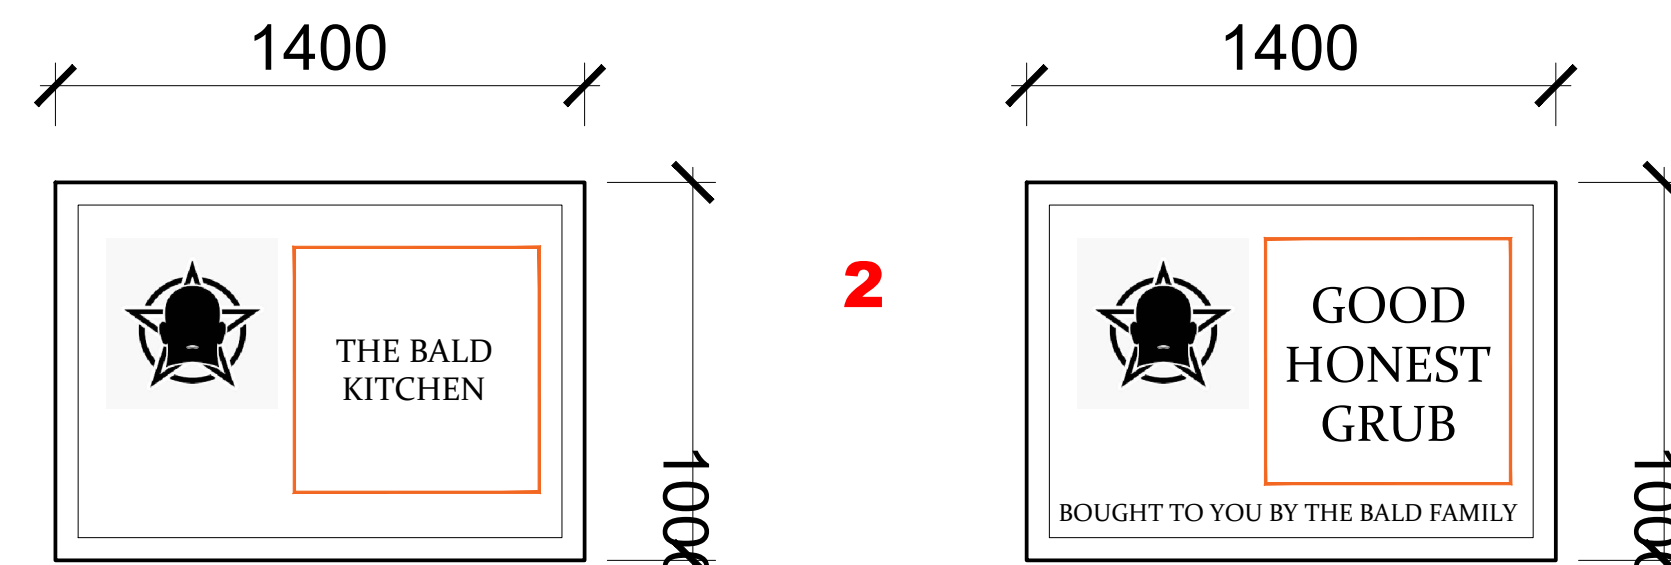


Bald kitchen logo
Scale: 1:20

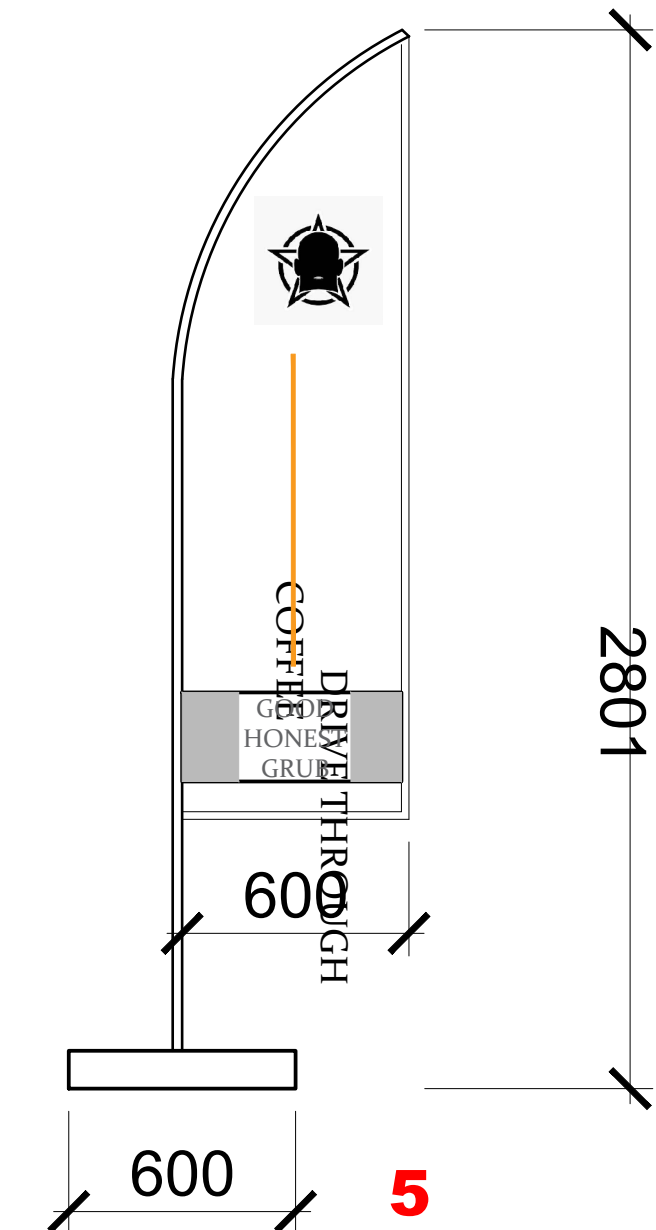


Flag to go road side
Scale: 1:20

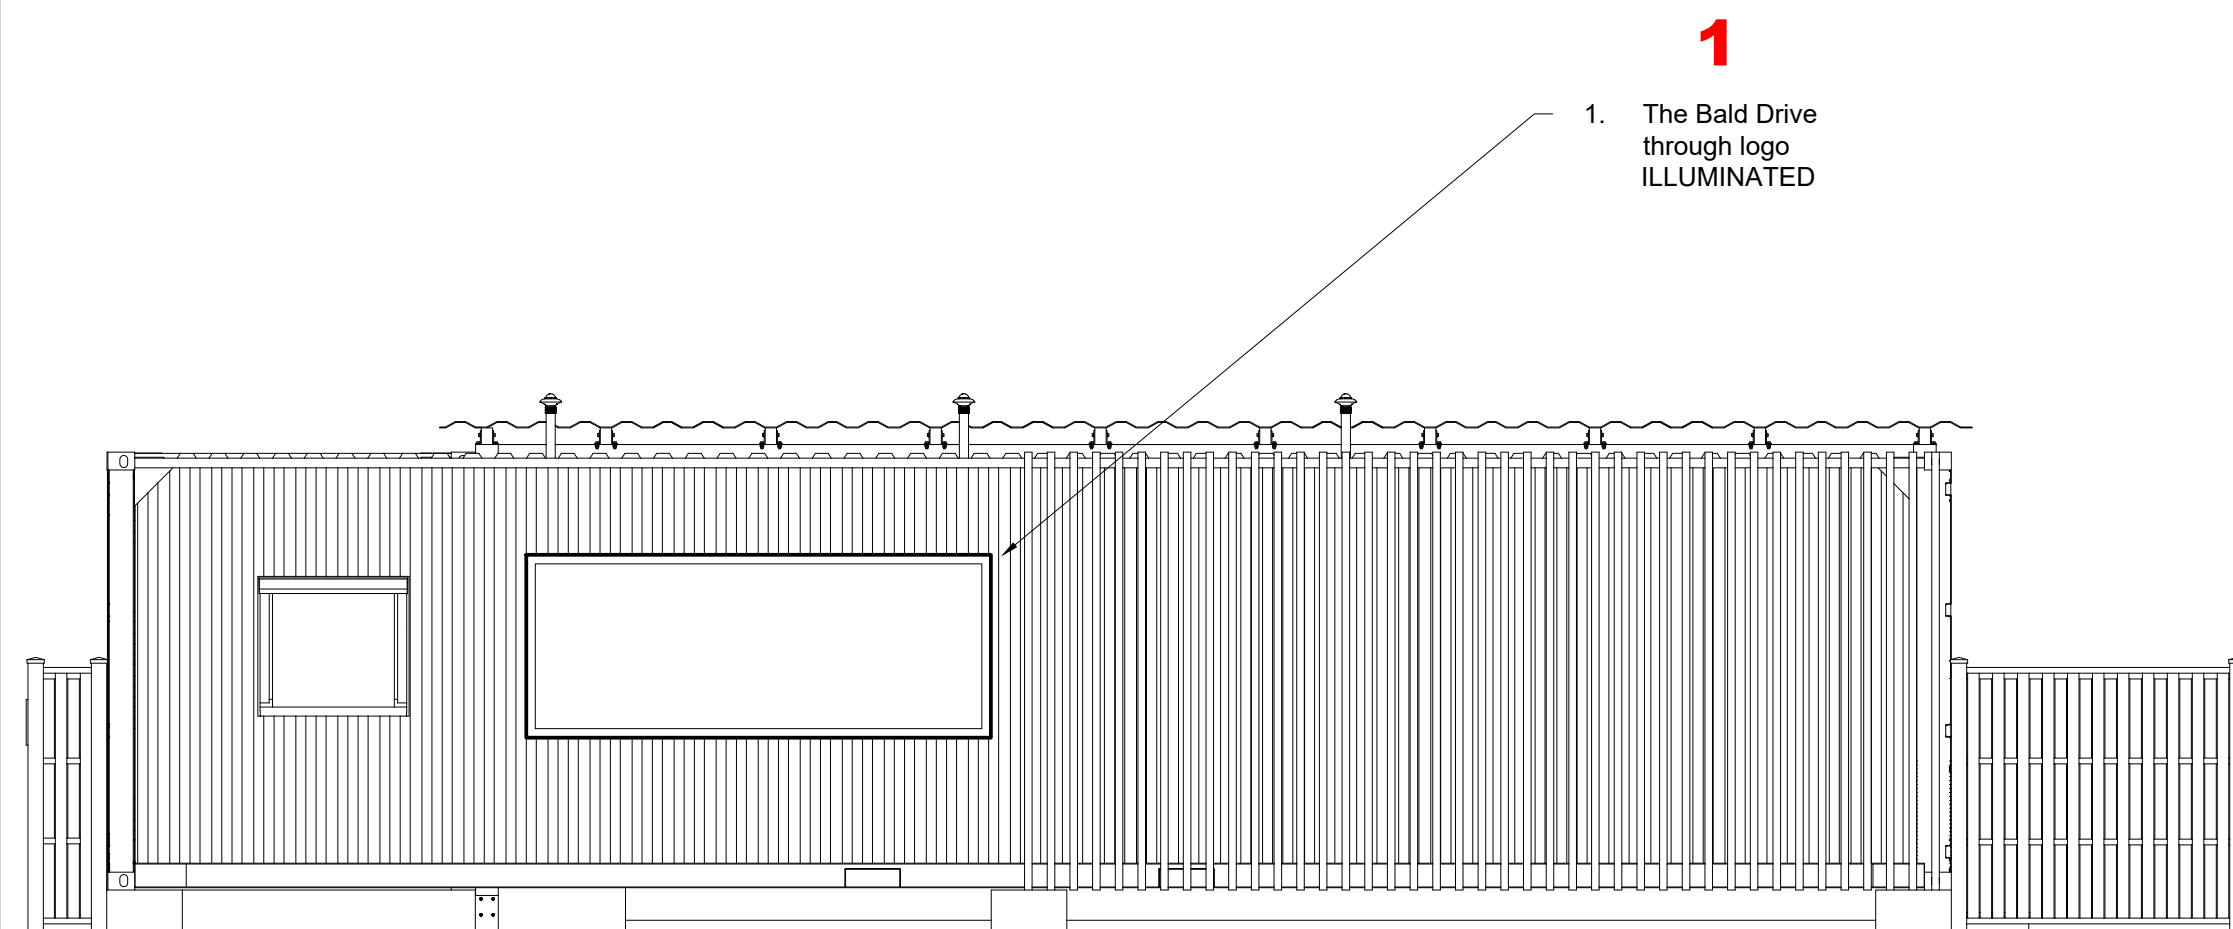


Proposed Rear WEST Elevation
Scale: 1:50

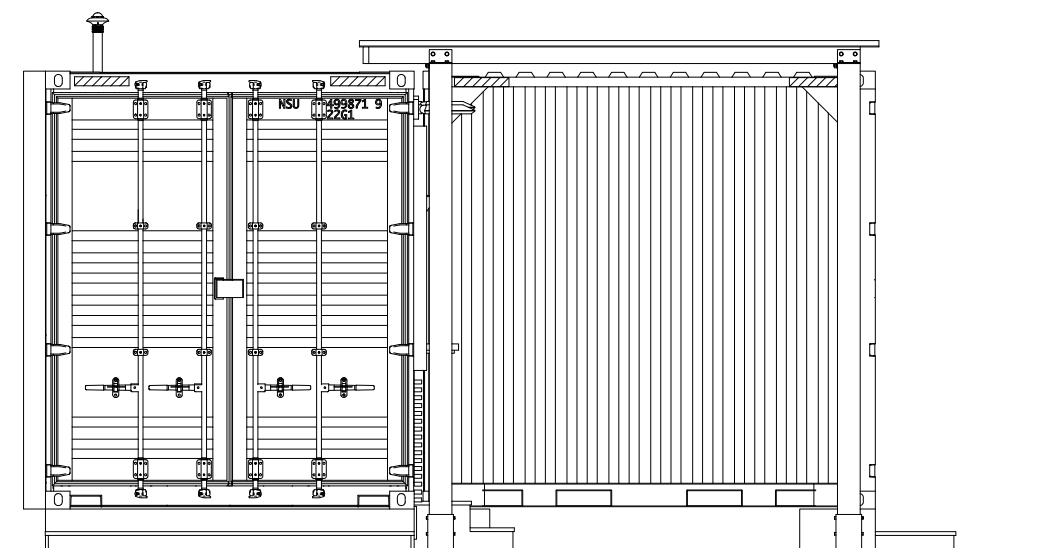

Proposed Side SOUTH Elevation
Scale: 1:50

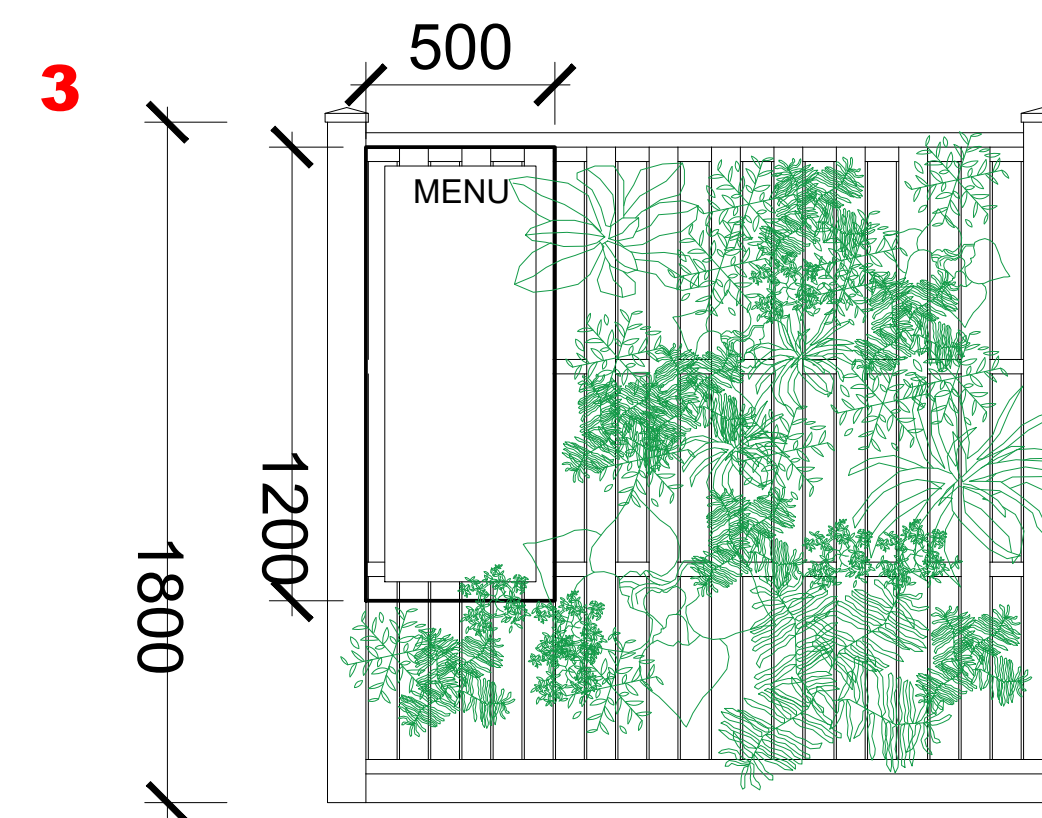

3. Proposed Side SOUTH Boundary of drive through sign - Illuminated

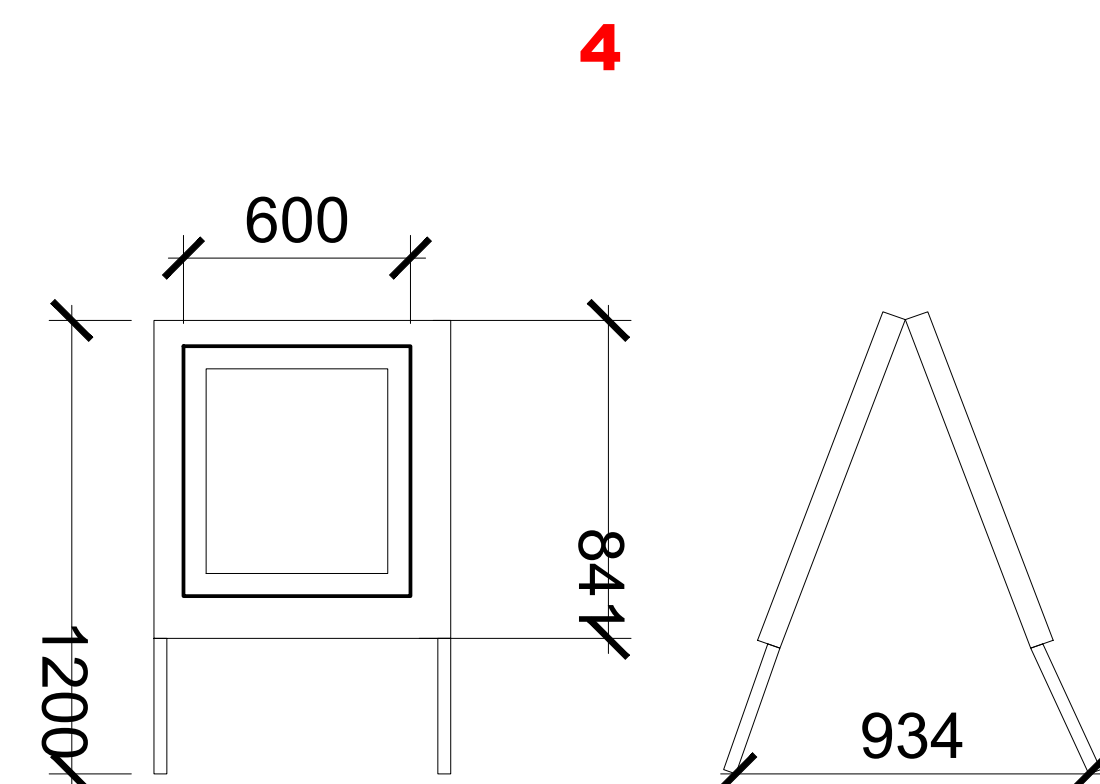

Proposed A Boards
Scale: 1:20

ONLY TO BE DISPLAYED DURING OPENING HOURS

This drawing is to be read in conjunction with the Construction Notes and Structural Engineer's details.

The Contractor is responsible for all setting out and must check levels and dimensions on site before ordering materials or commencing work.

Refer to written dimensions only. Do not scale from drawings, except for purposes of Planning assistance.

The Architect is to be immediately notified of any omissions or discrepancies.

Building work should not commence until all statutory approvals have been granted, i.e. Planning, Building Control, etc.

If a public sewer is discovered, consent to 'Build-over/Close-to' may be required from the Water Authority.

PARTY WALLS:

Work to Party Walls (including insertion of flashings, beam bearings, etc) are subject to Party Wall agreements with neighbours and must be arranged by the Client in accordance with the Party Wall Act (i.e. Providing two months written notice).

DRAWING LEGEND:

- Below ground drainage - Surface Water
- Below ground drainage - Foul Water
- Discharge pipes
- Existing structure
- Proposed structure
- Removed structure

SERVICES LISTED:

- TELEVISION POINT
- TELEPHONE POINT
- 13 AMP DOUBLE SWITCHED SOCKET OUTLET
- 13 AMP DOUBLE UN-SWITCHED SOCKET OUTLET
- CEILING LIGHT - PENDANT FITTING
- WALL LIGHT
- ONE WAY LIGHT SWITCH
- TWO WAY LIGHT SWITCH
- NEON INDICATOR SWITCH FOR LOFT LIGHT
- ENERGY EFFICIENT RECESSED DOWNLIGHTER

- | | |
|---|--|
|  | MAINS INTER-LINKED SMOKE DETECTOR |
|  | MAINS INTER-LINKED HEAT DETECTOR |
|  | CO DETECTOR |
|  | SPRINKLER HEAD - FLUSH TYPE |
|  | NEW RADIATOR (INDICATIVE SIZE) |
|  | SHAVING POINT |
|  | FUSED SPUR |
|  | SINGLE SWITCH FUSED SPUR |
|  | CONSUMER UNIT / MAINS DISTRIBUTION BOARD |
|  | CAT 5 / CAT 6 DATA CABLE SOCKET |
|  | COOKER SWITCH |
|  | MECHANICAL EXTRACT FAN COOKER HOOD |

- | | |
|---|---|
|  | UV ELECTRIC HEATER |
|  | ENCLOSED LUMINAIRE |
|  | EMERGENCY LUMINAIRE - SELF-CONTAINED |
|  | ENCLOSED LINEAR LUMINAIRE (INDICATIVE SIZE) |
|  | MECHANICAL EXTRACT FAN |
|  | LOUDSPEAKER (SSP = SINGLE STEREO SPEAKER) |
|  | VIDEO ENTRY PANEL |
|  | VIDEO ENTRY HANDSET |
|  | LED FLOODLIGHT |
|  | PIR SENSOR |
|  | CCTV CAMERA |
|  | CEILING FAN |
|  | UHF PROGRAMMER |

F	18/11/2021	Planning Amendments	DLS
E	09/11/2021	Planning Amendments	DLS
D	14/10/2021	Planning Amendments	DLS
C	13/10/2021	Planning Amendments	DLS
B	12/10/2021	Planning Amendments	DLS
A	09/10/2021	Planning Amendments	DLS

Top Floor
Trafalgar House
Newhaven
East Sussex
BN9 9DD


07881 656512
info@sheararchitecturaldesign.co.uk

PROJECT:

Maidenheads Aquatic
CROOKTHORN LAKE
Atherington
BN17 5SN

These drawings and design
Shear Architectural Design
copied, retained, or used w
consent.

Drive Through Cafe

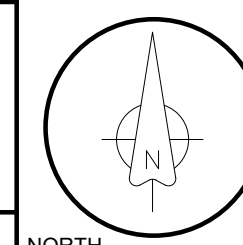

of NORTH


DATE:	16/06/2021
SCALE:	Various
DRAWN:	DS
CHECKED:	-

SHEET OF

DL 3

[illegible]

CREATE INSPIRE ENHANCE

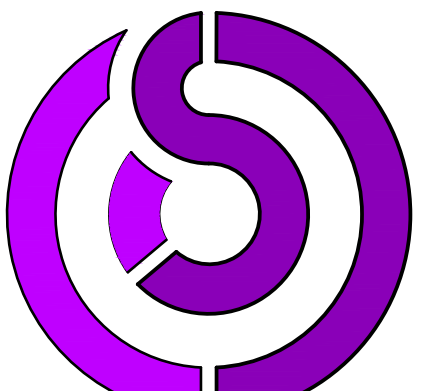

**SHEAR
ARCHITECTURAL
DESIGN**