


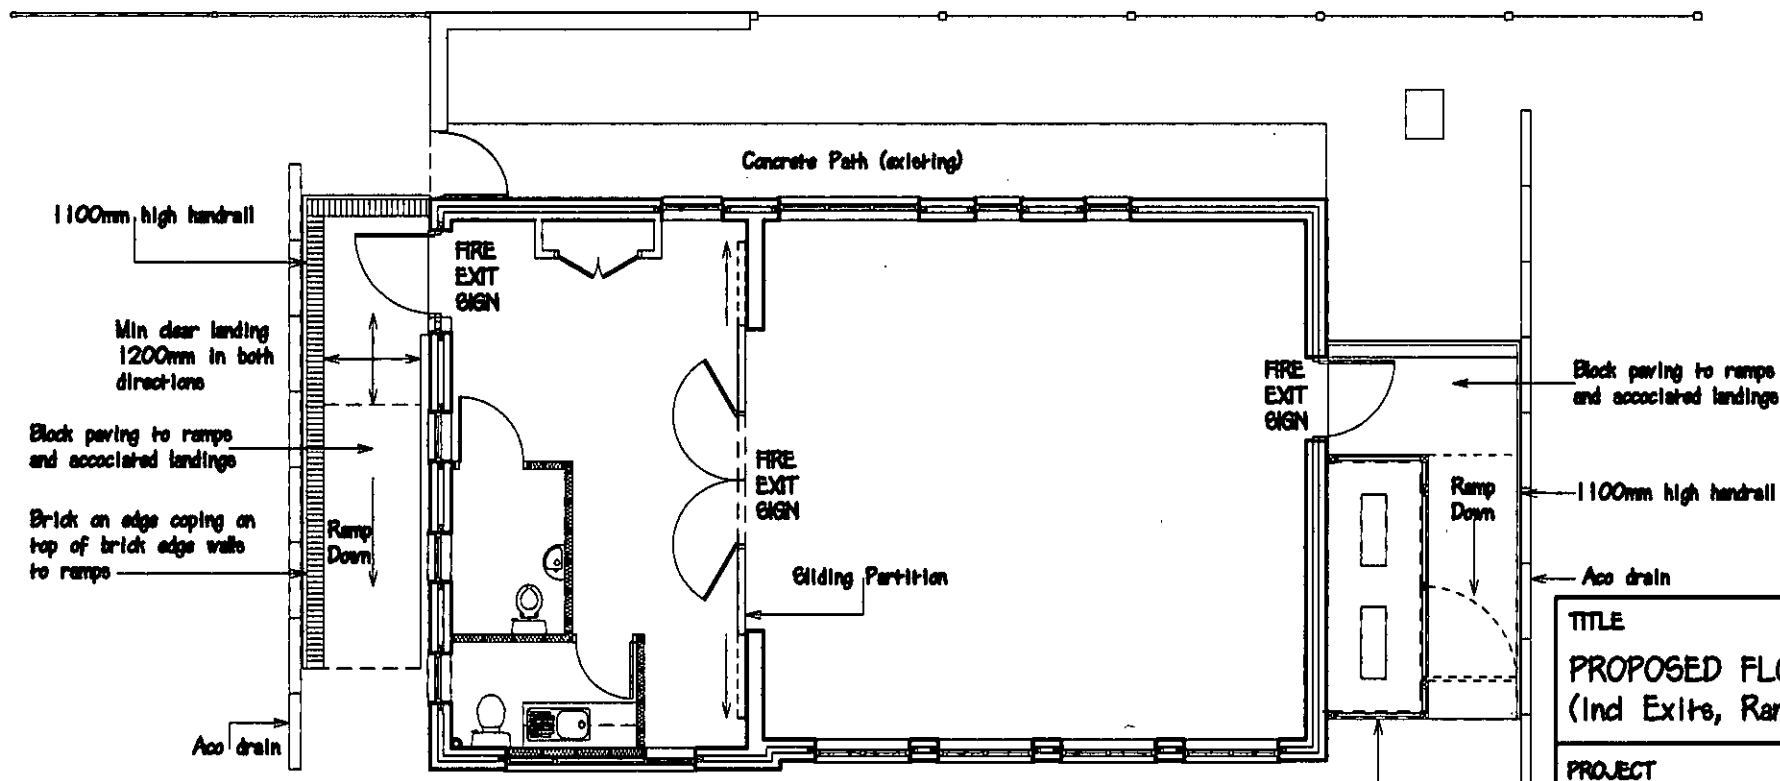

NOTE

To be read in conjunction with Drawing No 12-08-GD-131-10A
 External site lighting (Ind Emergency)
 See also Drawing No 12-07-GD-131-06B for lighting (Ind emergency)



TITLE PROPOSED FLOOR PLAN (Ind Exits, Ramps & Air Con)	
PROJECT ELM GROVE SOUTH GOSPEL HALL BARNHAM PO22	
CLIENT BOGNOR GOSPEL HALL TRUST	
DRAWN SCALE DATE DRAWING NO AMENDMENTS	R HOLLANDS 1 : 100 @ A4 AUGUST 2012 12-08-GD-131-09A (A) Rear ramp revised