


Check plumbing to BS 5572:1978
 floor mounted close coupled WC. 110
 UPVC to ex. SVP. Corner basin
 3/2 UPVC to ex. SVP and 75 deep seal
 trap. 81/s extract linked to
 light switch, 15 mins. overrun.

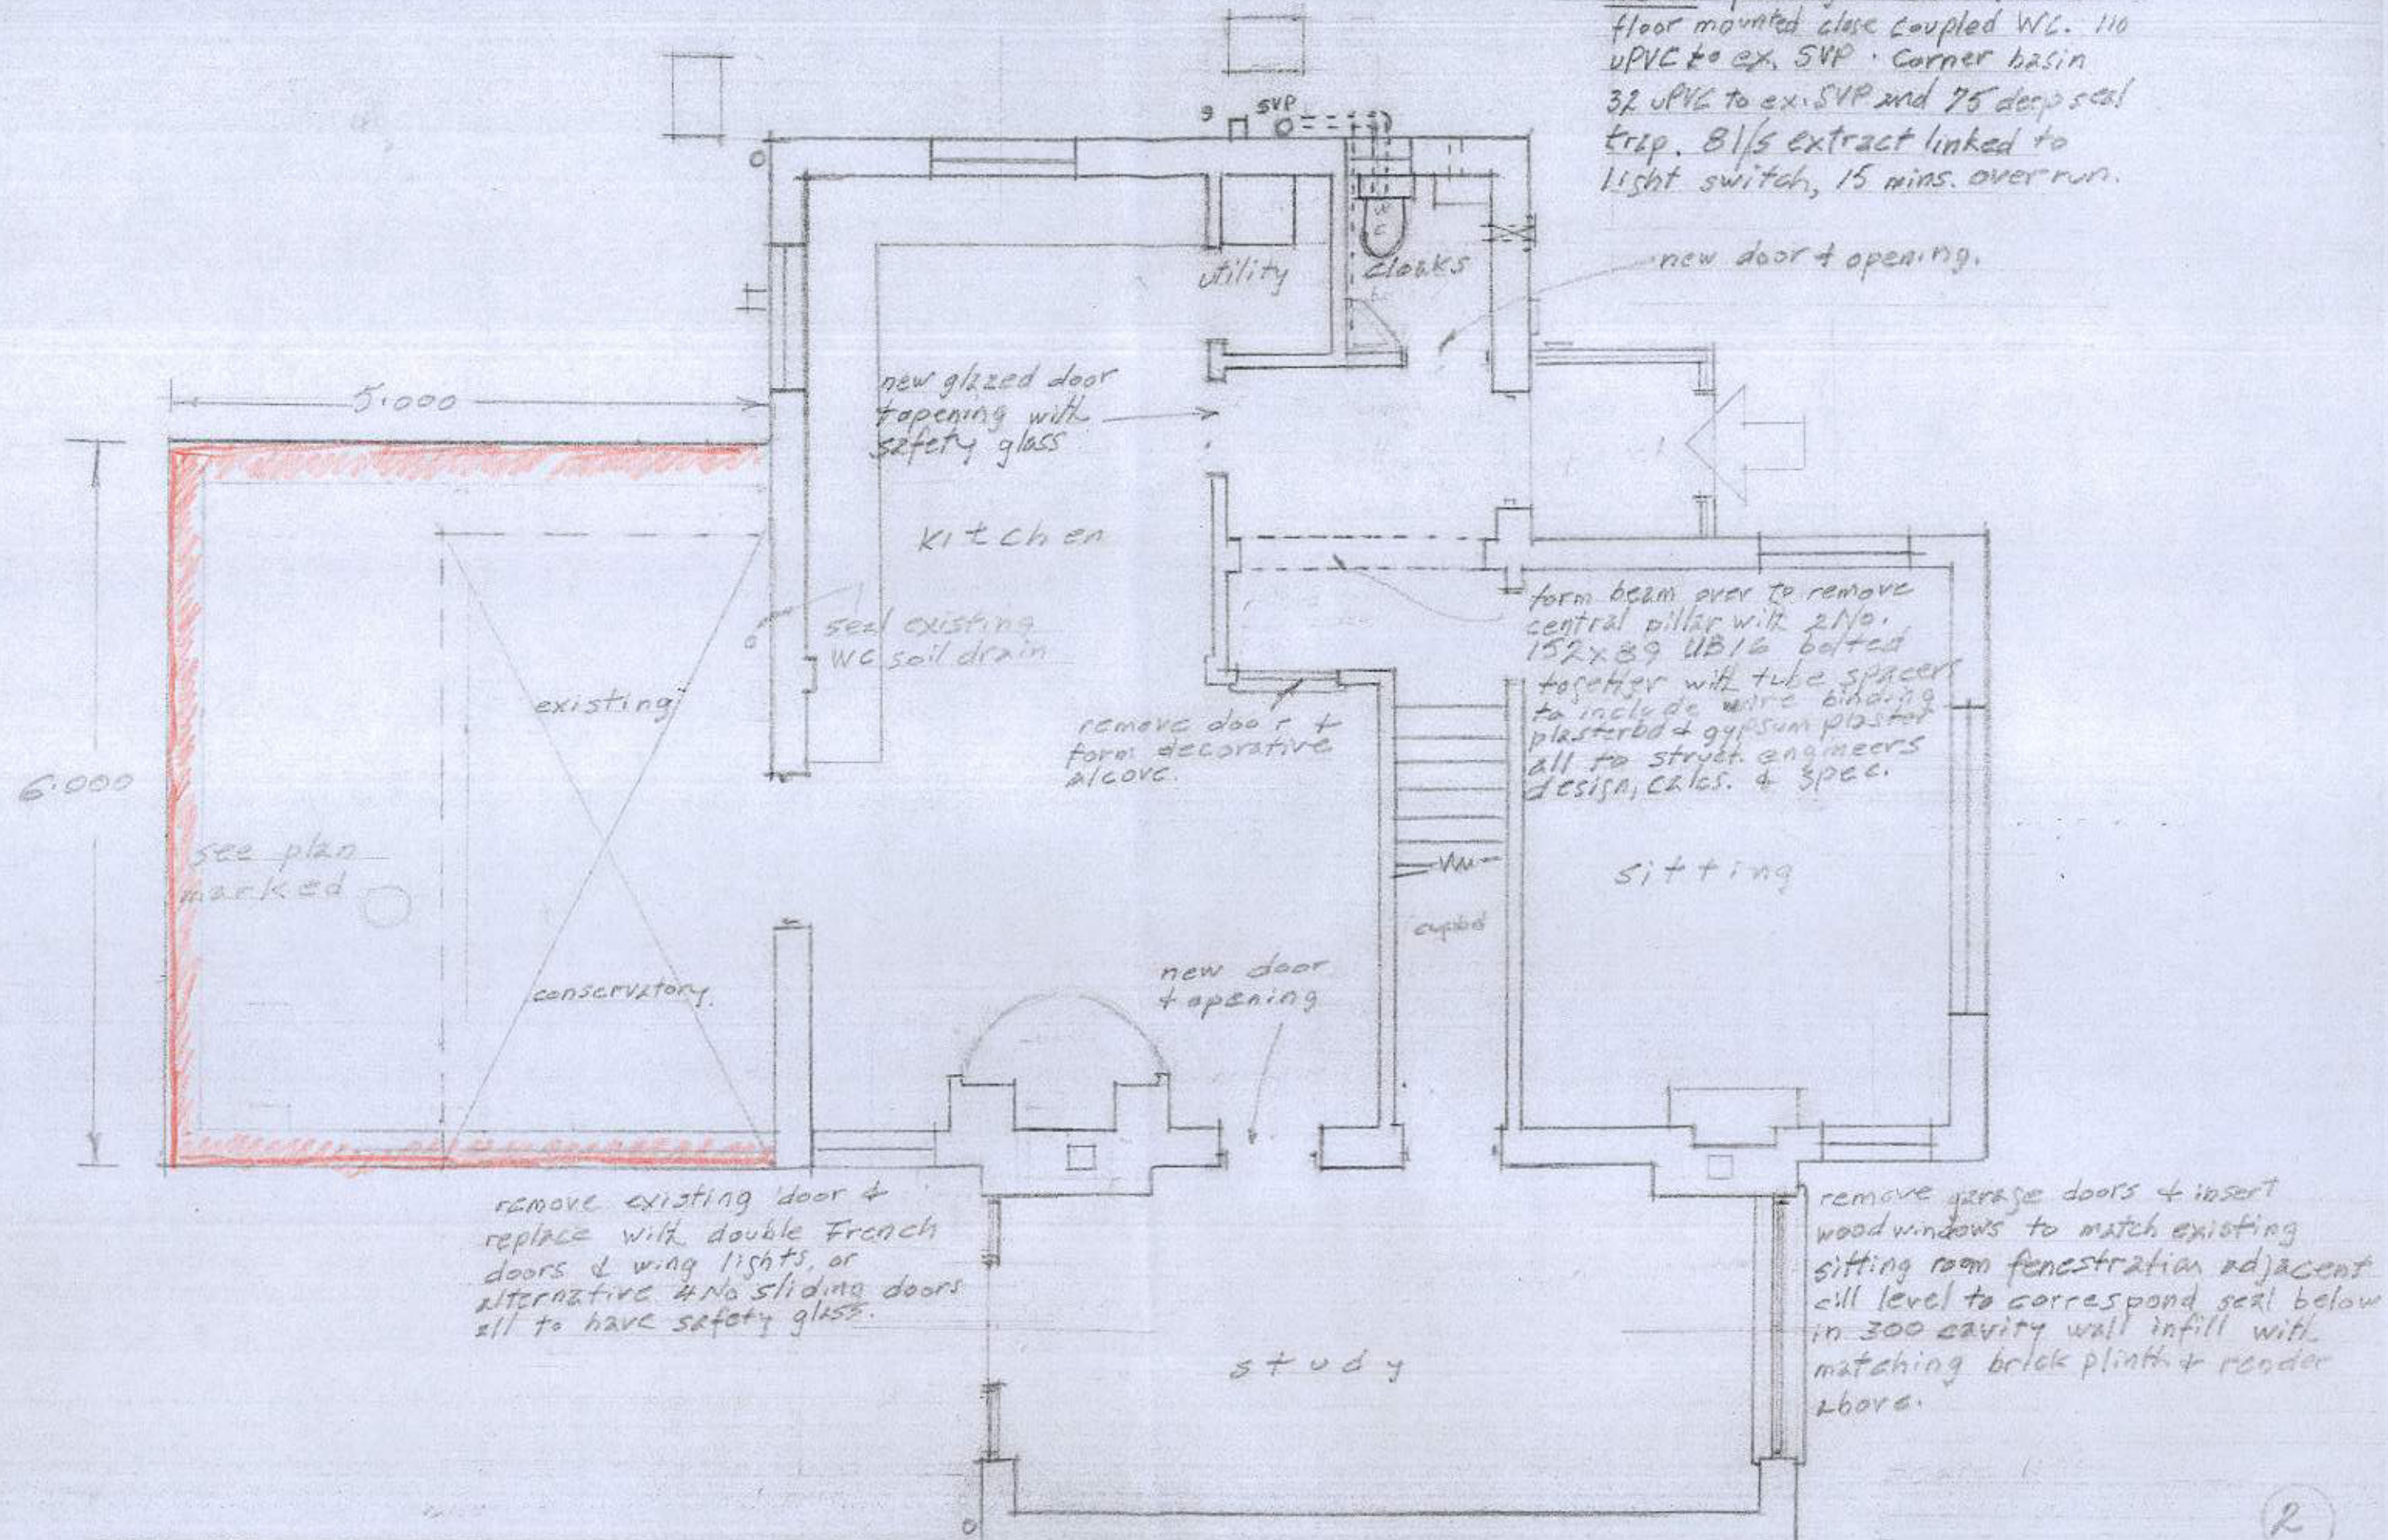

scale 1:50

November 2014

PROPOSED GROUND FLOOR PLAN