


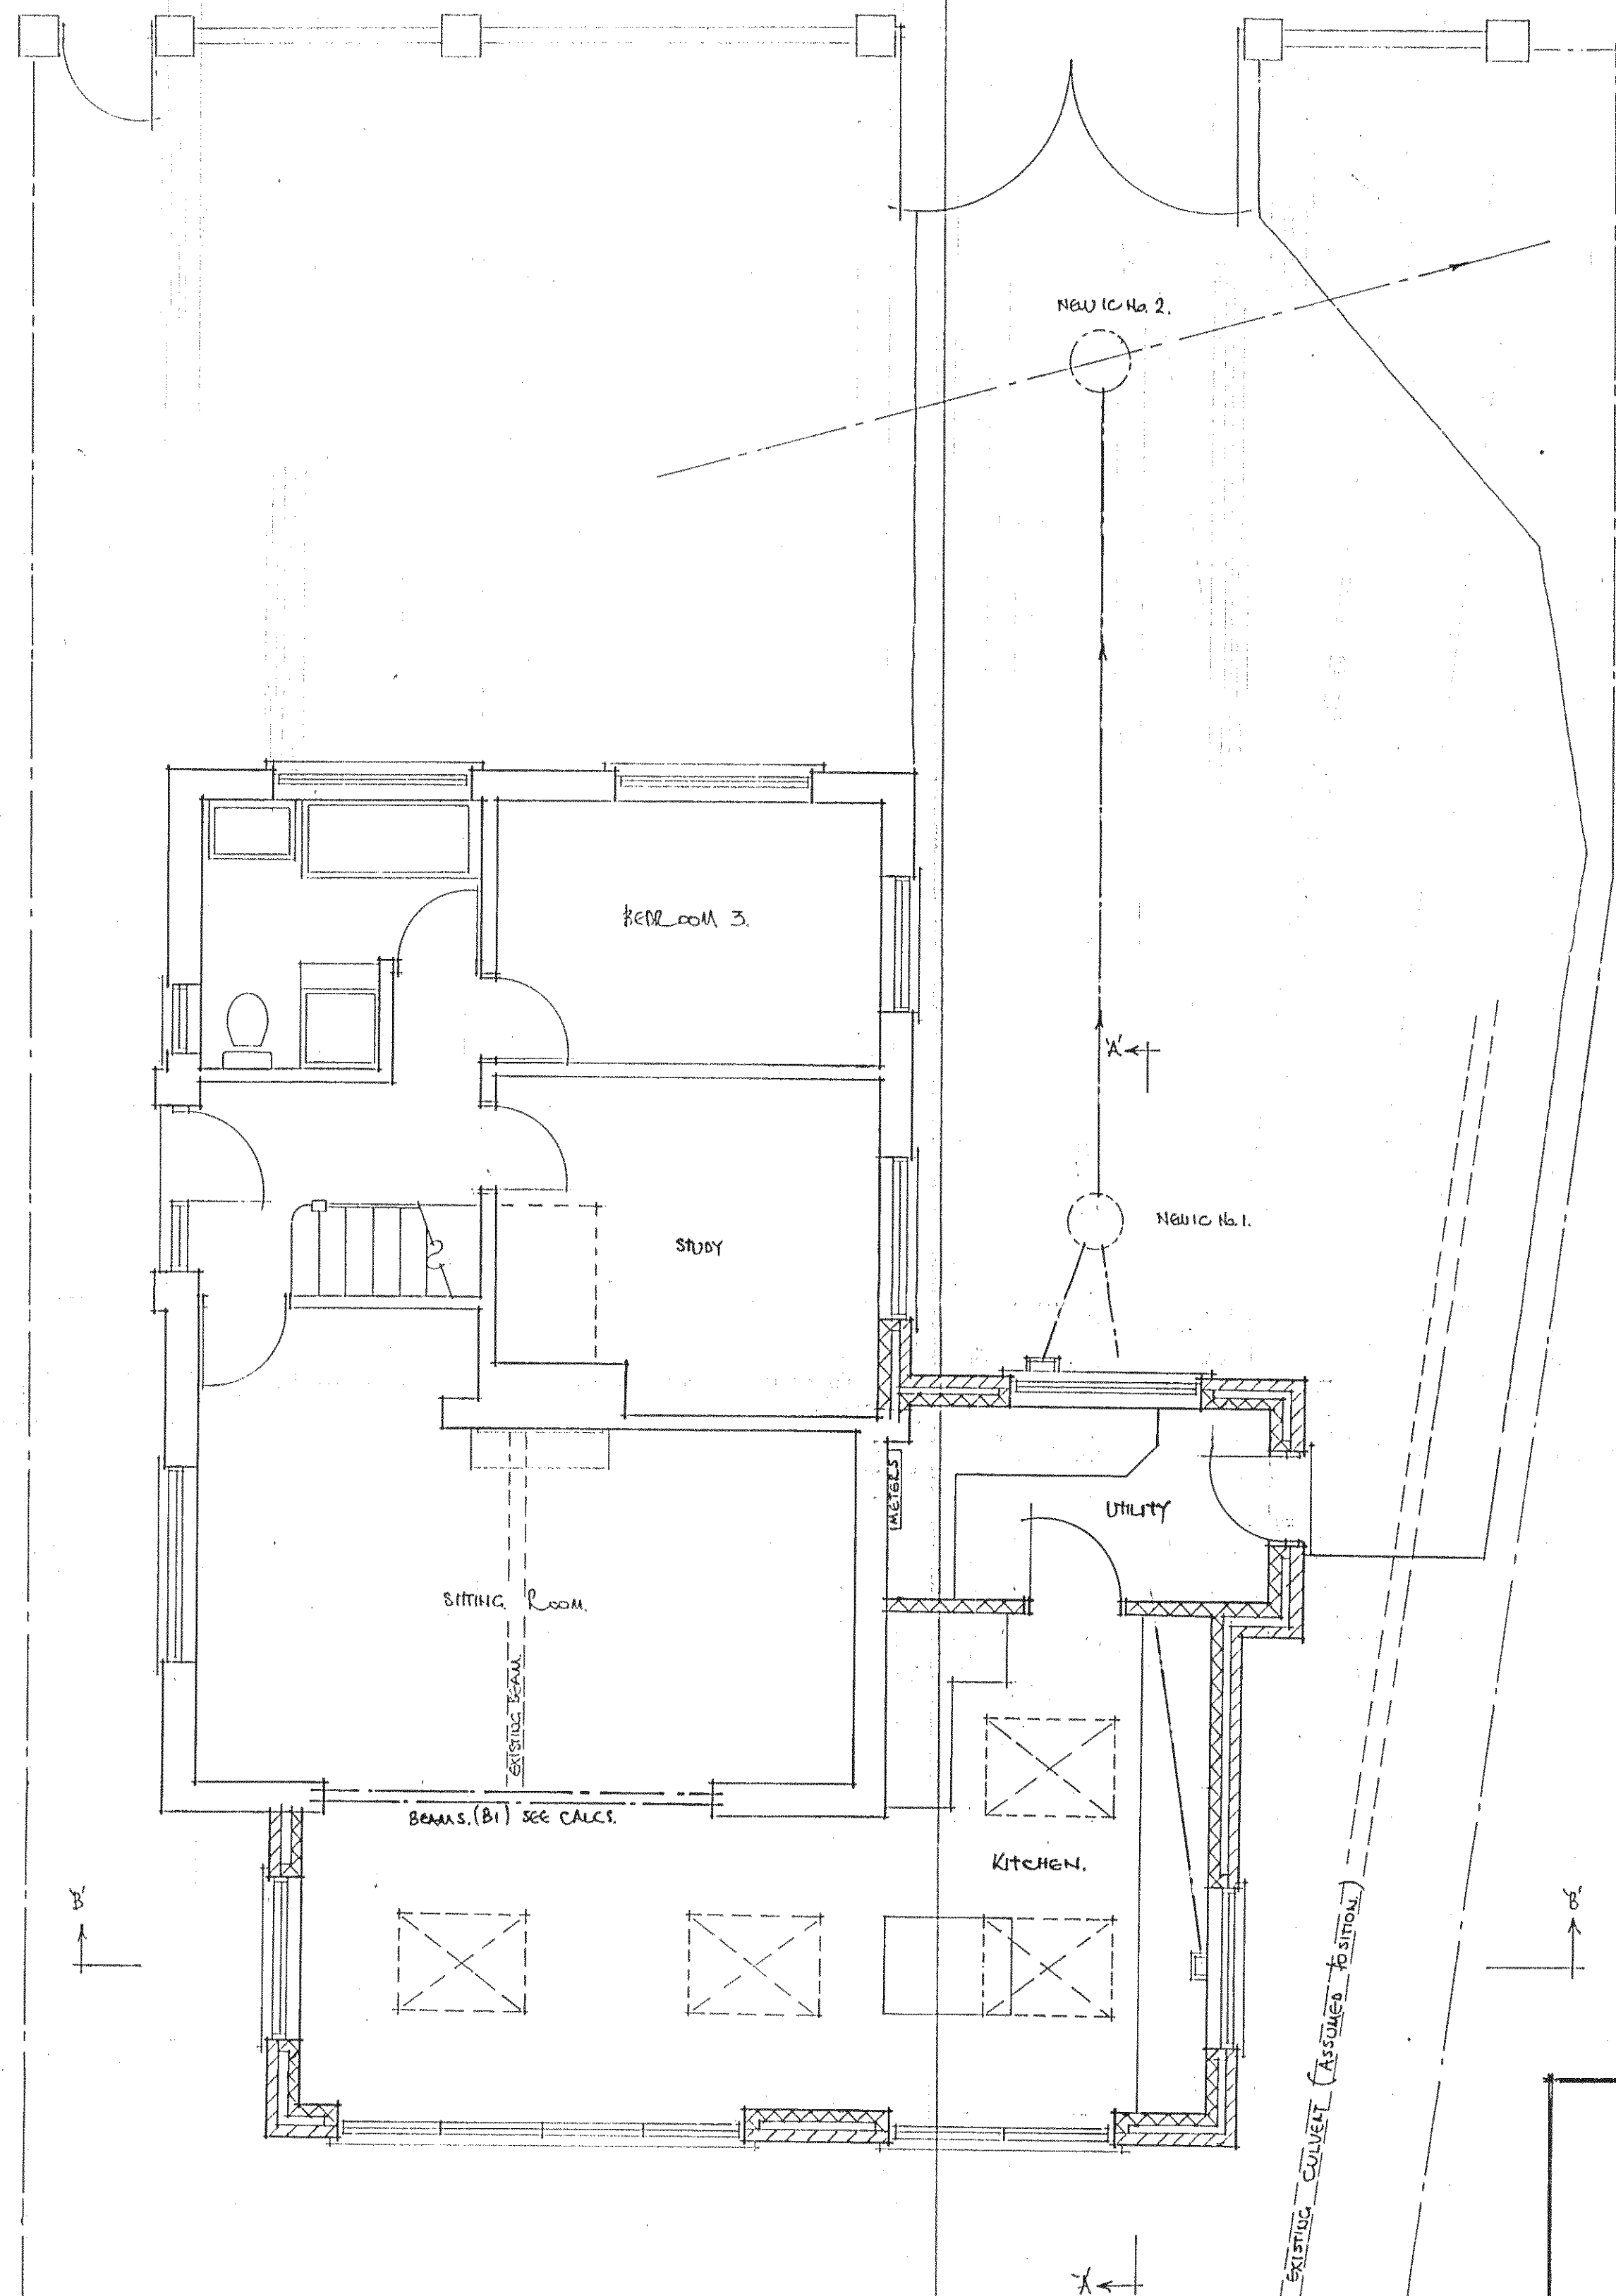


GROUND FLOOR PLAN ~ AS PROPOSED

FW DRAINAGE NOTES:-

LAY ALL NEW FW DRAINS IN 110MM DIA. UPVC DRAINAGE PIPING. BEDDED & SURROUNDED IN CONCRETE

CONSTRUCT NEW IC'S NO.1 & 2 IN 450MM DIA UPVC CHAMBER SECTION & SURROUNDED IN CONCRETE & FITTED WITH HEAVY DUTY COVERS & FRAME.

PROVIDE RS JOLC LINTELS ABOVE NEW DRAINS WHERE THEY PASS THRO' NEW OR EXISTING WALLS.

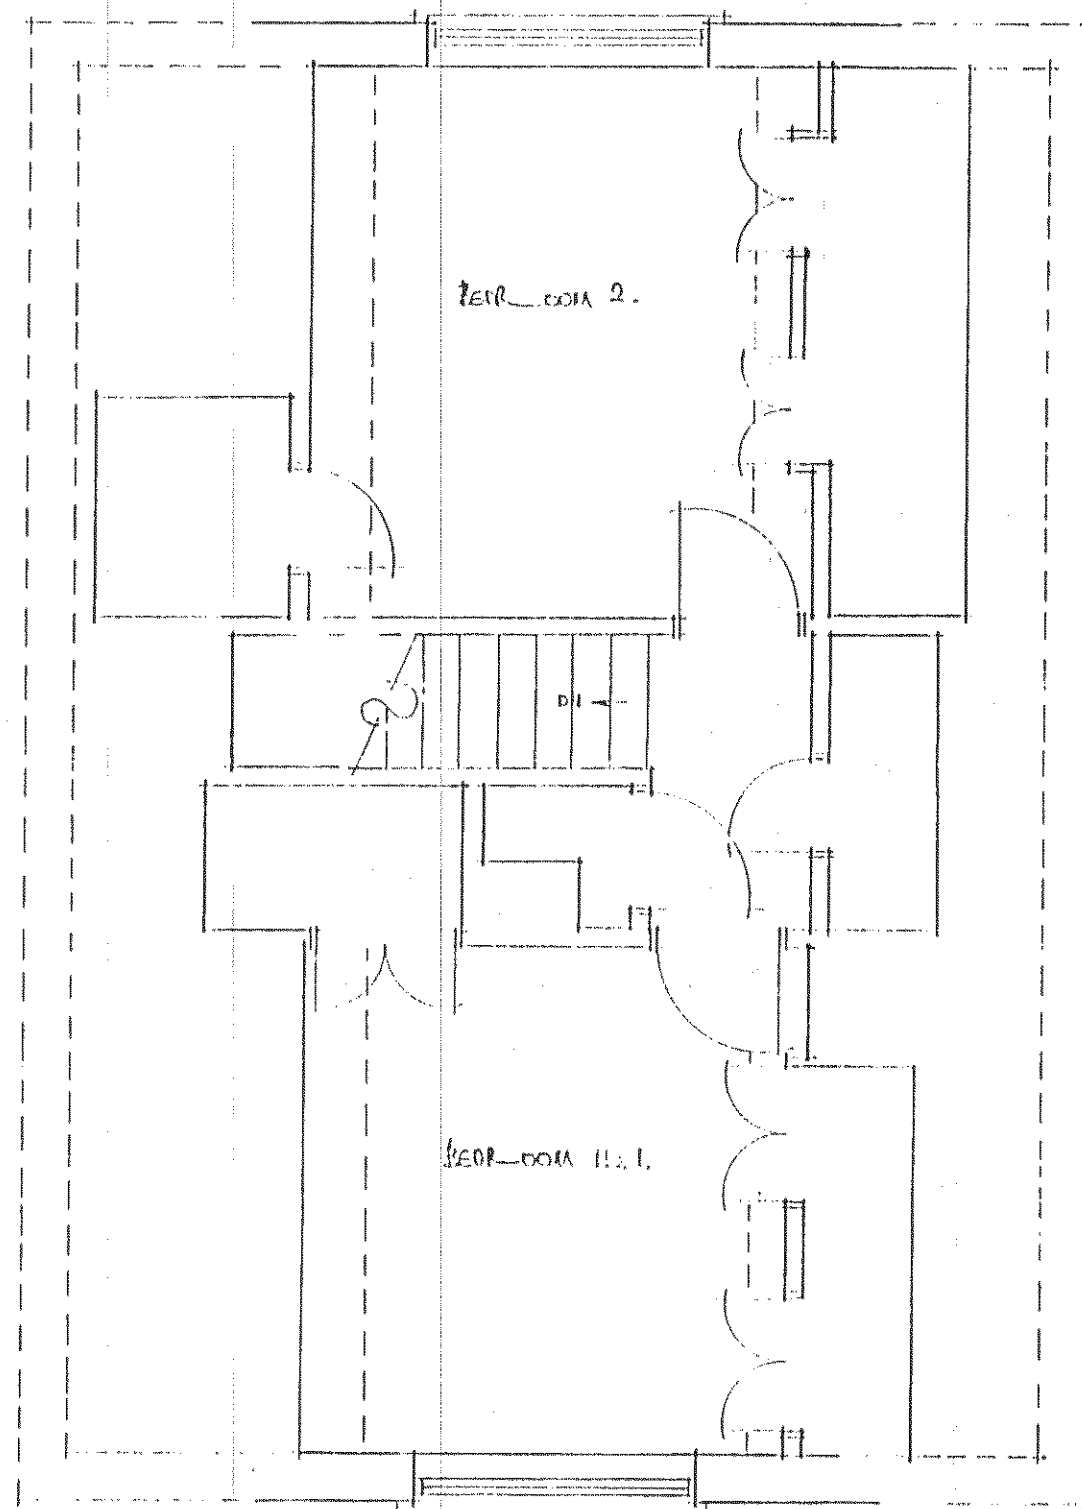

1st FLOOR PLAN ~ AS PROPOSED

NO. 26, MANOR ROAD, EAST PRESTON, WEST SUSSEX.

MR & MRS. I. COLWELL

(FLOOR PLAN AS ~ AS PROPOSED)

SCALE 1:50

AUGUST 2011 No. 14/12/04 X

Clive fish

BUILDING & DESIGN CONSULTANT
 CHARTERED
 17 NIABOS CLOSE
 BEAUMONT PARK
 LITTLE HAMPTON,
 WEST SUSSEX,
 BN17 6RX.

TEL: (01903) 732947

MEMBER OF: C.R. FISH

REV. X ~ ADDITIONAL NOTES ADDED FOR BUILDING CONTROL APPLICATION

OCT 2011