



- Notes:**
1. The location, size, depth and identification of existing services that may be shown or referred to on this drawing have been assessed from non-intrusive observations, record drawings or the like. The contractor shall carry out intrusive investigations, trial holes or soundings prior to commencing work to satisfy himself that it is safe to proceed and that the assessments are accurate. Any discrepancies shall be notified to the client prior to works commencing.
 2. Prior to commencement of works the contractor shall provide co-ordinated and dimensioned installation drawings and calculations and allow 10 working days for the client's checking procedure prior to proceeding with those works or the ordering of materials.
 3. Tender or bill of materials shall not be used for construction, or the ordering of materials.
 4. Do not scale. All dimensions and levels to be site confirmed.
 5. This drawing shall be read in conjunction with all relevant architect's, consultants drawings and specifications, together with H&S plan requirements.
 6. All workmanship must be undertaken in line with manufacturer's specification and in accordance with H&S requirements.
 7. Copyright: This drawing must not be copied, amended nor reproduced without the prior written agreement of gta.

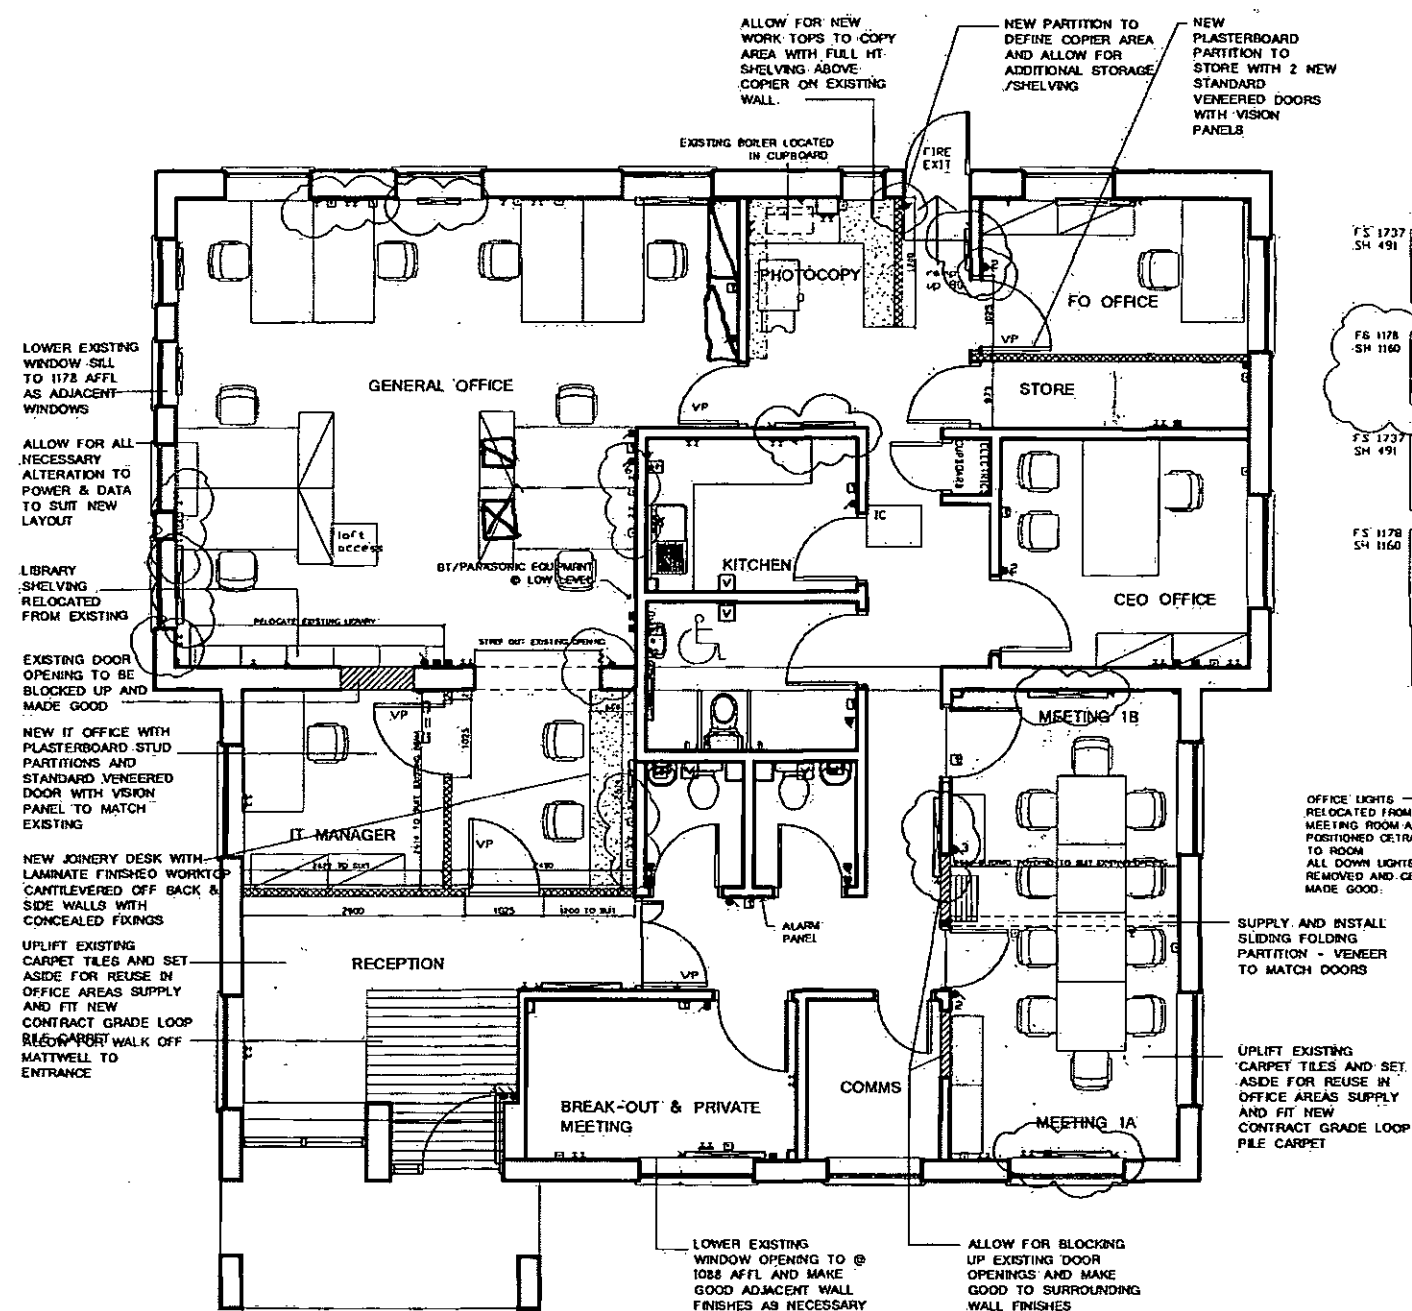

PROPOSED LAYOUT PLAN

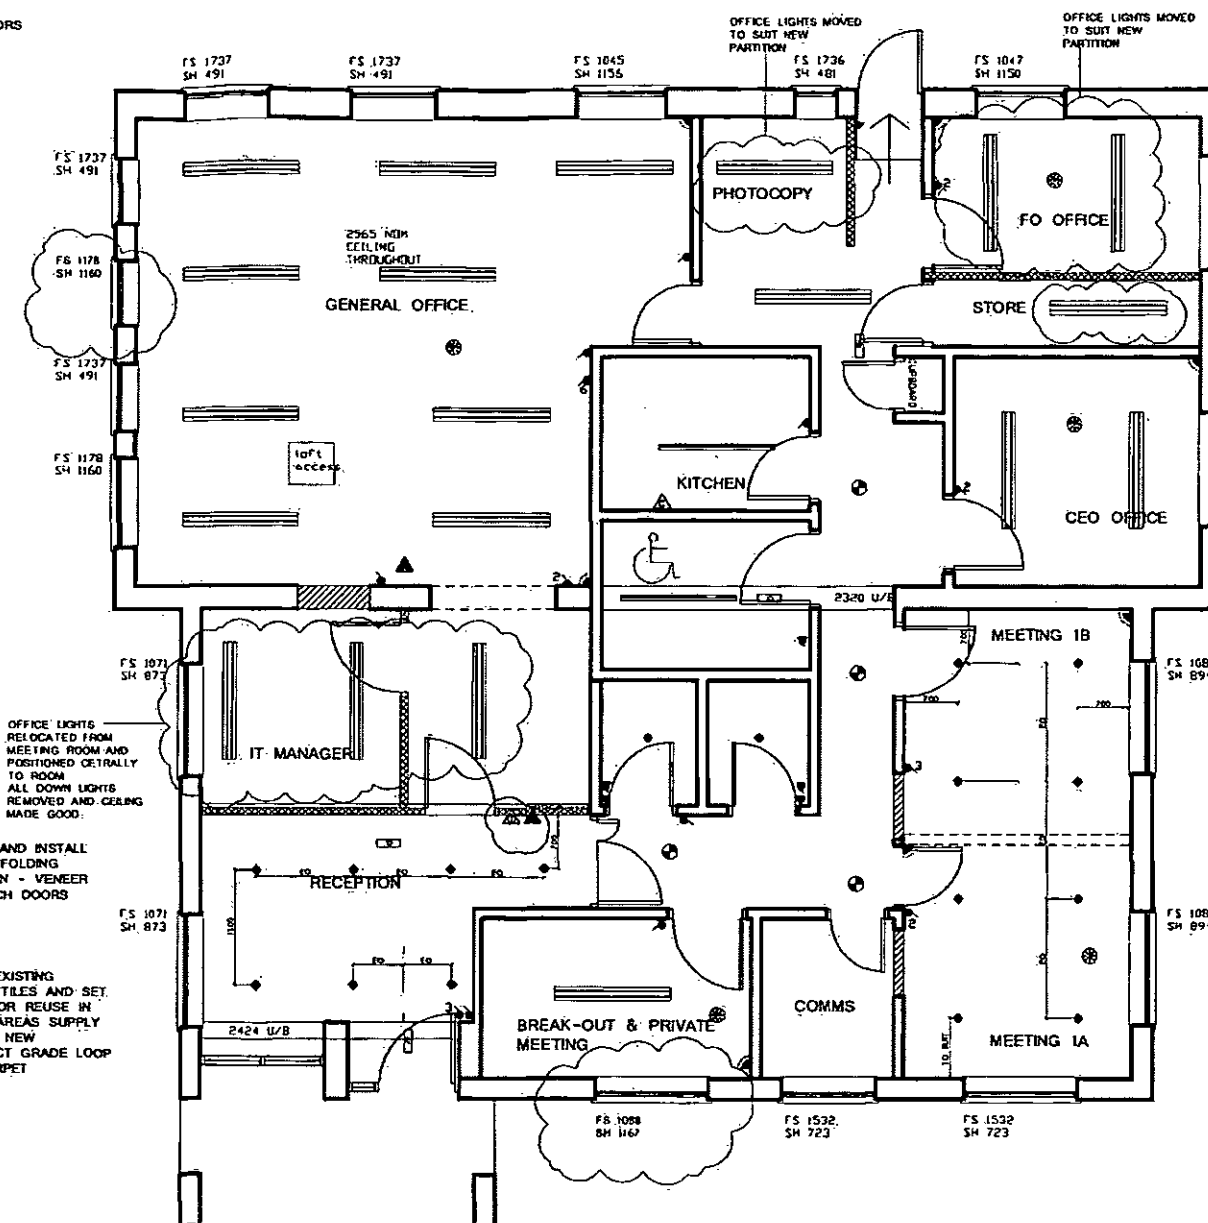

PROPOSED REFLECTED CEILING PLAN

- FS 1047 SH 1150 FLOOR TO SILL HEIGHT WHERE LOWERED SILL TO HEAD HEIGHT
- FS 1047 SH 1150 TWIN FLUORESCENT FITTING WITH DIFFUSER RELOCATED
- FS 1047 SH 1150 SINGLE FLUORESCENT FITTING WITH DIFFUSER
- FS 1047 SH 1150 SURFACE MOUNTED DOWNLIGHTER REMOVED
- FS 1047 SH 1150 NEW RECESSED DOWNLIGHTS TO RECEPTION AND MEETING ROOMS ONLY SETTING OUT TO BE AGREED ON SITE.
- FS 1047 SH 1150 CEILING MOUNTED GLOBE
- FS 1047 SH 1150 EMERGENCY LIGHT FITTING
- FS 1047 SH 1150 LIGHT SWITCH RELOCATED
- FS 1047 SH 1150 MULTITANG LIGHT SWITCH RELOCATED
- FS 1047 SH 1150 CEILING PULL SWITCH
- FS 1047 SH 1150 PIR
- FS 1047 SH 1150 SMOKE DETECTOR/SENSOR
- FS 1047 SH 1150 EXTRACT VENTILATOR
- FS 1047 SH 1150 TWIN SS50 NEW / RELOCATED
- FS 1047 SH 1150 SINGLE SS50 NEW / RELOCATED
- FS 1047 SH 1150 SINGLE SWITCH SPUR NEW / RELOCATED
- FS 1047 SH 1150 DATA OUTLET NEW / RELOCATED
- FS 1047 SH 1150 DATA/TELEPHONE OUTLET NEW / RELOCATED
- FS 1047 SH 1150 RELOCATED / NEW RADIATOR 330W x 900
- FS 1047 SH 1150 THERMOSTAT
- FS 1047 SH 1150 HANDWASH WATER HEATER
- FS 1047 SH 1150 FIRE BLANKET IN CONTAINER
- FS 1047 SH 1150 WATER FIRE EXTINGUISHER RELOCATED
- FS 1047 SH 1150 CO2 OR HALON FIRE EXTINGUISHER RELOCATED

Rev	Amendments	Date	By	Chk

Client

ICIS_INFORMATION_FOR_LIFE

Project

ICIS
EAST_PRESTON
BN16_1BQ

Title

EXISTING_LAYOUT

Date

12.03.09

Scale

1:100@A3

Drawn by

NN

gta

No. 4 Temple Bar Business Park, Shiffield, Chester, West Sussex, PO18 0LA

t: 0170 142 0000 f: 0170 142 0088 web: www.gta.co.uk

Drawing Number

ICIS_GTA_02

1:100 @ A3

metres 1 2 3 4