


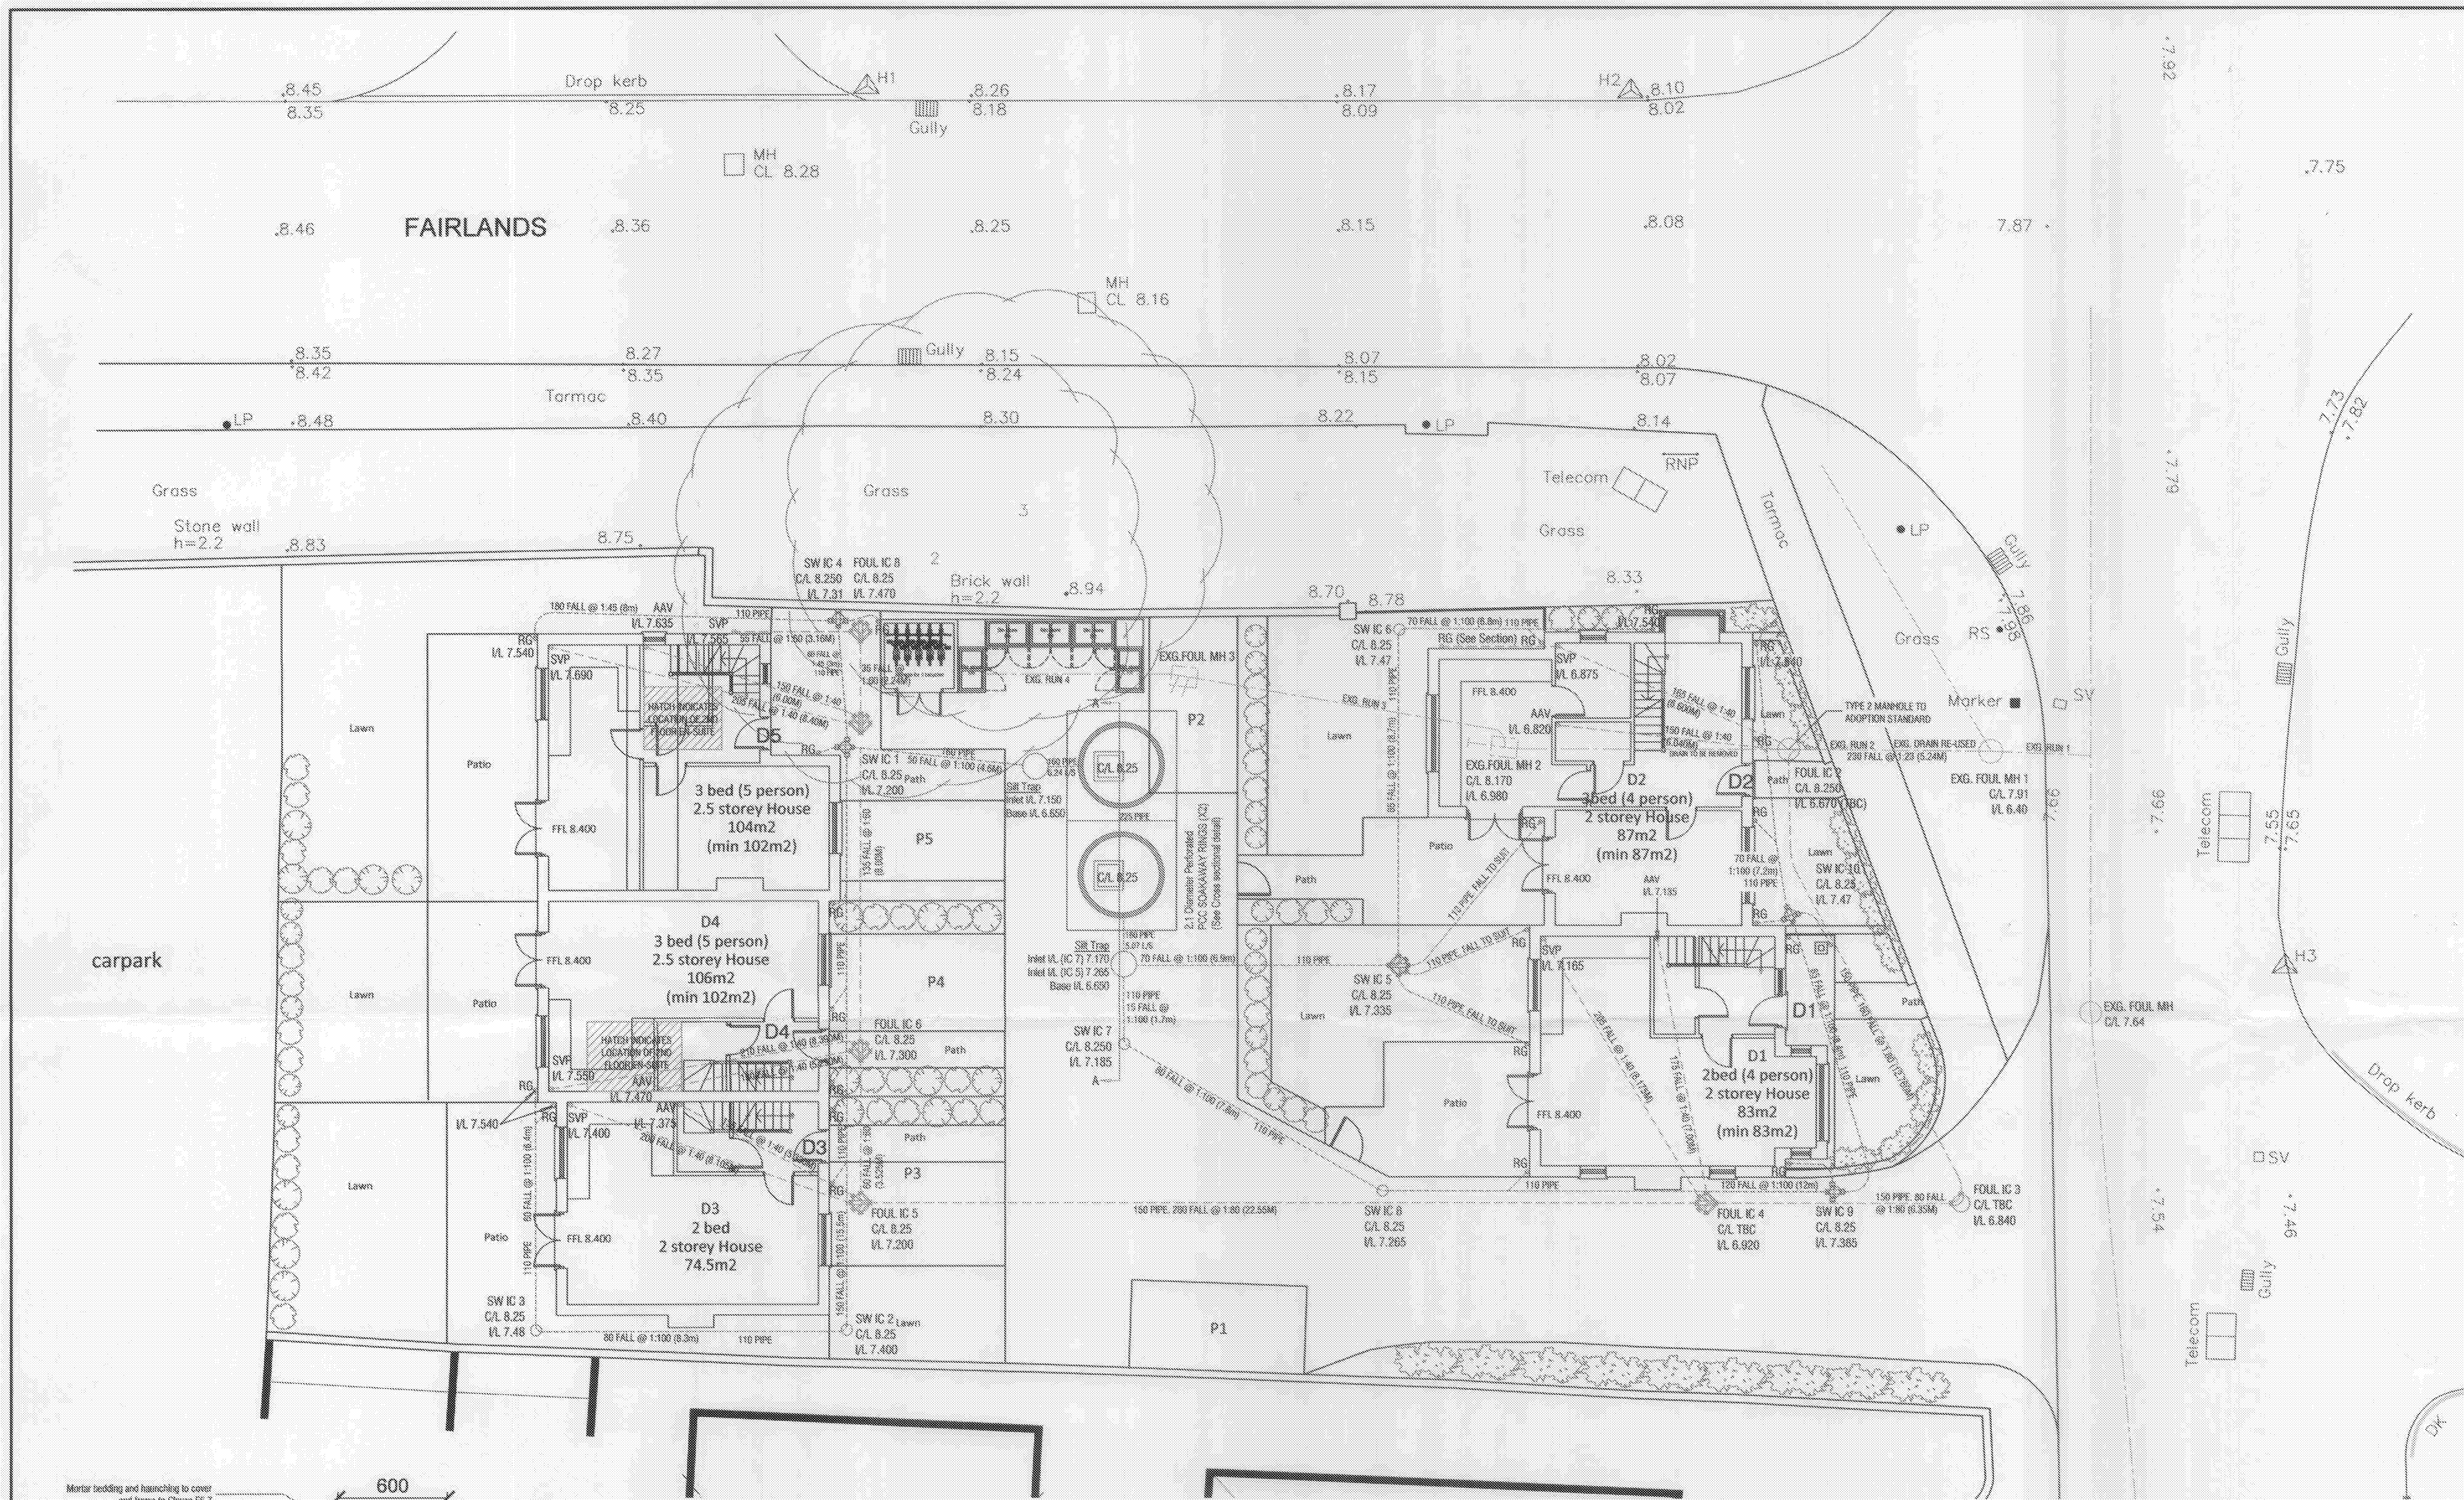

NOTES:

All dimensions must be checked on site and not scaled from this drawing.

For the detailed specification of works relating to this project, please refer to the relevant Schedule of Works issued by Aquatech Drainage Consultants Ltd.

The Contractor is to verify the layouts and levels suggested to both foul and surface water drainage systems before commencing work - Any discrepancies to be reported to ADC for attention.

SW Gullies subject to final verification on site. All cover levels subject to final landscaping detail and all surface water branch connections where not specified to be 110mm diameter at 1 in 60 gradient.

Final foul drainage layout subject to confirmation of Kitchen / Bathroom layouts


LEGEND:

Existing foul drainage run

Proposed foul drainage run

Proposed rainwater drainage run

AAV	RB	Revision	Initial
		No.	
		21/02/16	A
		23/10/16	B

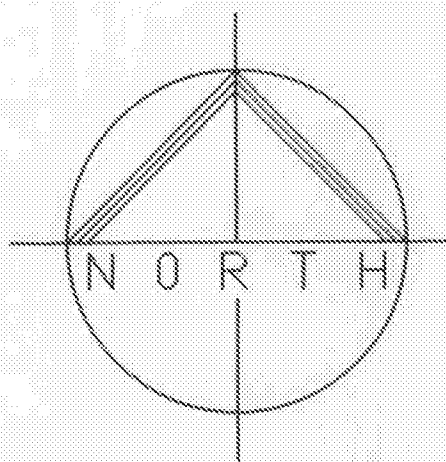

© Copyright

Aquatech Drainage Consultants Ltd

6 Lower Blakemere Road
Poundbury, Dorchester
Dorset, DT1 3BZ

Options also in:
Surrey Tel: 01306 887605
West Sussex Tel: 01903 744133



Client
South Nutfield Properties

Job Title
**The Martlets
Sea Road
Preston
West Sussex**

Drawing Title
**Proposed Foul and Surface
Water (Underground)
Drainage Layout**

© Crown Copyright 2015. All rights reserved. Licence No. 100047404
© Philips Street Atlas Series

Scale	1:100 / 1:20	Paper Size	A1
Date	Jan 2016	Drawn by	CT
Drg. No.	151102/1	Rev.	B

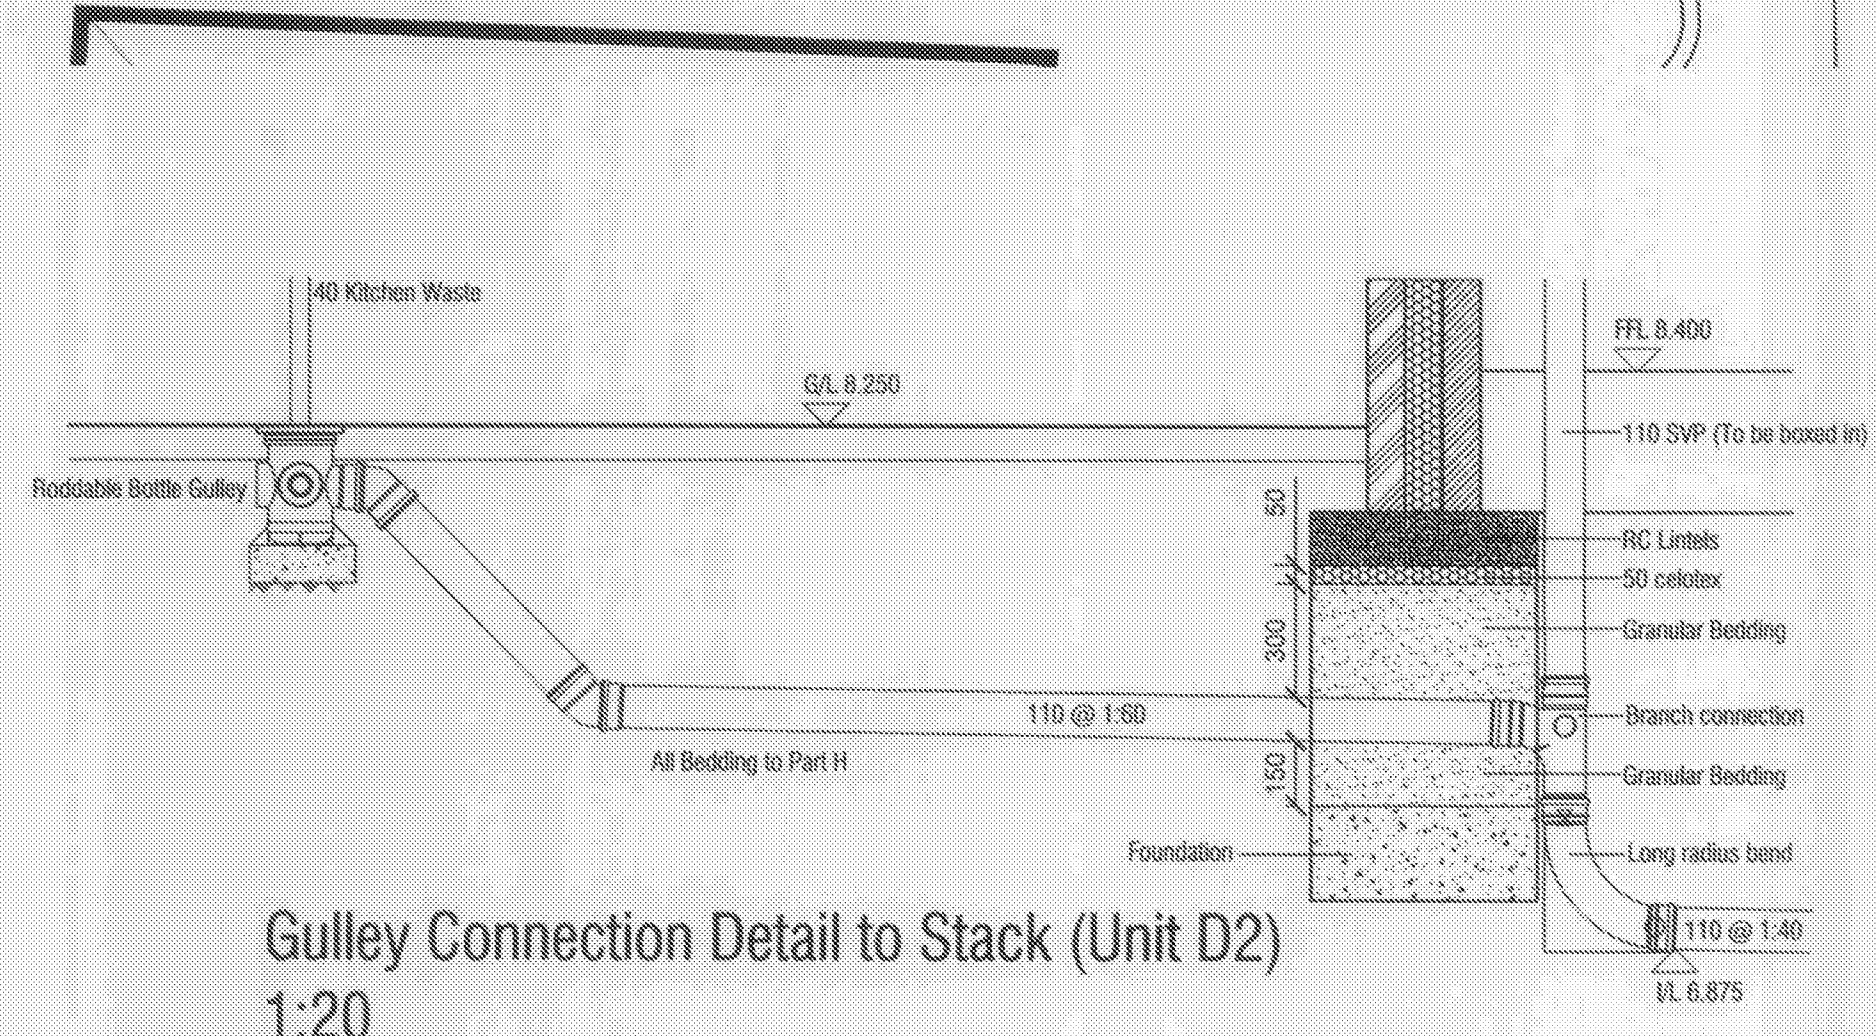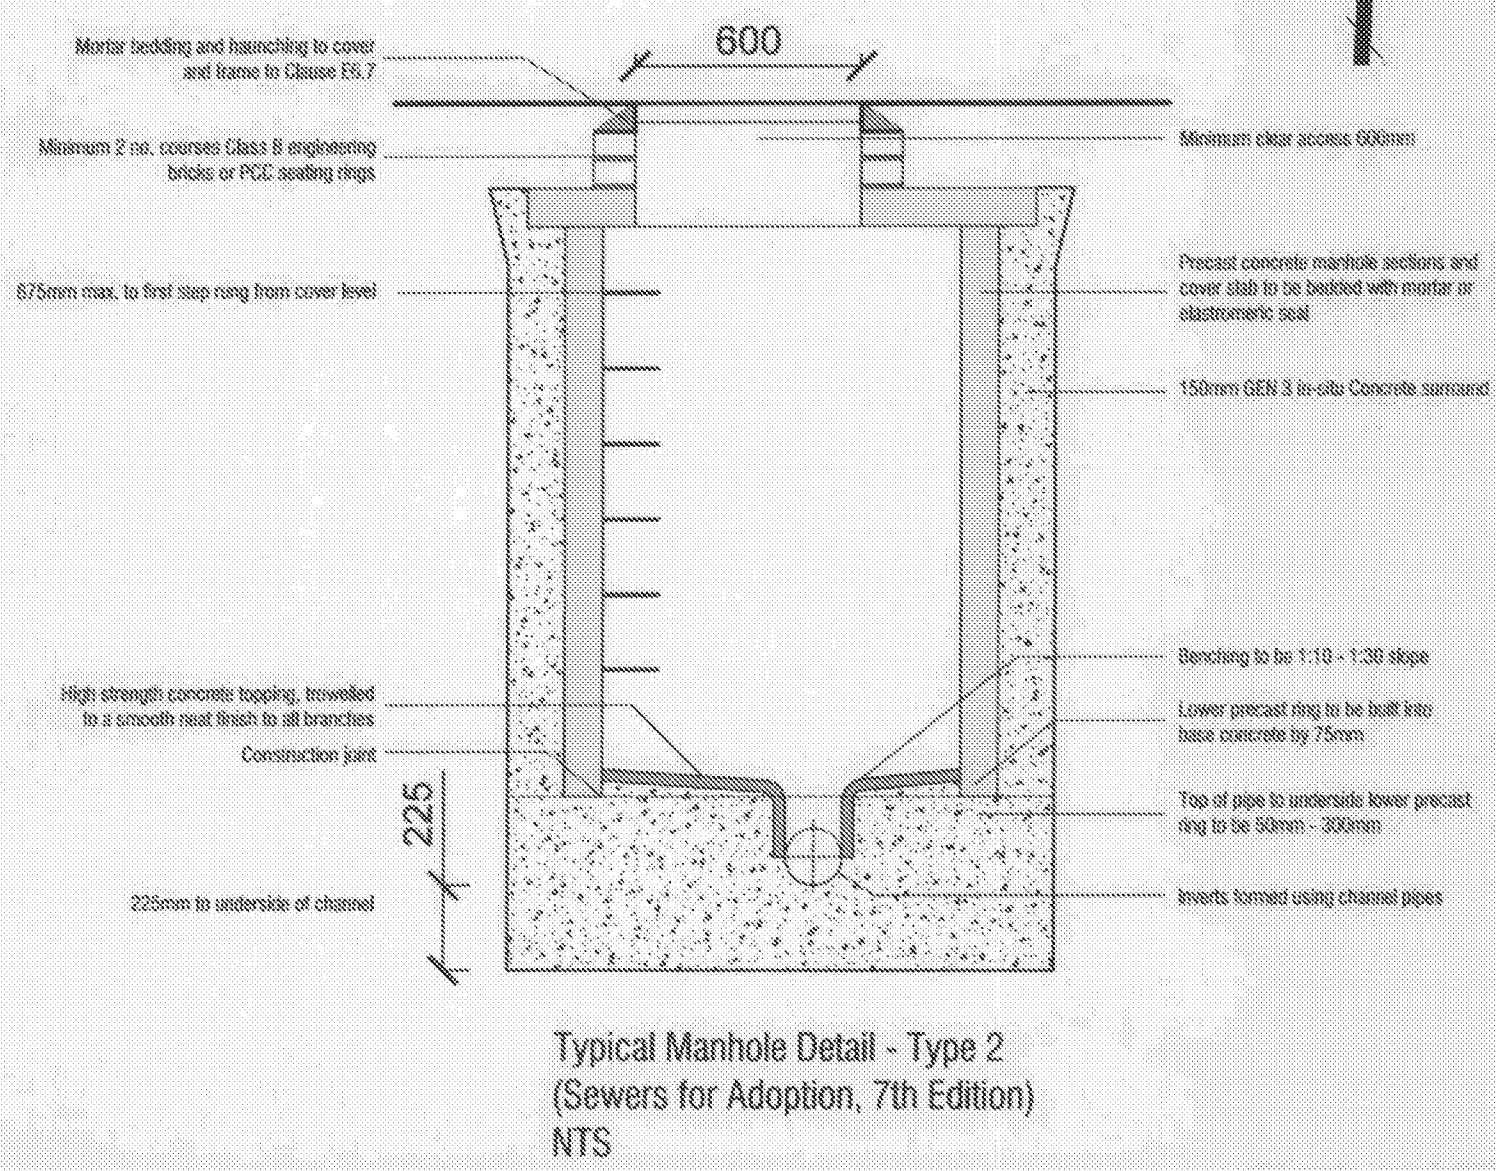

Gulley Connection Detail to Stack (Unit D2)
1:20