


A1
1
2
3
4
5
6
7
8
9
10
11

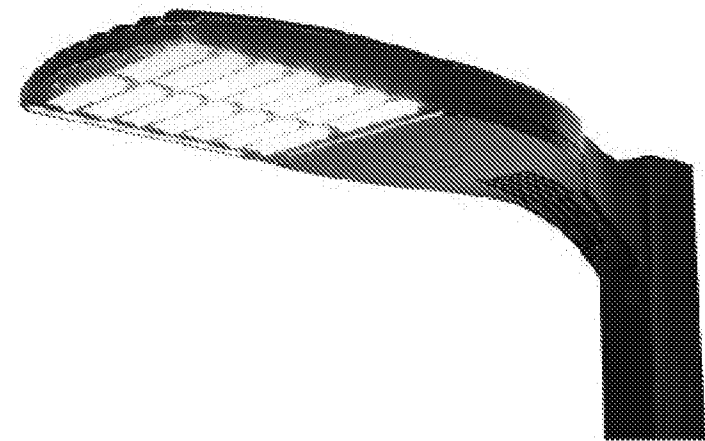

HOLOPHANE D-SERIES 1
LUMINAIRE




DEXTRA CANOPY
LUMINAIRE

STATISTICS

Description	Symbol	Avg	Min	Min/Avg
Air & Water 100 Lux Ave	+	104 lux	68 lux	0.65
Footpath	+	42 lux	14 lux	0.33
PFS Forecourt 50 Lux Ave	+	59 lux	28 lux	0.47
Parking 20 Lux Ave / 7 Min	+	52 lux	28 lux	0.54
Split Light	+	1 lux	0 lux	0.00
Under Canopy 200 Lux Ave	+	226 lux	132 lux	0.58

LUMINAIRE SCHEDULE

Symbol	Label	Qty	Catalog Number	Description	Lamp	Lumens Per Lamp	Watts
	FW22/6m	4	DSX1.2.LA224.FW	D-Series 1 Luminaire c/w 22,000 lm Output c/w FW Forward Throw Optic on 6m Column	LED C.22000LM-4000K	21874.73	208
	FW22/5m	1	DSX1.2.LA224.FW	D-Series 1 Luminaire c/w 22,000 lm Output c/w FW Forward Throw Optic on 5m Column	LED C.22000LM-4000K	21874.73	208
	SY22/6m	1	DSX1.2.LA224.AY	D-Series 1 Luminaire c/w 22,000 lm Output c/w SY Symmetric optic on 6m Column	LED C.22000LM-4000K	21874.73	208
	AY22/6m	2	DSX1.2.LA224.SY	D-Series 1 Luminaire c/w 22,000 lm Output c/w AY Asymmetric optic on 6m Column	LED C.22000LM-4000K	21874.73	208
	K1	12	PFC65 74 R11HW C84 CL (ASDA Y)	Dextra Canopy IP65 - Clear Glass Surface Box	LED C.8,500LM-4000K	8507	76.02

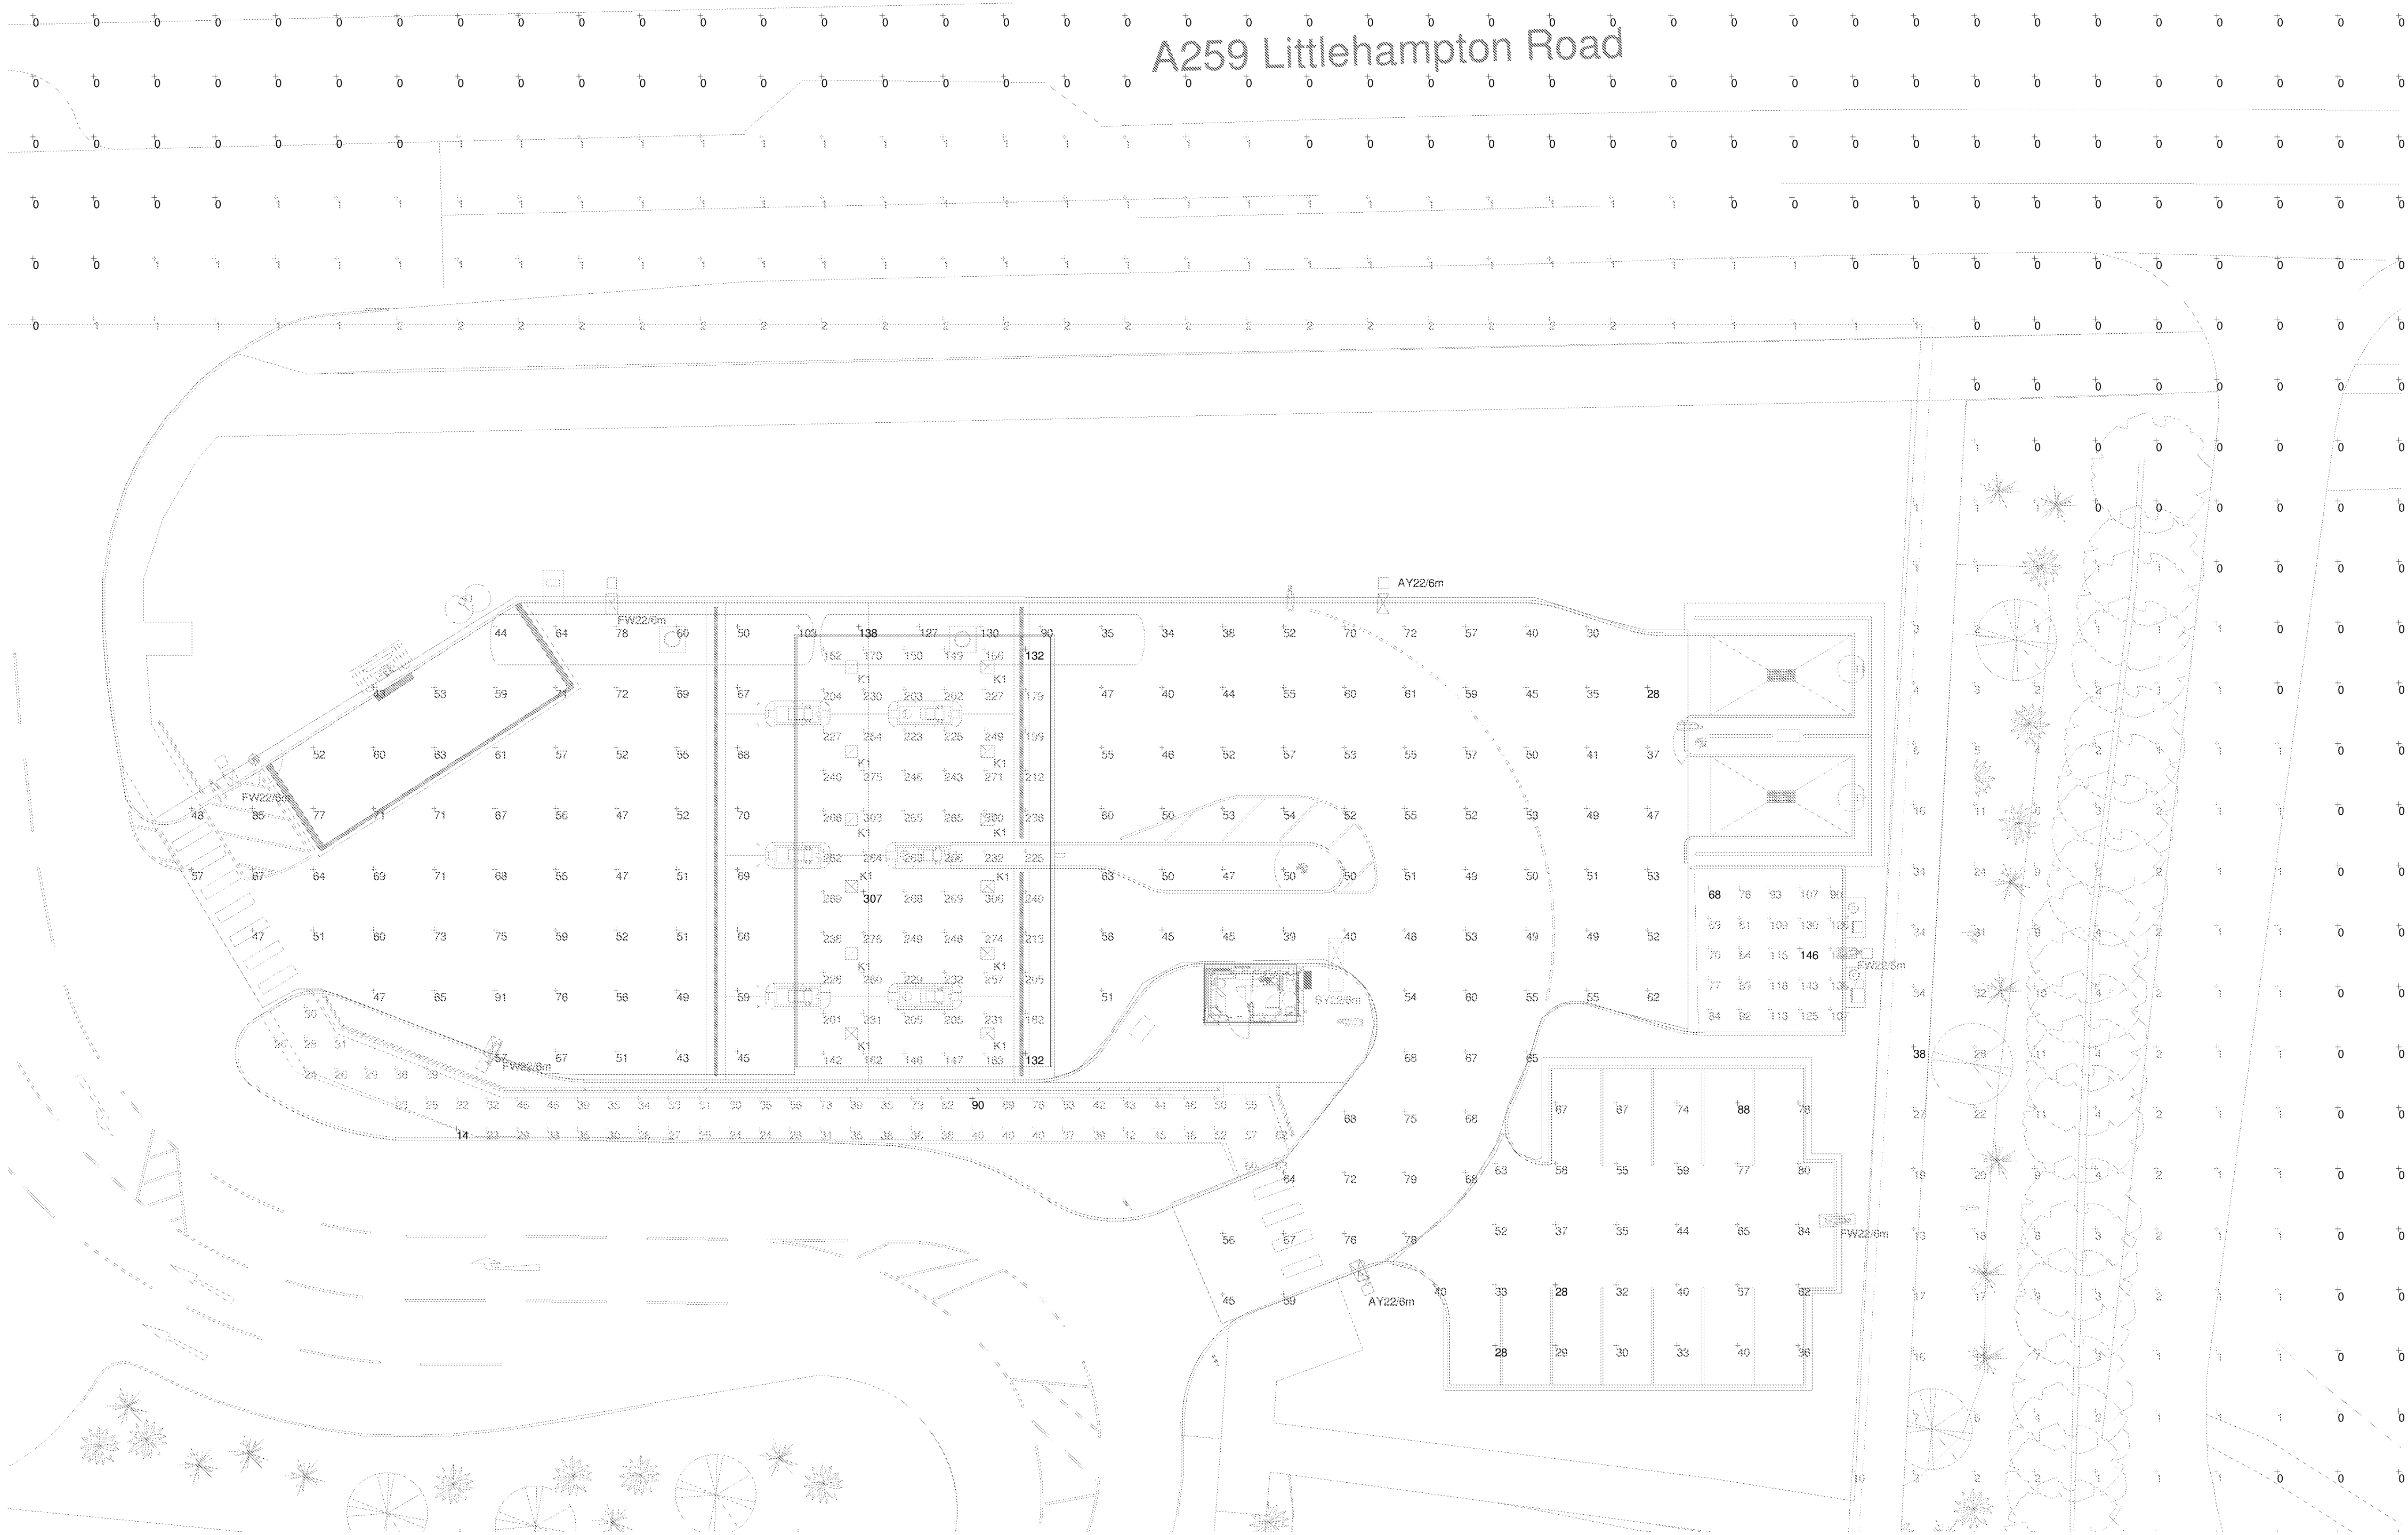

This drawing is the property of DDA Ltd Consultant Engineers. It must not be reproduced in whole or in part, nor the design used without prior written consent. This drawing and associated documents are strictly private and confidential and should not be discussed with anyone other than members of the design team. Do not scale from this drawing.

SAFETY, HEALTH & ENVIRONMENTAL INFORMATION
Refer to the DDA Ltd project specific risk assessment and design criteria for the M&E services installation. The installing contractor must prepare method statements for the installation works and agree all works in advance with the main contractor.

It is assumed that all works associated with this drawing will be carried out by competent operatives working, where appropriate, to an approved method.

NOTES

A	11-12-17	EXTERNAL LIGHTING REVISED TO NEW LAYOUT	NP
Rev	Date	Description	Eng

DDA
Building Services i Consultant Engineers

Elaine Greenwood & Associates Ltd
R&M Business Centre
Sandwich Trading Estate
Sandwich Road, Sandwich
Kent ME10 2YU
01304 268757
01304 275112
info@ddahd.co.uk
www.ddahd.co.uk

ASDA
Save money. Live better.

Project
**WORTHING FERRING PFS
EXTERNAL LIGHTING**

Drawing Title
**PETROL FILLING STATION
FORECOURT LIGHTING PLOT**

Scale at A1 1:200	Date 30-11-17
Drawn A.GREENWOOD	Engineer N.PHILLIPS
Status FOR INFORMATION	Checked
Drawing No. 17/2827/ EX/ 0001	Rev A