
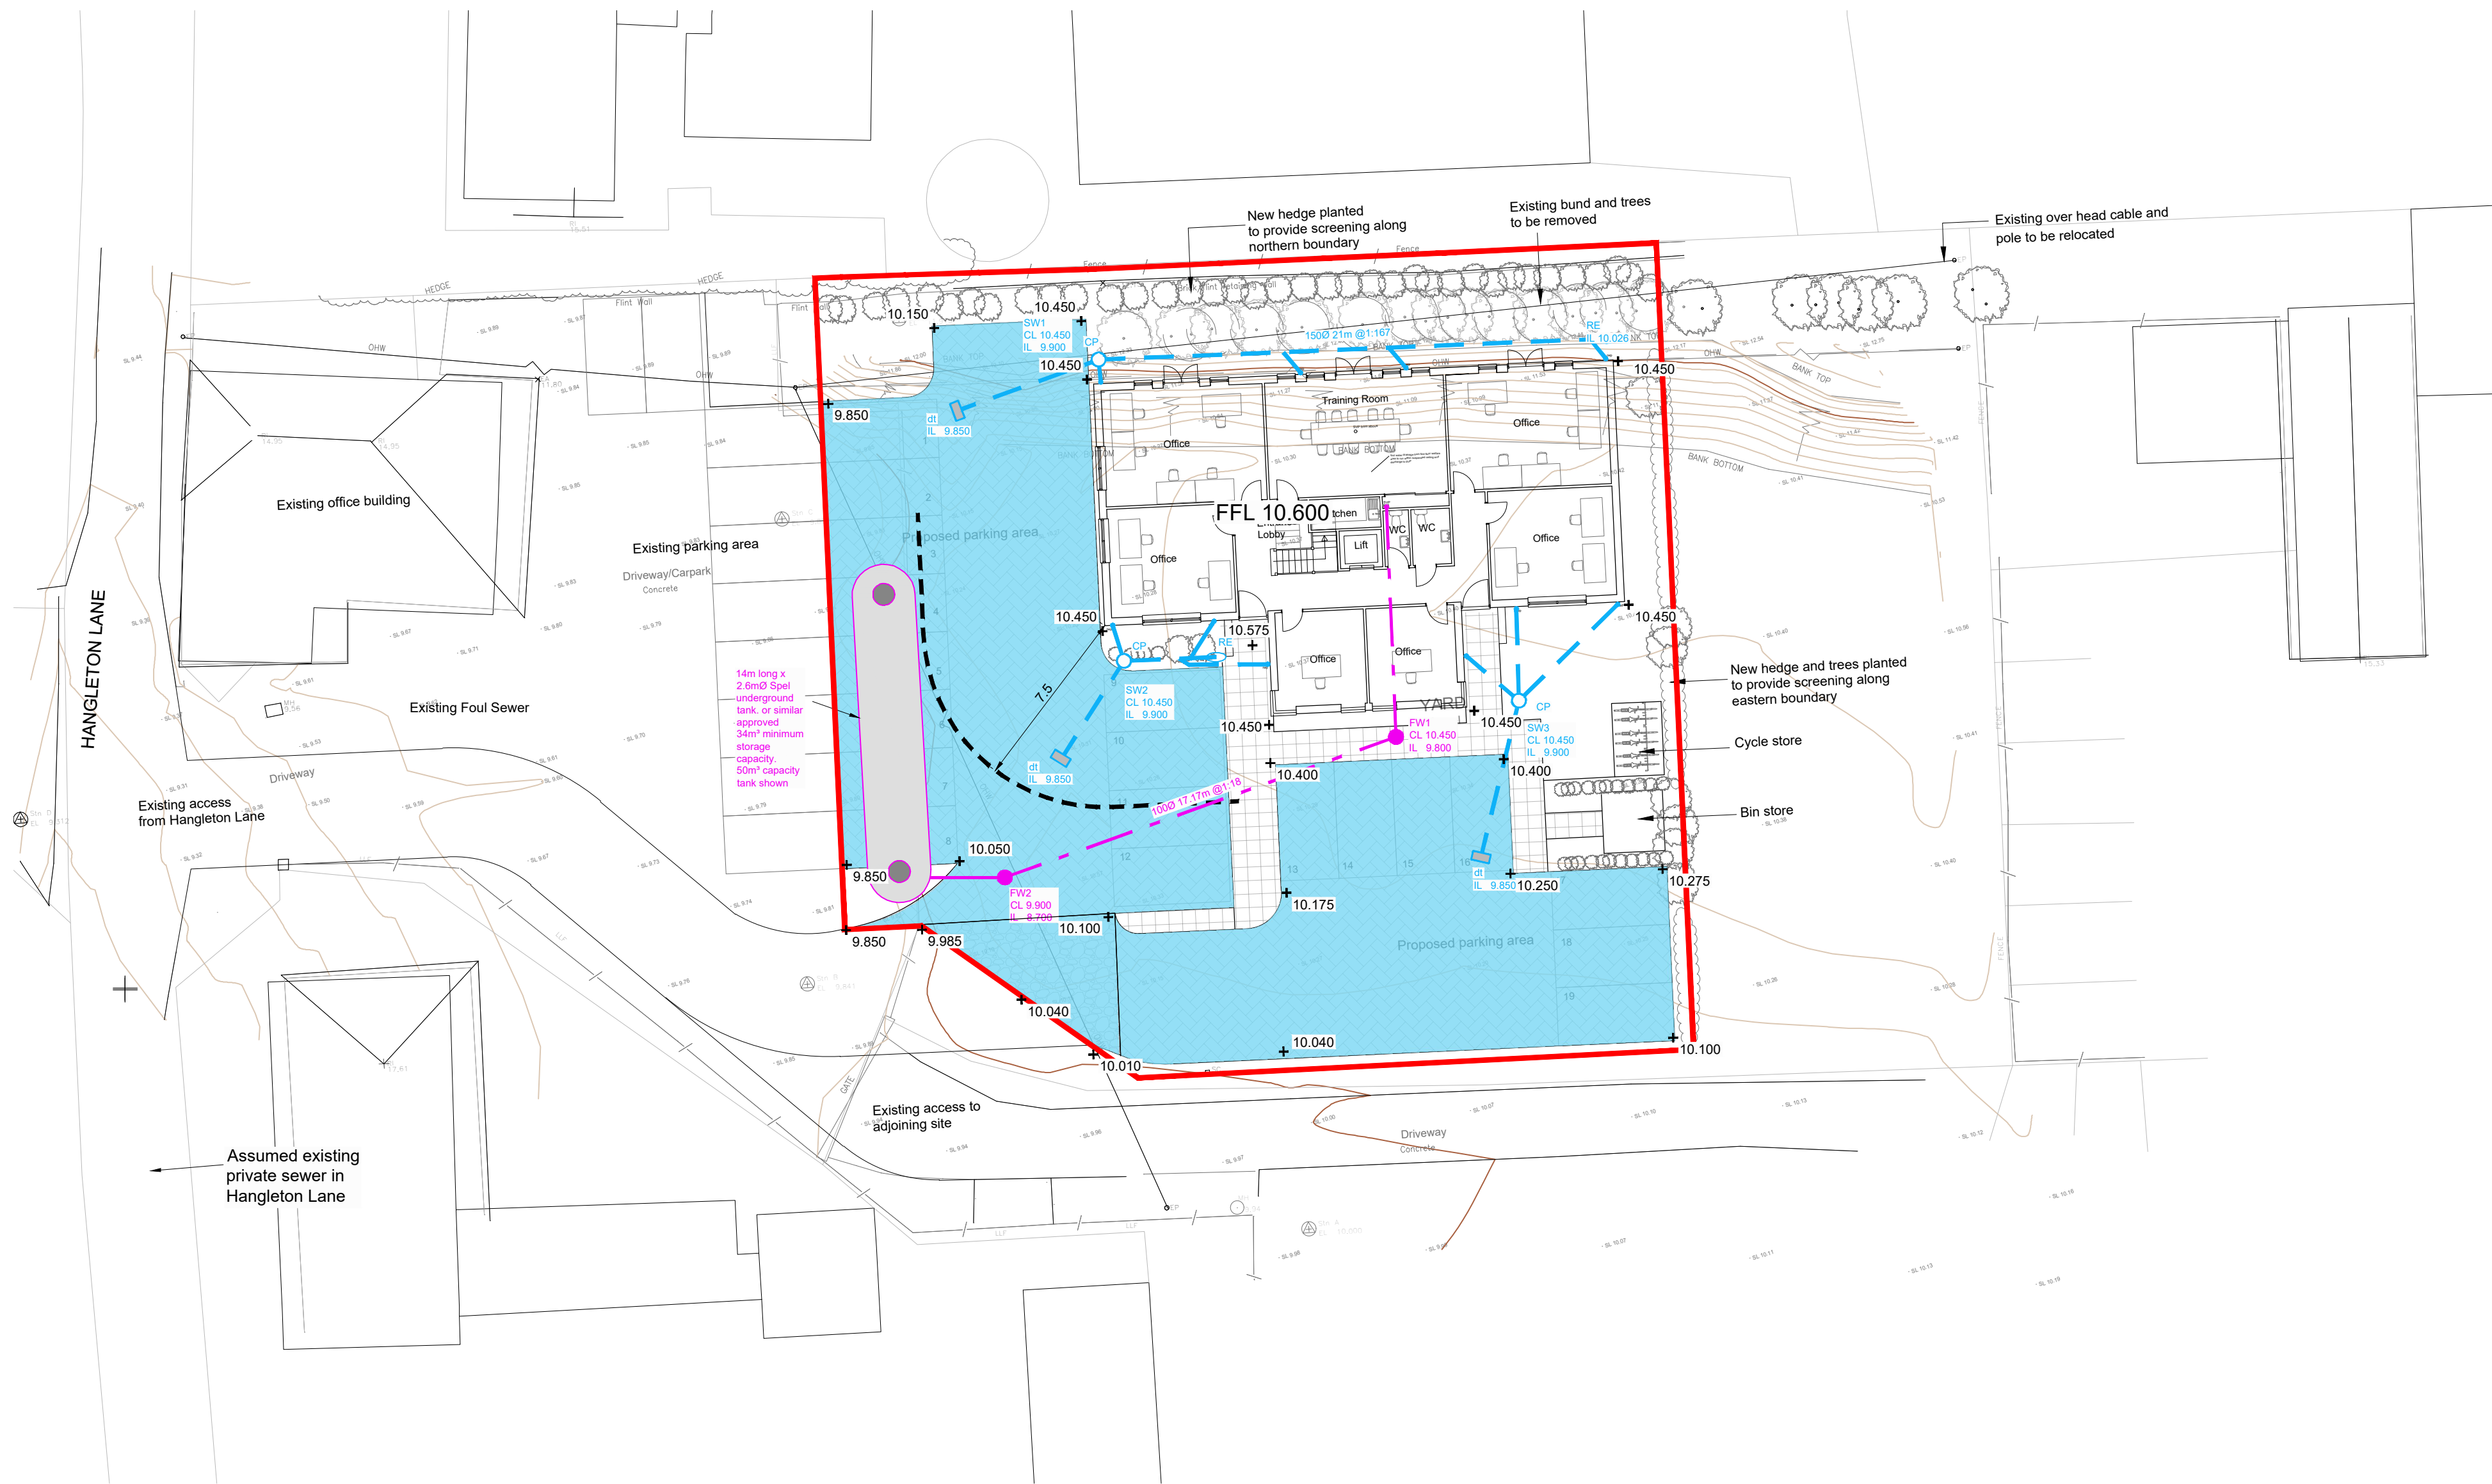


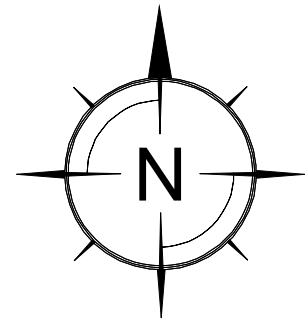

Drainage Legend:

- Existing Foul Sewer (private)
- Private Type 4 Storm Water Inspection Chamber
- Private Storm Water Rodding Eye
- Catchpit
- Diffuser tanks
- Voided subbase for attenuation and filtration, 526m³ providing Minimum 34m³ of storage required
- Private Type 4 Foul Water Inspection Chamber
- Site boundary

Surface Finishes Legend:

- Paving flags impermeable with falls to landscaping areas
- Permeable paving with voided subbase beneath.
- Permeable gravel surface to match existing with voided subbase beneath.

Note:
Surface finishes are shown for illustrative purposes only.
See architect's design and details

- NOTES:**
- All dimensions to be checked on site. All details and dimensions relating to sub-Contractors work must be checked and agreed between the sub-Contractor or supplier and the general Contractor.
 - This drawing is to be read in conjunction with all relevant Architect's and Engineer's drawings and specification.
 - The main Contractor is responsible for ensuring the stability of the structure whilst the works are in progress.
 - Any information given regarding existing underground services is given in good faith after consultation with the relevant authority. No liability is accepted by the Consultant and the main Contractor is responsible for obtaining and checking all information and taking due care and attention whilst undertaking the works.

A	03.03.21	MJP	Spel tank added	MK
REV	DATE	INT	DESCRIPTION	CHK

Issue Status **FOR APPROVAL**



The Civil Engineering Practice
11 Tungsten Building
George Street
Fishergate
Sussex
BN41 1RA
01273 424424
reception@civil.co.uk
www.civil.co.uk

CLIENT	Sussex District Carers Ltd				
PROJECT	Hangleton Nurseries, Hangleton Lane Ferring				
TITLE	Proposed Drainage Layout Plan				
DRAWN	M Pacifico	DATE	Feb 2021		
ENGINEER	M Kempshall	CHECKED			
SCALE	1:200 @ A1		PROJECT NO.	23487	
			DRG. No.	201	REV. A

