

notes

Do not scale directly from drawing. all measurements are to be taken from site prior to the commencement of works.
three|eleven design (trading name of eleven design Ltd)
reserves the right to all drawings produced, please see company Terms & Conditions for further details

	GAS METERS
	ELECTRICAL METERS
	BOILER
	CONSUMER UNIT
	MEGAFLOW UNIT
	RADIATOR
	DIRECTION OF ROOF FALL
	INSULATION
	INSPECTION CHAMBER
	SOLE VENTILATION STACK
	STUB STACK
	RAINWATER PIPE
	FOUL GULLY
	WATER FEED/COR TAPS
	SMOKE DETECTOR
	HEAT DETECTOR
	TOUGHENED SAFETY GLASS
	OBSOLETE GLAZING
	15L.5 MECHANICAL VENTILATION
	60L.5 MECHANICAL VENTILATION
	KITCHEN VENTILATION FLUE
	BATHROOM VENTILATION FLUE
	UTILITY ROOM VENTILATION FLUE
	TUMBLE DRYER VENTILATION
	PENDANT LIGHT FITTING
	WALL MOUNTED LIGHT FITTING
	SPOT / DOWN LIGHT FITTING
	UP LIGHT FITTING
	FIRE ALARM BELL
	FIRE ALARM PANEL
	FIRE ALARM BREAK POINT
	ELECTRICAL SOCKET
	ELECTRICAL DOUBLE SOCKET
	SPECIAL GRADE SOCKET
	SOCKET SWITCH
	TWO WAY SOCKET SWITCH
	INTERNET AND PHONE CONNECTION
	CABLE / TV DIGITAL SOCKET

date	revision	description
------	----------	-------------

project:
29 FERRING LANE, FERRING, W. SUSSEX
PROPOSED INTERNAL ALT. & GLAZING ALT

client:
DAVID & ANGELA SEARLE

three|eleven
DESIGN

01273 688 744
info@threeeleven.co.uk
www.threeeleven.co.uk


Unit 1
100 North Road
Brighton
BN1 1YE

title:
AS EXISTING FIRST FLOOR PLAN

project no:	drawing no:	revision:
414FR29	414FR29/02	/

date: 17/SEP/16 scale: 1:50 @ A1 draw: RUB & DJC

drawing status: PLANNING

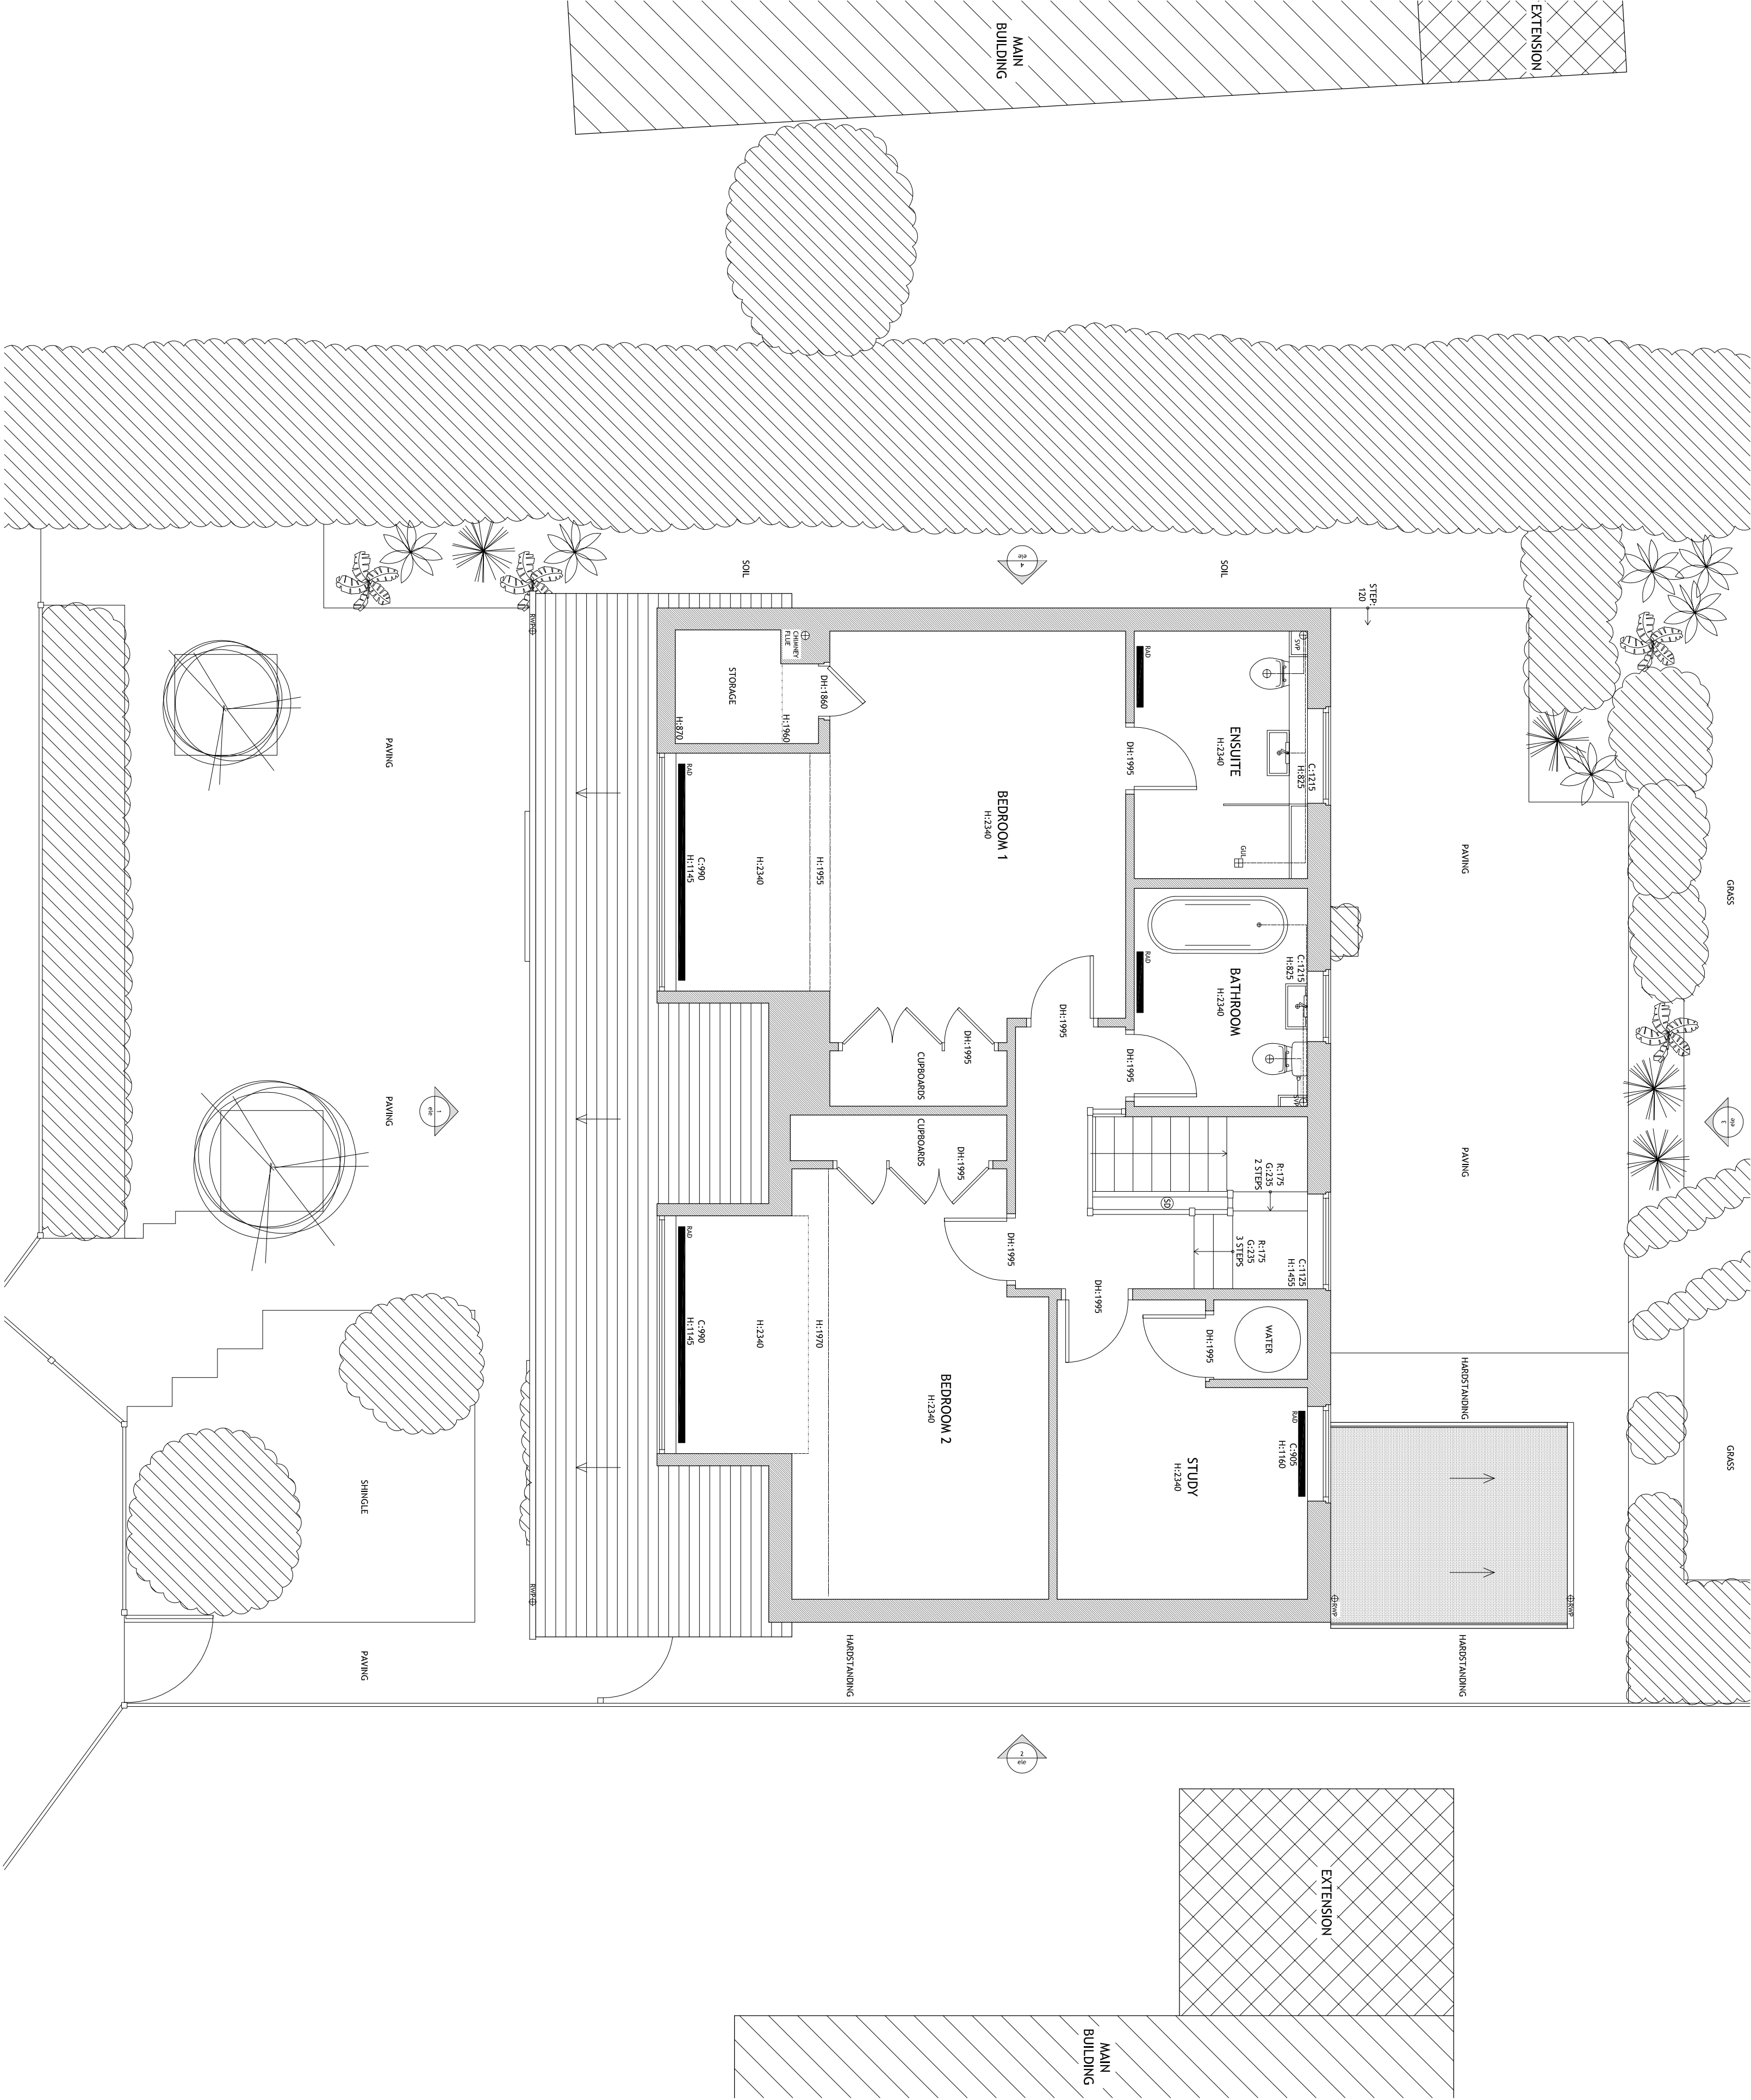

AS EXISTING FIRST FLOOR PLAN 1:50 @ A1

