

notes
Do not scale directly from drawing, all measurements are to be taken from site prior to the commencement of works.
three | eleven design (trading name of 3aeven design Ltd) reserves the right to all drawings produced, please see company Terms & Conditions for further details

GAS METERS

ELECTRICAL METERS

BOILER

CONSUMER UNIT

M/F

MEGALOW UNIT

RADIATOR

DIRECTION OF ROOF FALL

INSPECTION CHAMBER

SOIL VENTILATION STACK

STUB STACK

RAINWATER PIPE

GULLY

WATER FEED/ON TAPS

SMOKE DETECTOR

HEAT DETECTOR

TOUGHENED SAFETY GLASS

15L/5 MECHANICAL VENTILATION

30L/5 MECHANICAL VENTILATION

60L/5 MECHANICAL VENTILATION

KITCHEN VENTILATION FLUE

BATHROOM VENTILATION FLUE

UTILITY ROOM VENTILATION FLUE

BOILER EXTER VENTILATION

TUMBLE DRYER VENTILATION

PENDANT LIGHT FITTING

WALL MOUNTED LIGHT FITTING

SPOT / DOWN LIGHT FITTING

UP LIGHT FITTING

FIRE ALARM BELL

FIRE ALARM PANEL

FIRE ALARM BREAK POINT

ELECTRICAL SOCKET

ELECTRICAL DOUBLE SOCKET

SPECIAL GRABE SOCKET

SOCKET SWITCH

TWO WAY SOCKET SWITCH

INTERNET AND PHONE CONNECTION

CABLE / TV / DIGITAL SOCKET

date	revision	description

project:
29 FERRING LANE, FERRING, W. SUSSEX
PROPOSED INTERNAL ALT. & GLAZING ALT

client:
DAVID & ANGELA SEARLE

three|eleven

DESIGN

01273 688 744
info@3eleven.co.uk
www.3eleven.co.uk


Unit 1
100 North Road
Brighton
BN1 1YE

title:
PROPOSED ROOF PLAN

project no:	drawing no:	revision:
414FR29	414FR29/08	/

date:	scale:	drawn:
23/MAR/17	1:50 @ A1	RJB & DJC

drawing status:
PLANNING

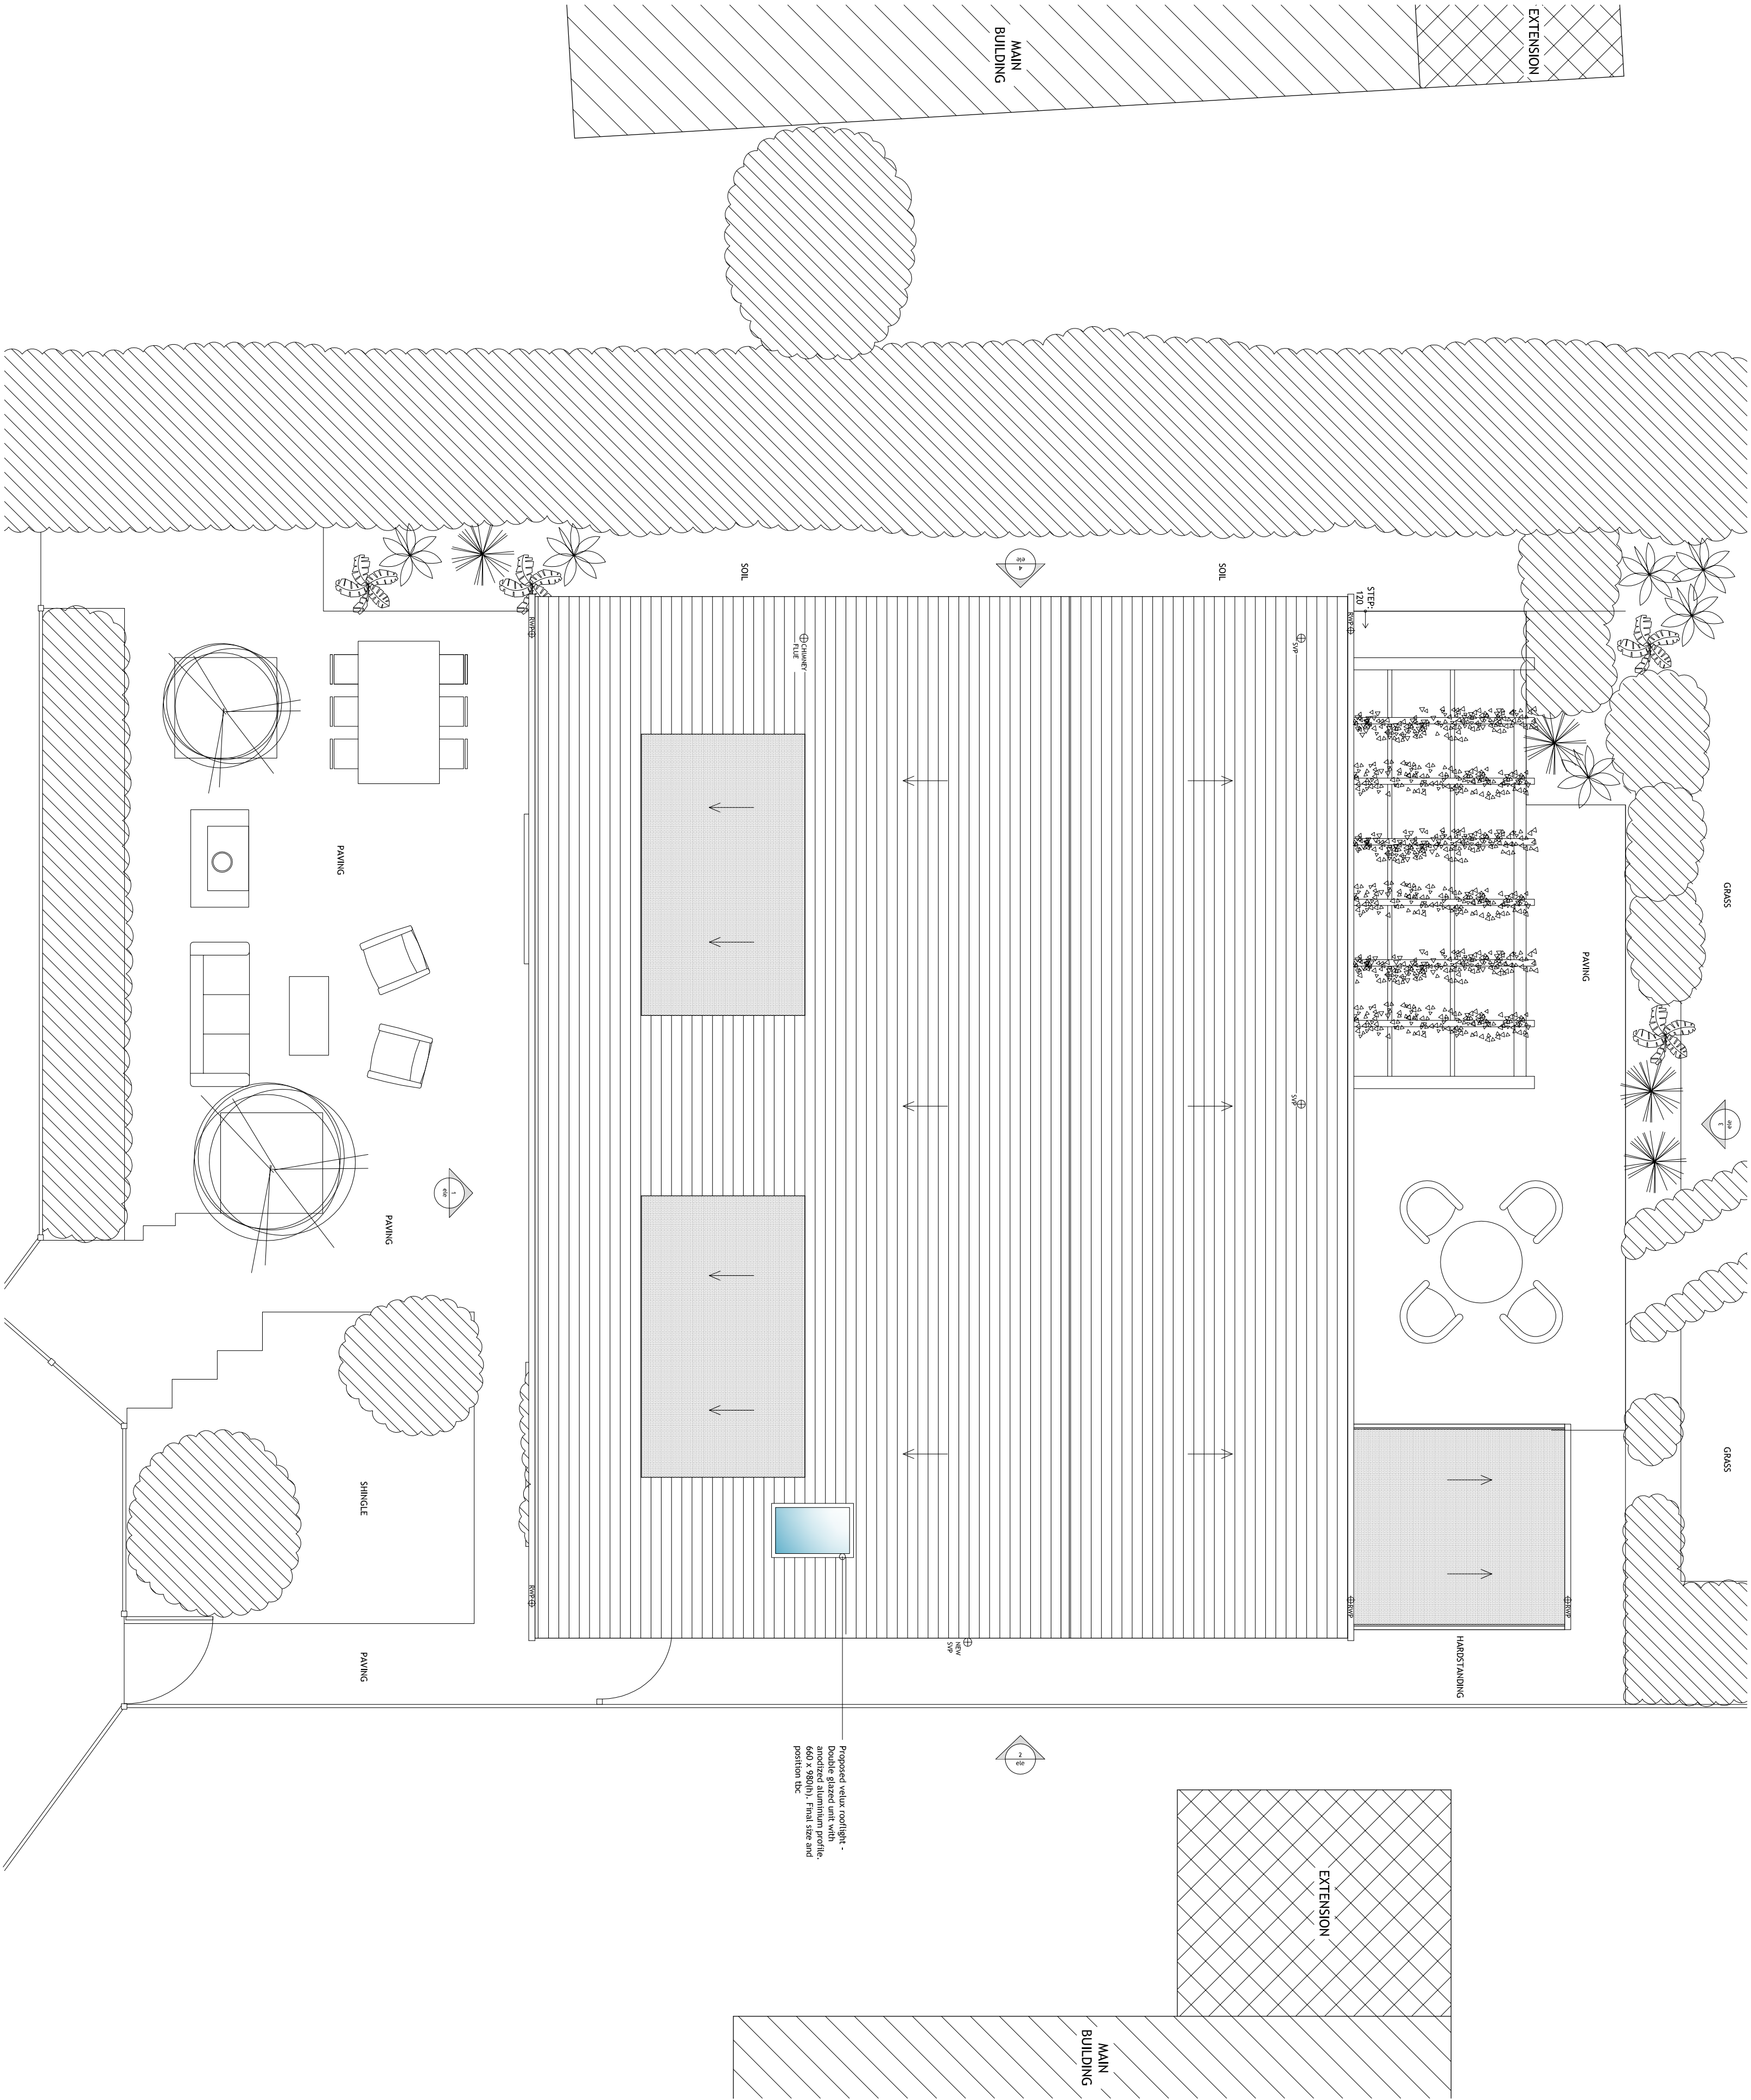

PROPOSED ROOF PLAN 1:50 @ A1

N

0 0.5 1.0 2.0 3.0 4.0 5.0 10.0

Scale in metres