 



notes

Do not scale directly from drawing. all measurements are to be taken from site prior to the commencement of works.


three|eleven design (trading name of eleven design Ltd) reserves the right to all drawings produced, please see company Terms & Conditions for further details



 GAS METERS



ELECTRICAL METERS

 

BOILER



 
CONSUMER UNIT




MEGAFLOW UNIT



RADIATOR




DIRECTION OF ROOF FALL

 

INSULATION



 
SOLE VENTILATION STACK



STUB STACK



 
RAINWATER PIPE



GULLY



 
WATER FEED/OR TAPS



SMOKE DETECTOR



 
HEAT DETECTOR




TOUGHENED SAFETY GLASS



 
OBSOLETE GLAZING



 150.5 MECHANICAL VENTILATION



 300.5 MECHANICAL VENTILATION



KITCHEN VENTILATION FLUE



BATHROOM VENTILATION FLUE



UTILITY ROOM VENTILATION FLUE



BOILER VENTILATION FLUE



TUMBLE DRYER VENTILATION



PENDANT LIGHT FITTING



 
WALL MOUNTED LIGHT FITTING



SPOT / DOWN LIGHT FITTING



UP LIGHT FITTING



FIRE ALARM BELL



FIRE ALARM PANEL



 
FIRE ALARM BREAK POINT




ELECTRICAL SOCKET



ELECTRICAL DOUBLE SOCKET




SPECIAL GRADE SOCKET

 

SOCKET SWITCH



 TWO WAY SOCKET SWITCH





INTERNET AND PHONE CONNECTION



CABLE / TV DIGITAL SOCKET

 AS EXISTING ROOF PLAN 1:50 @ A1

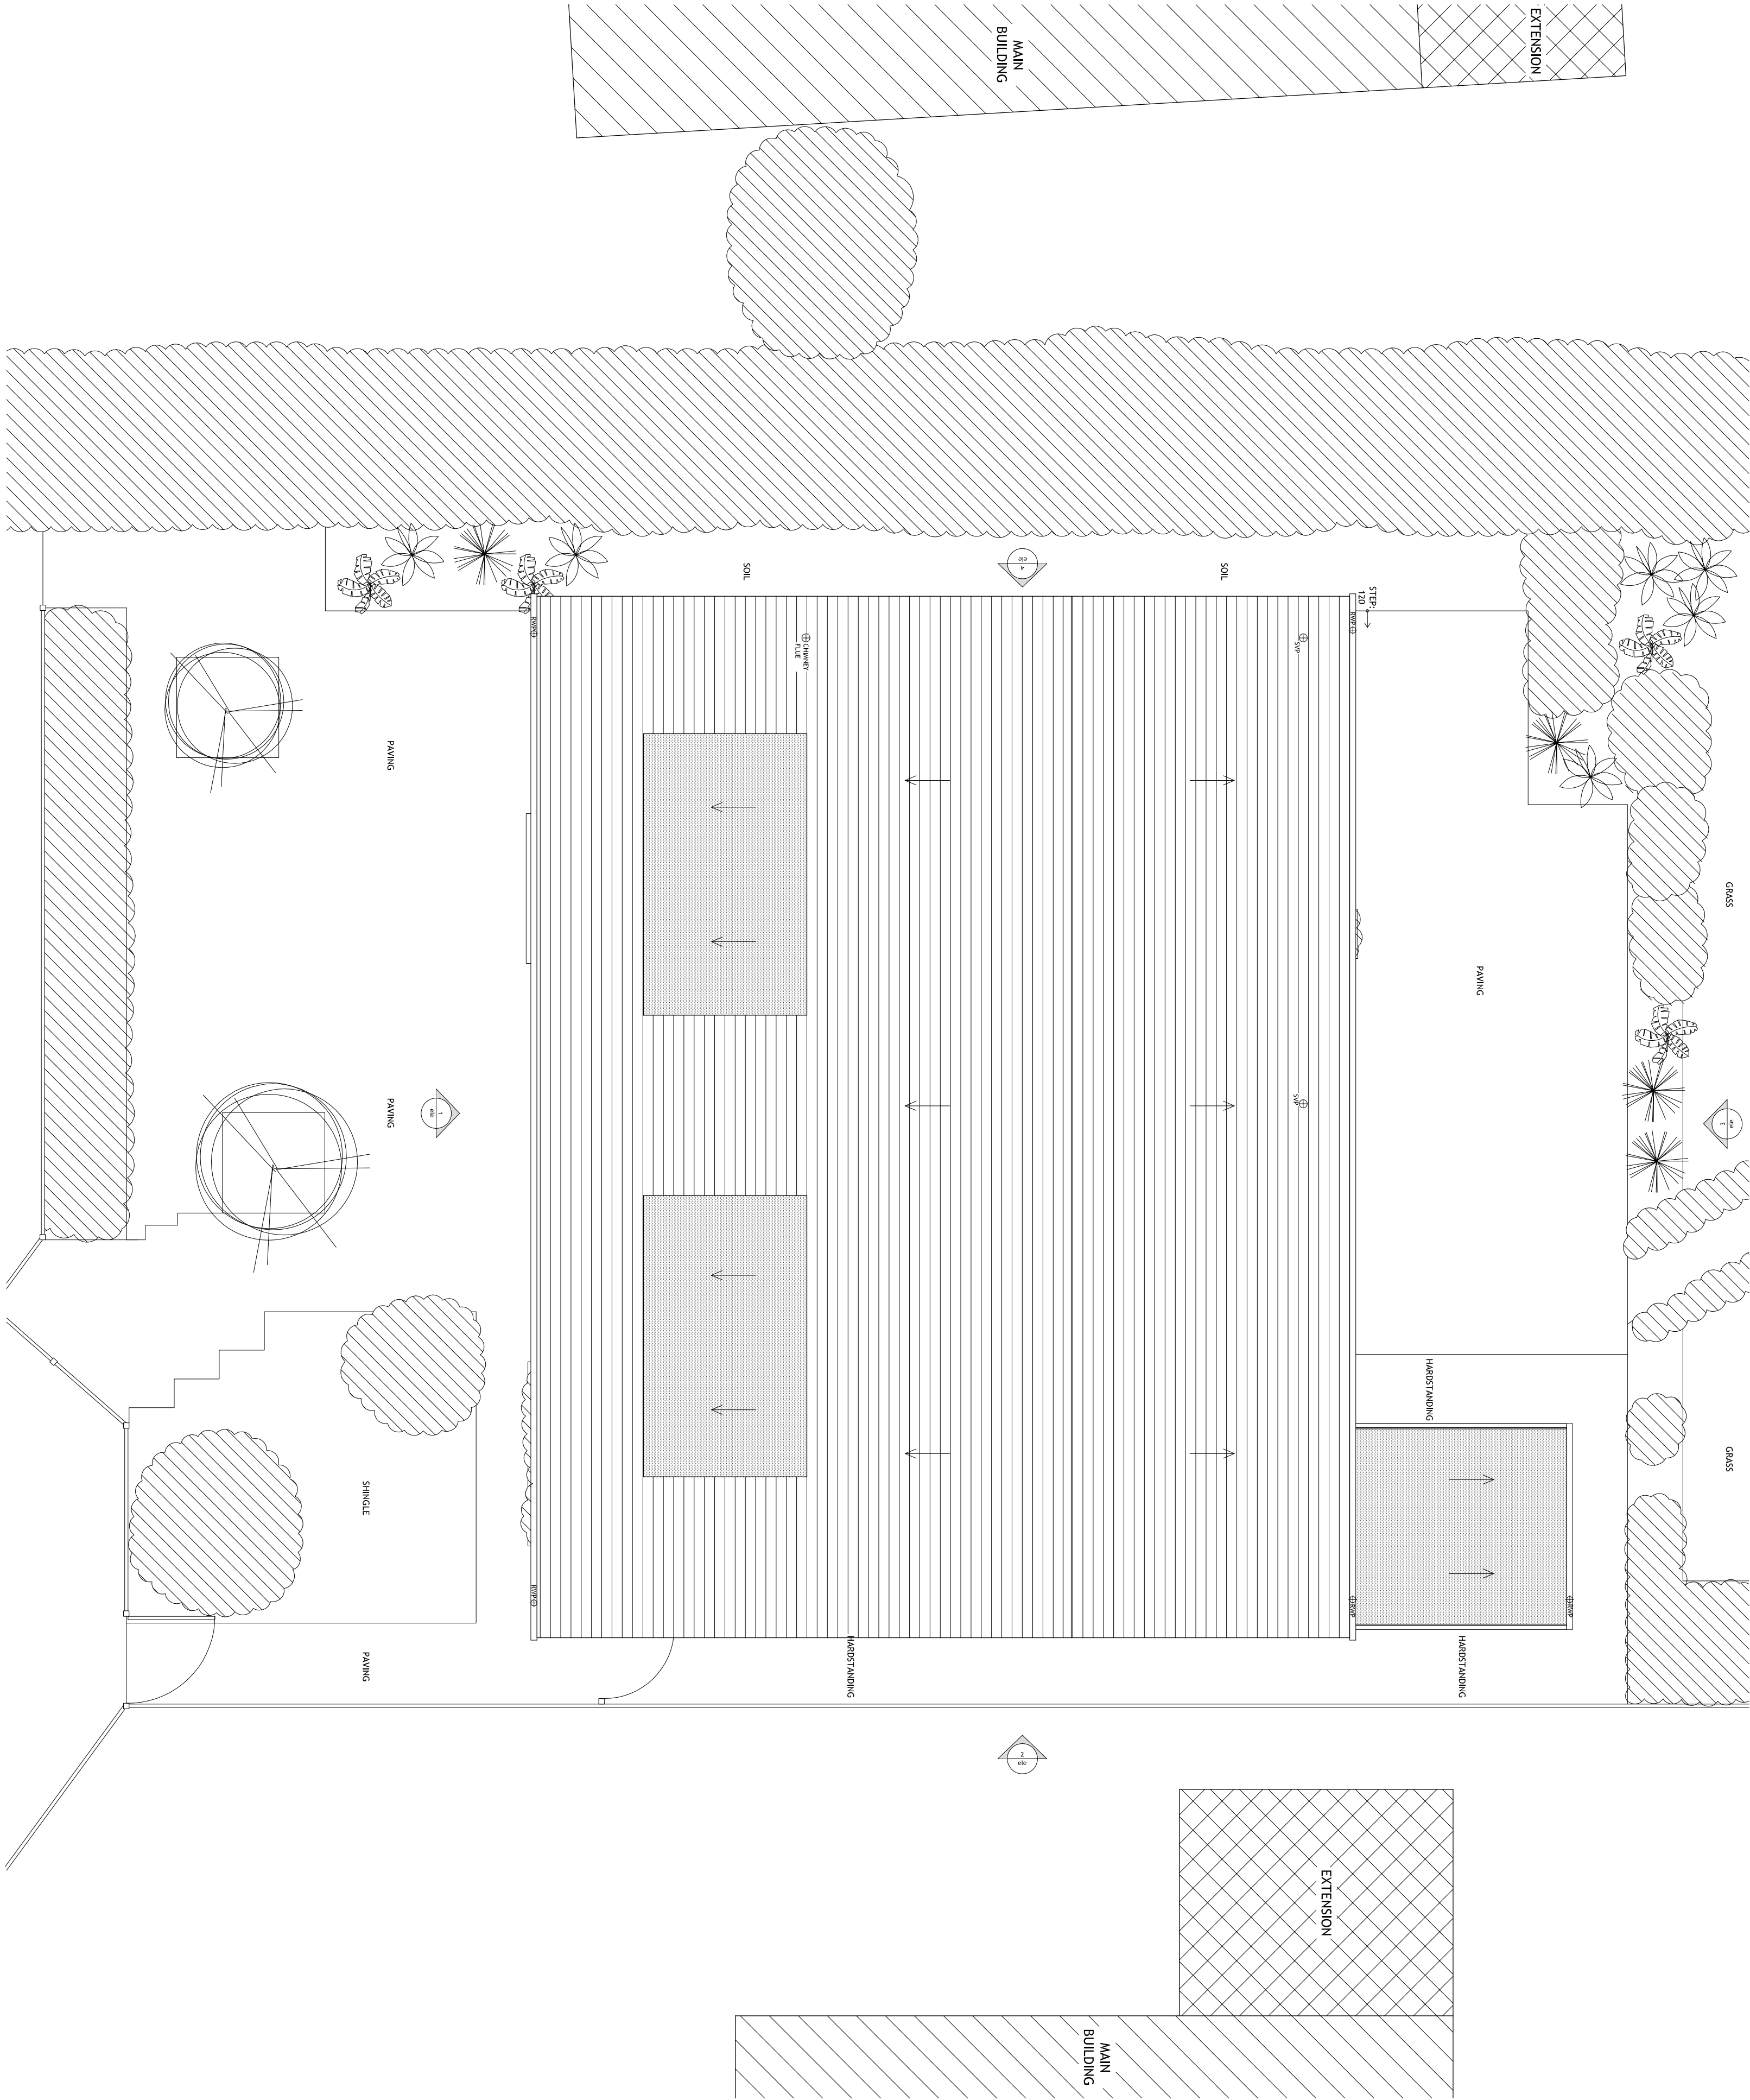



N



Scale in metres

title:		AS EXISTING ROOF PLAN	
project no:	drawing no:	revision:	
414FR29	414FR29/03	/	
date:	scale:	drawn:	
17/SEP/16	1:50 @ A1	RJB & DJC	
drawing status:			
PLANNING			

Unit 1
100 North Road
Brighton
BN1 1YE

01273 688 744
info@threeeleven.co.uk
www.threeeleven.co.uk

three|eleven
DESIGN

Project:
29 FERRING LANE, FERRING, W. SUSSEX
PROPOSED INTERNAL ALT. & GLAZING ALT

Client:
DAVID & ANGELA SEARLE