

notes
Do not scale directly from drawing, all measurements are to be taken from site prior to the commencement of works.
three | eleven design (trading name of 3aeven design Ltd) reserves the right to all drawings produced, please see company Terms & Conditions for further details

	GAS METERS
	ELECTRICAL METERS
	BOILER
	CONSUMER UNIT
	MFL
	RADIATOR
	DIRECTION OF ROOF FALL
	INSPECTION CHAMBER
	SOL VENTILATION STACK
	STUB STACK
	RAINWATER PIPE
	GULLY
	WATER FEED/ON TAP
	SMOKE DETECTOR
	HEAT DETECTOR
	TOUGHENED SAFETY GLASS
	15L/S MECHANICAL VENTILATION
	30L/S MECHANICAL VENTILATION
	60L/S MECHANICAL VENTILATION
	KITCHEN VENTILATION FLE
	BATHROOM VENTILATION FLE
	UTILITY ROOM VENTILATION FLE
	TUMBLE DRYER VENTILATION
	PENDANT LIGHT FITTING
	WALL MOUNTED LIGHT FITTING
	SPOT / DOWN LIGHT FITTING
	UP LIGHT FITTING
	FIRE ALARM BELL
	FIRE ALARM BREAK POINT
	ELECTRICAL SOCKET
	ELECTRICAL DOUBLE SOCKET
	SPECIAL GRABE SOCKET
	CABLE TV
	DIGITAL SOCKET

date	revision	description
------	----------	-------------

project:
29 FERRING LANE, FERRING, W. SUSSEX
PROPOSED INTERNAL ALT. & GLAZING ALT

client:
DAVID & ANGELA SEARLE

three | eleven
DESIGN

01273 688 744
info@3eleven.co.uk
www.3eleven.co.uk


Unit 1
100 North Road
Brighton
BN1 1YE

title:
PROPOSED FIRST FLOOR PLAN

project no:	drawing no:	revision:
414FR29	414FR29/07	/

date: 23/MAR/17
scale: 1:50 @ A1
drawn: RJB & DJC

drawing status:
PLANNING

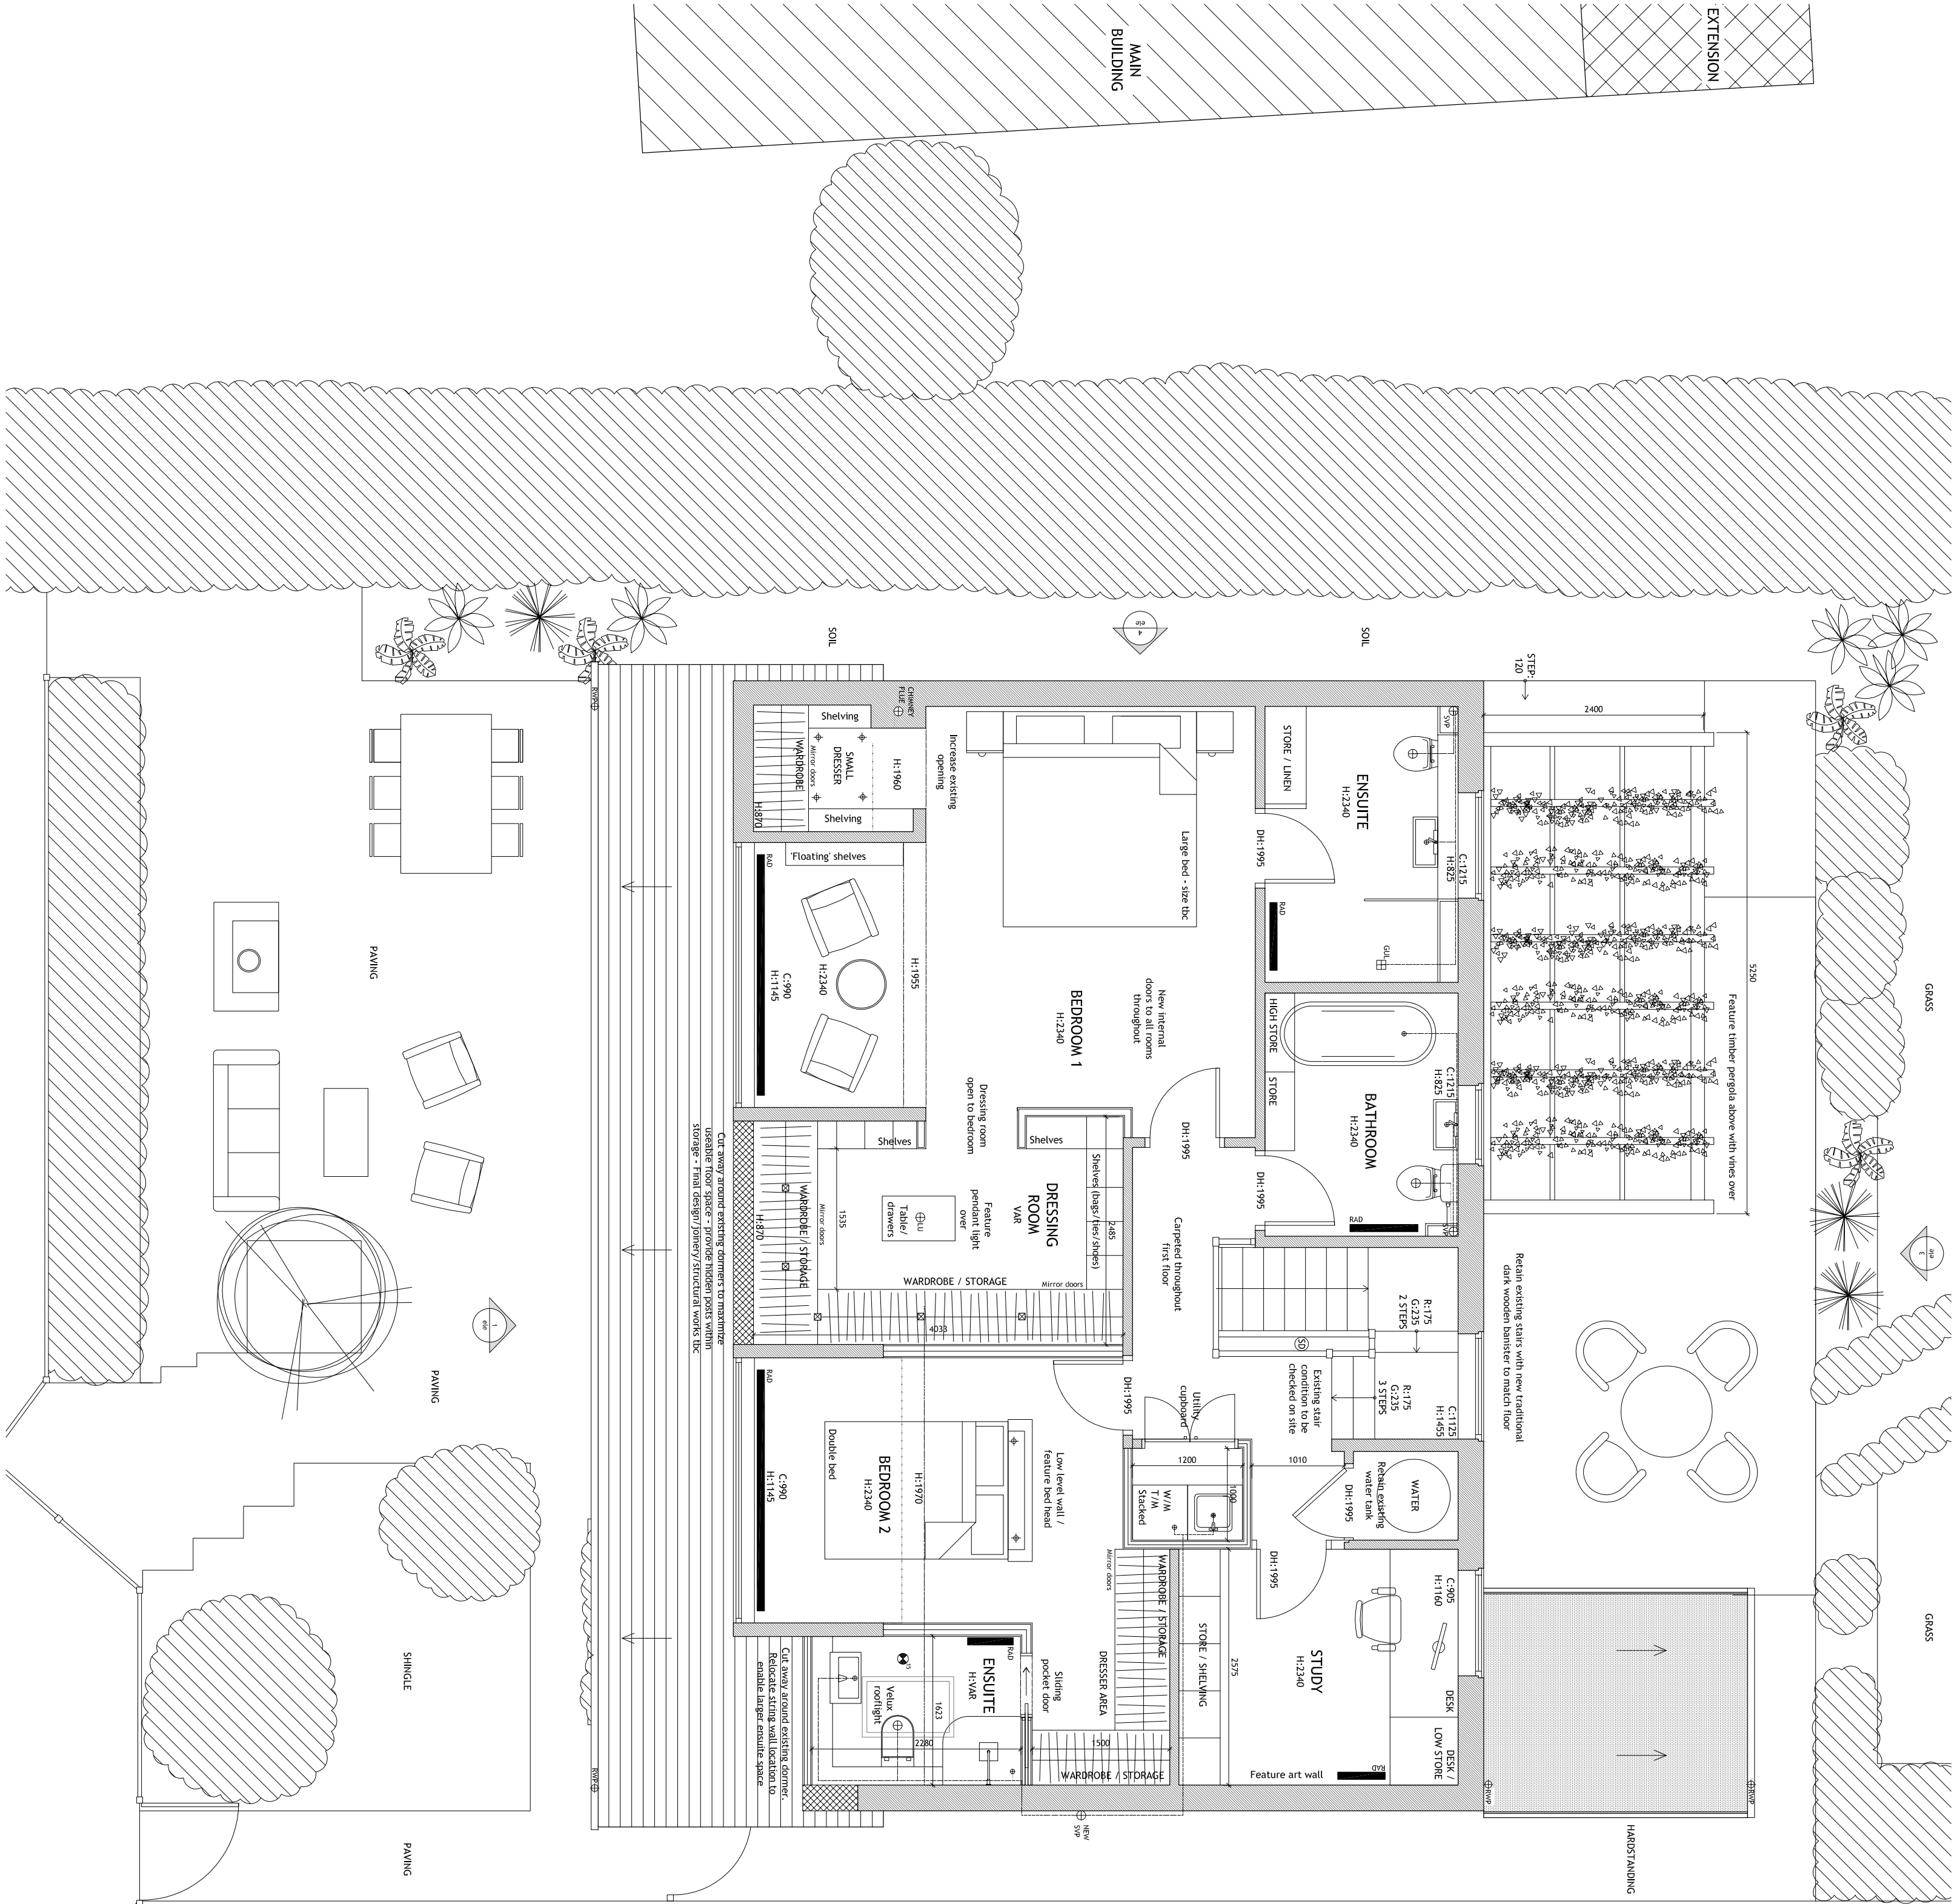

PROPOSED FIRST FLOOR PLAN 1:50 @ A1

