

notes

Do not scale directly from drawing, all measurements are to be taken from site prior to the commencement of works.

three | eleven design (trading name of 3aeaven design Ltd) reserves the right to all drawings produced, please see company Terms & Conditions for further details

	GAS METERS
	ELECTRICAL METERS
	BOILER
	CONSUMER UNIT
	M/F
	RADIATOR
	DIRECTION OF ROOF FALL
	INSPECTION CHAMBER
	SOLE VENTILATION STACK
	STUB STACK
	RAINWATER PIPE
	GULLY
	WATER FEED/OR TAPS
	SMOKE DETECTOR
	HEAT DETECTOR
	TINTED OR SAFETY GLASS
	OBSOURE GLAZING
	15L/S MECHANICAL VENTILATION
	60L/S MECHANICAL VENTILATION
	KITCHEN VENTILATION FLUE
	BATHROOM VENTILATION FLUE
	UTILITY ROOM VENTILATION FLUE
	TUMBLE DRYER VENTILATION
	PENDANT LIGHT FITTING
	WALL MOUNTED LIGHT FITTING
	SPOT / DOWN LIGHT FITTING
	UP LIGHT FITTING
	FIRE ALARM BELL
	FIRE ALARM BREAK POINT
	ELECTRICAL SOCKET
	ELECTRICAL DOUBLE SOCKET
	SOCKET SWITCH
	TWO WAY SOCKET SWITCH
	INTERNET AND PHONE CONNECTION
	CABLE / TV / DIGITAL SOCKET

date	revision	description
------	----------	-------------

project:
29 FERRING LANE, FERRING, W. SUSSEX
PROPOSED INTERNAL ALT. & GLAZING ALT

client:
DAVID & ANGELA SEARLE

three | eleven
DESIGN

01273 688 744
info@3eleven.co.uk
www.3eleven.co.uk


Unit 1
100 North Road
Brighton
BN1 1YE

title:
PROPOSED GROUND FLOOR PLAN

project no:	drawing no:	revision:
414FR29	414FR29/06	/

date: 23/MAR/17
scale: 1:50 @ A1
drawn: RJB & DJC

drawing status:
PLANNING

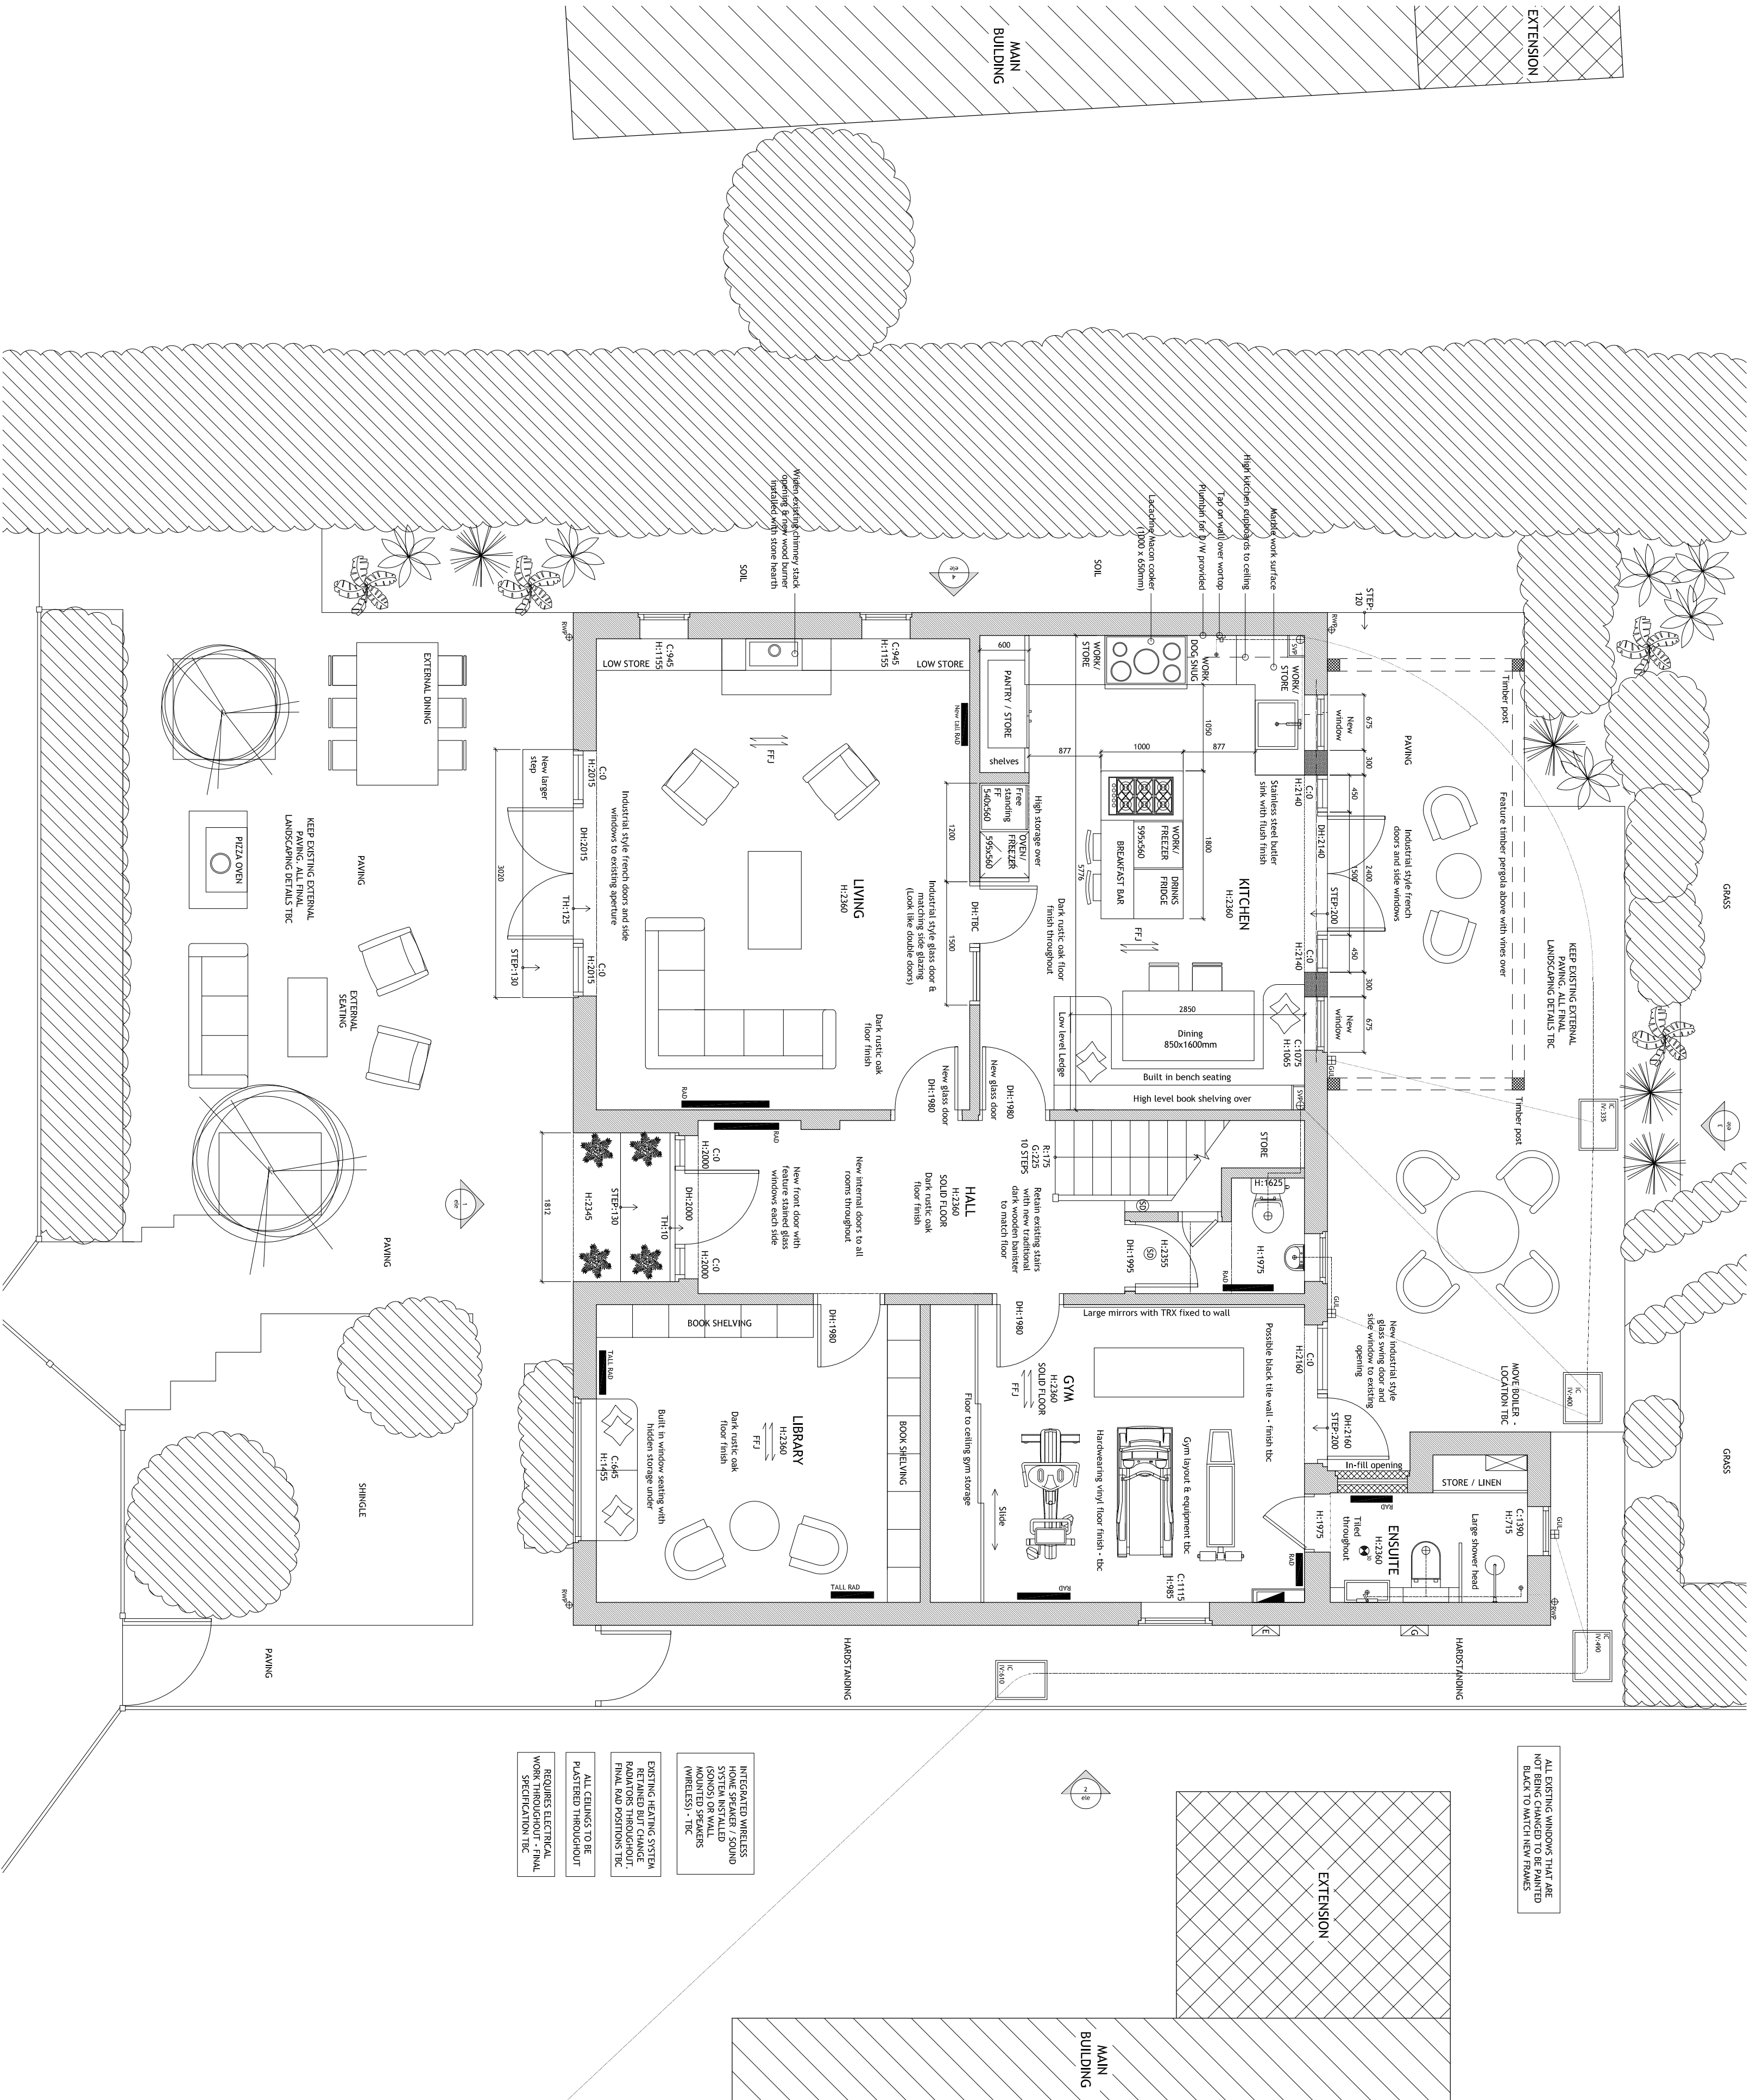

PROPOSED GROUND FLOOR PLAN 1:50 @ A1 - IDEA 1

