

Notes & Legends

All dimensions should be checked on site by contractor. Allow for 10% margin of error due to variations along existing building elements.


New M/H with redirected drainage to be confirmed with Building Inspector on site.
Hose union bib tap with double check valve for rear garden

Chimney to be removed and boiler to be repositioned

M/H and associated drainage to be sealed
Rodding access point, low on boxed SVP

Flat roof windows 930x930

Hose union bib tap with double check valve for front garden

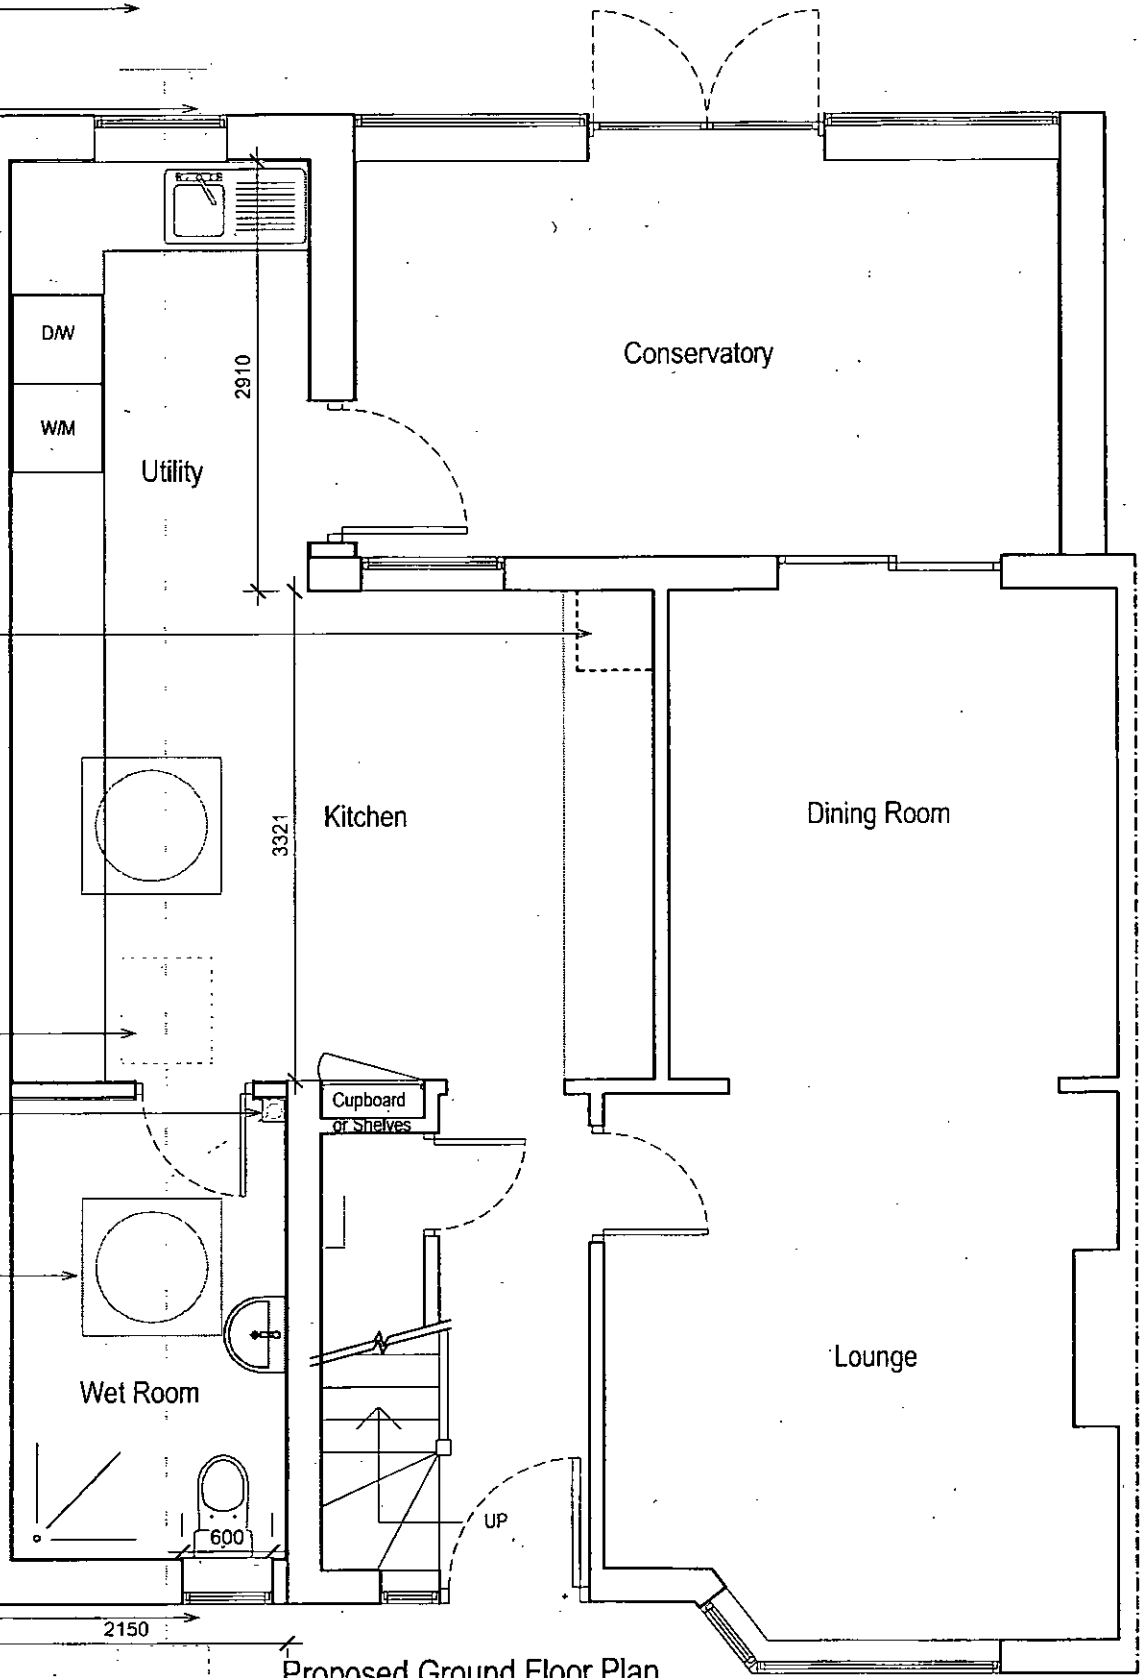

Proposed Ground Floor Plan
Scale 1/100@A3

ARUN DISTRICT COUNCIL	
No. FP 144/13	RECEIVED
SUBSTITUTION	
G.A.B.	



Technical Drawings Ltd
Drop Anchor, Drift Lane, Bosham, West Sussex, PO18 8PP
01243 572414 or 07754414693

Mr D Sawyer
11 Chesswood Avenue
Felpham
West Sussex
PO22 6AX

Proposed Ground Floor

Project Number: 11CHE-13	Drawing No: 04 REVA
Date: 4th July 2013	
Drawn By: Technical Drawings Ltd	
Checked By: JEG	Scale: 1:50