

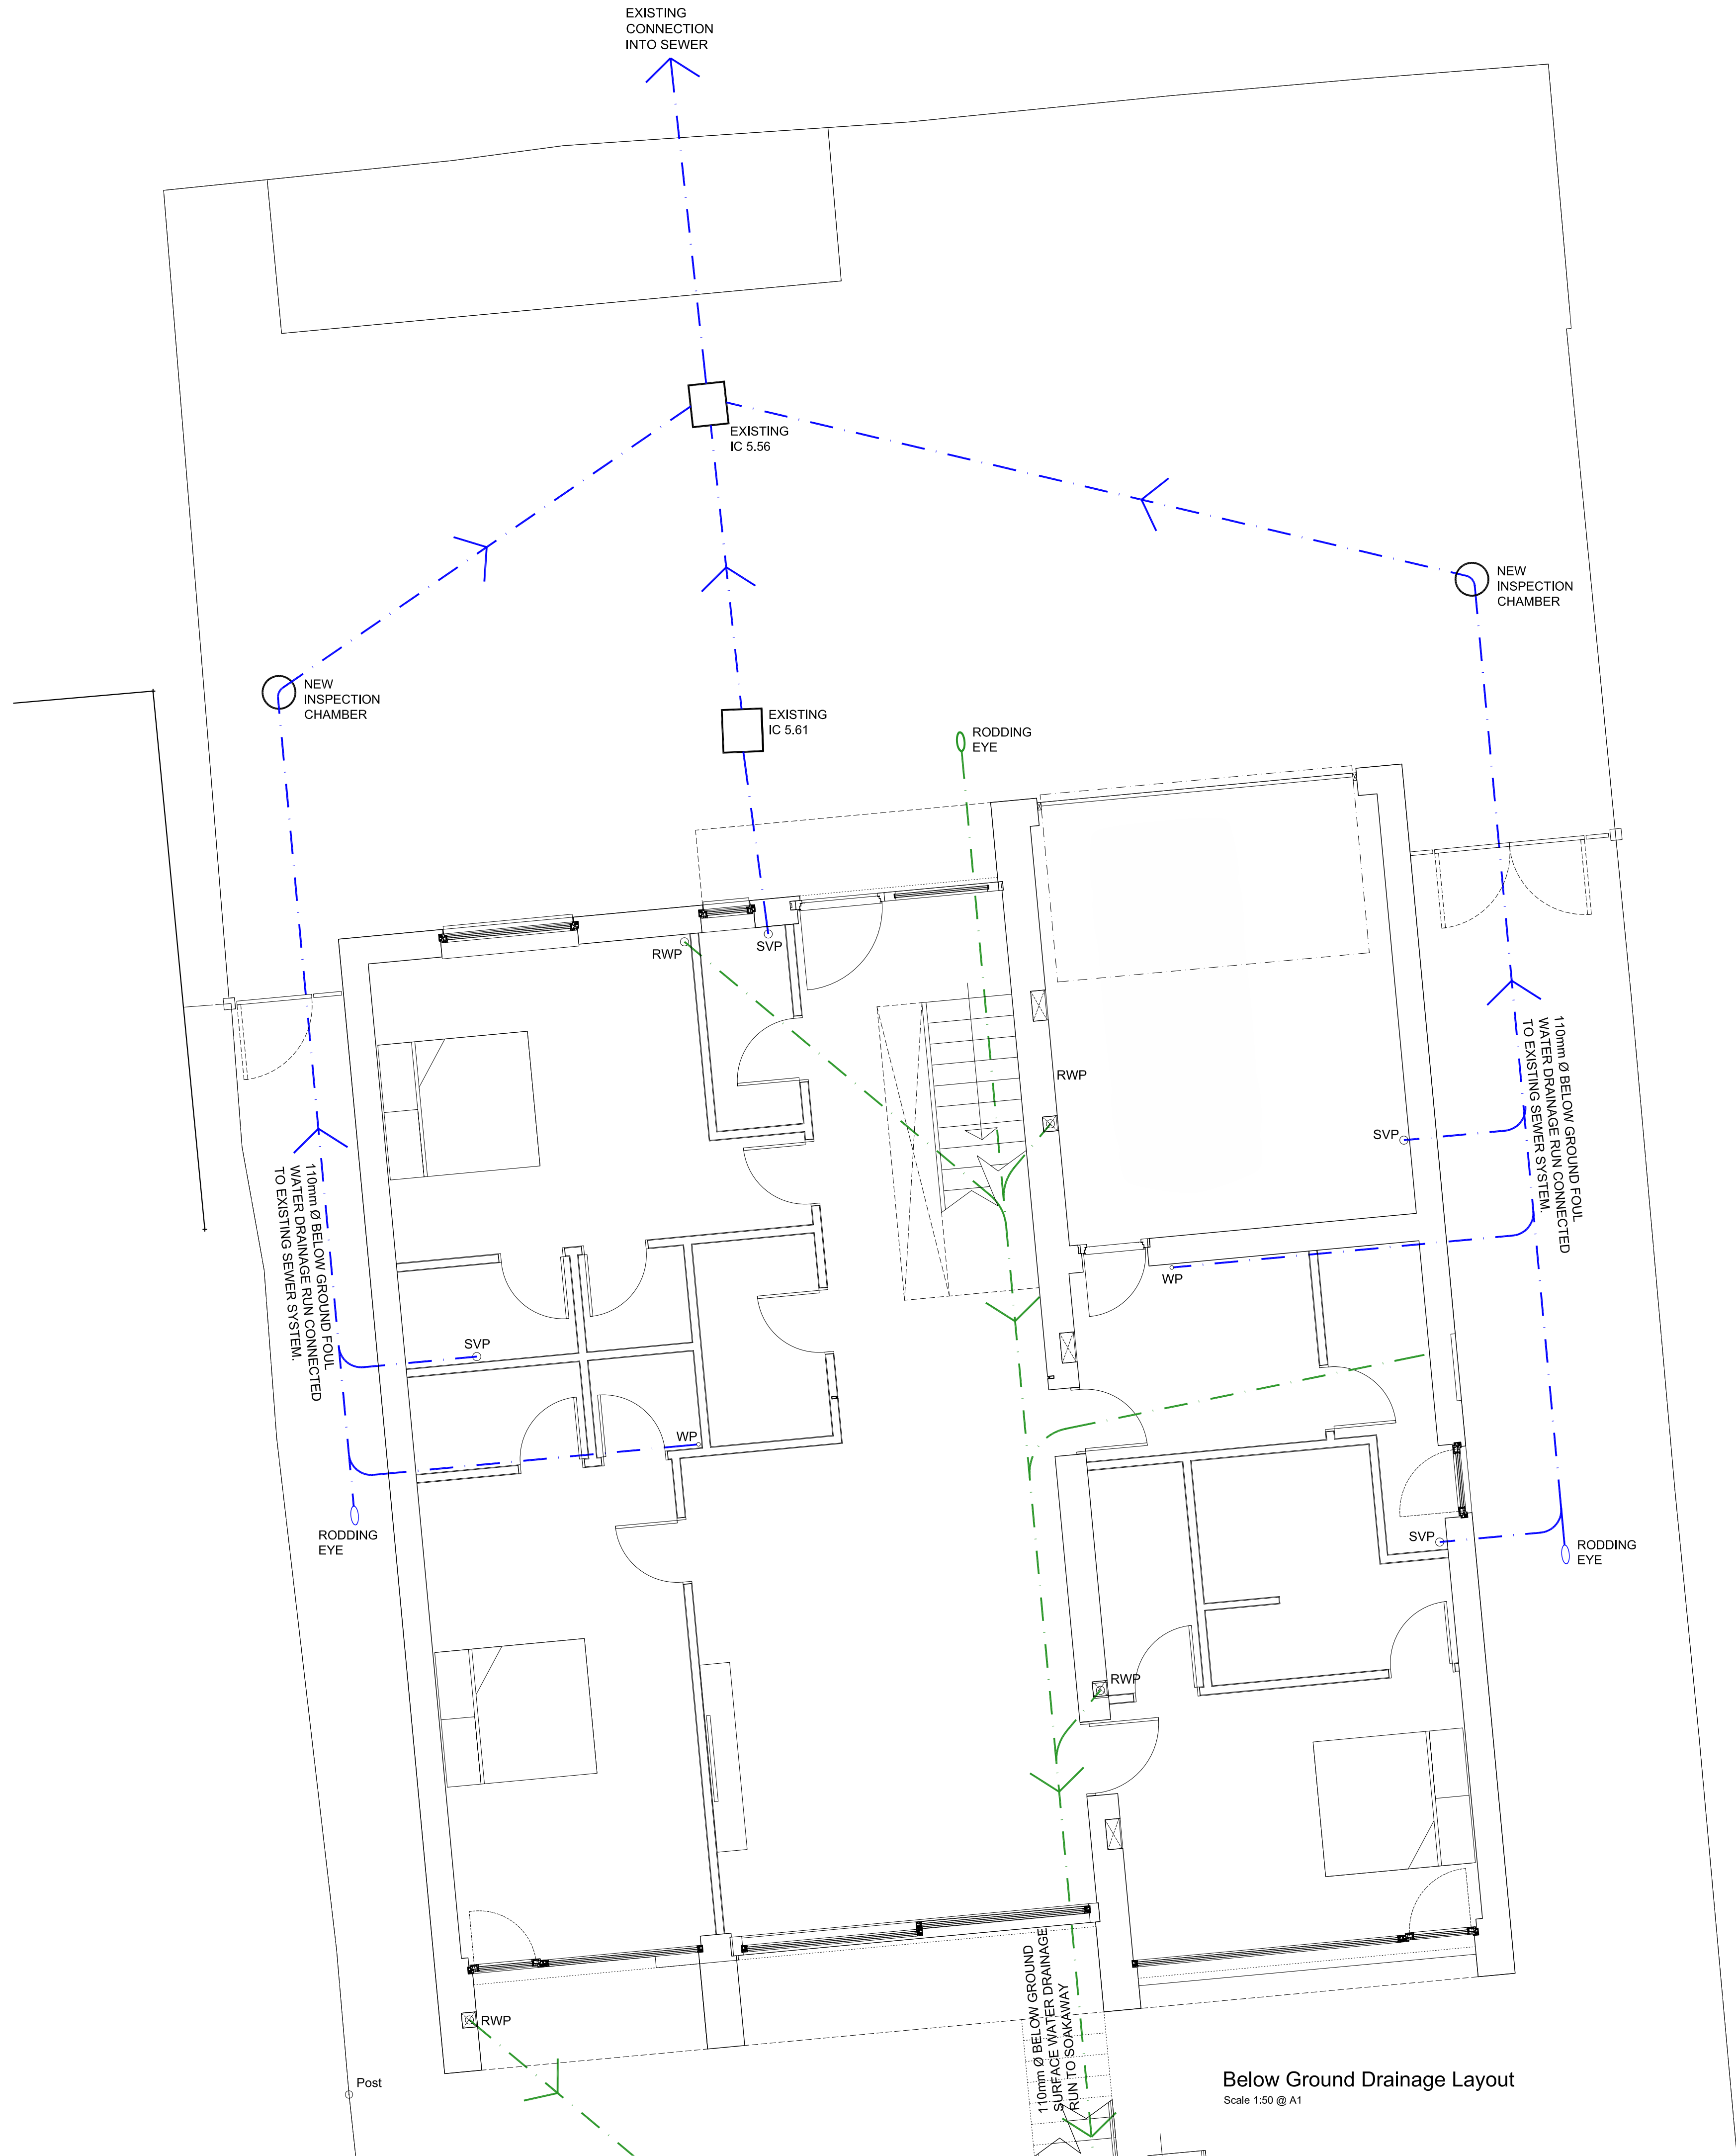


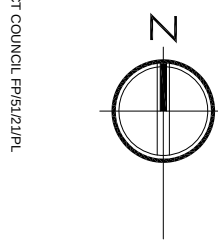


Below Ground Drainage Layout
Scale 1:50 @ A1

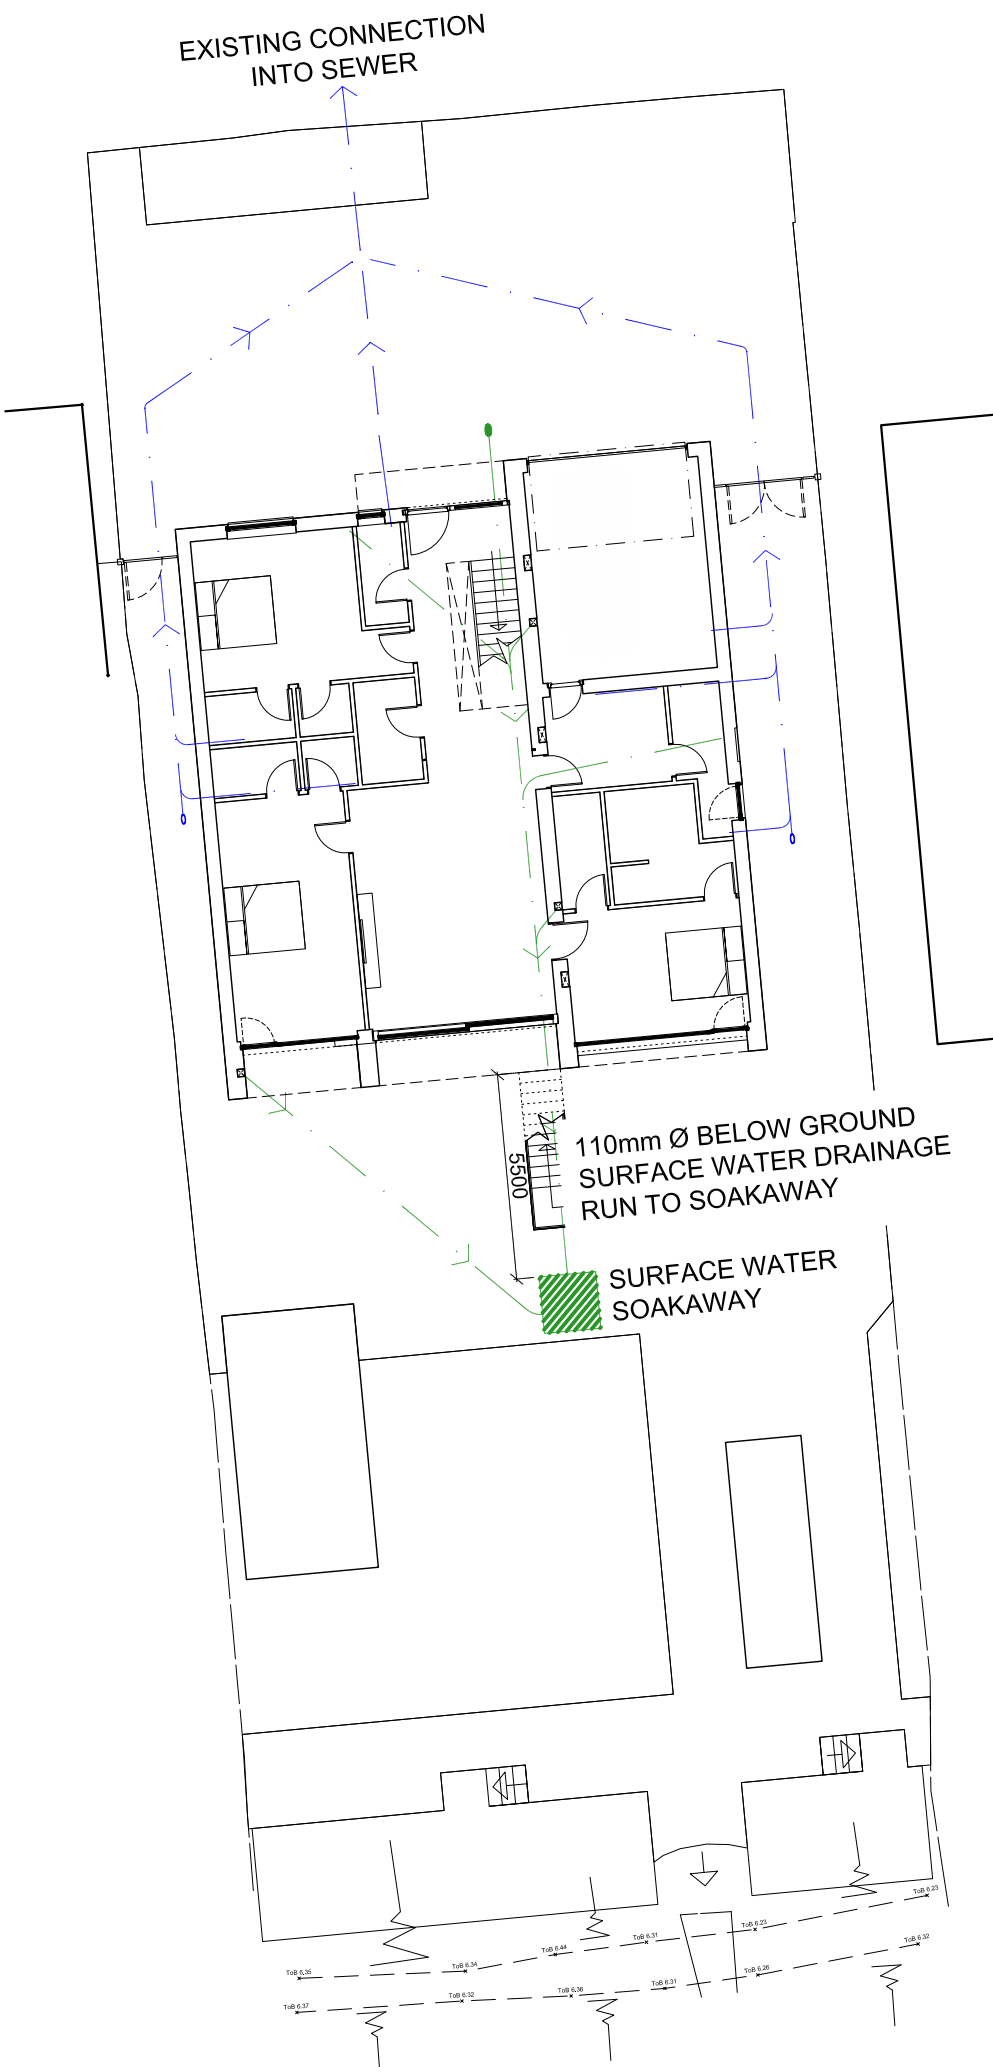

Siteplan showing Surface Water Soakaway Outlet
Scale 1:200 @ A1

SURVEY INFORMATION PROVIDED
BY LIME GREEN ASSOCIATES

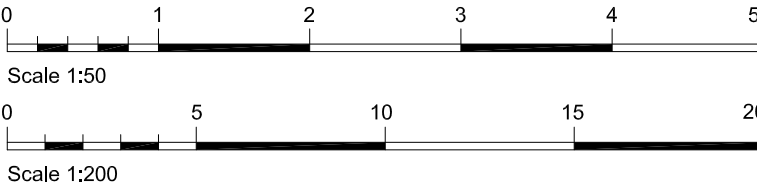

P L A N N I N G

A	Revised for Planning Re-Submission	23 June 21
revision	description	date



Project	Felpham House		
Title	Below Ground Drainage Layout		
Date	03.03.21	Drawn by	fm
Scale	1:50 @ A1	Drawing no.	7013/06
		Rev.	A

Do not Scale - check all measurements on site.
© Copyright remains with the designer