
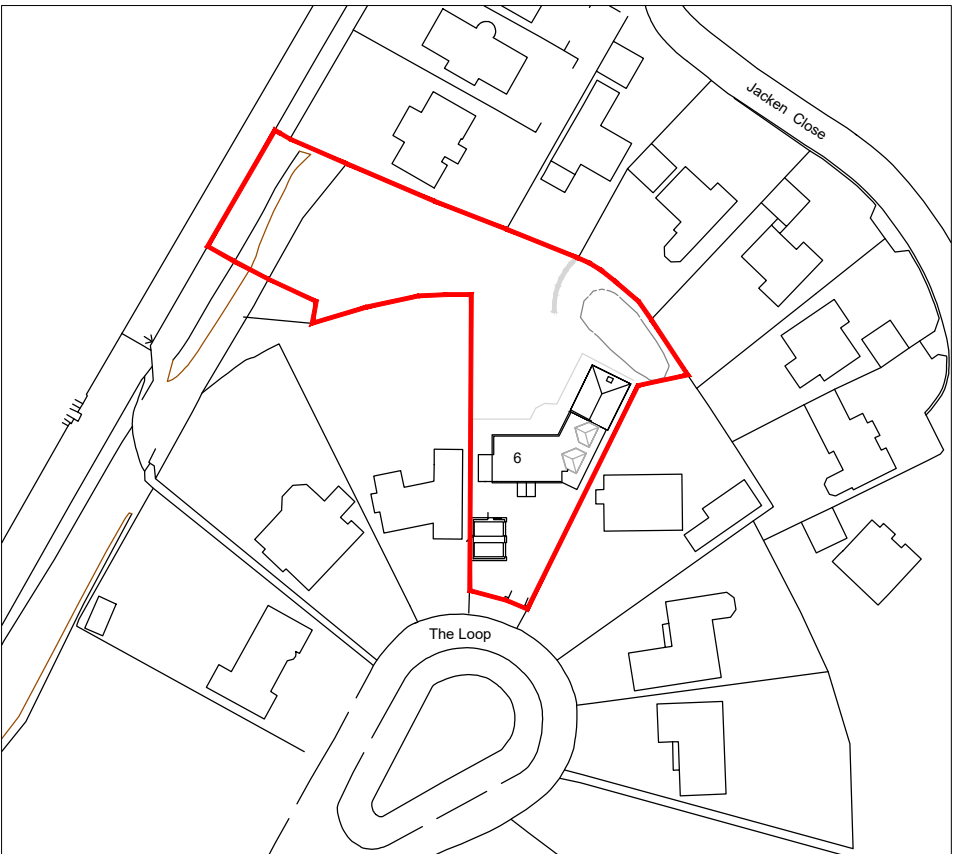


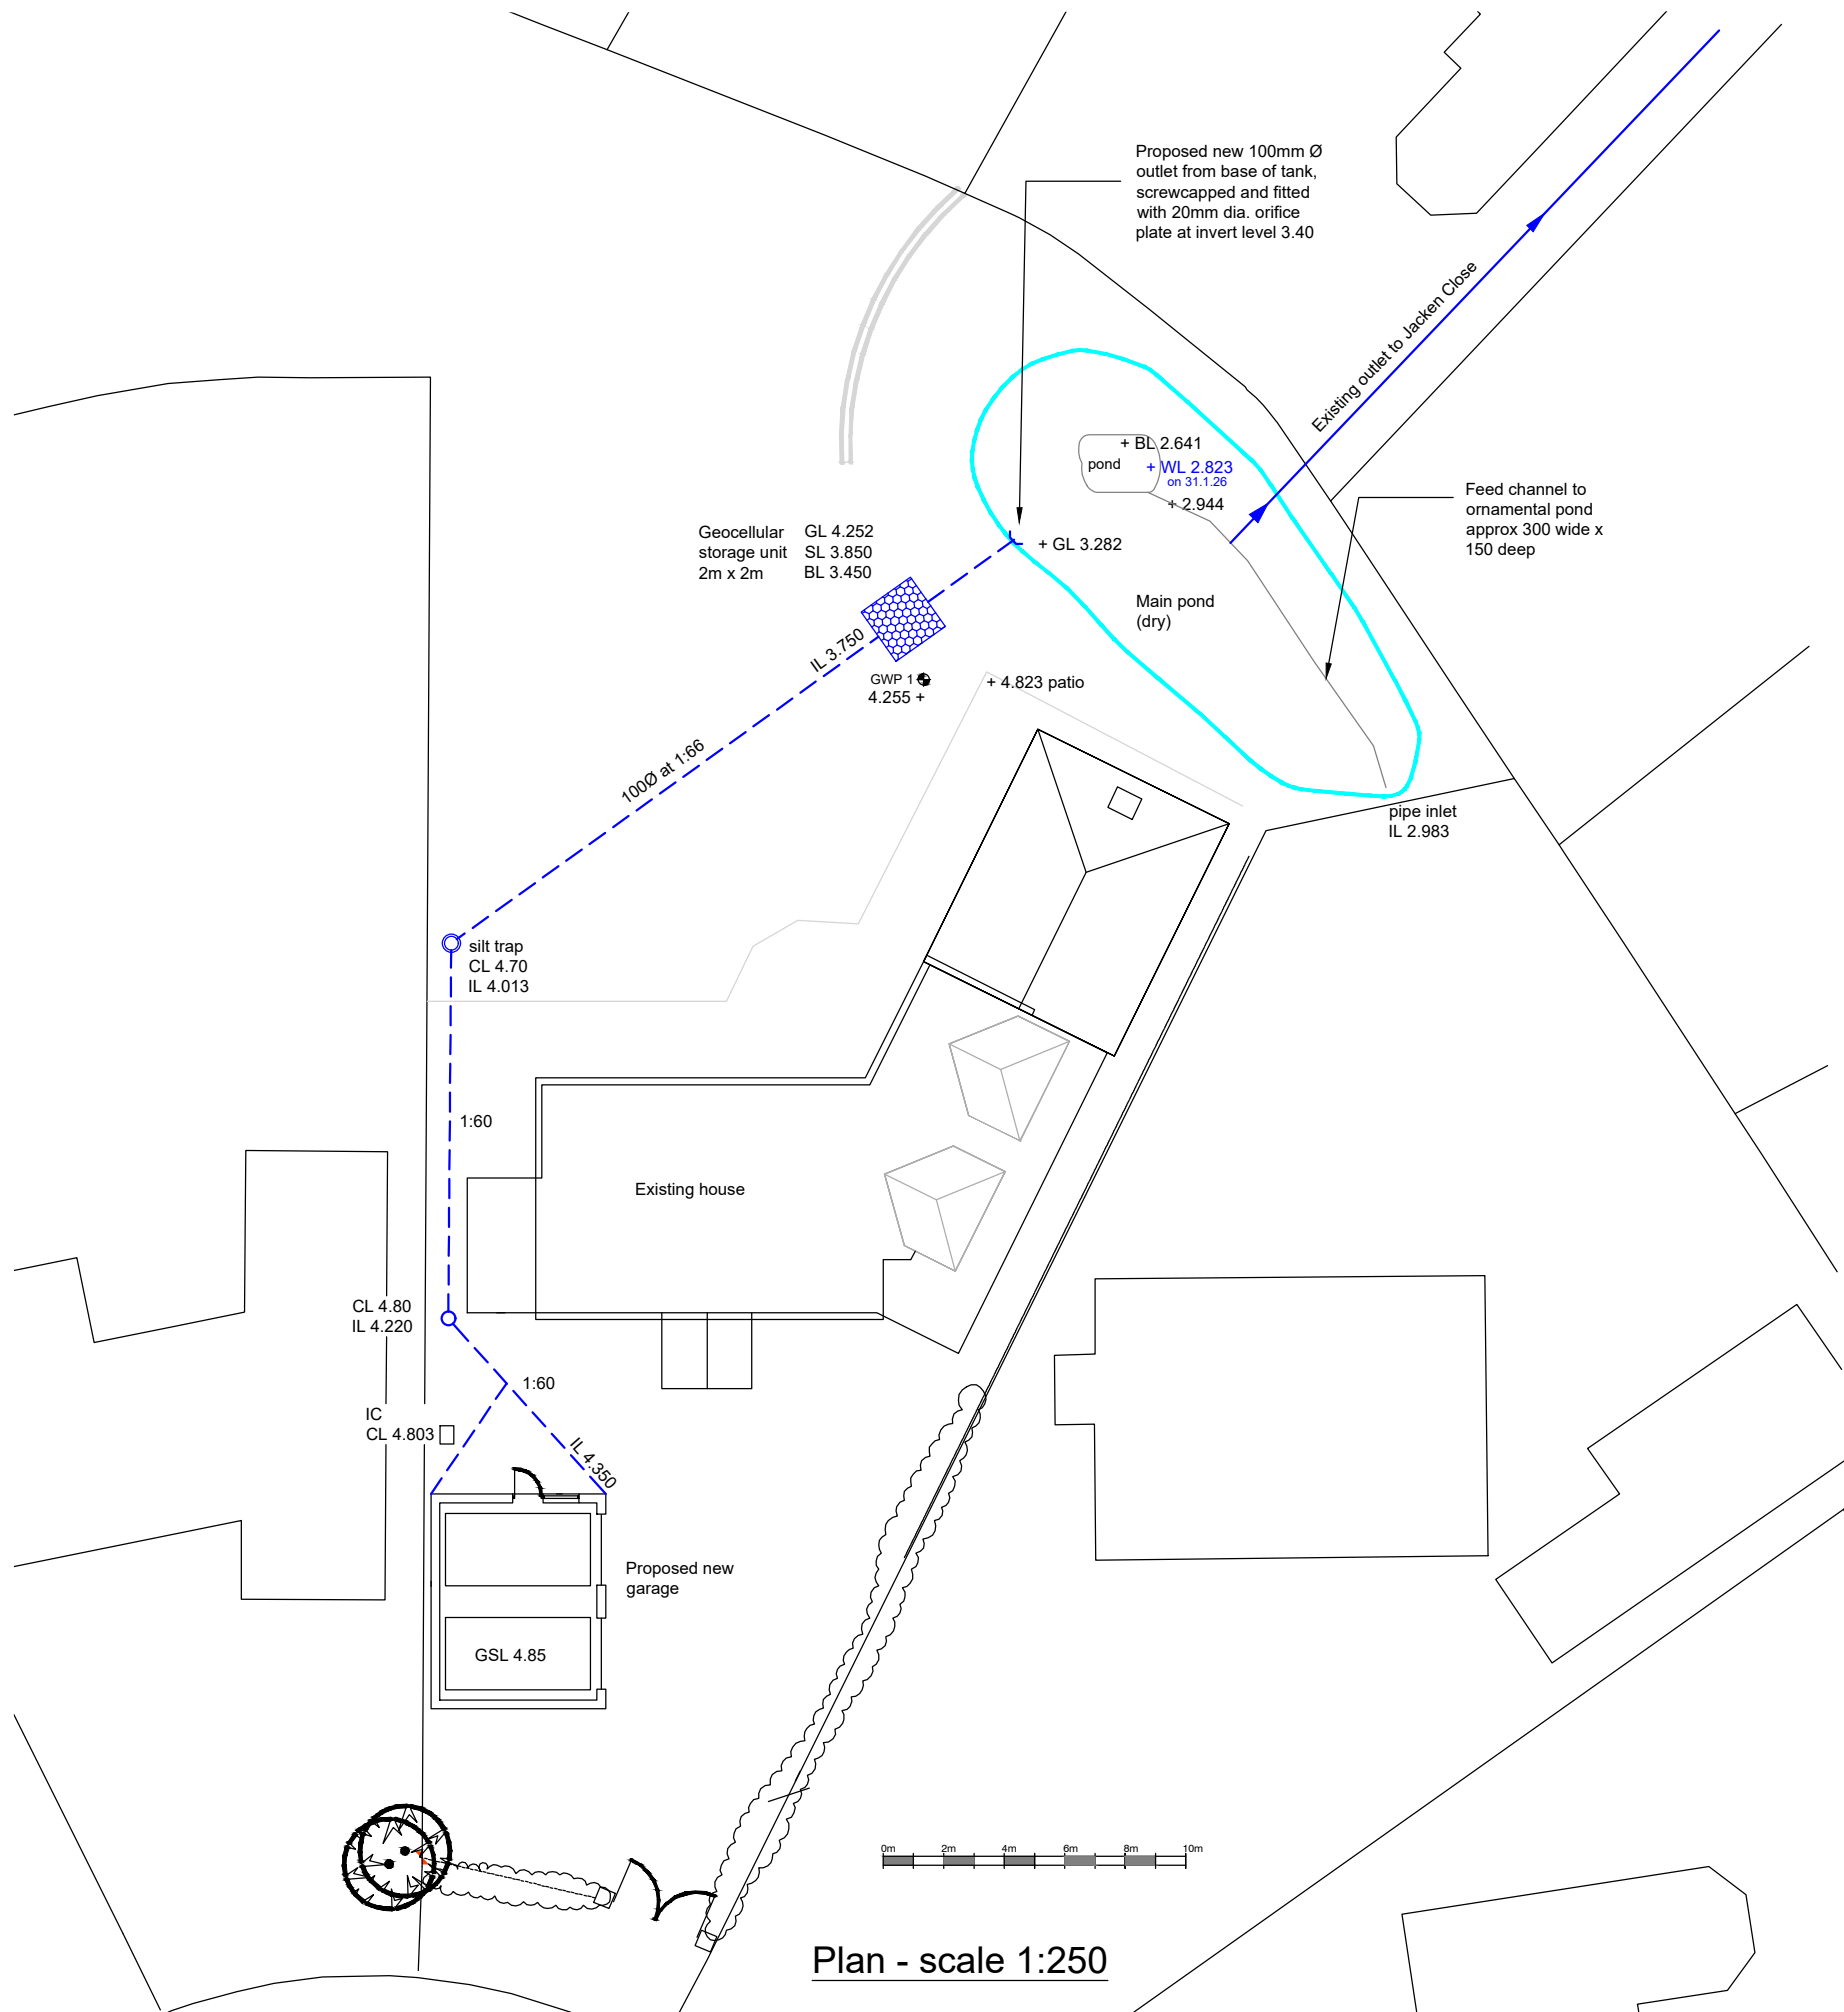

Location Plan - scale 1:1250

Key

- Proposed surface water drainage 100Ø at min1:100
- 450 dia silt trap inspection chamber with 300 sump
- Geocellular storage tank 2m x 2m comprising 1 layer of 400mm units with approx 400mm cover
- GWP 1 Groundwater monitoring borehole

-	Original	RTC	20.4.26
Rev.	Description	Dm.	Date

Project

6 The Loop
Felpham

Client

Matt Isitt

Drawing Title

SW Drainage Layout

Robert Clark
Chartered Civil Engineer
Willow Cottage, Herne Lane, Rustington
West Sussex BN16 3EE
07778 903891 Bob.Clark1485@gmail.com

© This drawing is the copyright of Robert Clark BSc CEng MICE It may not be copied or reproduced without his written authority			
Scale	As shown	At original	A3
Drawing Number	2161/D2	Revision	-