

Drawing Naming Convention:

| Job No Code Dwg type Location Ref |  |  |  |
|-----------------------------------|--|--|--|
| Code:                             |  |  |  |
| Dwg Type:                         |  |  |  |
| Location:                         |  |  |  |
| Ref                               |  |  |  |

Standard Abbreviations (where applicable):

| Building Survey |                       | Land Survey |                  |
|-----------------|-----------------------|-------------|------------------|
| AB              | AIR BRICK             | B           | BOLLARD          |
| ACU             | AIR CONDITIONING UNIT | BS          | BROCK SETTS      |
| AH              | ACCESS HATCH          | BT          | B.T. COVER       |
| AP              | ACCESS PANEL          | CAM         | CAMERA           |
| AV              | AIR VALVE             | CATV        | CABLE TV COVER   |
| BH              | BEAM HT               | CL          | COVER LEVEL      |
| BR              | BOILER                | EL          | ELECTRIC COVER   |
| BSL             | BEAM SOFFIT LEVEL     | EP          | ELECTRIC POLE    |
| CB              | CUPBOARD              | ER          | EARTH ROD        |
| CC              | CEILING CHANGE        | FB          | FLOWERBED        |
| CH              | CLEAR INTERNAL HT     | FH          | FIRE HYDRANT     |
| C-A             | CILL TO APEX HT       | FW          | FOUL WATER       |
| C-H             | CILL TO HEAD HT       | GU          | GULLY            |
| C-S             | CILL TO SPRING HT     | GV          | GAS VALVE        |
| DB              | DOOR BASE HT          | IC          | INSPECTION COVER |
| DH              | DOOR HEAD HT          | IL          | INVERT LEVEL     |
| FA              | FIRE ALARM            | LP          | LAMP POST        |
| FAB             | FIRE ALARM BELL       | MH          | MANHOLE          |
| FX              | FIRE EXTINGUISHER     | OHT         | OVERHEAD TELECOM |
| F-A             | FLOOR TO APEX HT      | P           | POST             |
| F-C             | FLOOR TO CILL HT      | PM          | PARKING METER    |
| F-H             | FLOOR TO HEAD HT      | PI          | PIPE             |
| F-S             | FLOOR TO SPRING HT    | RO          | RODDING EYE      |
| GEA             | GROSS EXTERNAL AREA   | RS          | ROAD SIGN        |
| GIA             | GROSS INTERNAL AREA   | RTW         | RETAINING WALL   |
| GU              | GULLY                 | RWP         | RAIN WATER PIPE  |
| HT              | HEATER                | SA          | SITE AREA        |
| HW              | HOT WATER TANK        | SI          | SIGN             |
| IA              | NET INTERNAL AREA     | STU         | TREE STUMP       |
| NTS             | NOT TO SCALE          | SV          | STOP VALVE       |
| RAD             | RADIATOR              | SVP         | SOIL VENT PIPE   |
| RE              | RECESS HEAD HEIGHT    | SW          | STORM WATER      |
| RFV             | RAISED FLOOR VOID     | TOF         | TOP OF FENCE     |
| RL              | ROOF LIGHT            | TOW         | TOP OF WALL      |
| RSH             | ROLLER SHUTTER        | TP          | TELEGRAPH POLE   |
| RWP             | RAIN WATER PIPE       | UTL         | UNABLE TO LIFT   |
| SFO             | SPOT LIGHT            | VP          | VENT PIPE        |
| SVP             | SOIL VENT PIPE        | WM          | WATER METER      |
| V               | VENT                  | WT          | WATER TAP        |

Symbols (where applicable):

|                                |                                   |                                     |
|--------------------------------|-----------------------------------|-------------------------------------|
|                                |                                   |                                     |
| Direction of sloping ceiling   | PLUG SOCKET<br>2 = NO. OF SOCKETS | LIGHT SWITCH<br>1 = NO. OF SWITCHES |
|                                |                                   |                                     |
| FLOOR TO STRUCTURAL CEILING HT | FLOOR TO SUSPENDED CEILING HT     | FLOOR LEVEL RELATIVE TO DATUM       |

Notes:

The Survey relates to OS GPS 'Active Network'.


All direction arrows indicate UP unless otherwise stated.

Drainage pipe sizes (where shown) have been gauged from the surface (for safety reasons) and should be regarded as approximate only.


Visible features in the vicinity of any boundaries, as shown on this survey, may not represent the extent of legally conveyed ownership.

Whilst every effort has been made to determine wall materials, no guarantee is given. Materials should be regarded as assumed unless verified by a qualified third party.


Tree spread and height are approximate. Species should be regarded as assumed unless verified by a qualified third party.

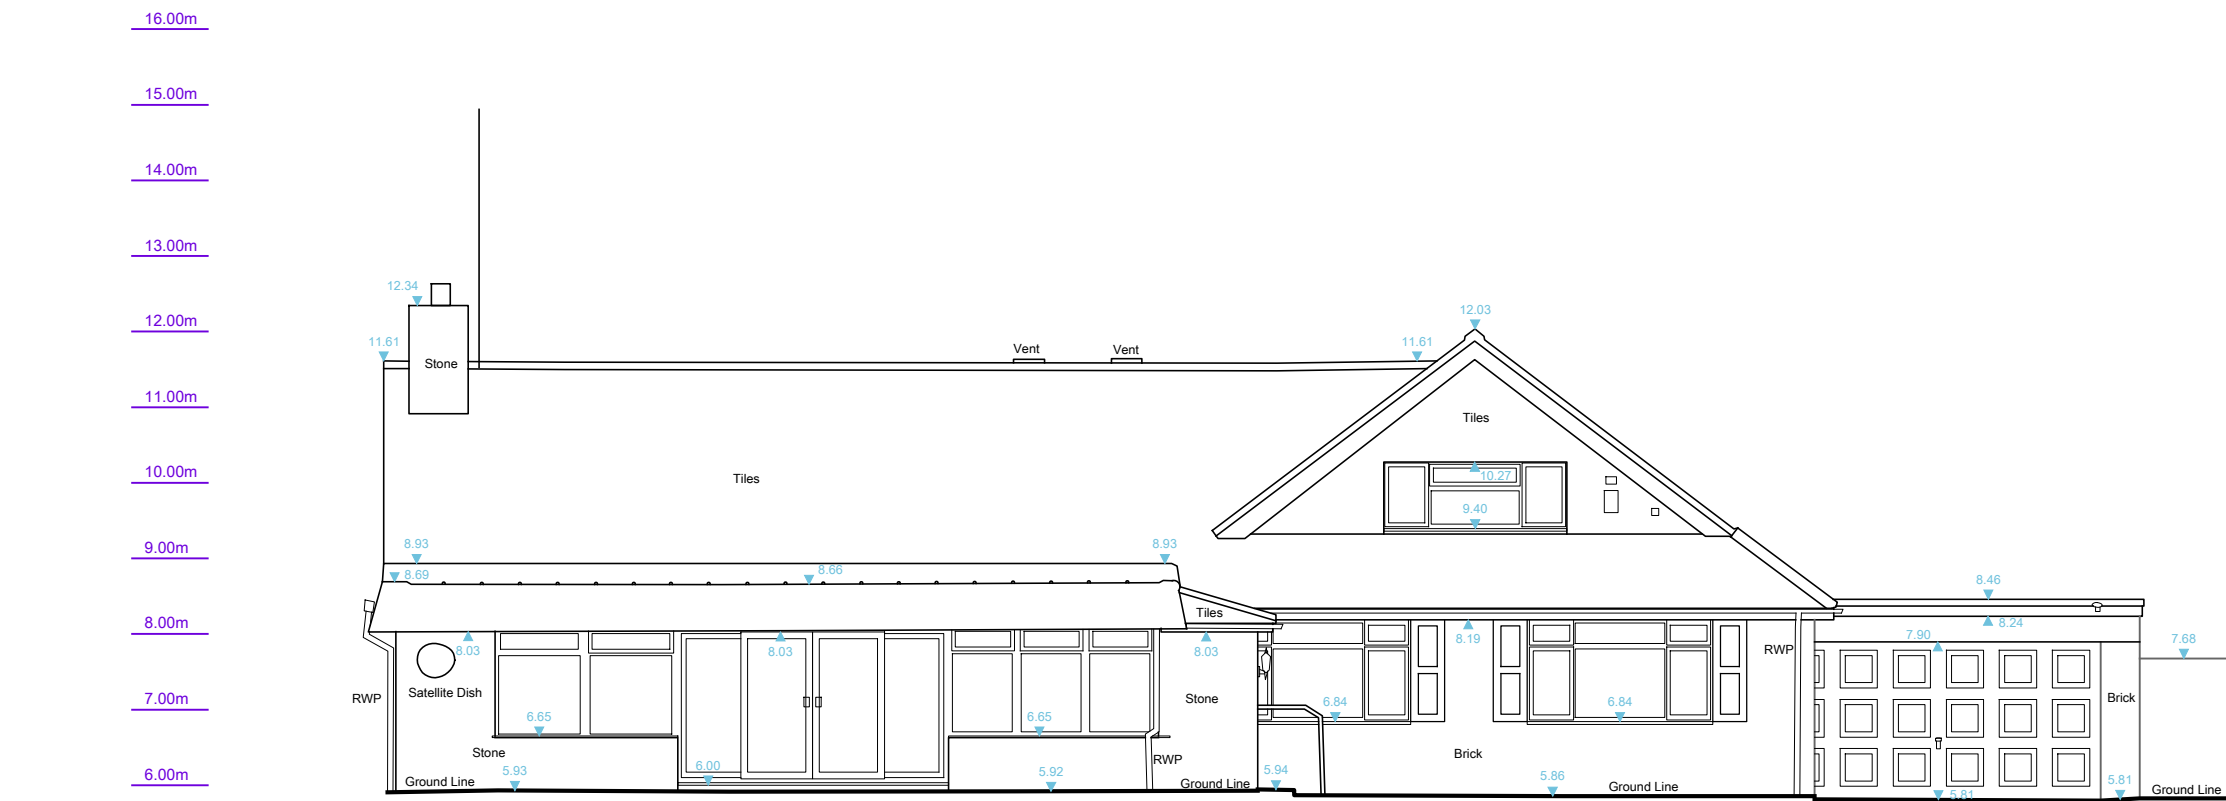


EXISTING SOUTH ELEVATION

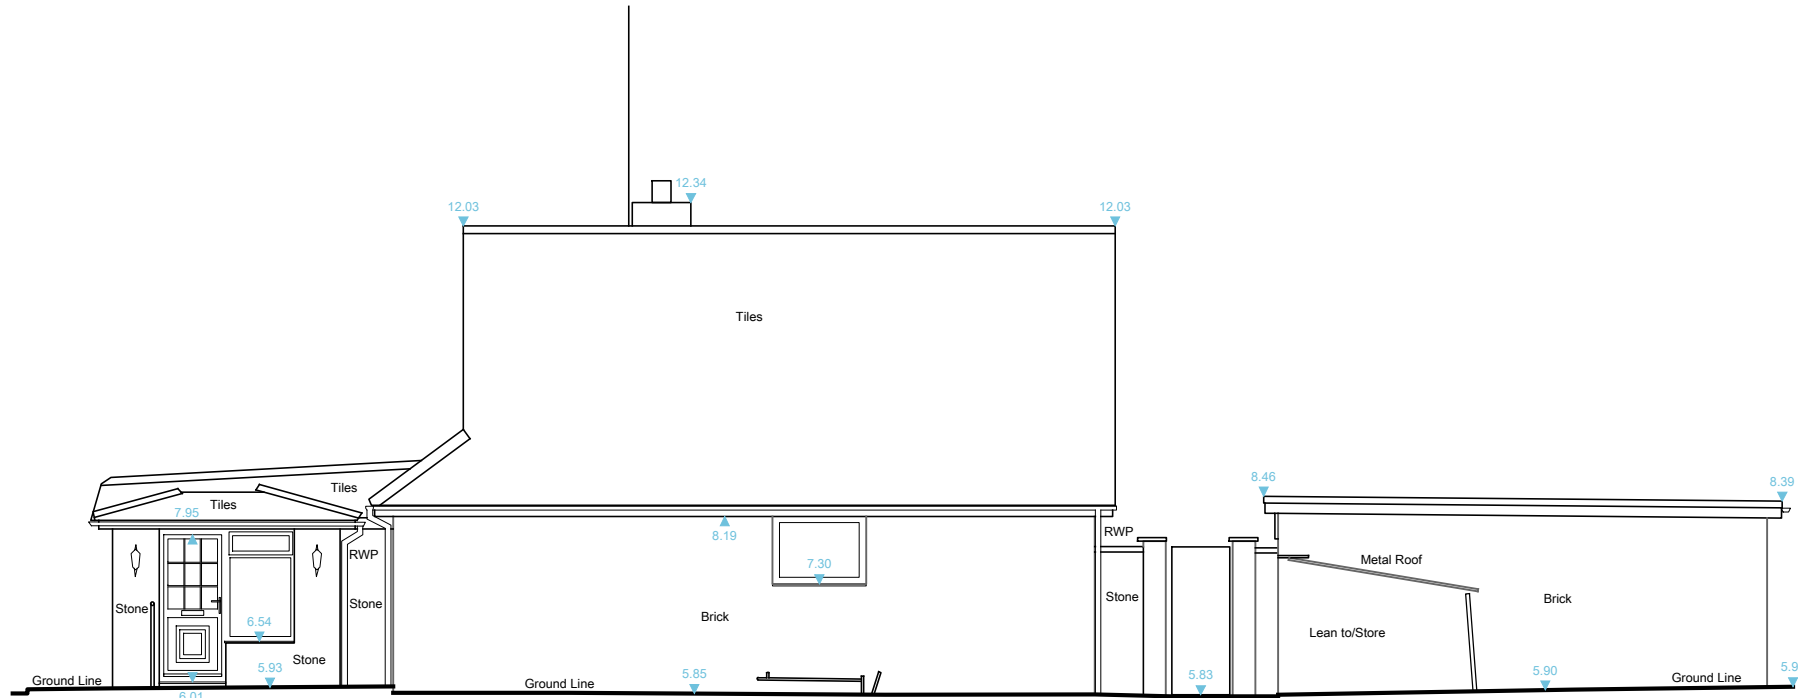

EXISTING EAST ELEVATION

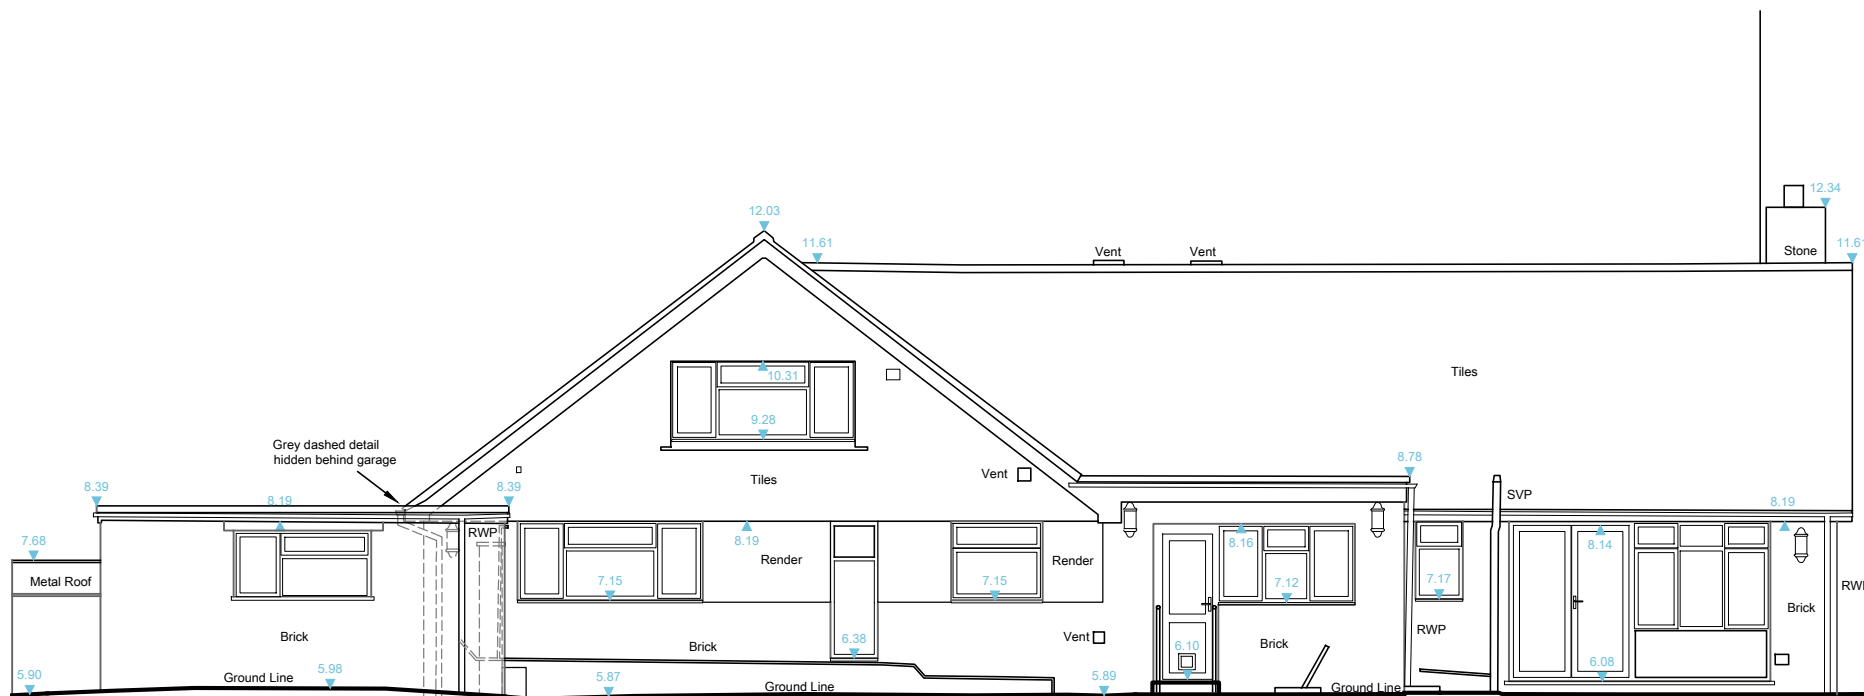

EXISTING NORTH ELEVATION

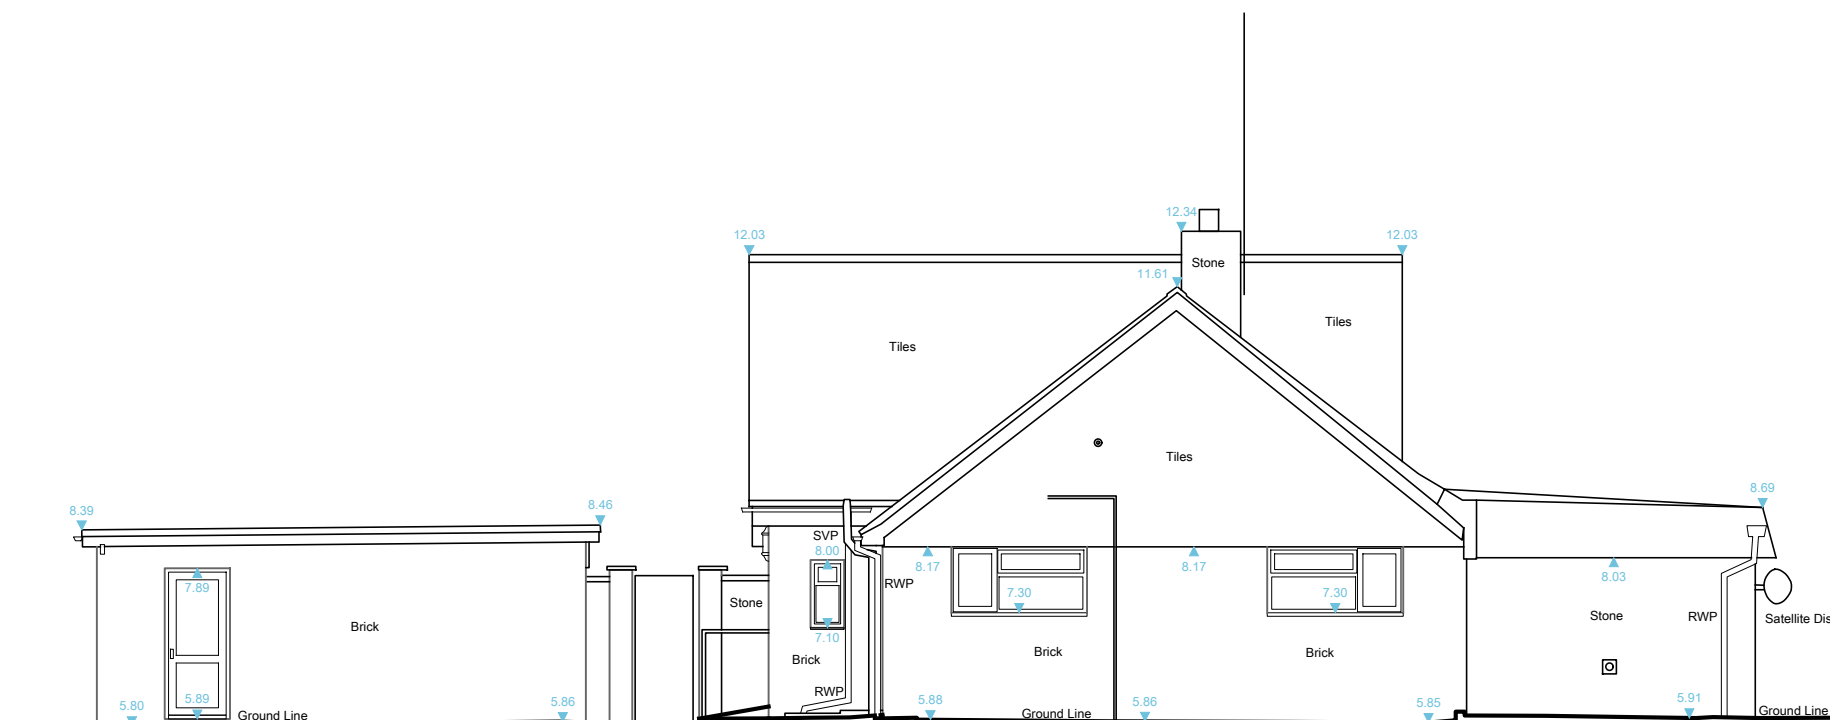

EXISTING WEST ELEVATION

|  |  |  |  |
|--|--|--|--|
|  |  |  |  |
|  |  |  |  |
|  |  |  |  |
|  |  |  |  |
|  |  |  |  |

| Rev | Date | By | Description |
|-----|------|----|-------------|
|-----|------|----|-------------|

**HB Surveys Ltd**  
Land & Measured Building Surveyors

Spring House, 60 Poplar Way, Midhurst, West Sussex GU29 9TA  
t. 01730 814884 info@hbsurveys.com

Client: FRED BACON

Project: LITTLE TANGLEY  
MIDDLE WAY  
KINGSTON GORSE

Drawing Title:

EXISTING  
ELEVATIONS

|         |               |           |        |          |
|---------|---------------|-----------|--------|----------|
| Date:   | Scale:        | Surveyor: | Drawn: | Checked: |
| JULY 18 | 1:100@A1      | CGL       | CGL    | HB       |
| Job No: | Drawing No:   | Sheet No: | Rev:   |          |
| 18084   | 18084-02-E-GA | 4 of 4    |        |          |