





Drainage information provided by Archibald Shaw

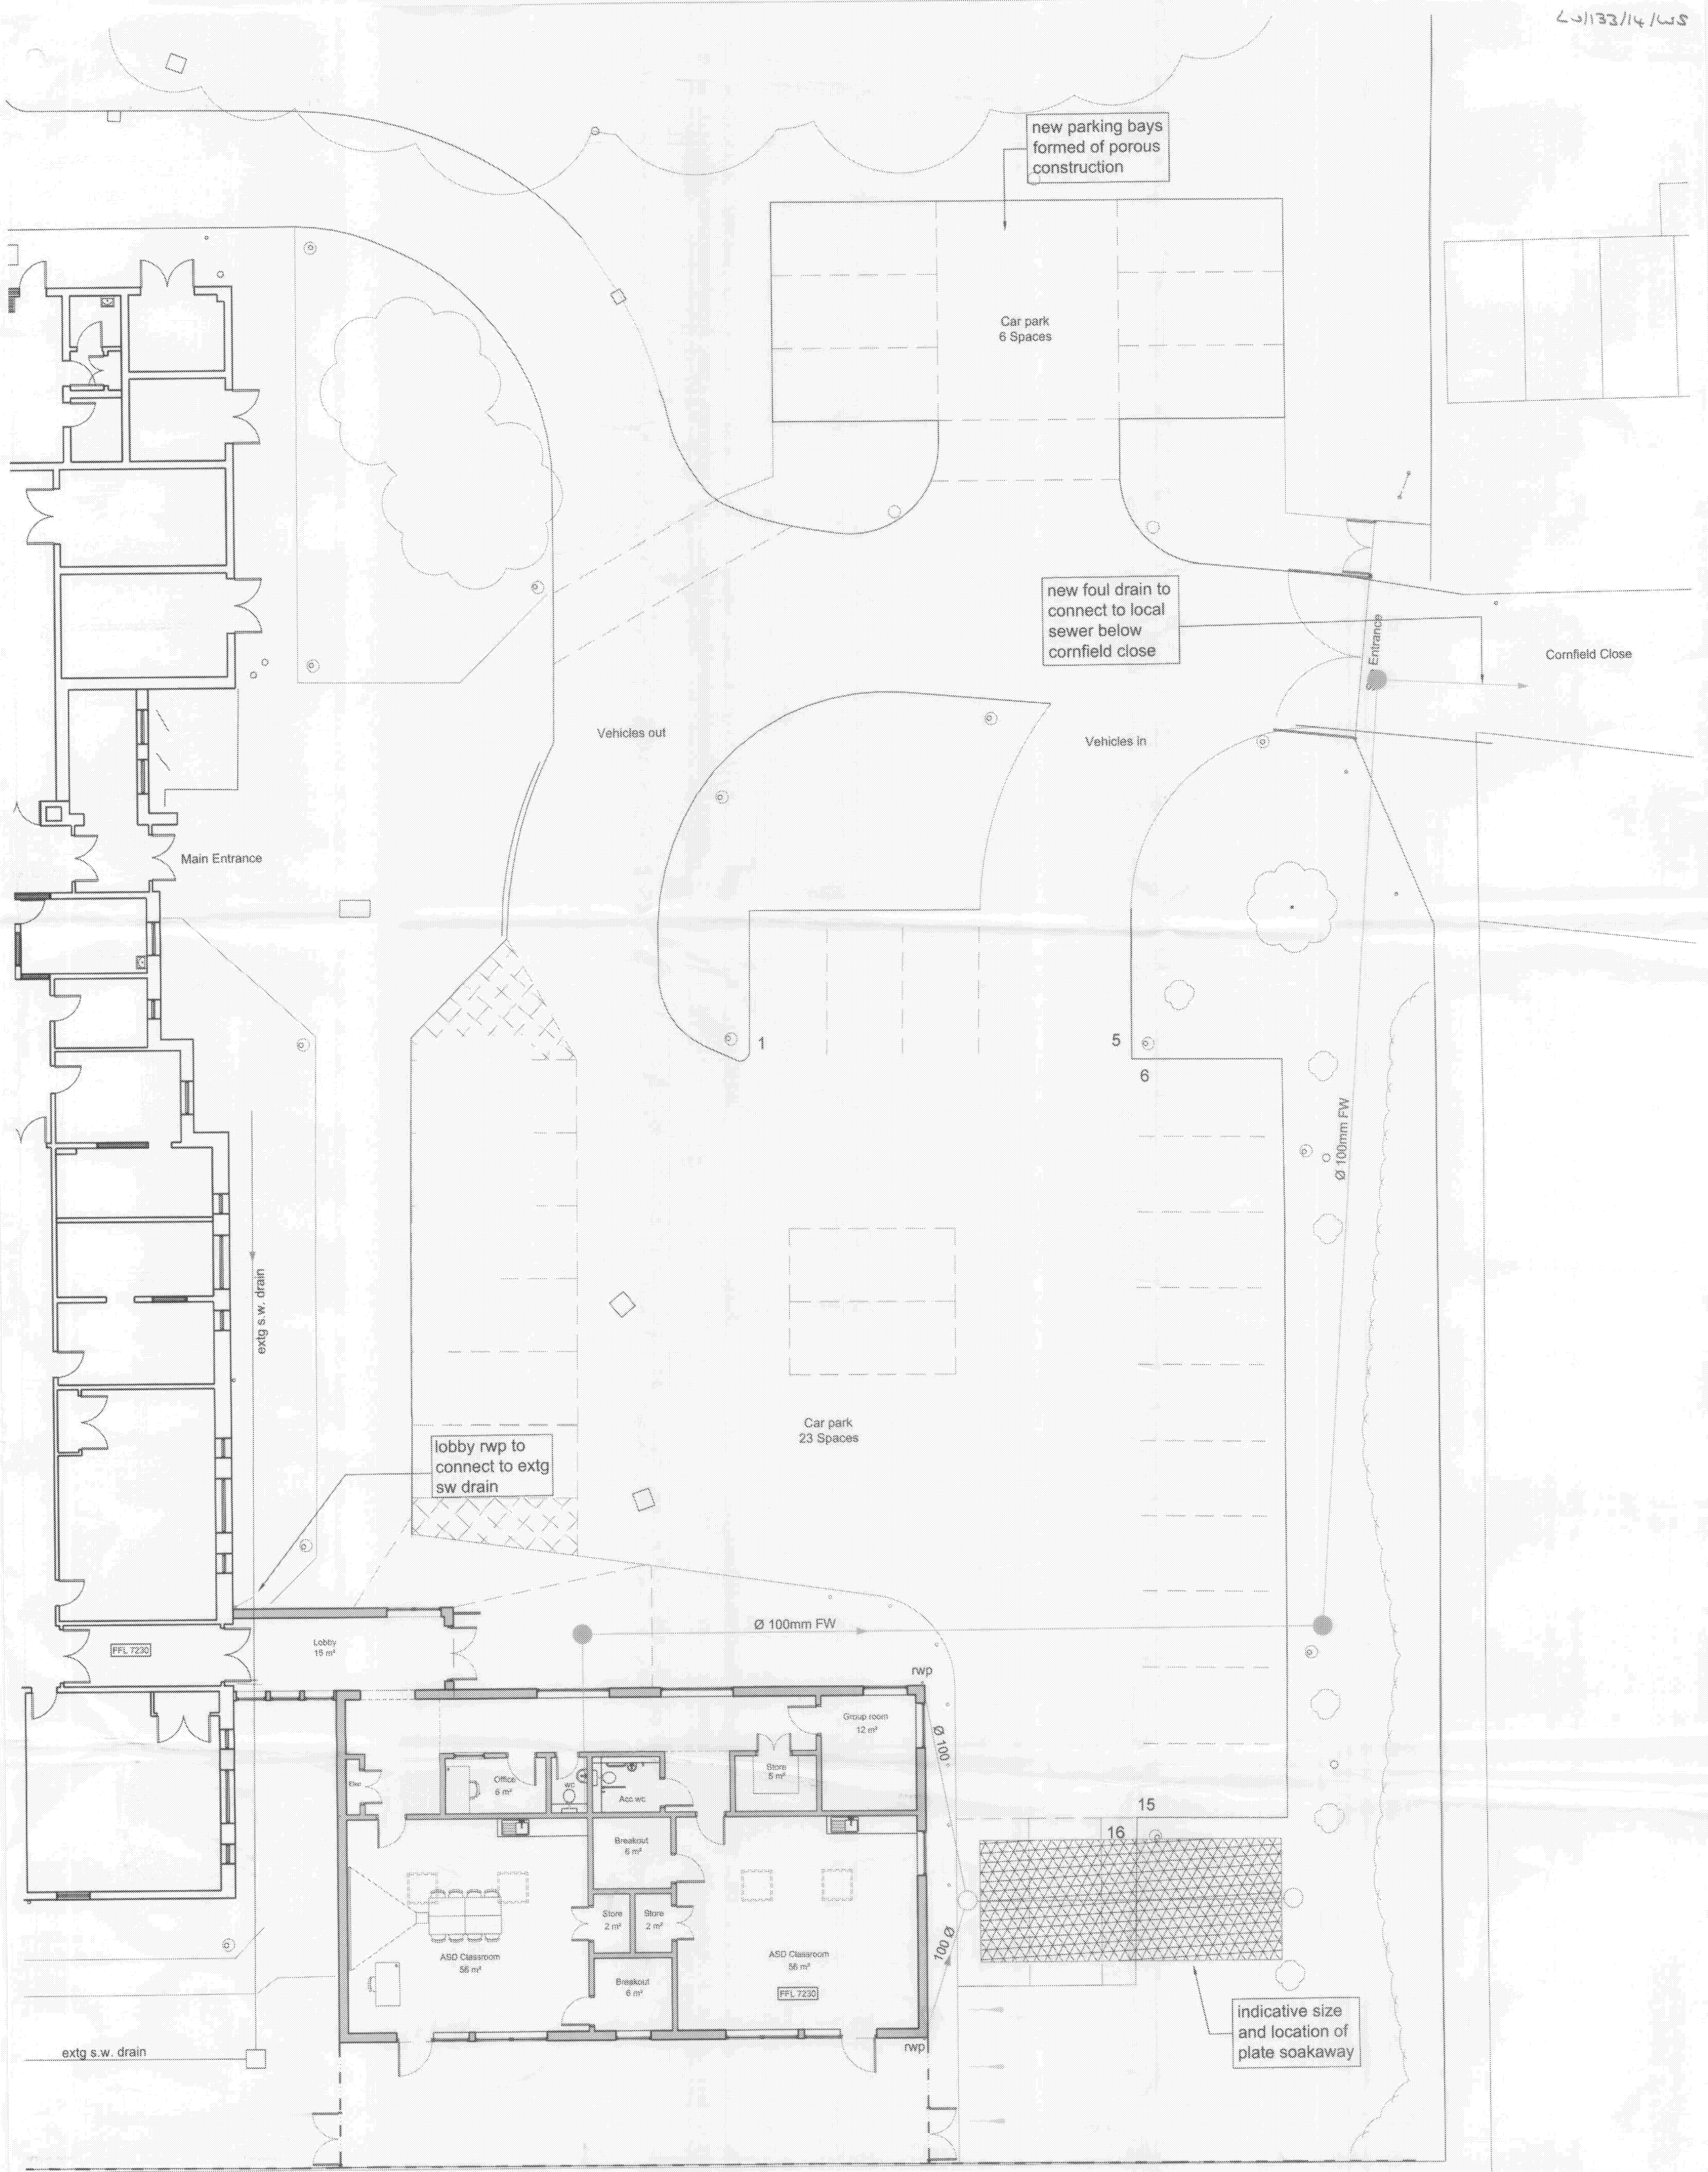

Drawing Proposed Floor Plan Project Cornfield School, Littlehampton Kier Construction	Date March 14 Scale 1:100
1688 114	Approval

PLEASE NOTE
FOR CONSTRUCTION PURPOSES USE ONLY FIGURED
DIMENSIONS. THIS DRAWING MUST ALWAYS BE READ
IN
CONJUNCTION WITH ALL RELEVANT PROJECT DETAILS.
ALL DIMENSIONS MUST BE CHECKED ON SITE PRIOR TO
COMMENCEMENT. PLEASE REPORT ANY DISCREPANCY
TO THE ARCHITECT OR CONTRACT ADMINISTRATOR

Revisions

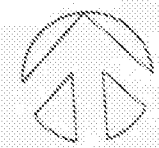

HMV

HazelMcConnachyYoung LLP/Chartered Architects/
3 Turnagain Lane/ Palace Street/ Canterbury/
Kent/ CT1 2ED/ T: 01227 454497/ F: 01227 451372