


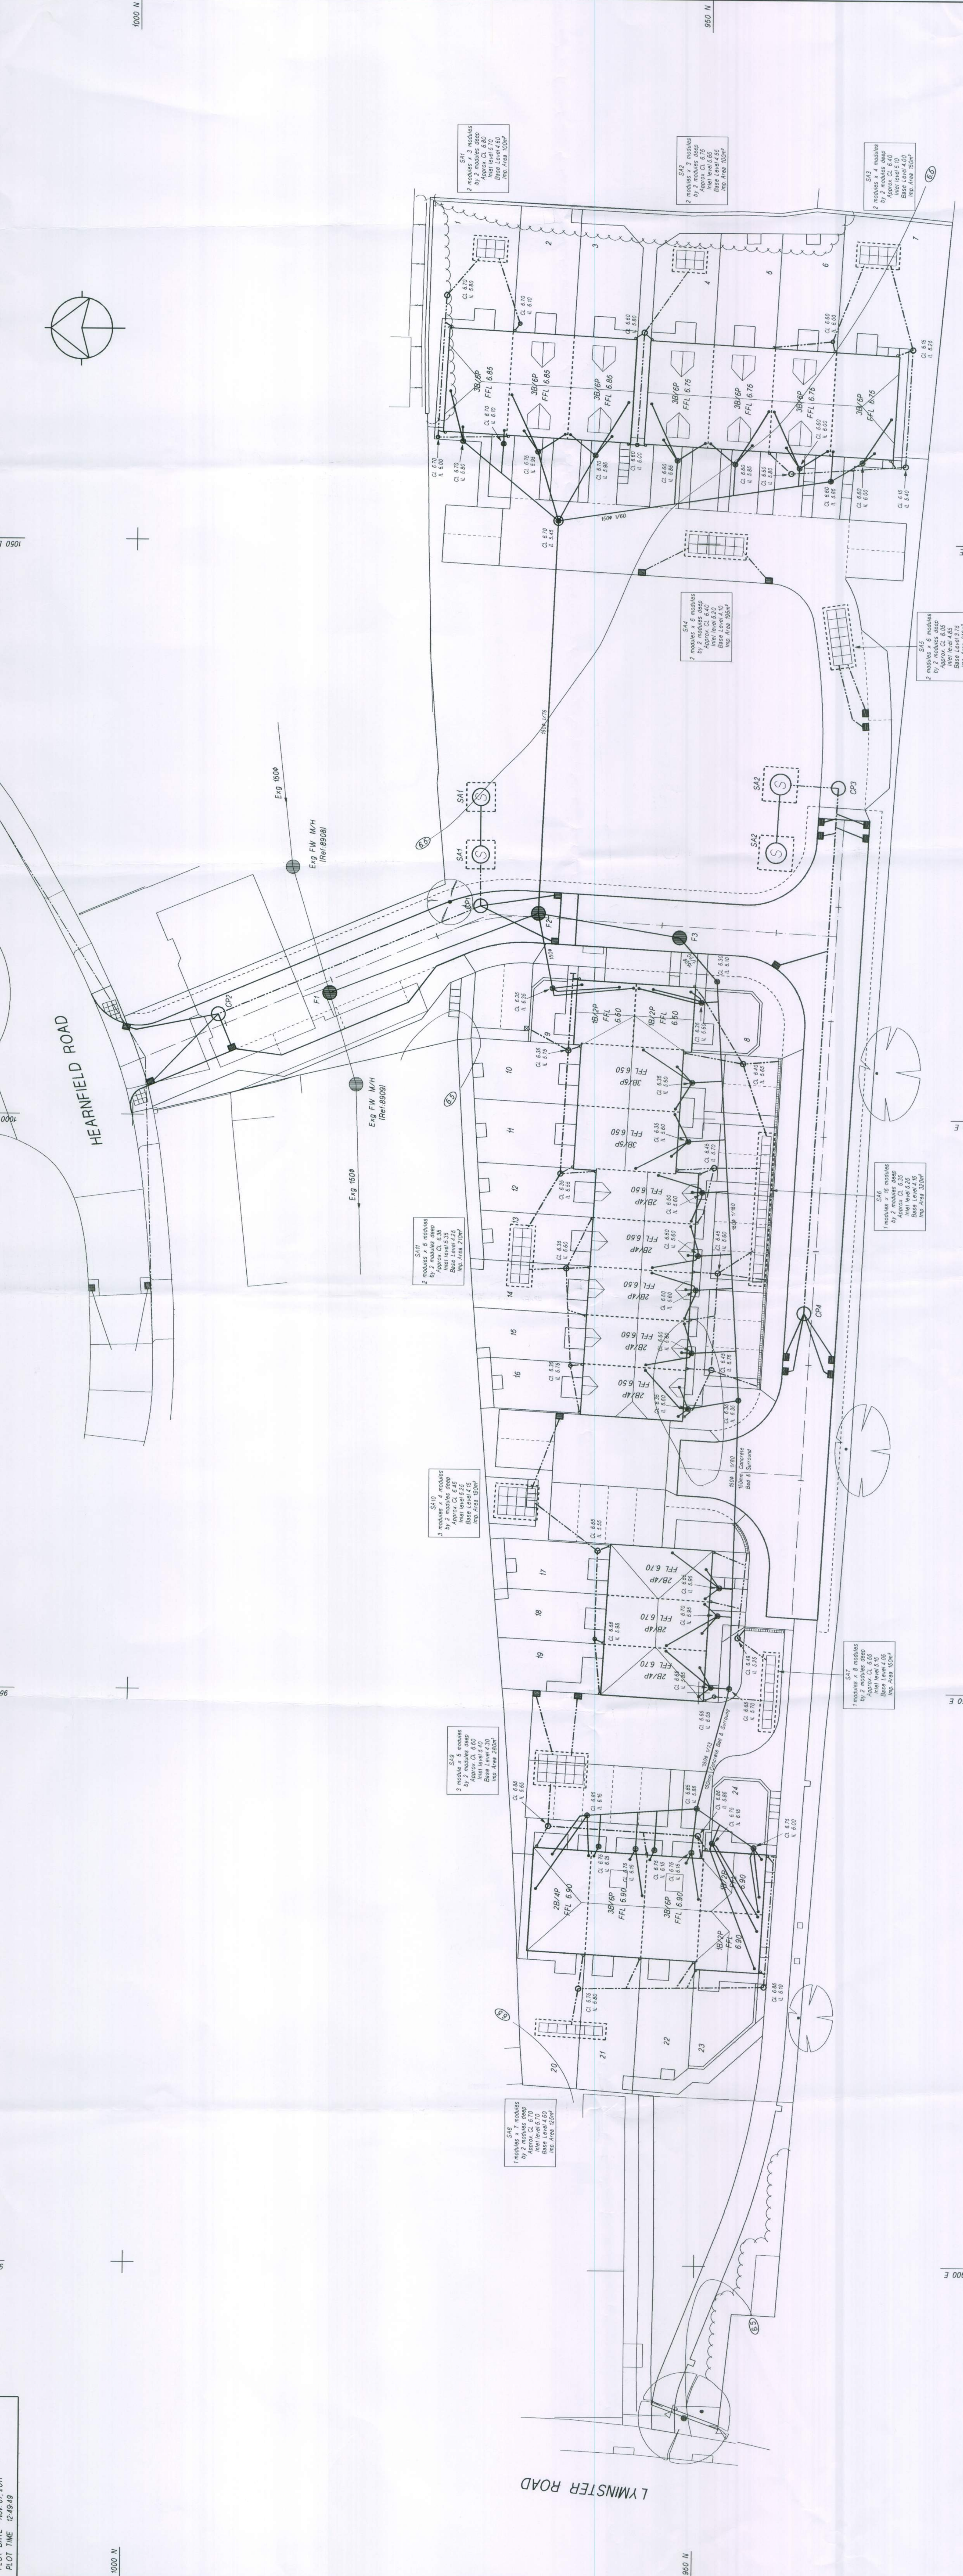

M/H	Agave- GL	I.L.	Type	Dia. (mm)	Remarks
F1	6.34	4.64	B	1200	On line of existing sewer
F2	6.42	4.90	G	1240 x 876	
F3	6.30	5.00	C	1240 x 676	

HIGHWAY CATCHIT SCHEDULE						
M/H	Approx. $\frac{1}{2}$ L.	Water L.	Type	Size (mm)	Depth Insulating Temp	Remarks
CPI	6.44	4.00		1200	3.04	
CPI	6.56	4.20		1200	2.66	
CPI	6.10	4.40		1200	2.30	
CPI	6.20	4.80		1200	2.00	
				REFER TO DRG No. 210384/13		


S/A No	Approx. C/G	Trk	Type	Dia (mm)	Depth	Remarks
S#1	6.60	3.95	3.00	1900	3.60	Linked members
S#4	6.60	-	3.00	1900	3.60	
S#2	6.30	-	2.00	1900	4.30	Linked members
S#3	6.30	4.35	2.00	1900	4.30	

NOTES

- | | | |
|---|--|--|
| 1 | Alternative drainage system to be in accordance with the Water Authorizing Association Scheme for Adoption Plans, 11 th EDITION | |
| 2 | All accessible highway works to be in accordance with West Sussex County Council Detailed Specification for the Construction of 'Water Resilient' Roads for Guidance and Standard Drainage Details | |
| 3 | Provide drainage connections to proposed adjacent sewerage or existing public sewers in the following:
a) RCD-1000
b) RCD-1500
c) RCD-2000
d) RCD-2500
e) RCD-3000
f) RCD-3500
g) RCD-4000
h) RCD-4500
i) RCD-5000
j) RCD-5500
k) RCD-6000
l) RCD-6500
m) RCD-7000
n) RCD-7500
o) RCD-8000
p) RCD-8500
q) RCD-9000
r) RCD-9500
s) RCD-10000
t) RCD-10500
u) RCD-11000
v) RCD-11500
w) RCD-12000
x) RCD-12500
y) RCD-13000
z) RCD-13500
aa) RCD-14000
ab) RCD-14500
ac) RCD-15000
ad) RCD-15500
ae) RCD-16000
af) RCD-16500
ag) RCD-17000
ah) RCD-17500
ai) RCD-18000
aj) RCD-18500
ak) RCD-19000
al) RCD-19500
am) RCD-20000
an) RCD-20500
ao) RCD-21000
ap) RCD-21500
aq) RCD-22000
ar) RCD-22500
as) RCD-23000
at) RCD-23500
au) RCD-24000
av) RCD-24500
aw) RCD-25000
ax) RCD-25500
ay) RCD-26000
az) RCD-26500
ba) RCD-27000
bb) RCD-27500
bc) RCD-28000
bd) RCD-28500
be) RCD-29000
bf) RCD-29500
bg) RCD-30000
bh) RCD-30500
bi) RCD-31000
bj) RCD-31500
bk) RCD-32000
bl) RCD-32500
bm) RCD-33000
bn) RCD-33500
bo) RCD-34000
bp) RCD-34500
bq) RCD-35000
br) RCD-35500
bs) RCD-36000
bt) RCD-36500
bu) RCD-37000
bv) RCD-37500
bw) RCD-38000
bx) RCD-38500
by) RCD-39000
bz) RCD-39500
ca) RCD-40000
cb) RCD-40500
cc) RCD-41000
cd) RCD-41500
ce) RCD-42000
cf) RCD-42500
cg) RCD-43000
ch) RCD-43500
ci) RCD-44000
cj) RCD-44500
ck) RCD-45000
cl) RCD-45500
cm) RCD-46000
cn) RCD-46500
co) RCD-47000
cp) RCD-47500
cq) RCD-48000
cr) RCD-48500
cs) RCD-49000
ct) RCD-49500
cu) RCD-50000
cv) RCD-50500
cw) RCD-51000
cx) RCD-51500
cy) RCD-52000
cz) RCD-52500
da) RCD-53000
db) RCD-53500
dc) RCD-54000
dd) RCD-54500
de) RCD-55000
df) RCD-55500
dg) RCD-56000
dh) RCD-56500
di) RCD-57000
dj) RCD-57500
dk) RCD-58000
dl) RCD-58500
dm) RCD-59000
dn) RCD-59500
do) RCD-60000
dp) RCD-60500
dq) RCD-61000
dr) RCD-61500
ds) RCD-62000
dt) RCD-62500
du) RCD-63000
dv) RCD-63500
dw) RCD-64000
dx) RCD-64500
dy) RCD-65000
dz) RCD-65500
ea) RCD-66000
eb) RCD-66500
ec) RCD-67000
ed) RCD-67500
ee) RCD-68000
ef) RCD-68500
eg) RCD-69000
eh) RCD-69500
ei) RCD-70000
ej) RCD-70500
ek) RCD-71000
el) RCD-71500
em) RCD-72000
en) RCD-72500
eo) RCD-73000
ep) RCD-73500
eq) RCD-74000
er) RCD-74500
es) RCD-75000
et) RCD-75500
eu) RCD-76000
ev) RCD-76500
ew) RCD-77000
ex) RCD-77500
ey) RCD-78000
ez) RCD-78500
fa) RCD-79000
fb) RCD-79500
fc) RCD-80000
fd) RCD-80500
fe) RCD-81000
ff) RCD-81500
fg) RCD-82000
fh) RCD-82500
fi) RCD-83000
fj) RCD-83500
fk) RCD-84000
fl) RCD-84500
fm) RCD-85000
fn) RCD-85500
fo) RCD-86000
fp) RCD-86500
fq) RCD-87000
fr) RCD-87500
fs) RCD-88000
ft) RCD-88500
fu) RCD-89000
fv) RCD-89500
fw) RCD-90000
fx) RCD-90500
fy) RCD-91000
fz) RCD-91500
ga) RCD-92000
gb) RCD-92500
gc) RCD-93000
gd) RCD-93500
ge) RCD-94000
gf) RCD-94500
gg) RCD-95000
gh) RCD-95500
gi) RCD-96000
gj) RCD-96500
gk) RCD-97000
gl) RCD-97500
gm) RCD-98000
gn) RCD-98500
go) RCD-99000
gp) RCD-99500
gq) RCD-100000
gr) RCD-100500
gs) RCD-101000
gt) RCD-101500
gu) RCD-102000
gv) RCD-102500
gw) RCD-103000
gx) RCD-103500
gy) RCD-104000
gz) RCD-104500
ha) RCD-105000
hb) RCD-105500
hc) RCD-106000
hd) RCD-106500
he) RCD-107000
hf) RCD-107500
hg) RCD-108000
hh) RCD-108500
hi) RCD-109000
hj) RCD-109500
hk) RCD-110000
hl) RCD-110500
hm) RCD-111000
hn) RCD-111500
ho) RCD-112000
hp) RCD-112500
hu) RCD-113000
hv) RCD-113500
hw) RCD-114000
hx) RCD-114500
hy) RCD-115000
hz) RCD-115500
ia) RCD-116000
ib) RCD-116500
ic) RCD-117000
id) RCD-117500
ie) RCD-118000
if) RCD-118500
ig) RCD-119000
ih) RCD-119500
ii) RCD-120000
ij) RCD-120500
ik) RCD-121000
il) RCD-121500
im) RCD-122000
in) RCD-122500
io) RCD-123000
ip) RCD-123500
iq) RCD-124000
ir) RCD-124500
is) RCD-125000
it) RCD-125500
iu) RCD-126000
iv) RCD-126500
iw) RCD-127000
ix) RCD-127500
iy) RCD-128000
iz) RCD-128500
ja) RCD-129000
jb) RCD-129500
jc) RCD-130000
jd) RCD-130500
je) RCD-131000
jf) RCD-131500
jg) RCD-132000
jh) RCD-132500
ji) RCD-133000
jj) RCD-133500
jk) RCD-134000
jl) RCD-134500
jm) RCD-135000
jn) RCD-135500
jo) RCD-136000
jp) RCD-136500
jq) RCD-137000
jr) RCD-137500
js) RCD-138000
jt) RCD-138500
ju) RCD-139000 | |

SECTION - PRIVATE DOMESTIC SOAKAWAY

Scale N.T.S.

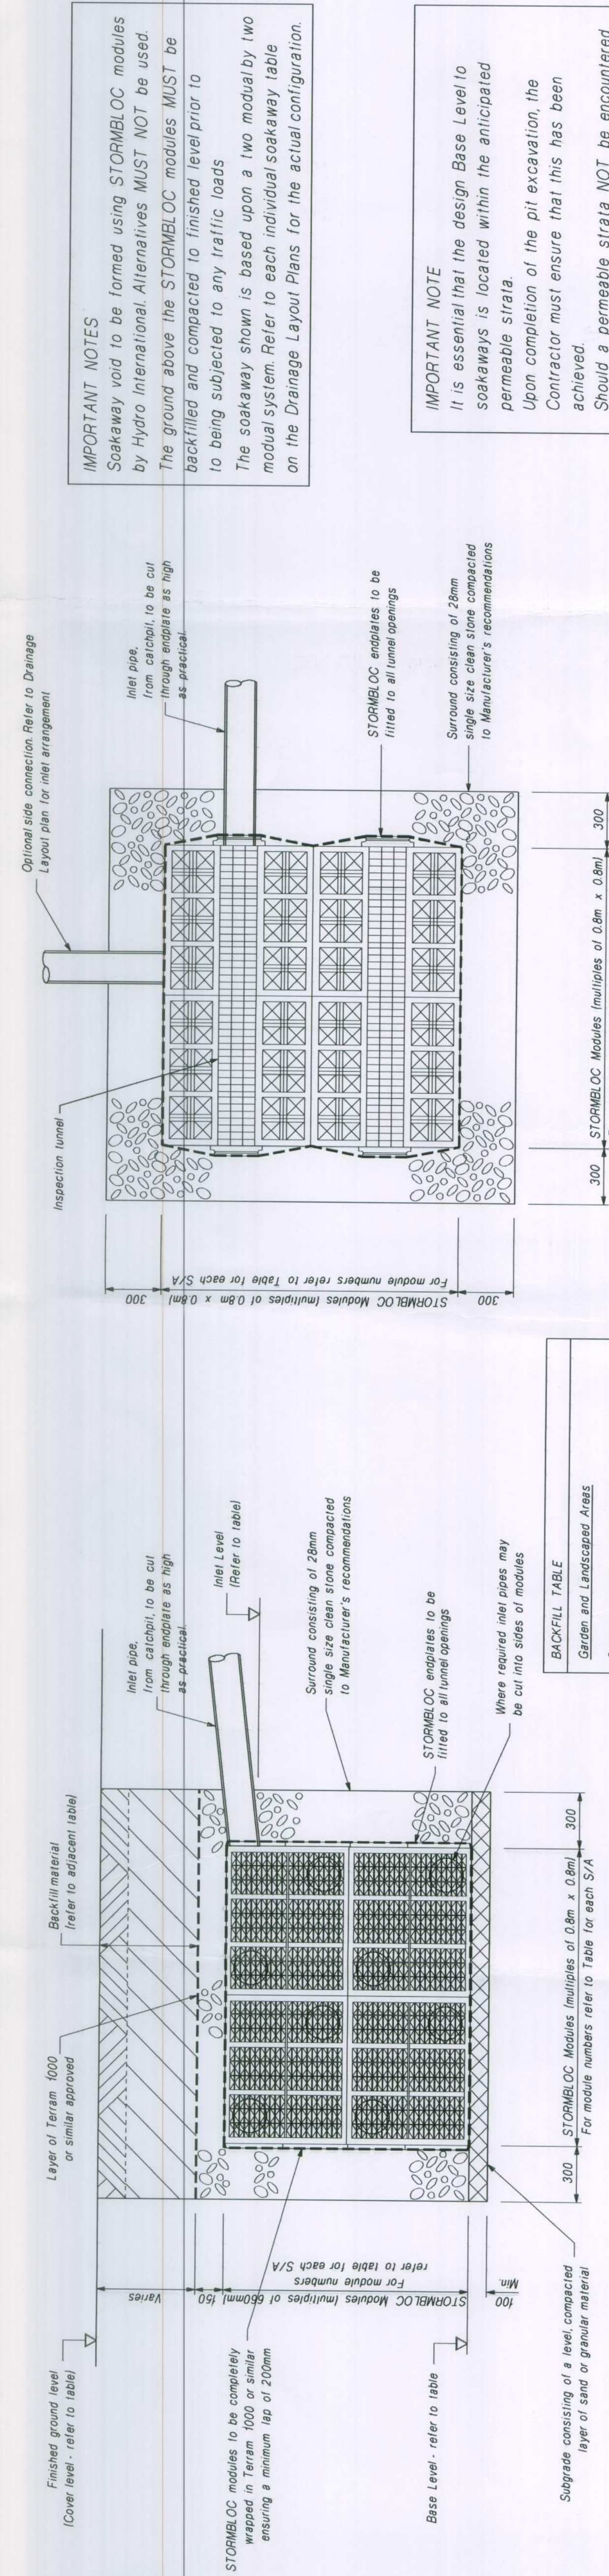

PLAN - PRIVATE DOMESTIC SOAKAWAY

Scale N.T.S.

IMPORTANT NOTES

Soakaway void to be formed using STORMBLOC modules by Hydro International. Alternatives **MUST NOT** be used.

The ground above the STORMBLOC modules **MUST** be backfilled and compacted to finished level prior to being subjected to any traffic loads

The soakaway shown is based upon a two modular by two modular system. Refer to each individual soakaway table on the Drainage Layout Plans for the actual configuration

IMPORTANT NOTE
It is essential that the design Base Level to soakways is located within the anticipated permeable strata.
Upon completion of the pit excavation, the Contractor must ensure that this has been achieved.
Should a permeable strata NOT be encountered, construction must cease and TRIBRACH ASSOCIATES advised in order that a review of the design may be undertaken.

Rev. No.	Revision	Date	Drawn
A	Manhole F4 installed in line of existing manhole. Spawr length F2-F4 shown as PVC in plan.		BRC
B	Working drawings incorporating Sotwajays amended to reflect design file	18/5/11	BRC
C	S42 amended for 1000r rags. Sotwajay revised to suit.	22/6/11	BRC
D	Sotwajay Sotwajay revised	3/6/11	BRC
E	Water works completed 18/05/2012 23:47. 17.00 M	23/11/11	BRC



14 Eversley Road, Boxhill on Sea, East Sussex. TN40 1EU
Tel: (01424) 216214 Fax: (01424) 734284

Client

ABBEE DEVELOPMENTS LTD

Project **HEARNFIELD ROAD, WICK
LITTLEHAMPTON, WEST SUSSEX**

DRAINAGE LAYOUT

Scales
Horizontal: 1:200 at A0
Date: May 2011

DRAWING No: 210389/14

DRAWING No. 210389/14