


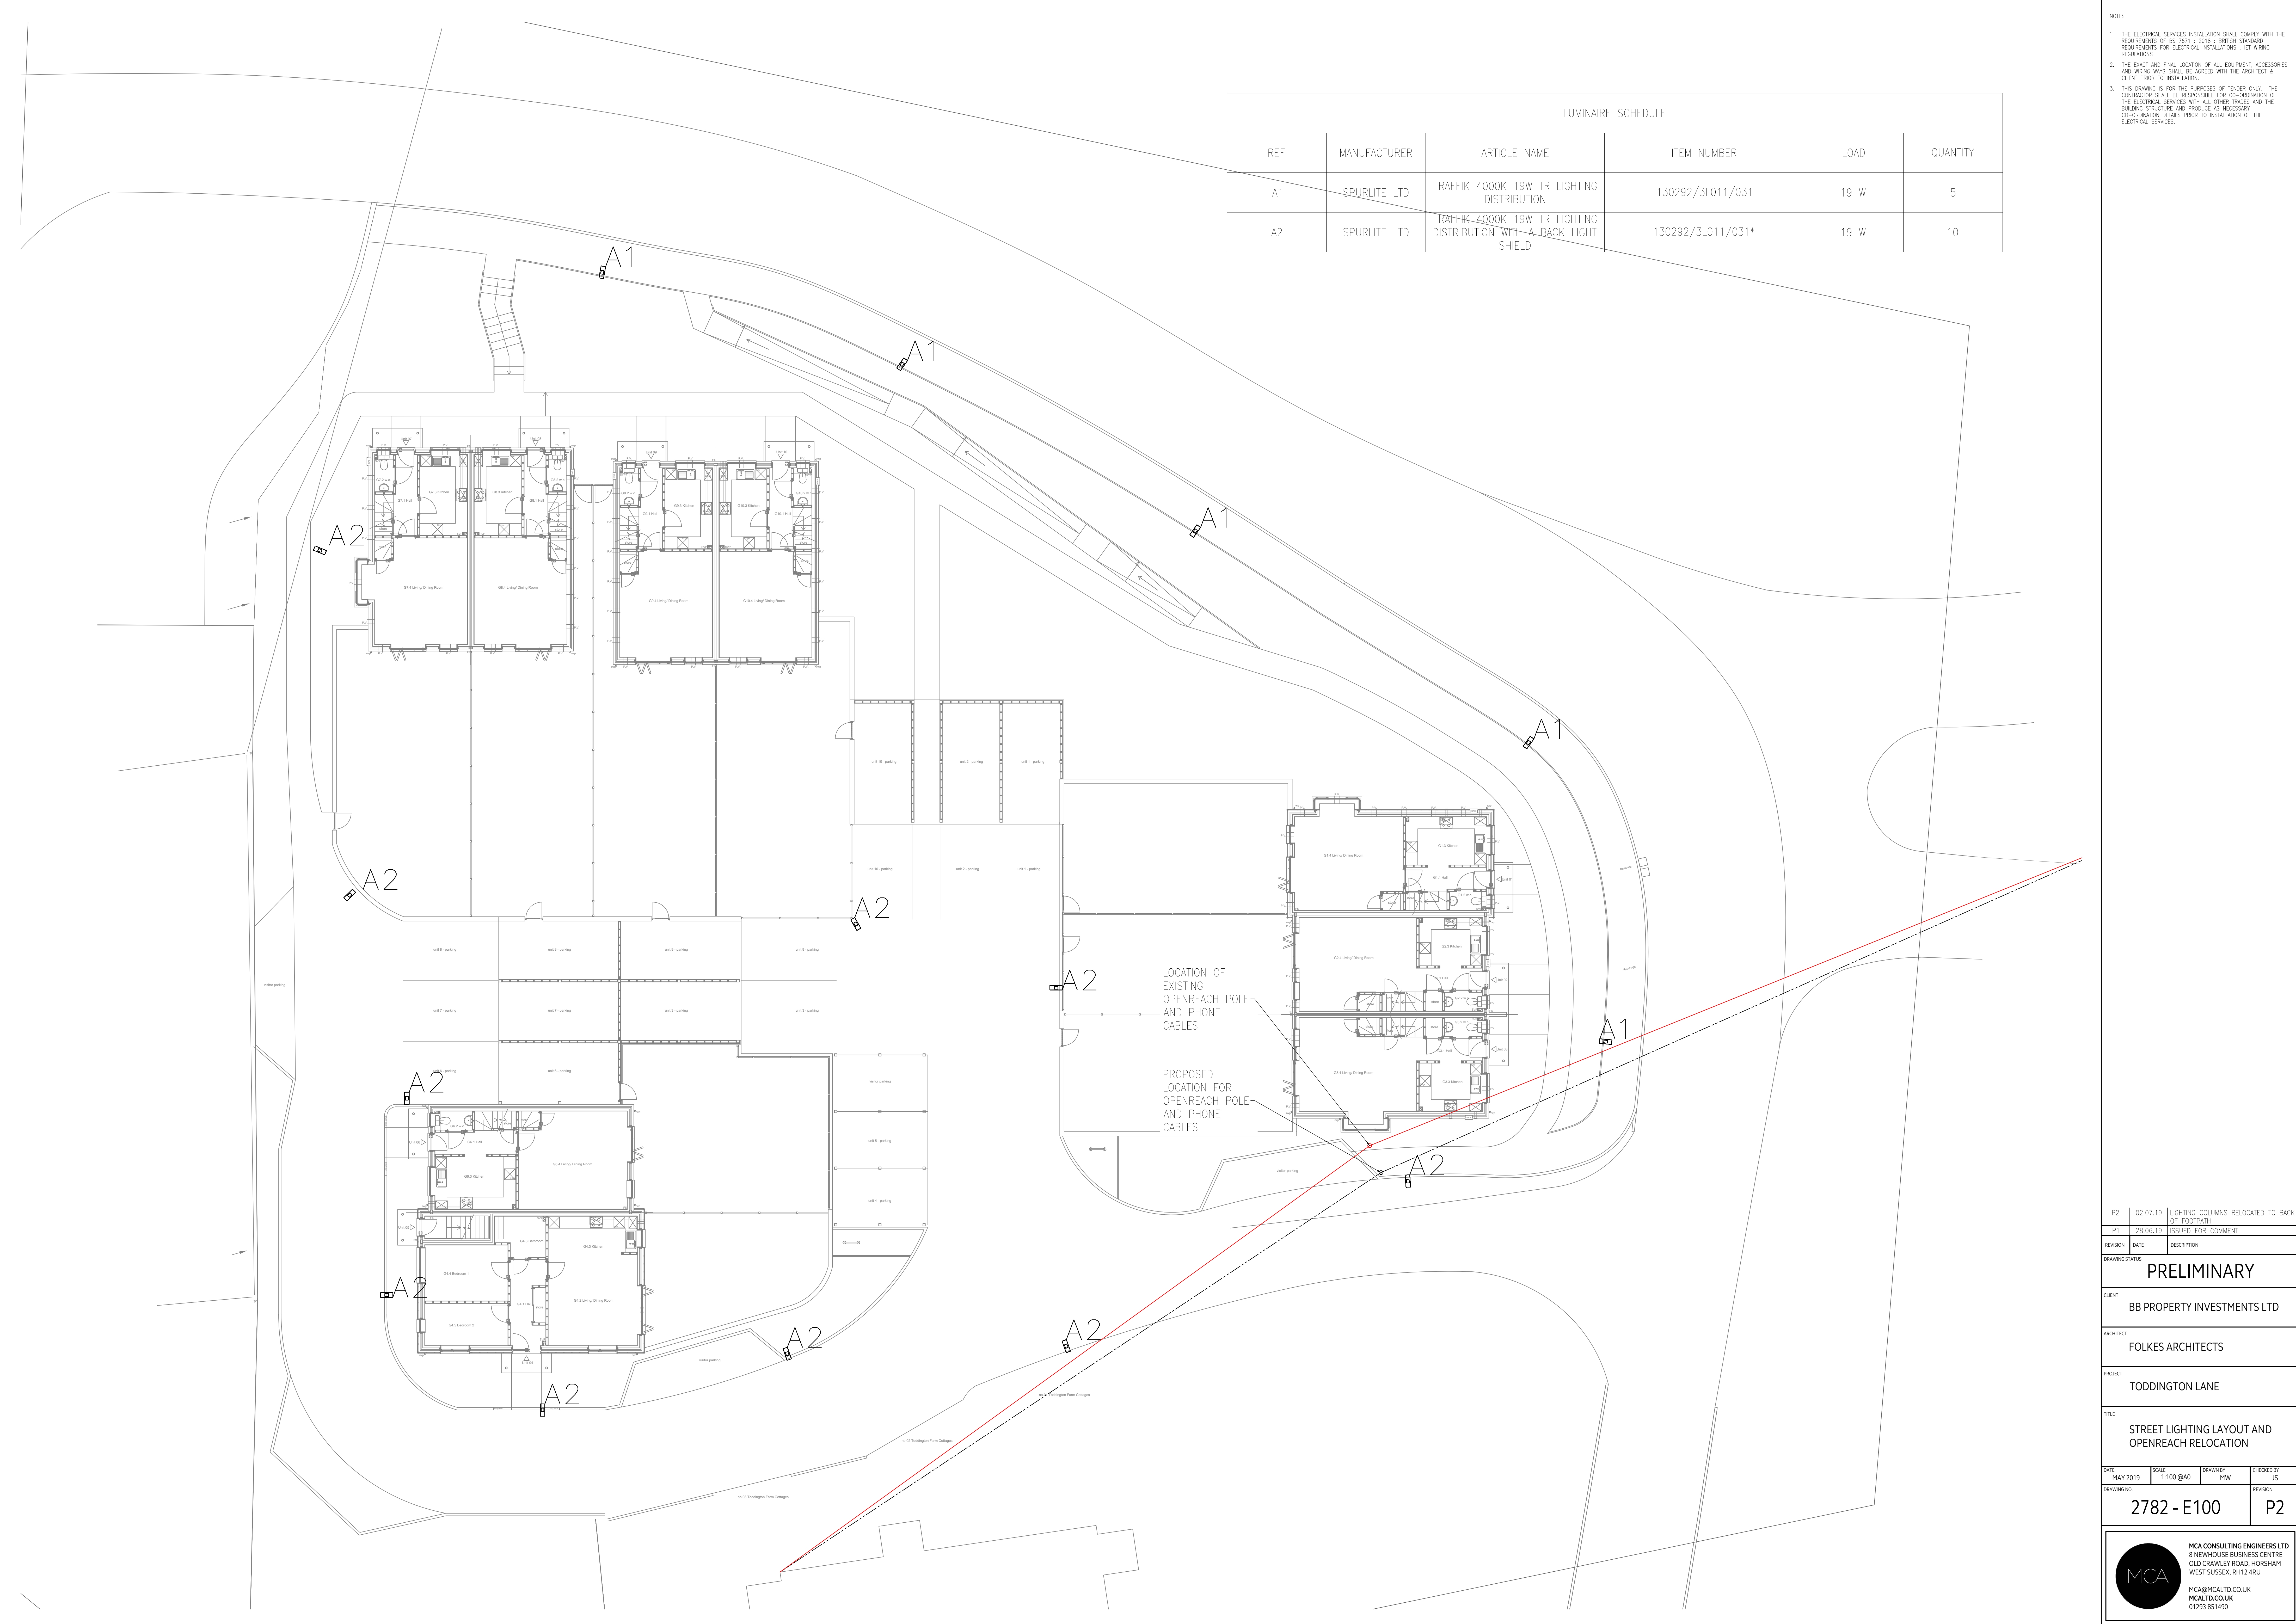

LUMINAIRE SCHEDULE					
REF	MANUFACTURER	ARTICLE NAME	ITEM NUMBER	LOAD	QUANTITY
A1	SPURLITE LTD	TRAFFIK 4000K 19W TR LIGHTING DISTRIBUTION	130292/3L011/031	19 W	5
A2	SPURLITE LTD	TRAFFIK 4000K 19W TR LIGHTING DISTRIBUTION WITH A BACK LIGHT SHIELD	130292/3L011/031*	19 W	10

- NOTES
1. THE ELECTRICAL SERVICES INSTALLATION SHALL COMPLY WITH THE REQUIREMENTS OF BS 7671 : 2018 : BRITISH STANDARD REQUIREMENTS FOR ELECTRICAL INSTALLATIONS : IET WIRING REGULATIONS
 2. THE EXACT AND FINAL LOCATION OF ALL EQUIPMENT, ACCESSORIES AND WIRING MAYS SHALL BE AGREED WITH THE ARCHITECT & CLIENT PRIOR TO INSTALLATION.
 3. THIS DRAWING IS FOR THE PURPOSES OF TENDER ONLY. THE CONTRACTOR SHALL BE RESPONSIBLE FOR CO-ORDINATION OF THE ELECTRICAL SERVICES WITH ALL OTHER TRADES AND THE BUILDING STRUCTURE AND PROVIDE AS NECESSARY CO-ORDINATION DETAILS PRIOR TO INSTALLATION OF THE ELECTRICAL SERVICES.

P2	02.07.19	LIGHTING COLUMNS RELOCATED TO BACK OF FOOTPATH
P1	28.06.19	ISSUED FOR COMMENT

REVISION	DATE	DESCRIPTION
----------	------	-------------

DRAWING STATUS

PRELIMINARY

CLIENT
BB PROPERTY INVESTMENTS LTD

ARCHITECT
FOLKES ARCHITECTS

PROJECT
TODDINGTON LANE

TITLE
STREET LIGHTING LAYOUT AND OPENREACH RELOCATION

DATE
MAY 2019

SCALE
1:100 @A0

DRAWN BY
MW

CHECKED BY
JS

DRAWING NO
2782 - E100

REVISION
P2

MCA CONSULTING ENGINEERS LTD
8 NEWHOUSE BUSINESS CENTRE
OLD CRAWLEY ROAD, HORSHAM
WEST SUSSEX, RH12 4RU

MCA@MCALTD.CO.UK
MCALTD.CO.UK
01293 851490

MCA

MCA

MCA

MCA