


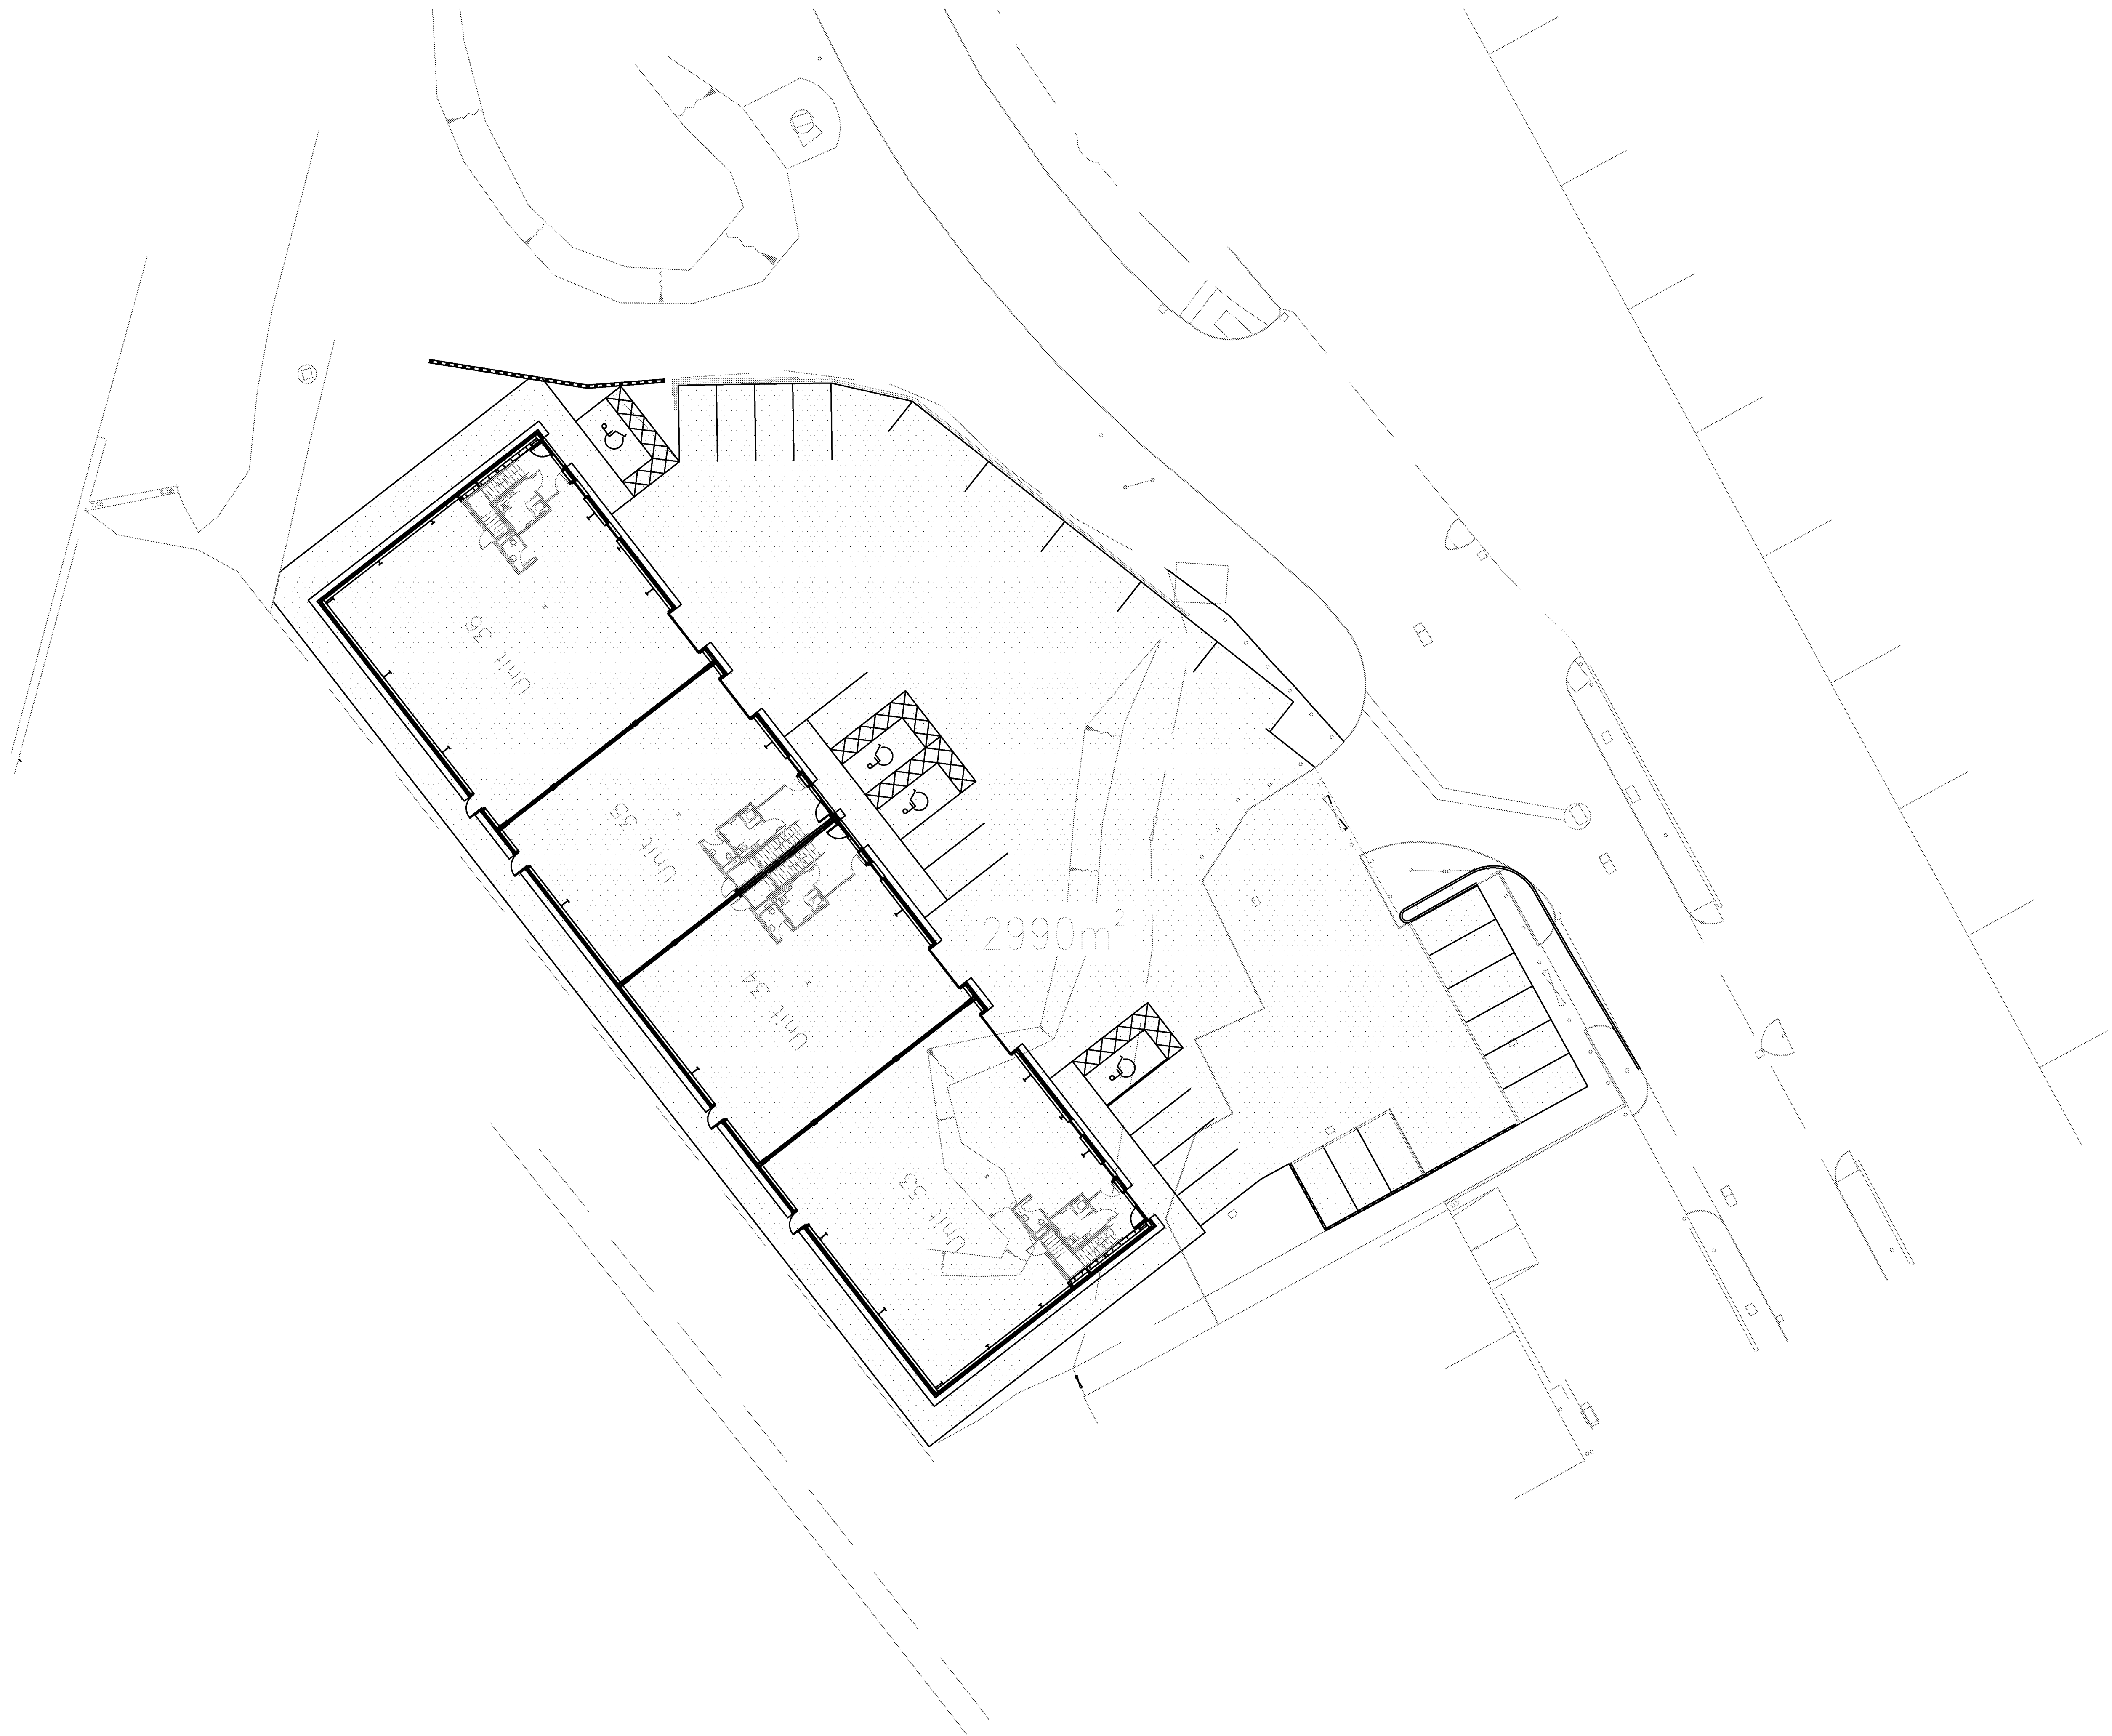


Ref.	Revisions	By	Date

Lineside Industrial Estate
Eldon Way
Littlehampton

INFORMATION ISSUE

Drainage Layout
Soakaway Design
Impermeable Areas Plan

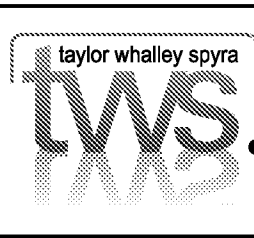

taylor whalley spyrar
consulting civil and structural engineers

3 Dufferin Avenue, Barbican, LONDON EC1Y 8PQ
Tel: (020) 7253 2828 Fax: (020) 7253 2787
E-mail: tws@tws.uk.com Website: www.tws.uk.com

Scale at A1	Date	Drawn By	
1:200	25/07/19	JDC	

Project No.	Drg No.	Rev.
9261	PH_SK01	—