



ARUN DISTRICT COUNCIL L/1914/18/PL

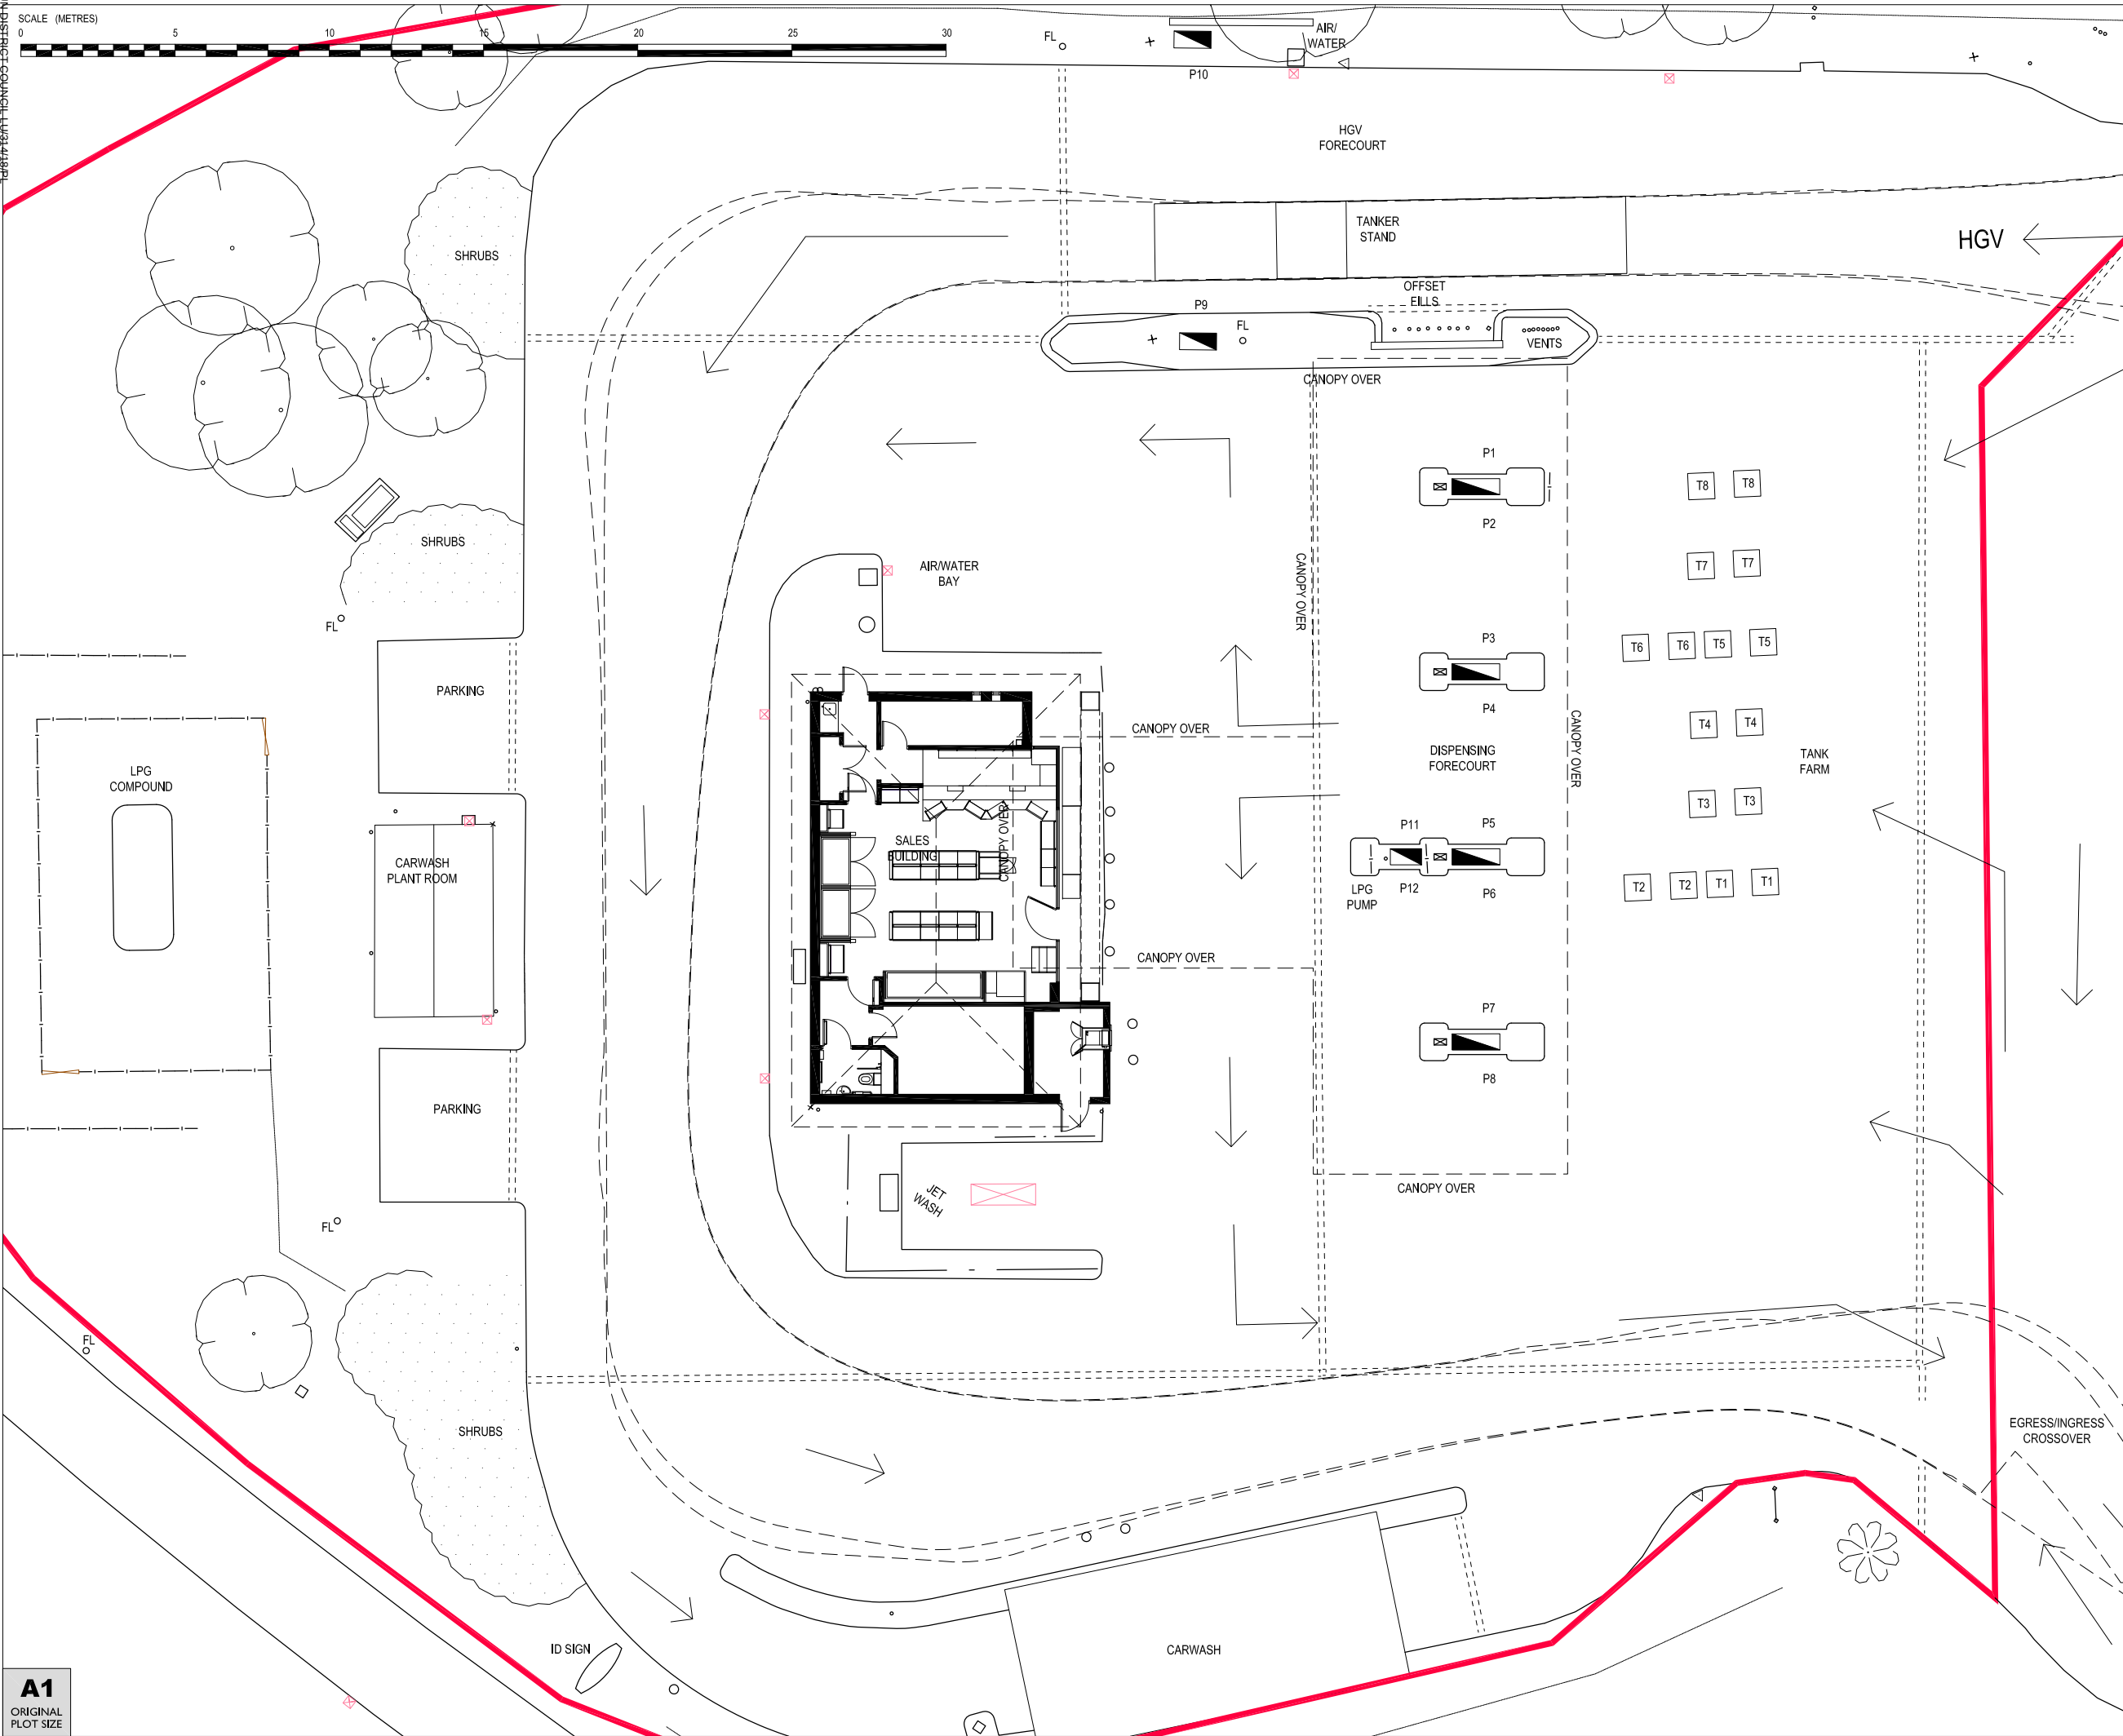

TANK TO PUMP SCHEDULE						
tank no	fuel grade	Max working capacity (L)	pump numbers			
			1/2	3/4	5/6	7/8 9/10
TANK No.1	VPOWER UNLEADED	12,350			●	●
TANK No.2	VPOWER DIESEL	12,350			●	●
TANK No.3	DIESEL	24,700				●
TANK No.4	UNLEADED	24,700			●	●
TANK No.5	VPOWER UNLEADED	12,350			●	●
TANK No.6	VPOWER UNLEADED	12,350	●			
TANK No.7	UNLEADED	24,700				●
TANK No.8	DIESEL	24,700	●			
TANK No.9	LPG	5,000				

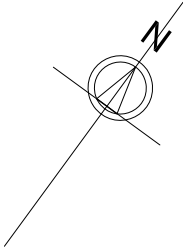

PLANNING DRAWING

ALLAN.B. MATTHEWS A.R.I.B.A. 37 Fore Street,
Bovey Tracey, Devon
TQ13 9AD
Tel : (01626) 633727
Fax : (01626) 633102
enquiries@allanbmattthews.co.uk



PROJECT: SHELL EASTFIELD
RUSTINGDON BYPASS, WICK,
LITTLEHAMPTON, BN17 6LE

TITLE: SITE LAYOUT PLAN (1:100) as existing



SHELL UK RETAIL
PO BOX 430
STAINES
TW18 3ZB
UNITED KINGDOM

DRAWN BY:	DH	SCALE:	1:100
DATE:	11.10.2018	PLOT DATE:	
CAD FILE:	E:\ARCHIVE\DRAWINGS\EASTFIELD\10019507		
DWG No:	10019507	PLG - 01	2018

A1
ORIGINAL
PLOT SIZE