


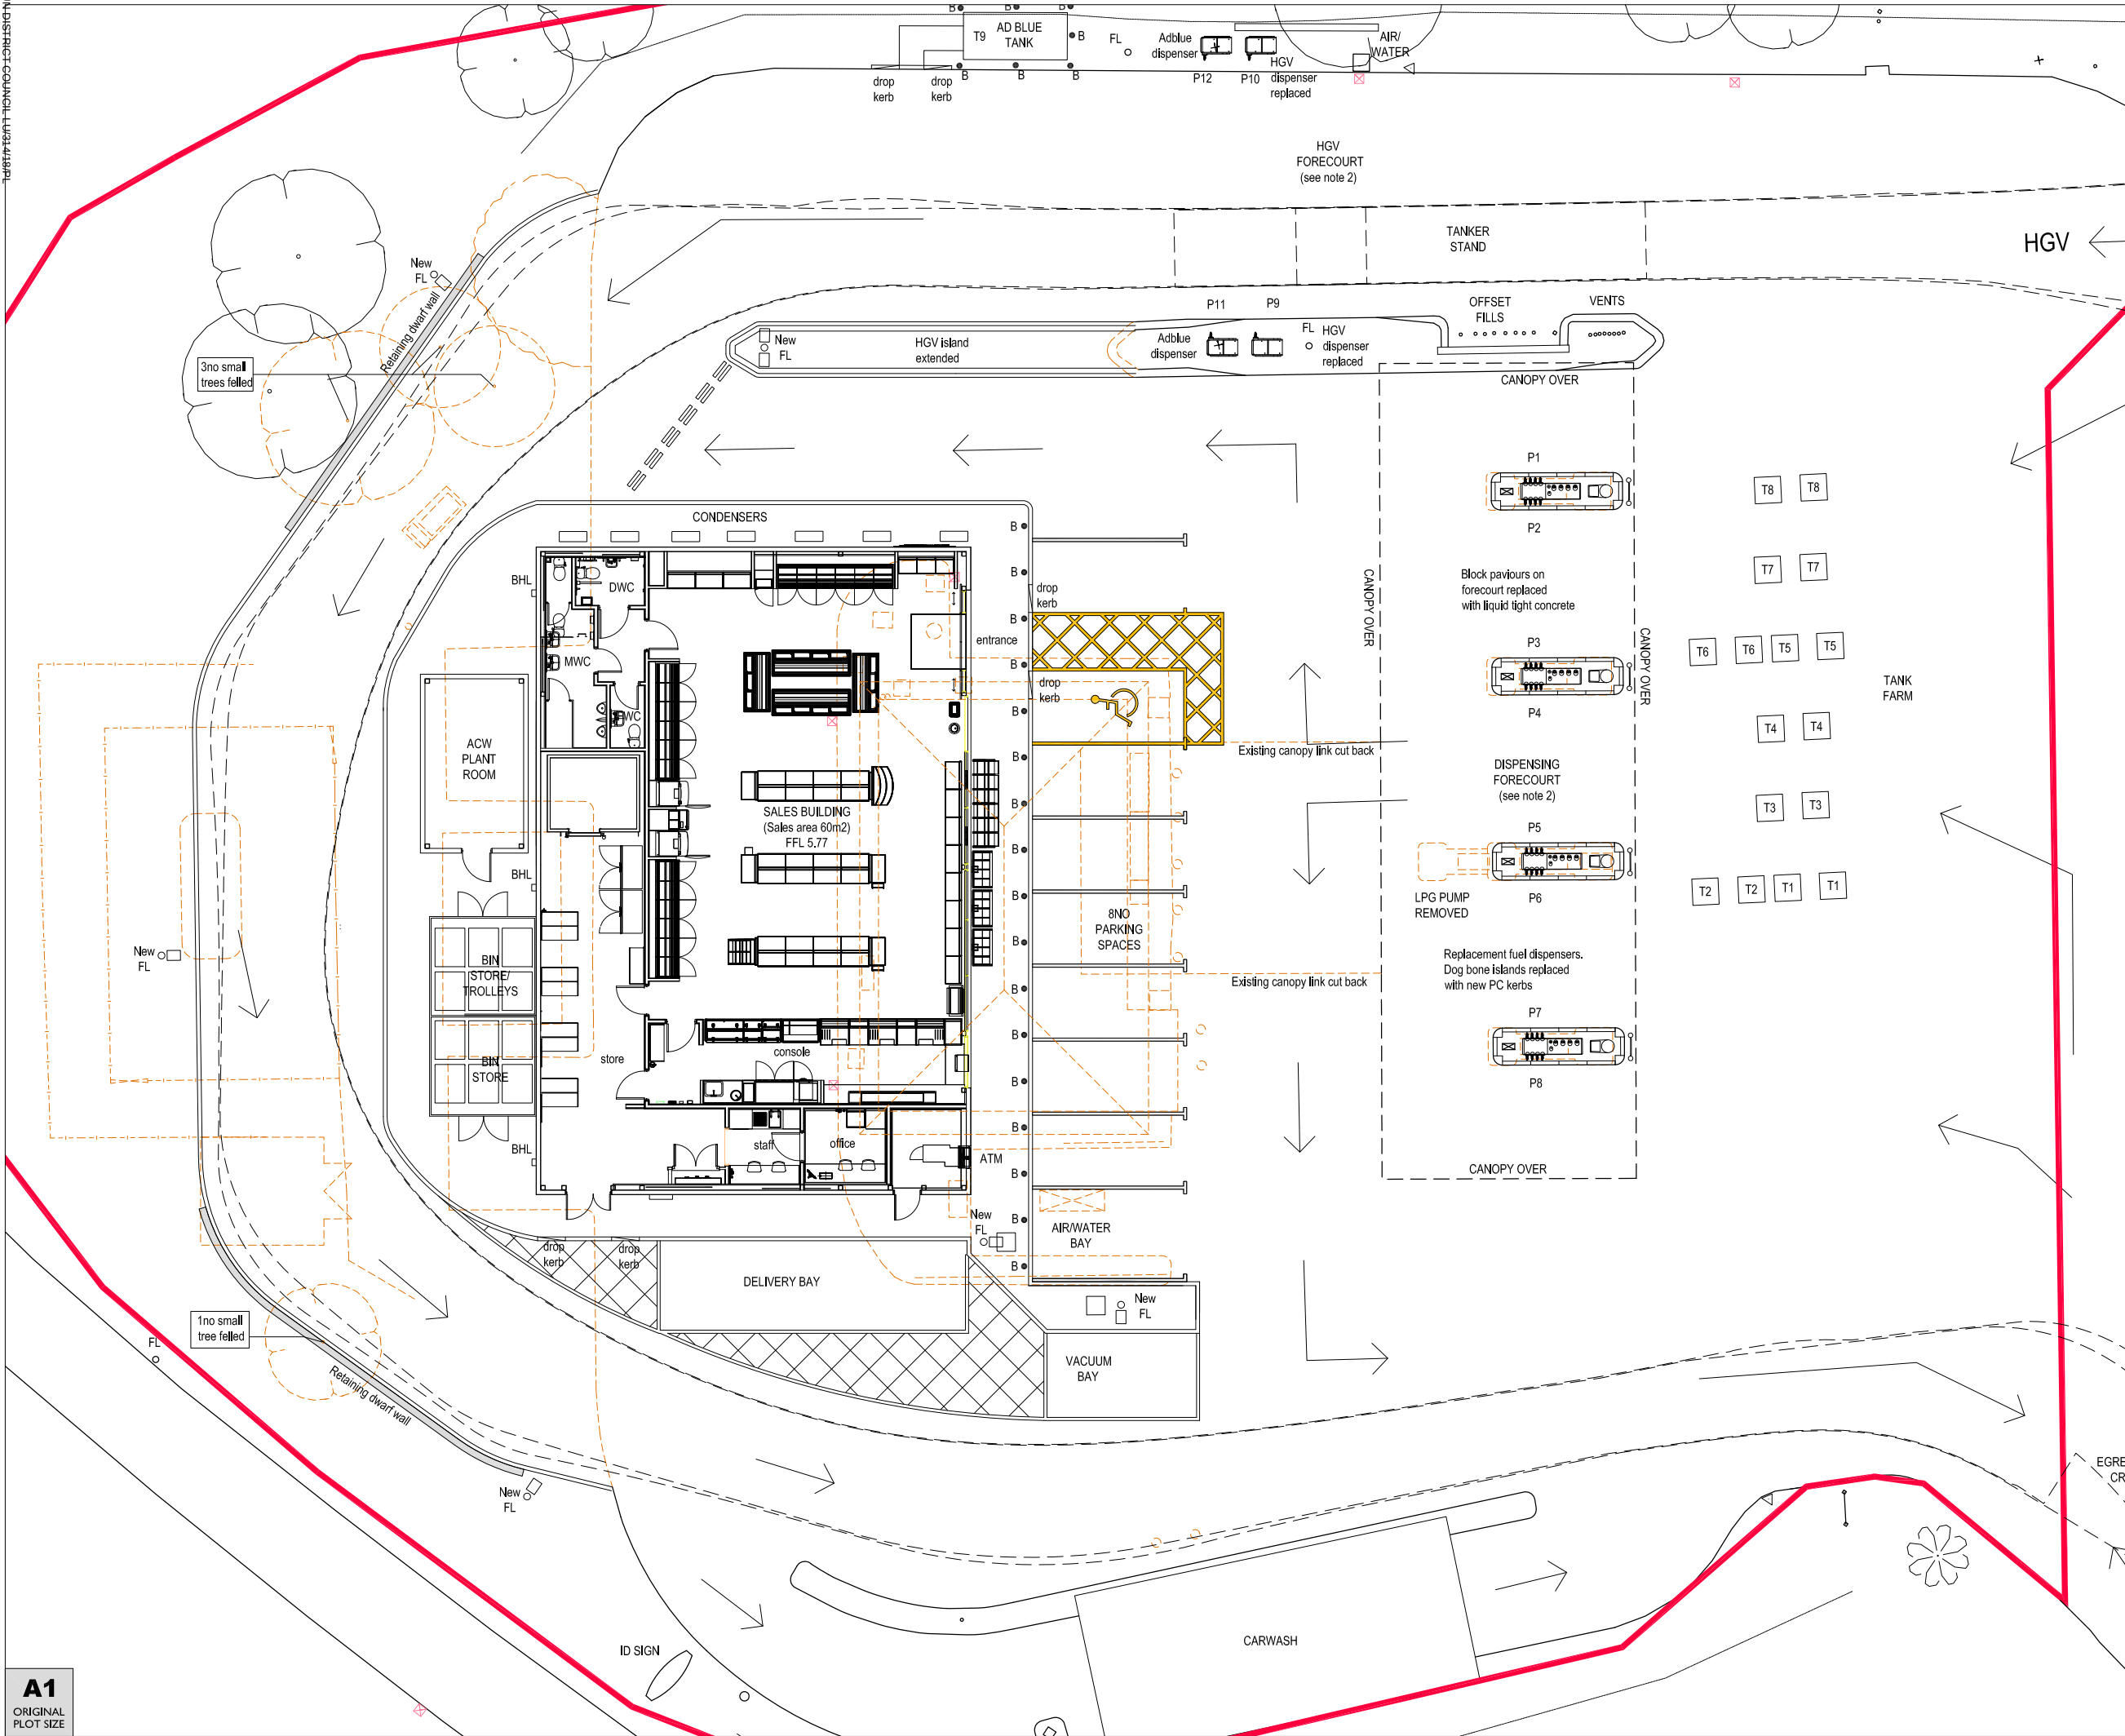

1. THIS PROJECT IS FOR THE REPLACEMENT OF THE SALES BUILDING AND FRONT OF STORE CUSTOMER PARKING ONLY.

2. THERE ARE NO WORKS PROPOSED TO THE FUEL INFRASTRUCTURE

KEY

EXISTING DEMOLISHED

B **NEW BALLARD**


 BOUNDARY LINE

FL = Existing Floodlight

New FL = Floodlight on 5m high pole

BHL = Wall mounted bulkhead light

TANK TO PUMP SCHEDULE											
	tank no	fuel grade	Max working capacity (L)	pump numbers							
				1/2	3/4	5/6	7/8	9/10	11/12		
Existing tank	TANK No. 1	VPOWER UNLEADED	12,350								
Existing tank	TANK No. 2	VPOWER DIESEL	12,350	●							
Existing tank	TANK No. 3	DIESEL	24,700		●	●	●	●			
Existing tank	TANK No. 4	UNLEADED	24,700			●	●	●	●		
Existing tank	TANK No. 5	VPOWER UNLEADED	12,350								
Existing tank	TANK No. 8	VPOWER UNLEADED	12,350	●							
Existing tank	TANK No. 7	UNLEADED	24,700					●			
Existing tank	TANK No. 8	DIESEL	24,700	●					●		
Tank removed		LPG	5,000								
New tank	TANK No. 9	AD BLUE	5,000							●	
3NO NEW SUCTION LINES FROM T2 TO P1-2, P3-4 & P7-8 NO NEW SUCTION LINE FROM T3 TO P5-6											

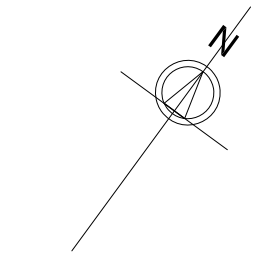

PLANNING DRAWING

ALLAN.B. MATTHEWS A.R.I.B.A.

37 Fore Street,

ovey Tracey, Devon
TO13 9AD

el : (01626) 833727

Fax : (01626) 833102
 enquiries@allanbmattthews.co.uk



REV	DATE		BY

PROJECT: SHELL EASTFIELD
RUSTINGDON BYPASS, WICK,
LITTLEHAMPTON, BN17 6LE

TITLE : SITE LAYOUT PLAN (1:100) as proposed



SHELL UK RETAIL
PO BOX 430
STAINES
TW18 3ZB
UNITED KINGDOM

DRAWN BY: DH		SCALE: 1:100	
DATE: 11.10.2018		PLOT DATE:	
CAD FILE: E:\ARCHIVE\DRAWINGS\EASTFIELD\10019507			
DWG No:	10019507	PLG - 04	2018