


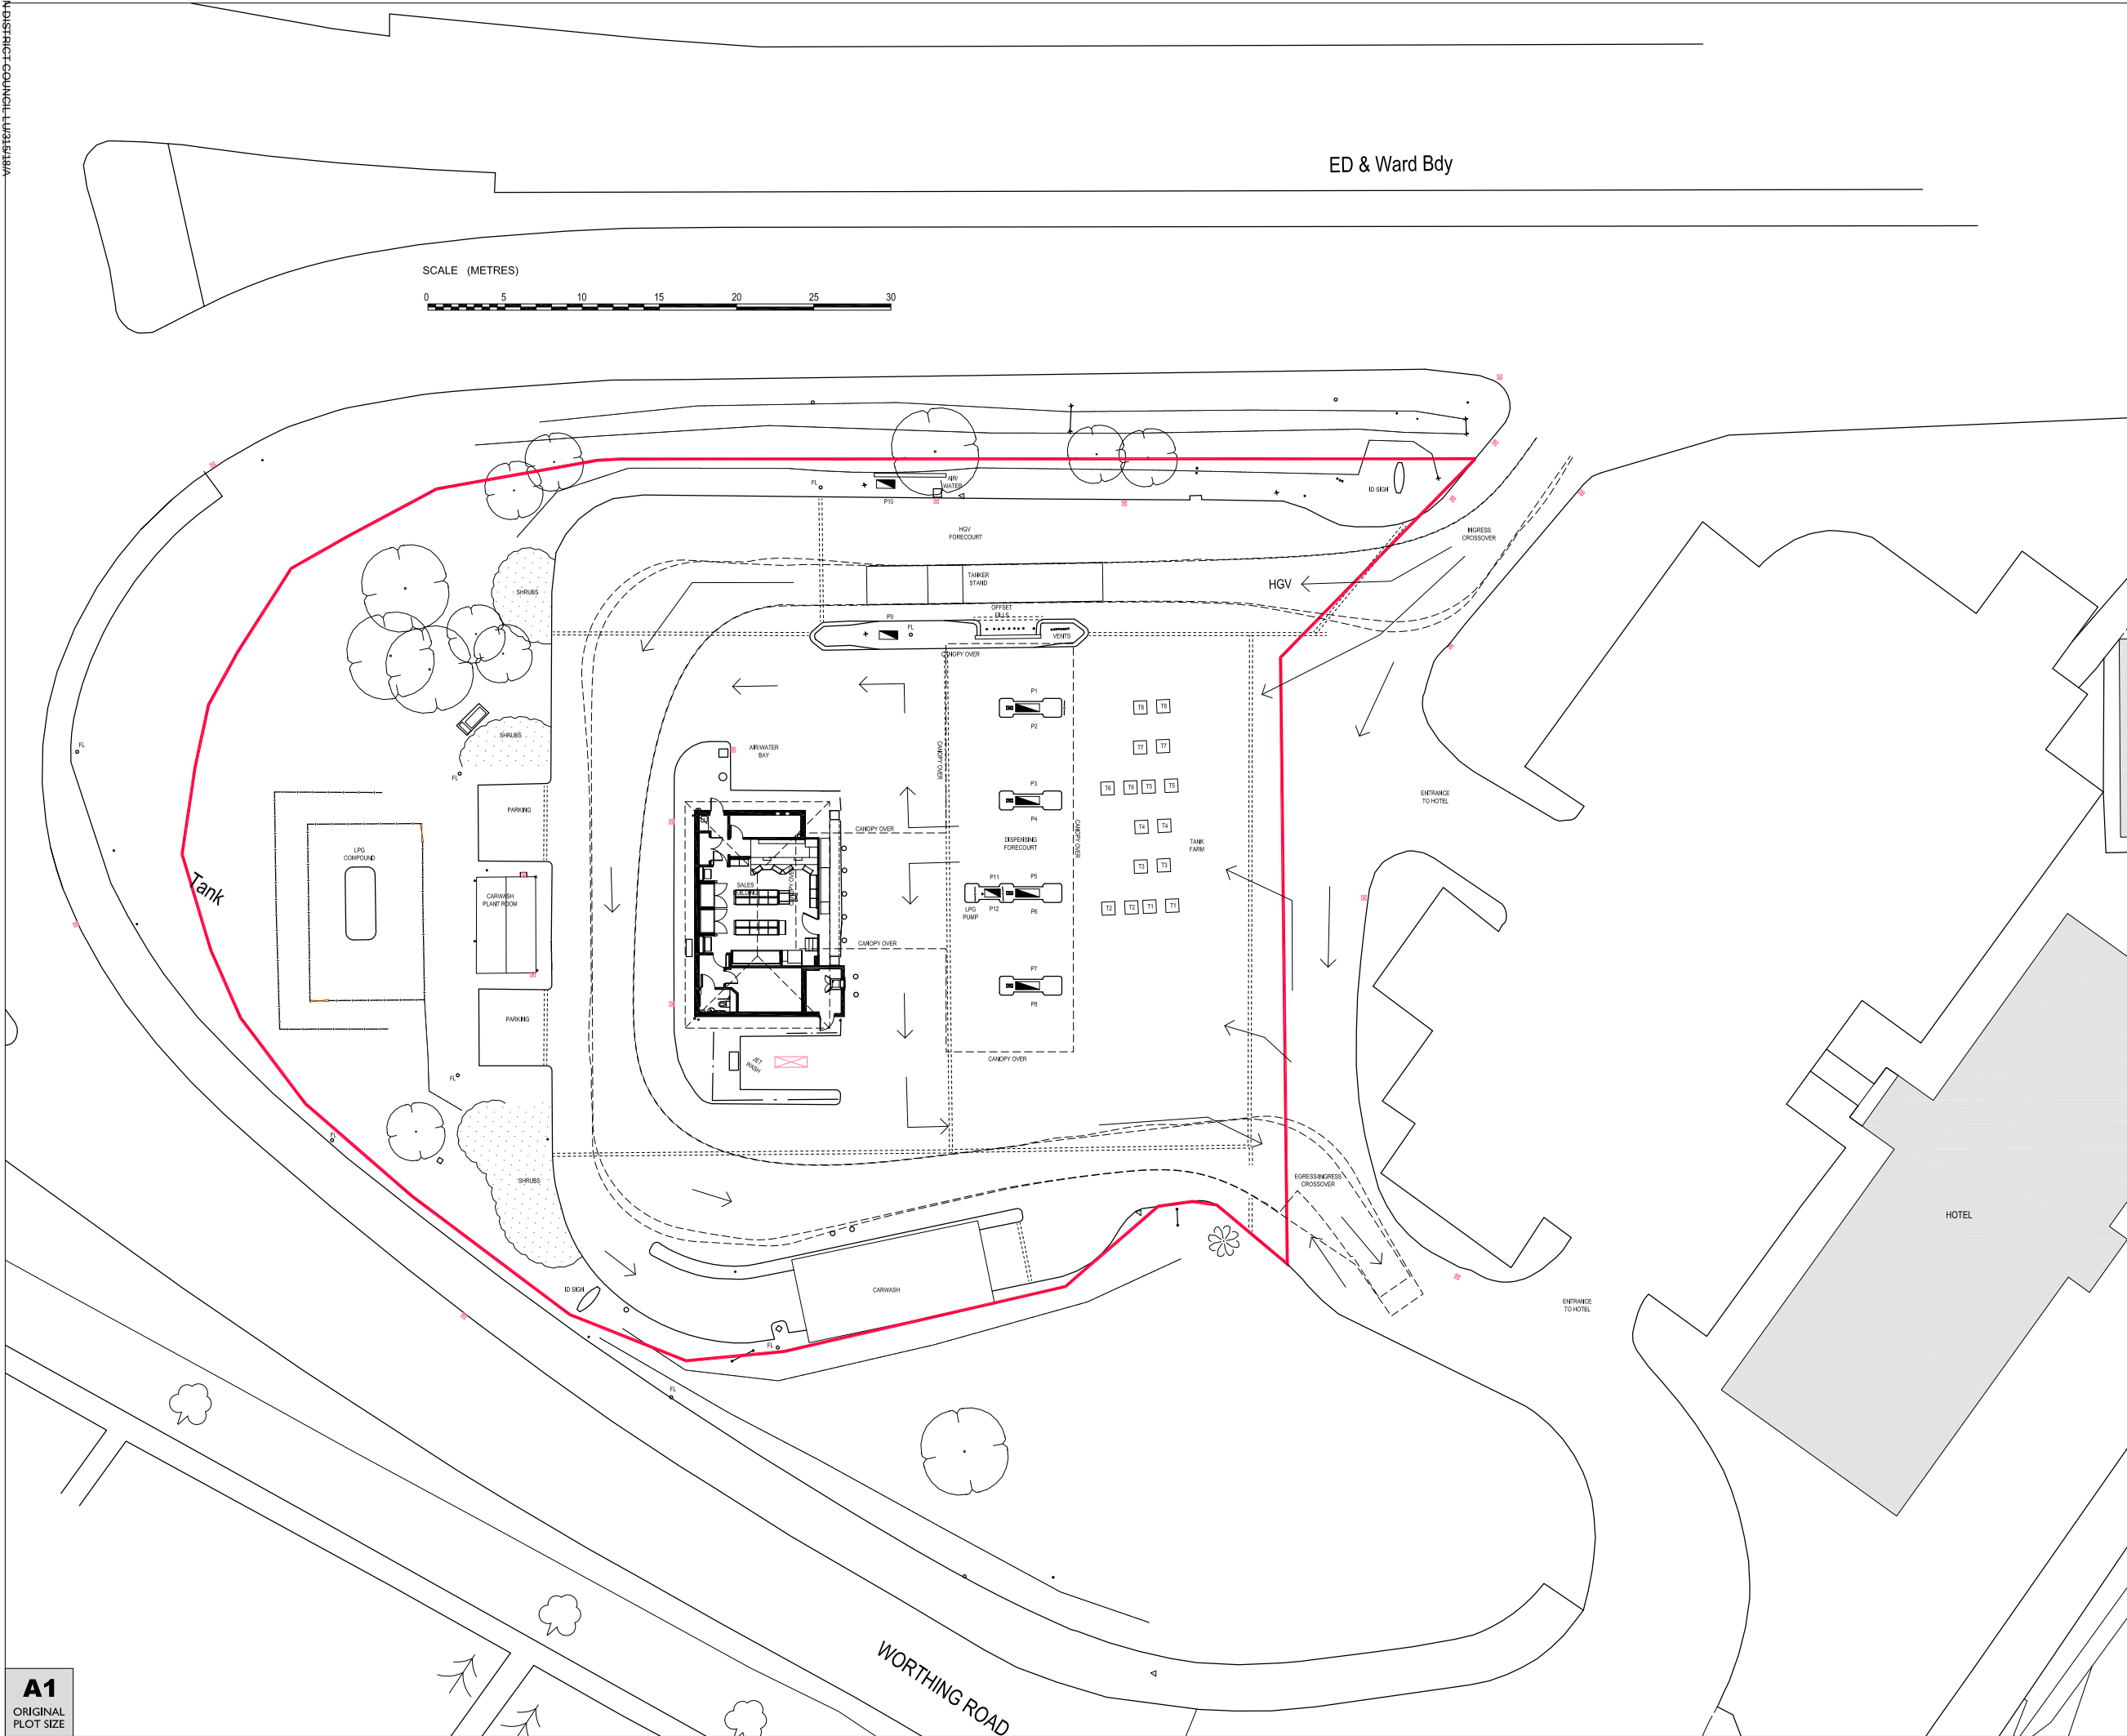

TANK TO PUMP SCHEDULE								
tank no	fuel grade	Max working capacity (L)	pump numbers					
			1/2	3/4	5/6	7/8	9/10	
TANK No.1	VPOWER UNLEADED	12,350						
TANK No.2	VPOWER DIESEL	12,350			●			
TANK No.3	DIESEL	24,700		●			●	
TANK No.4	UNLEADED	24,700						
TANK No.5	VPOWER UNLEADED	12,350		●				
TANK No.6	VPOWER UNLEADED	12,350		●				
TANK No.7	UNLEADED	24,700					●	
TANK No.8	DIESEL	24,700		●				●
TANK No.9	LPG	5,000						



PLANNING DRAWING

ALLAN.B. MATTHEWS A.R.I.B.A. 37 Fore Street,
Bovey Tracey, Devon
TQ13 9AD
Tel : (01626) 633727
Fax : (01626) 633102
enquiries@allanbmatthews.co.uk



REV	DATE	BY

PROJECT: SHELL EASTFIELD
RUSTINGTON BYPASS, WICK,
LITTLEHAMPTON, BN17 6LE

TITLE: SITE LAYOUT PLAN (1:200) as existing



SHELL UK RETAIL
PO BOX 430
STAINES
TW18 3ZB
UNITED KINGDOM

DRAWN BY:	DH	SCALE:	1:200
DATE:	11.10.2018	PLOT DATE:	
CAD FILE:	E:\ARCHIVE\DRAWINGS\EASTFIELD\10019507		
DWG No:	10019507	PLG - 02	2018