


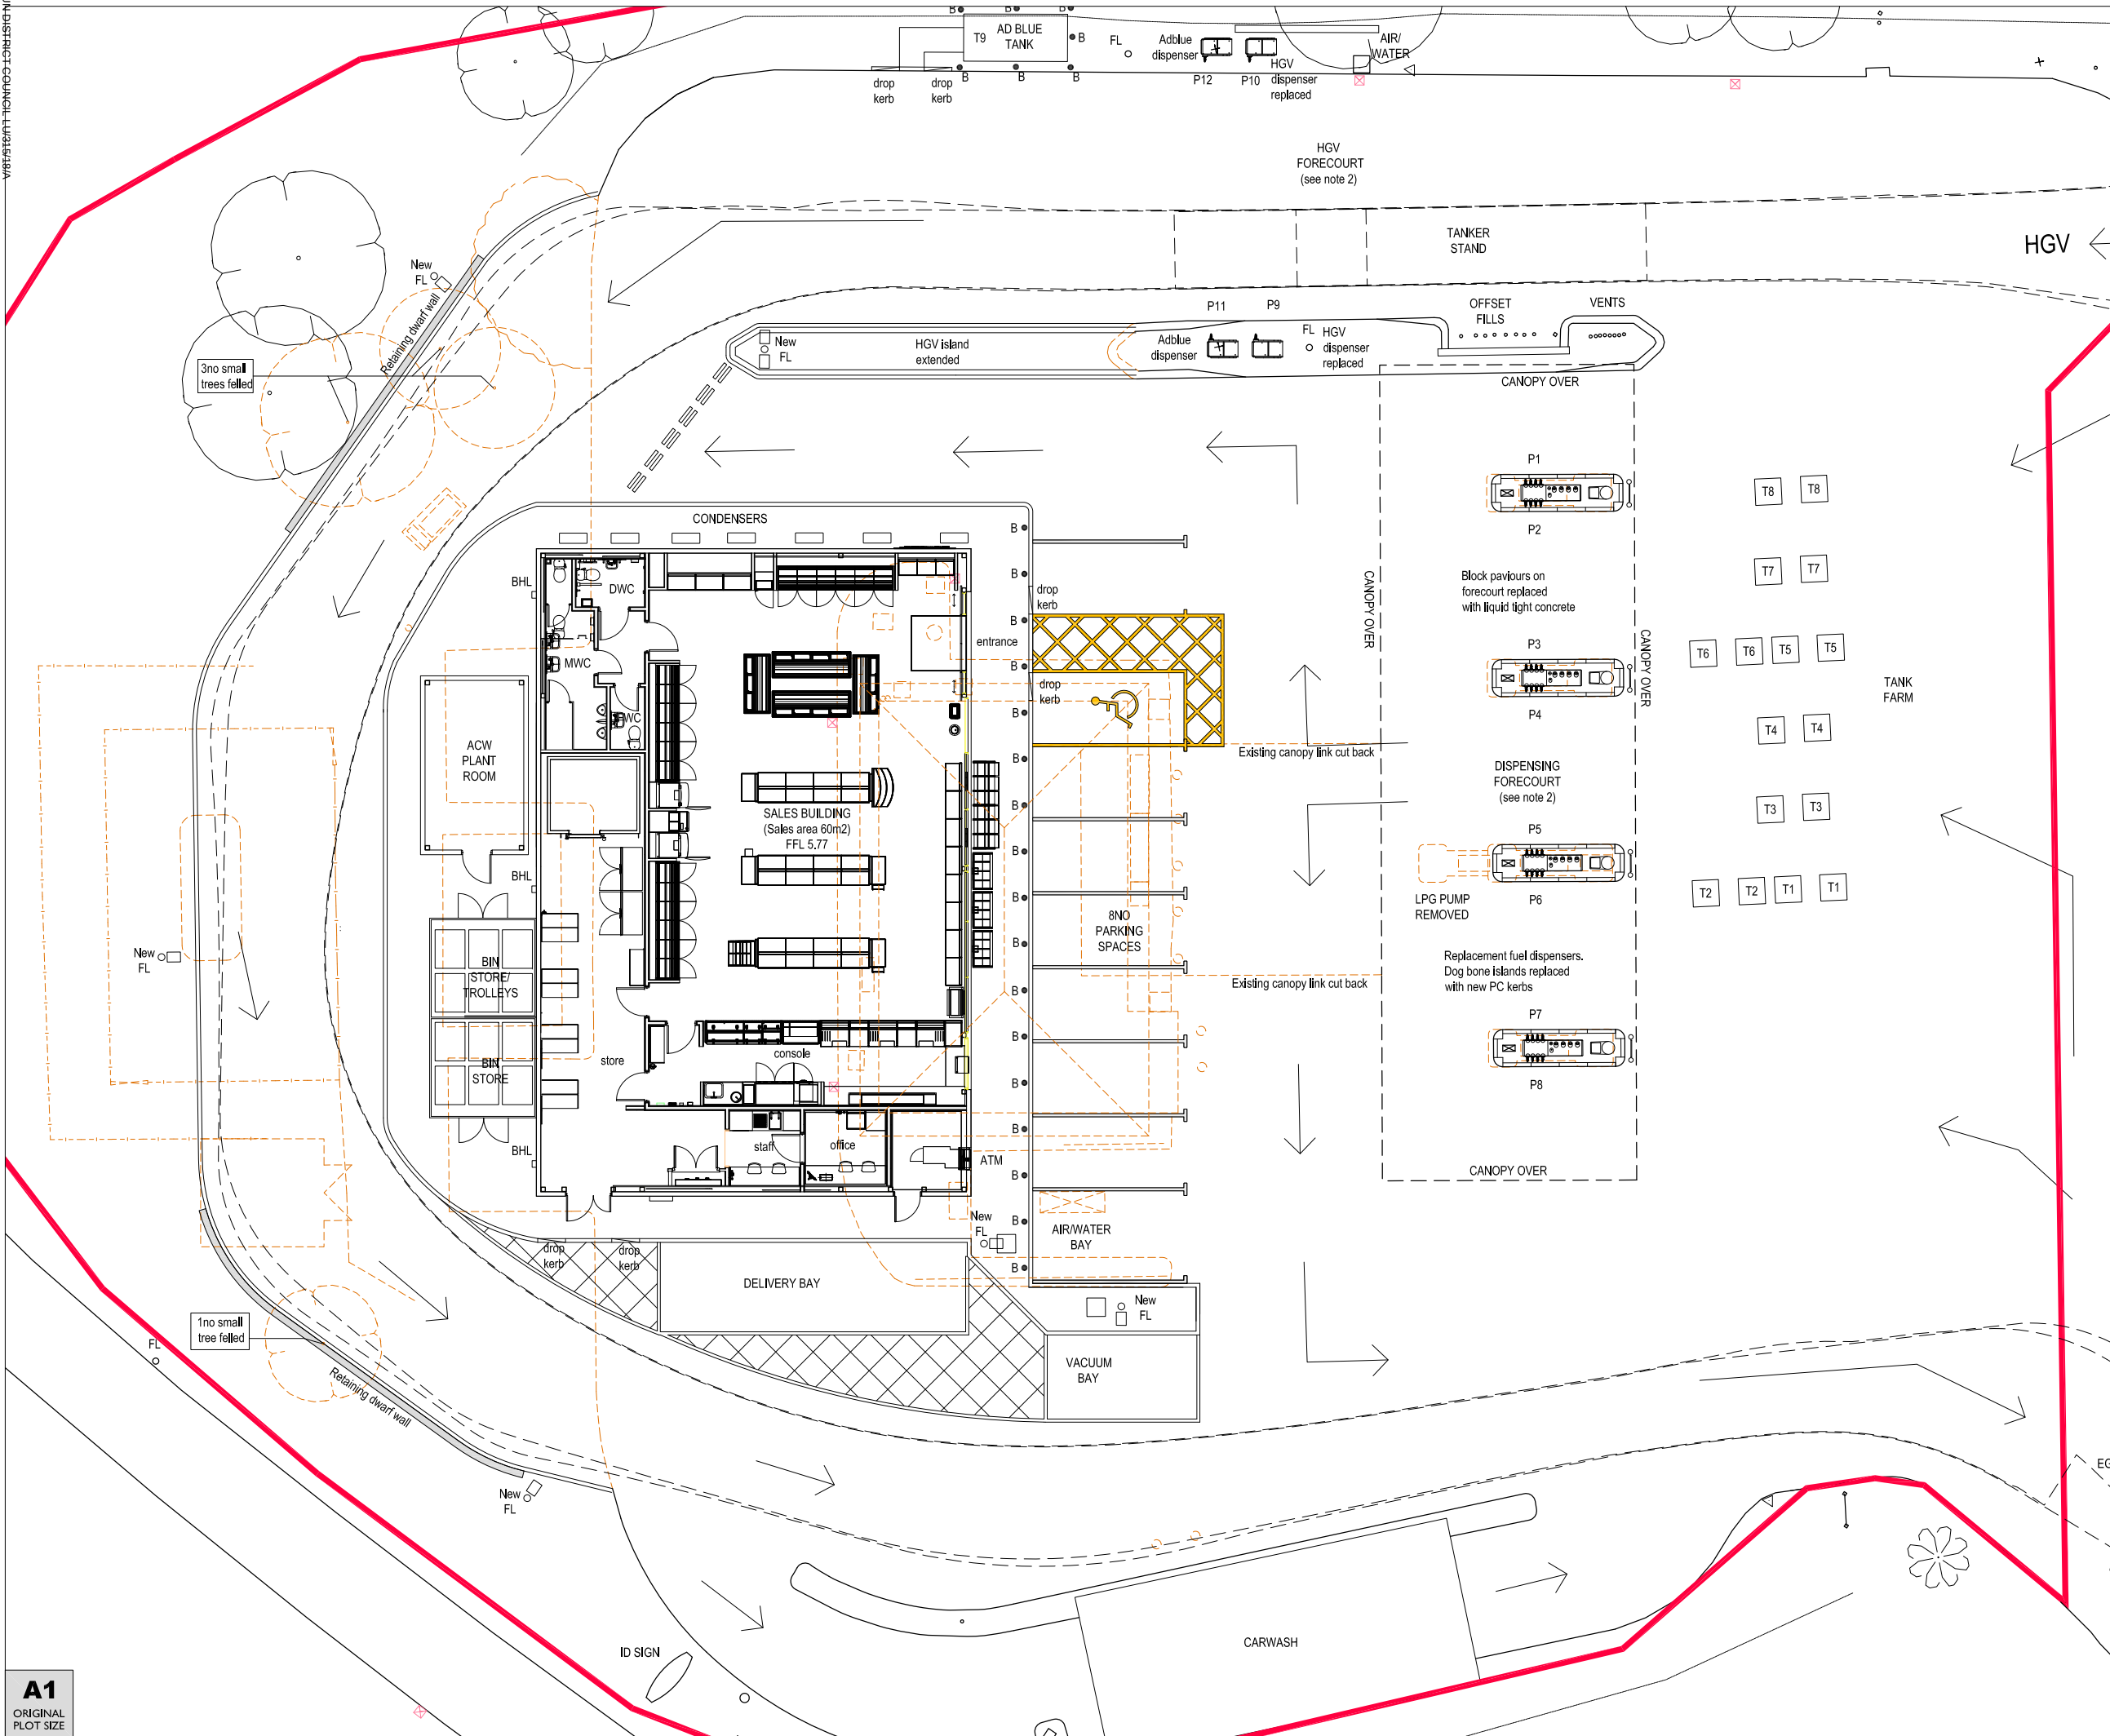

1. THIS PROJECT IS FOR THE REPLACEMENT OF THE SALES BUILDING AND FRONT OF STORE CUSTOMER PARKING ONLY.

2. THERE ARE NO WORKS PROPOSED TO THE FUEL INFRASTRUCTURE

KEY

--- EXISTING DEMOLISHED

NEW BOLLARD

 BOUNDARY LINE

FL = Existing Floodlight

New FL = Floodlight on 5m high pole

BHL = Wall mounted bulkhead light

TANK TO PUMP SCHEDULE									
	tank no	fuel grade	Max working capacity (L)	pump numbers					
				1/2	3/4	5/6	7/8	9/10	
Existing tank	TANK No. 1	VPOWER UNLEADED	12,350						
Existing tank	TANK No. 2	VPOWER DIESEL	12,350		●	●			
Existing tank	TANK No. 3	DIESEL	24,700			●	●		
Existing tank	TANK No. 4	UNLEADED	24,700			●			
Existing tank	TANK No. 5	VPOWER UNLEADED	12,350						
Existing tank	TANK No. 6	VPOWER UNLEADED	12,350	●					
Existing tank	TANK No. 7	UNLEADED	24,700				●		
Existing tank	TANK No. 8	DIESEL	24,700		●				●
Tank removed	TANK No. 9	UNLEADED	5,000						
New tank	TANK No. 9	AD BLUE	5,000						

3NO NEW SUCTION LINES FROM T2 TO P1-2, P3-4 & P7-8
1NO NEW SUCTION LINE FROM T3 TO P5-6



PLANNING DRAWING

ALLAN.B. MATTHEWS A.R.I.B.A.

37 Fore Street.

Bovey Tracey, Devon
TQ13 0AF

Tel : (01626) 833727

Fax : (01626) 833102
enquiries@allanbmattthews.co.uk

REV	DATE		BY

PROJECT: SHELL EASTFIELD
RUSTINGDON BYPASS, WICK,
LITTLEHAMPTON, BN17 6LE

TITLE: SITE LAYOUT PLAN (1:100) as proposed



SHELL UK RETAIL
PO BOX 430
STAINES
TW18 3ZB
UNITED KINGDOM

DRAWN BY:	DH	SCALE :	1:100
-----------	----	---------	-------

DATE :	11.10.2018	PLOT DATE :
--------	------------	-------------

CAD FILE :	E:\ARCHIVE\DRAWINGS\EASTFIELD10019507
------------	---------------------------------------

DWG No:	10019507	PLG - 04	2018
---------	----------	----------	------