


- DESIGN NOTES**
1. SOAKAWAY DESIGN BASED ON 1 IN 100 YR STORM + 30% AND SOIL INFILTRATION RATE OF 2.4 x 10-6m/s AS SOAKAGE TESTING CARRIED OUT BY CONSTRUCTIVE EVALUATION
 2. DRAIN POINTS AND LOCATIONS TO BE CONFIRMED BY ARCHITECT.
 3. CONTRACTOR TO ESTABLISH LOCATIONS OF ALL EXISTING SERVICES PRIOR TO COMMENCING.
 4. EXISTING TREES TO BE PROTECTED WHERE EXCAVATIONS RUN CLOSE.


SPECIFICATION NOTES

1. ALL DRAINAGE SHALL BE CONSTRUCTED AND COMMISSIONED IN ACCORDANCE WITH BS EN 295 & BS EN752, BUILDING REGULATIONS DOC. H AND ANY PARTICULAR REQUIREMENTS OF THE BUILDING CONTROL OFFICER.
2. DRAIN BEDDING IS TO BE PROVIDED AS D200.0, D200.1 AND D200.2 AS SHOWN ON THE DRAINAGE DETAILS SHEETS.
3. 'EFFECTIVE COVER' IS THE MINIMUM DEPTH OF COVER OVER THE PIPE CROWN AT ANY TIME DURING THE CONSTRUCTION PROCESS.
4. ALL CONCRETE PIPEWORK, MANHOLES AND FITTINGS SHALL BE TO BS 5911 (ALL RELEVANT PARTS). ALL CONCRETE PIPEWORK TO BE TO HIGH STRENGTH
5. WHERE CONNECTIONS ARE TO BE MADE TO EXISTING MANHOLES/SEWERS, INVERT LEVELS, PIPE SIZES & ORIENTATION SHALL BE CHECKED PRIOR TO THE COMMENCEMENT OF THE WORKS AND ANY VARIANCE REPORTED TO THE ENGINEER IMMEDIATELY.
6. WHERE PIPELINES CROSS, EACH IS TO BE SURROUNDED WITH GRADE ST4 MASS CONCRETE FOR A DISTANCE NOT LESS THAN 1m CENTRED ON THE CROSSING POINT. LENGTH OF SURROUND TO BE EXTENDED AS NECESSARY TO WITHIN 150mm OF THE NEXT NEAREST FLEXIBLE JOINTS.
7. THE CONTRACTOR IS TO ENSURE THAT PROTECTIVE MEASURES ARE TAKEN TO ENSURE THAT DRAINAGE PIPEWORK AND FITTINGS ARE NOT DAMAGED BY SITE TRAFFIC PRIOR TO OVERSITE FILLING OPERATIONS BEING COMPLETED AROUND BUILDINGS.
8. ALL PRIVATE DRAINAGE PIPEWORK SHALL BE PVCu. ALL ADOPTED DRAINAGE TO BE VC. ALL UNDERBUILDING DRAINS TO BE LAID AT A GRADIENT OF 1:40
9. WHERE DRAINS PASS THROUGH FOUNDATIONS OR CONNECT TO MANHOLES, FLEXIBLE PIPE JOINTS ARE TO PROVIDED WITHIN 150mm OF THE FACE OF THE STRUCTURE AND WITHIN A FURTHER 600mm TO FORM A ROCKER PIPE.
10. WHERE PIPES PASS THROUGH SCREEN WALLS, FOOTINGS OR RETAINING WALLS, LINTELS ARE TO BE PROVIDED.
11. WHERE PIPELINES PASS WITHIN 1m OF BUILDINGS OR WALLS THE FOUNDATIONS ARE TO BE TAKEN DOWN BELOW THE BOTTOM OF THE TRENCH
12. 450mm DIA. INSPECTION CHAMBERS (FIC/SIC) MAY BE USED:
 - WITH 350mm REDUCED OPENING WHERE THE DEPTH FROM COVER TO INVERT EXCEEDS 1000mm.
 - 300mm DIA. POLYPROPYLENE ACCESS CHAMBERS (FAC/SAC) MAY BE USED
 - WHERE THE DEPTH FROM COVER TO INVERT DOES NOT EXCEED 600mm AND WHERE THE PIPE SIZE DOES NOT EXCEED 100mm DIA.
13. STEEL COVERS WITHIN PROPERTY BOUNDARIES SHALL BE:
 - (UNLESS NOTED ON DRAWING OR MANHOLE SCHEDULE)
 - ON PRIVATE DRIVEWAYS: FACTA GRADE B (BS EN ISO 1461:1999)
 - ON PRIVATE PATHWAYS, VERGES OR ON GARDENS: FACTA GRADE A (BS EN ISO 1461:1999)
- DUCTILE IRON COVERS OUTSIDE PROPERTY BOUNDARIES SHALL BE:
 - (UNLESS NOTED ON DRAWING OR MANHOLE SCHEDULE)
 - ON ACCESS ROADS AND CAR PARKS: GRADE D400 (BS EN 124:1994)
 - ON SHARED PATHWAYS, VERGES: GRADE A15 (BS EN 124:1994)

14. COVER LEVELS SHOWN 'CL' AND INVERT LEVELS SHOWN 'IL' ARE IN METRES ABOVE ORDNANCE DATUM.
15. ALL DRAINS TO BE 100mm DIAMETER UNLESS NOTED OTHERWISE
16. ALL DRAINS MARKED 'FWS' OR 'SWS' ARE PROPOSED ADOPTED SEWERS AND ARE TO BE CONSTRUCTED IN ACCORDANCE WITH 'SEWERS FOR ADOPTION, 7TH EDITION'

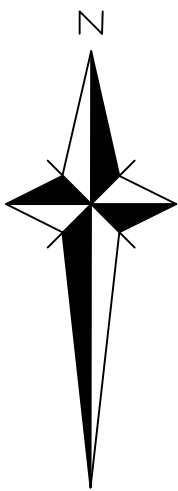

52-67 GREENFIELDS

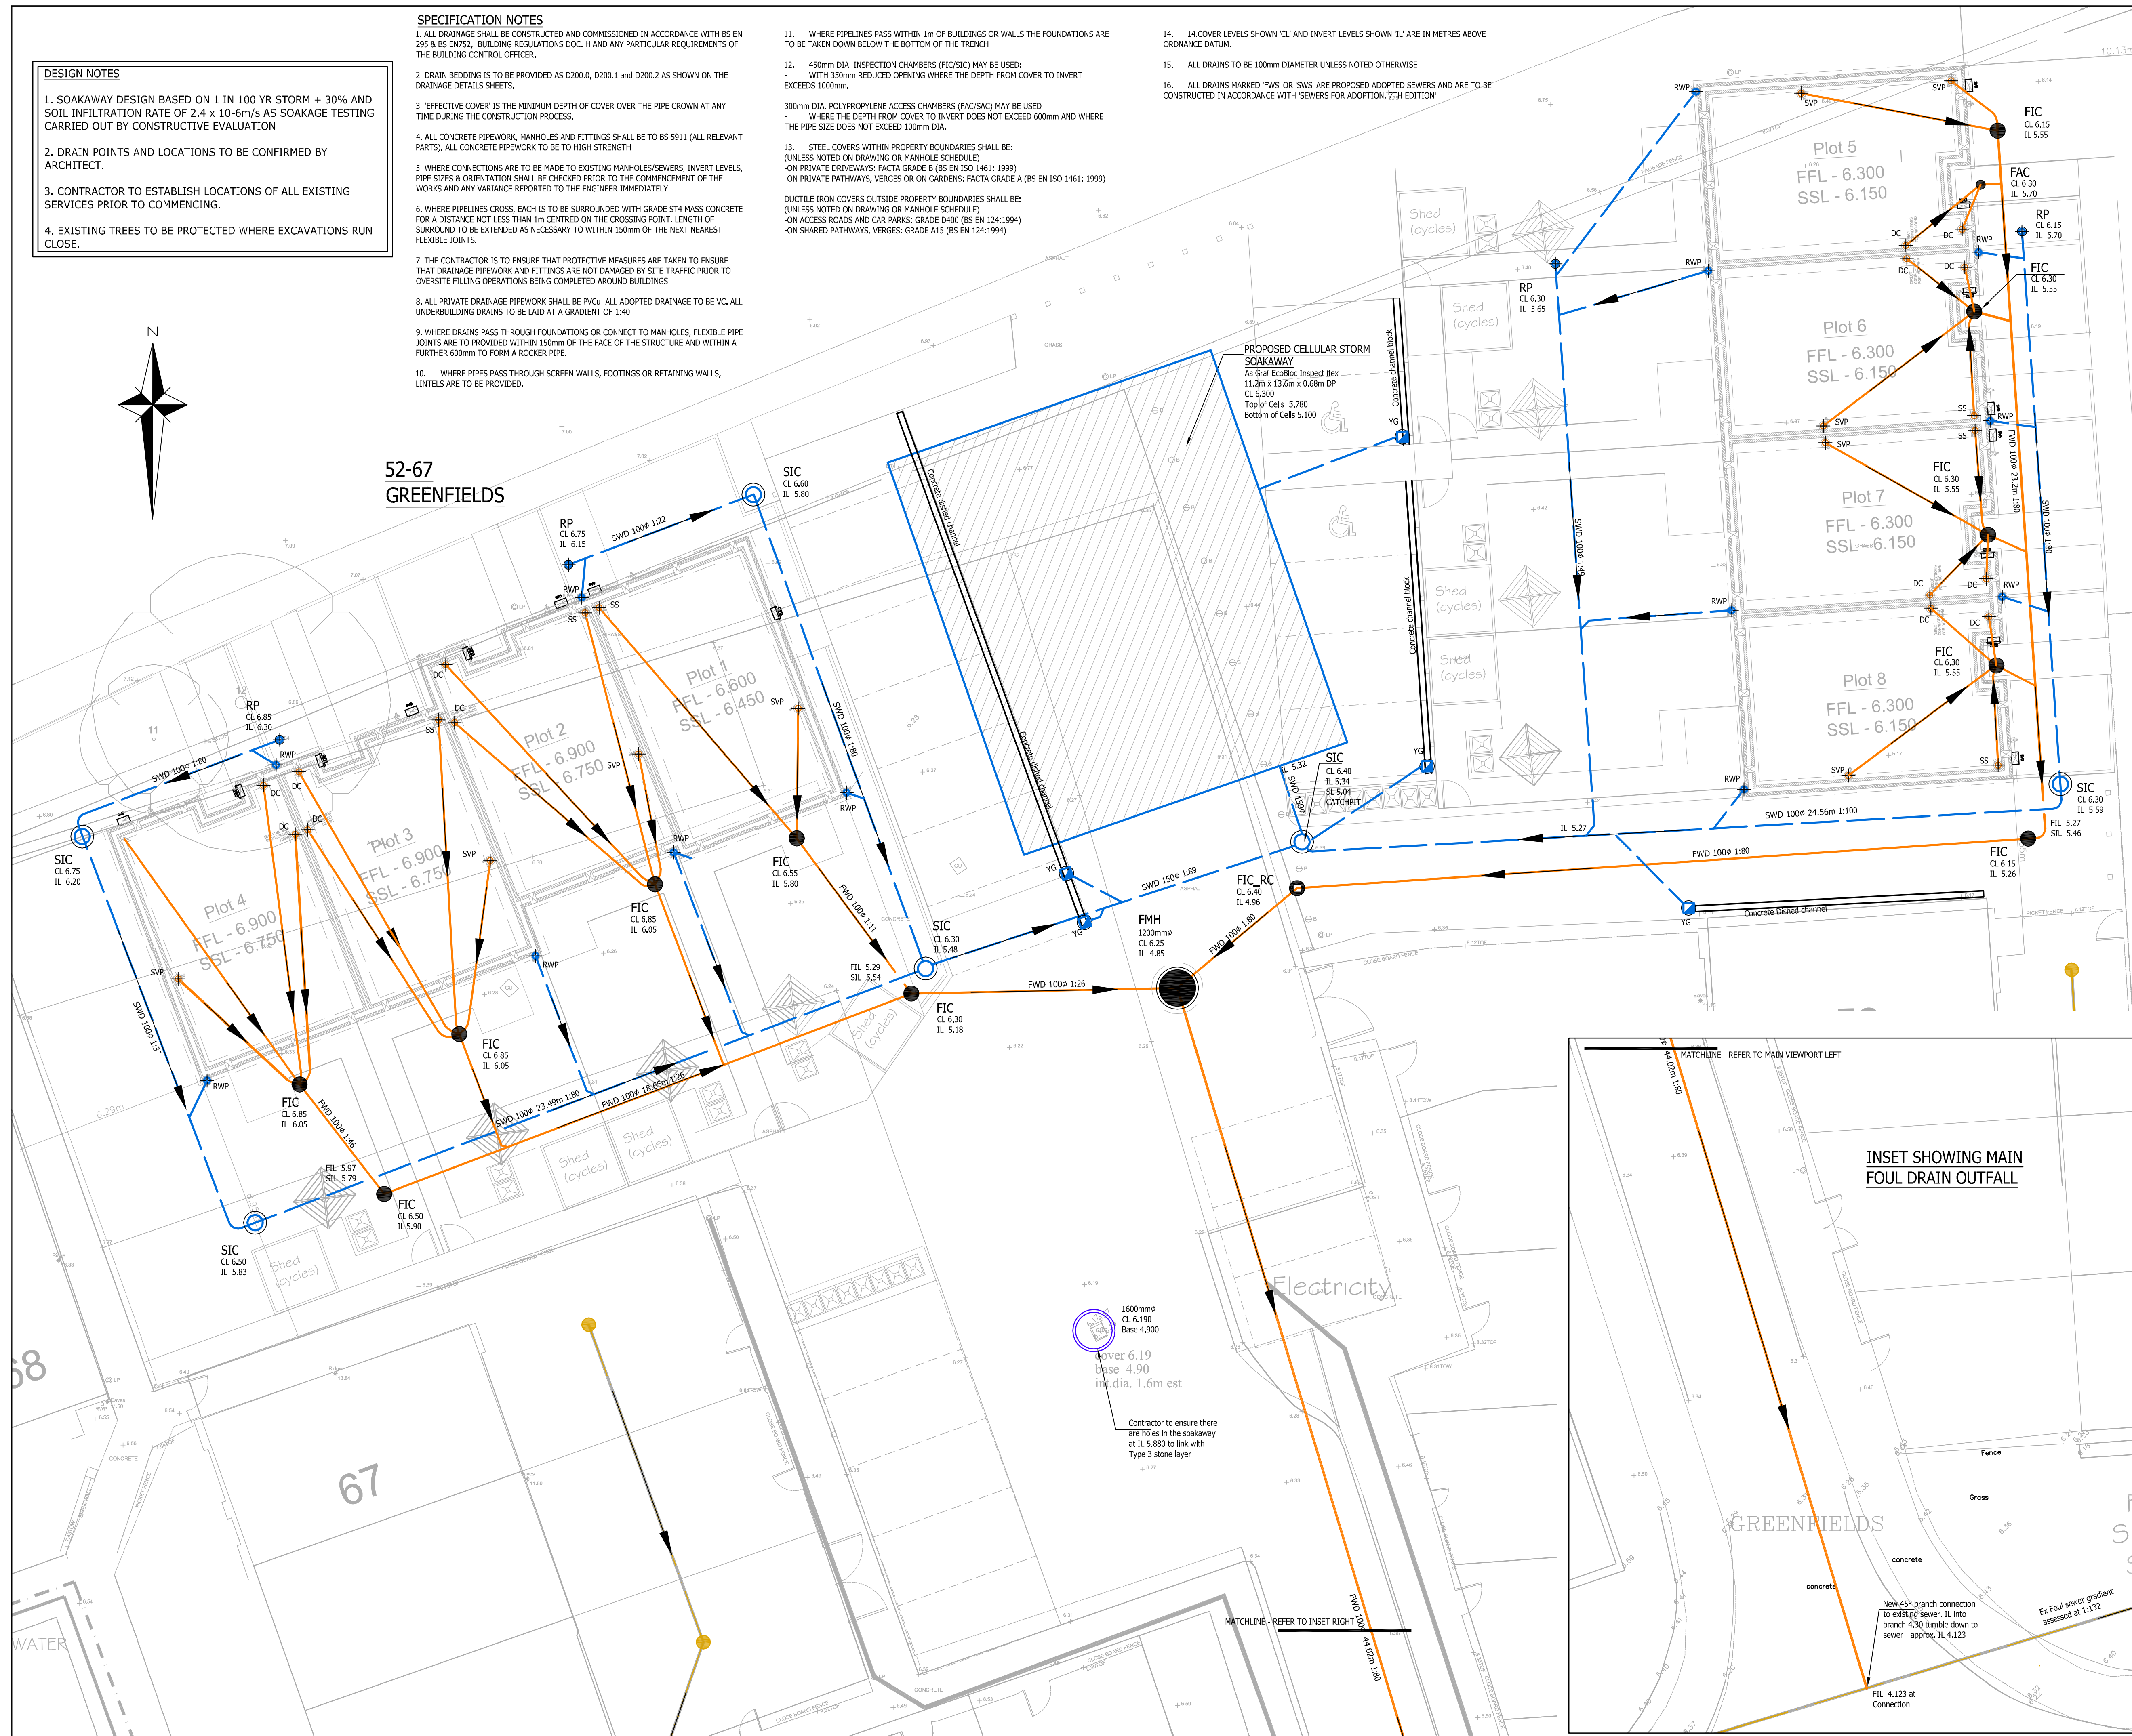


1600mmø
CL 6.190
Base 4.900
in dia. 1.6m cst

Contractor to ensure there are no holes in the soakaway at IL 5.880 to link with Type 3 stone layer

MATCHLINE - REFER TO INSET RIGHT

INSET SHOWING MAIN FOUL DRAIN OUTFALL

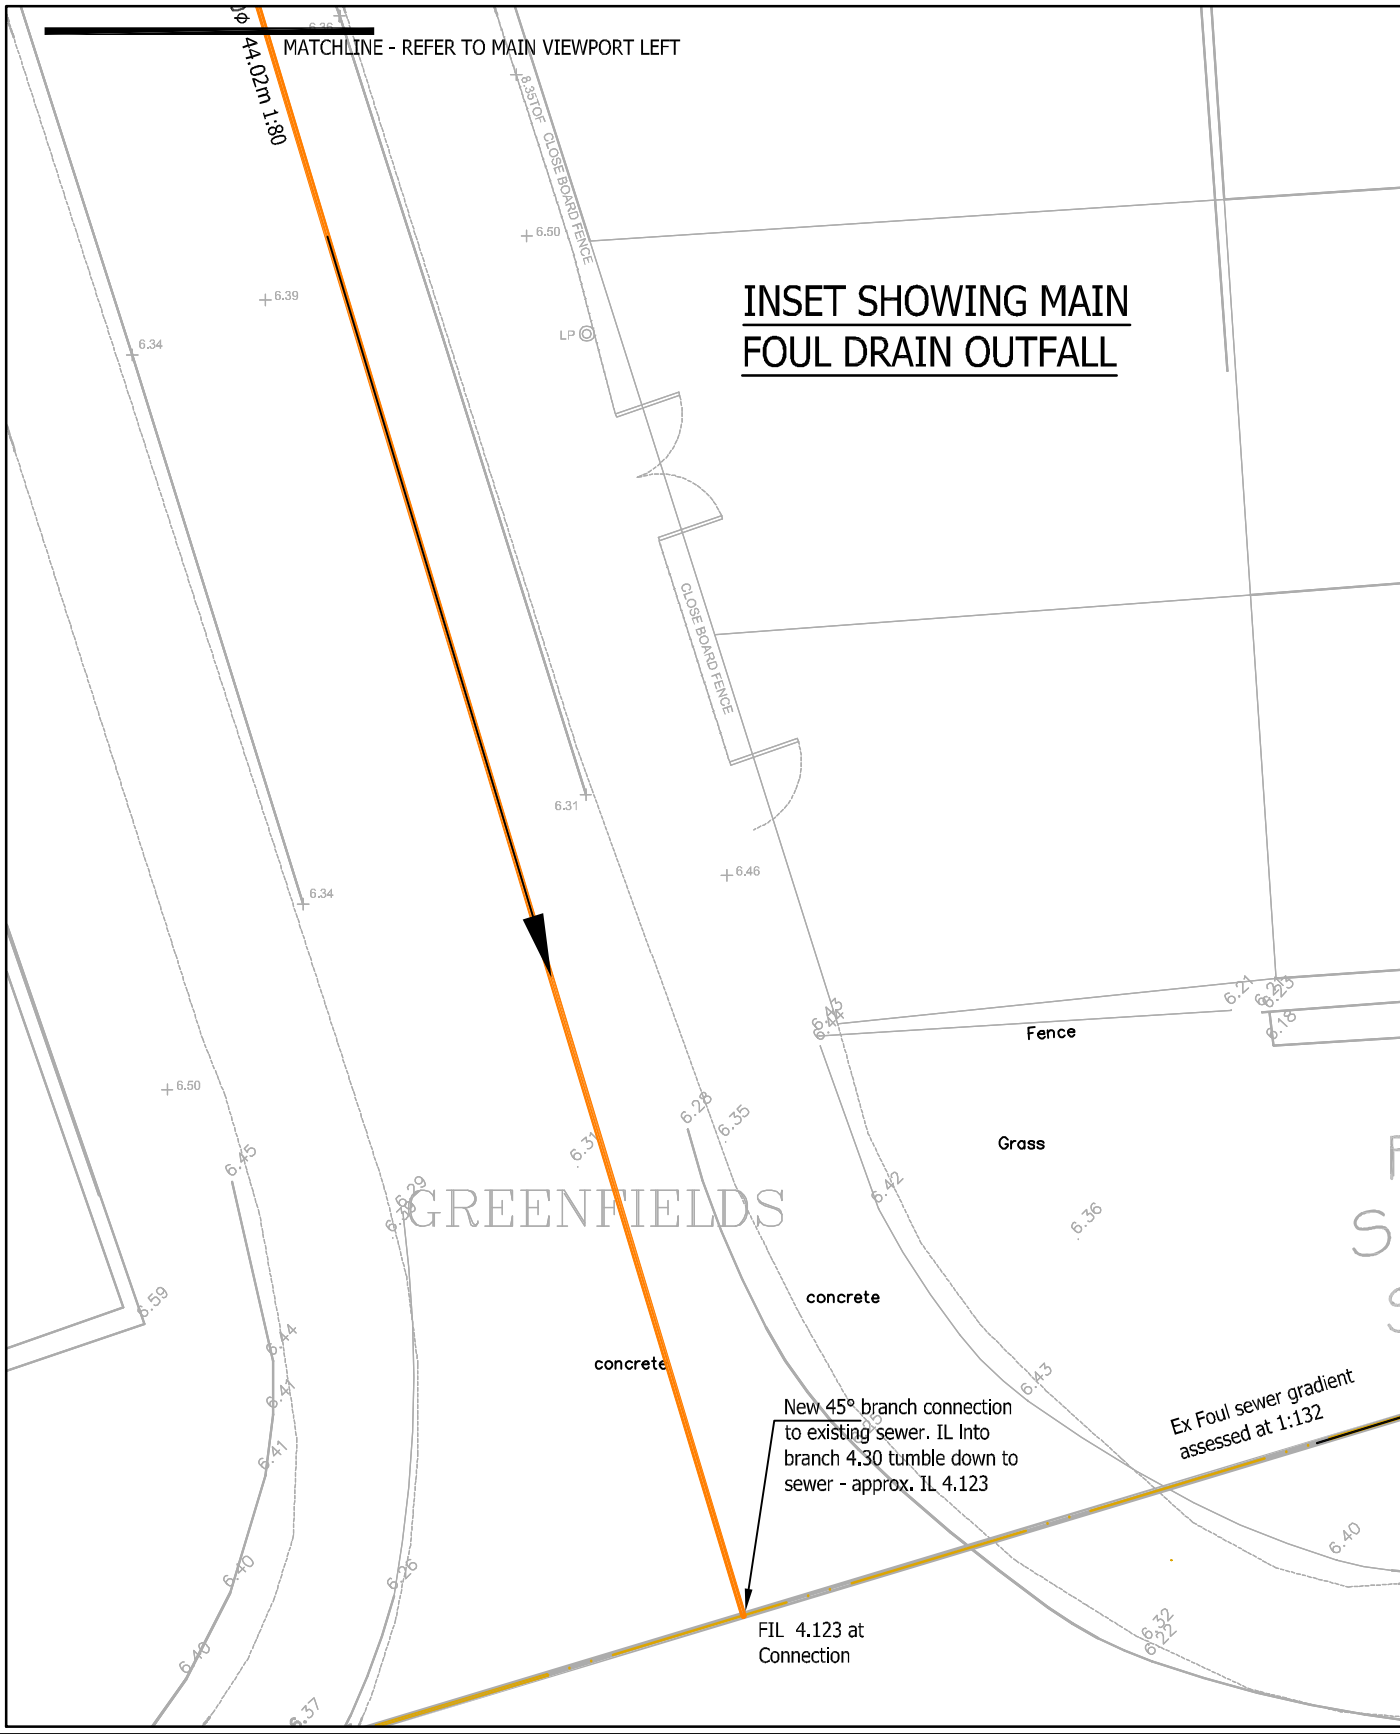

GENERAL NOTES:

1. All dimensions to be checked on site. All details and dimensions relating to sub-contractors or suppliers work must be checked and agreed between the sub-contractor or supplier and the main contractor.
2. This drawing is to be read in conjunction with all relevant architects, services and engineers drawings and specifications.
3. The location, size, depth and identification of existing services that may be shown or referred to on this drawing have been assessed from non intrusive observations, record drawings or the like. The contractor shall safely carry out intrusive investigations, trial holes or soundings prior to commencing work to satisfy himself that it is safe to proceed and that the assessments are accurate. Any discrepancies shall be notified to gap prior to works commencing.
4. Tender or billing drawings shall not be used for construction or the ordering of materials.
5. Do not scale. All dimensions and levels to be site confirmed.
6. Copyright : This drawing must not be copied, amended nor reproduced without the prior written agreement of gsp.

KEY

- Private surface water drain
- Private foul drain
- FIC
● Foul Plastic Inspection Chamber - D202.6
- SIC
● Surface Water Plastic Inspection Chamber - D202.6
- SAC
● 300mm diameter Surface Water Access Chamber - D202.18
- FAC
● 300mm diameter Foul Water Access Chamber - D202.18
- FMH
● Private Foul Manhole
- SWMH
● Private Surface Water Manhole
- SVP
● Foul drain point for D207.0
- RWP
● SW Drain point for RWP D203.5
- Drainage channel
- SVP
● SOIL VENT PIPE
- RWP
● RAINWATER PIPE

PREFIXES TO DRAWING NUMBERS SHALL SIGNIFY THE FOLLOWING

P	= PRELIMINARY	SHALL NOT BE USED FOR CONTRACT OR CONSTRUCTION PURPOSES.
T	= TENDER	SHALL NOT BE USED FOR CONSTRUCTION PURPOSES.
C	= CONSTRUCTION	THESE ARE THE ONLY DRAWINGS THAT SHALL BE USED FOR CONSTRUCTION PURPOSES.
R	= RECORD	RECORD OF ACTUAL COMPLETED WORK.

REV	DATE	DESCRIPTION	BY	CHK	APP
-	24.10.16	INITIAL ISSUE	JW	MR	MR

Gyours Self
CONSULTING ENGINEERS

10 THE GARDENS, BROADCUT, FAREHAM,
HAMPSHIRE PO16 8SS
TELEPHONE 01329 822308 - FACSIMILE 01329 232258
E-MAIL: mail@gpsfareham.co.uk
WEBSITE: www.gyoursself.com
Also at Hove and St Albans

CLIENT
ARUN DISTRICT COUNCIL

ARCHITECT
MH ARCHITECTS

JOB TITLE
**ARUN GARAGES
WICK ESTATE, LITTLEHAMPTON
(52-67 Greenfields)**

DRAWING TITLE
**DRAINAGE LAYOUT
SHEET 3**

DRAWN	JW	ENGINEER	MR	CHECKED	APP
DATE	OCT 2016	SCALE	@ A1	1:100	
JOB No.	F16943	STATUS	P	DRAWING No.	1063
REV					1

PRELIMINARY