


L4/43/11


ATTENUATOR PERFORMANCE TABLE

FREQUENCY Hz	125	250	500	1000	2000	4000
FAN NOISE dBA	58.5	64.5	66.5	71.5	70.5	67.5
ATTENUATOR PERFORMANCE	7.5	13.5	31.5	37.5	42.0	29.5
DISCHARGE NOISE dBA	51.0	51.0	35.0	34.0	28.5	38.0
NC 45 REQUIREMENTS	61.0	55.0	45.0	42.0	40.0	38.0


ATTENUATOR SELECTED, 1200 LONG PODDED.

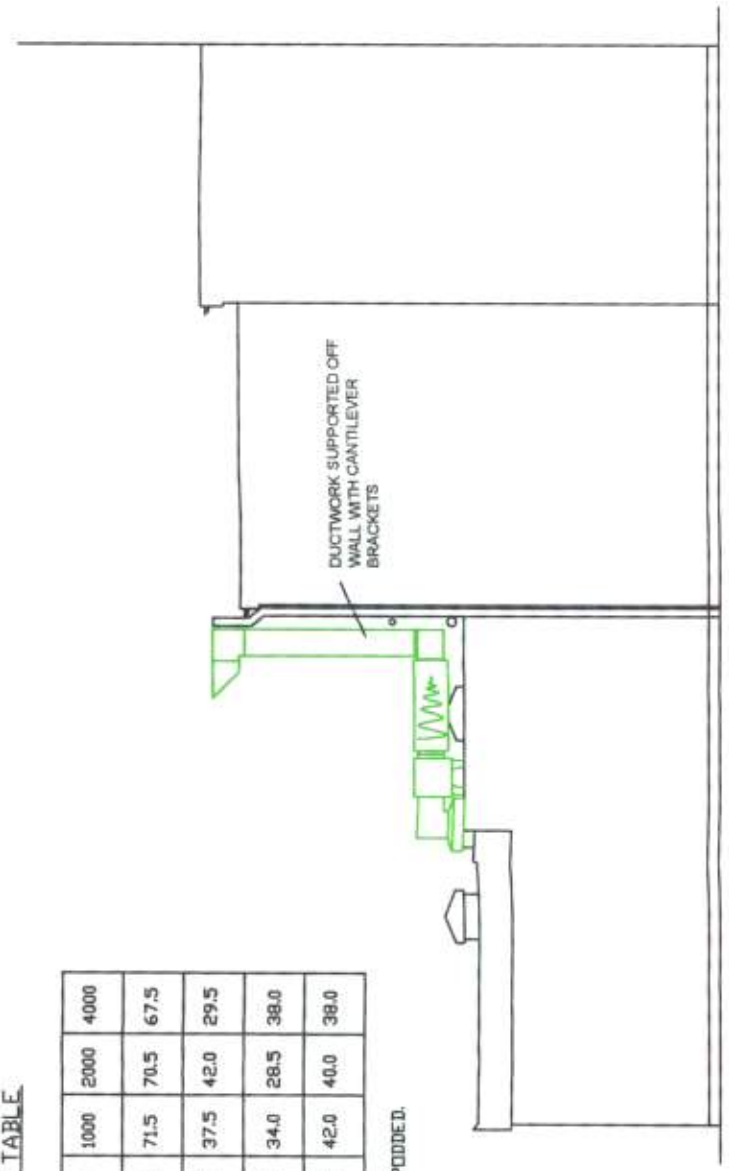


Rear Elevation

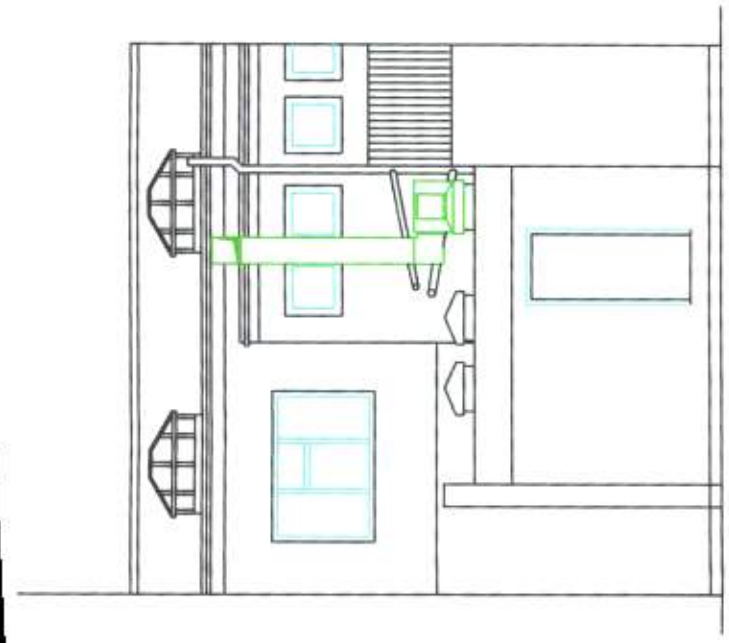


Side Elevation

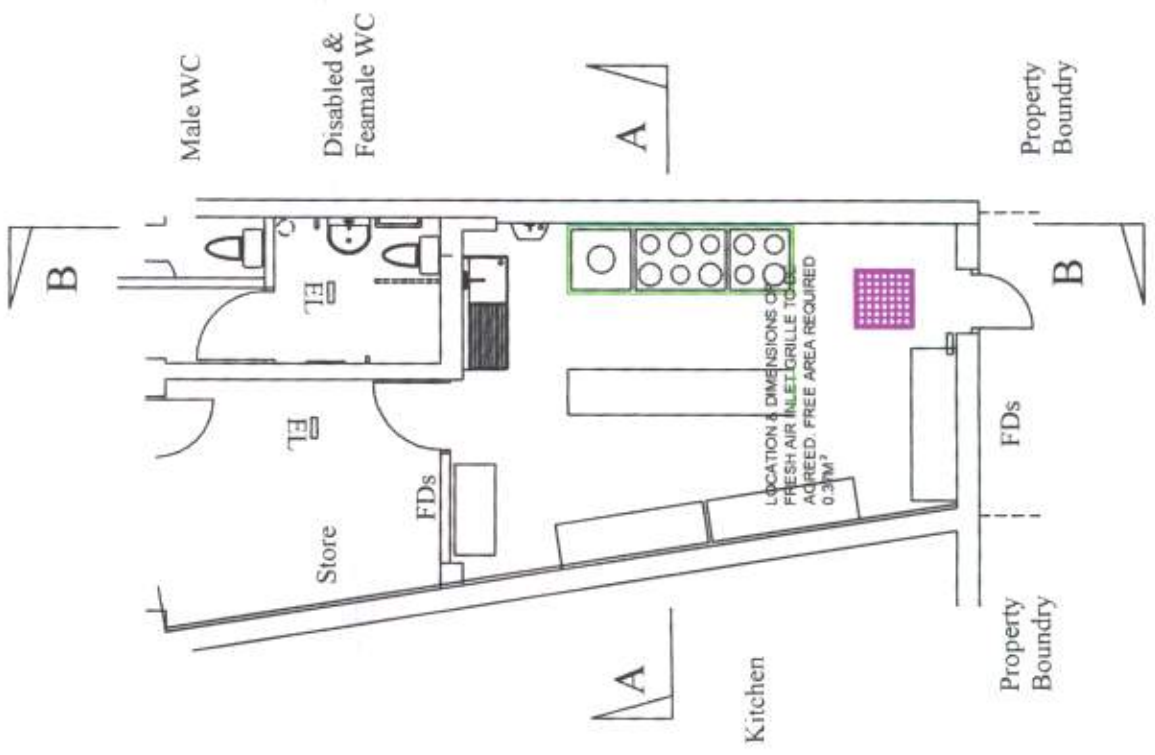

Section A - A nts

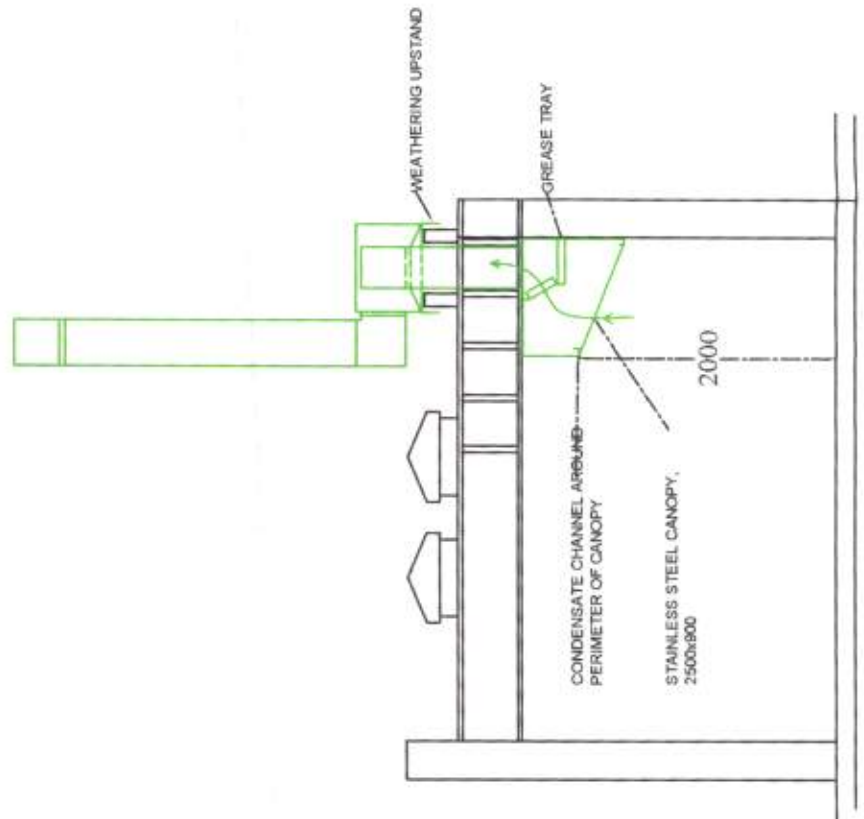

Section B - B nts

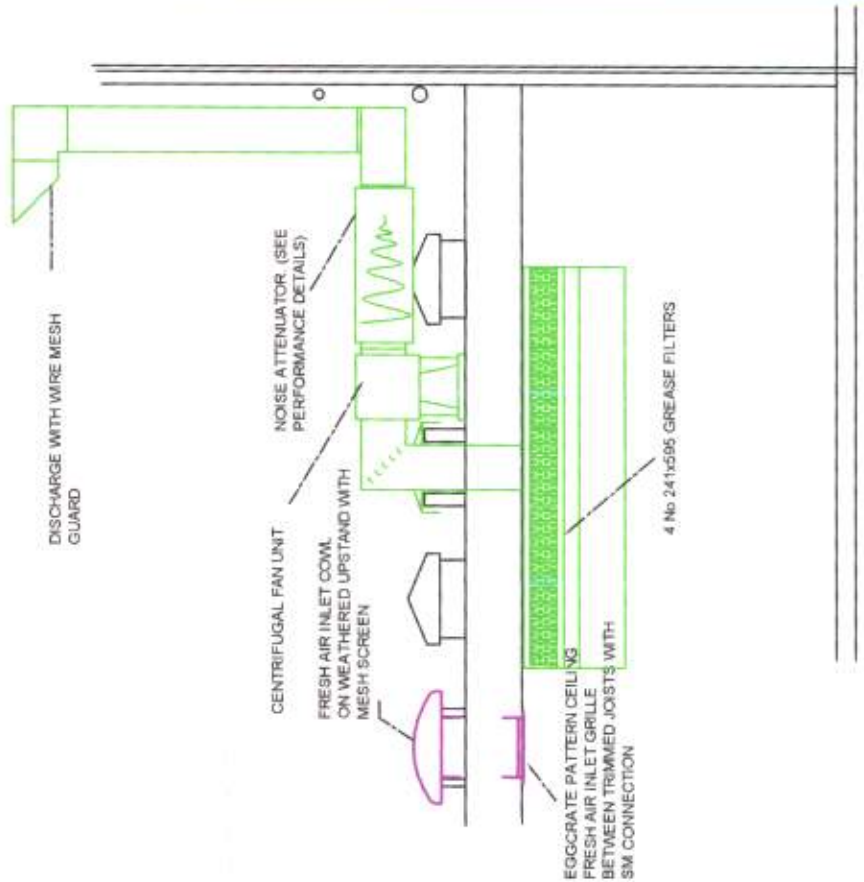

GAS SAFETY DEVICE
AN AUTOMATIC GAS SAFETY SHUT OFF SYSTEM TO BE SUPPLIED AND INSTALLED BY OTHERS. UNIT TO COMPRISE GAS SOLENOID VALVE, AIR FLOW SENSORS, CONTROL PANEL WITH LCD DISPLAY AND EMERGENCY GAS SHUT OFF BUTTON AND PREFERABLY CO. MONITORING.
SUGGESTED UNIT MEDEH VGPS-K OR VGPS-K-CO.

**BEACH ROAD
LITTLEHAMPTON
INDIAN TANDOORI
RESTAURANT**

**HARRISON
INDUSTRIAL
Ltd**
RODNEY ROAD
FRATTON INDUSTRIAL EST
PORTSMOUTH PO4 8SY
Tel: 023 92751687
Fax: 023 92818564
e-mail: admin@harrisonindustrial.co.uk

**KITCHEN VENTILATION
PROPOSALS**

SCALE 1:50 DATE Jan 2011
DRAWN CR CHECKED
DRAWING No 4515