


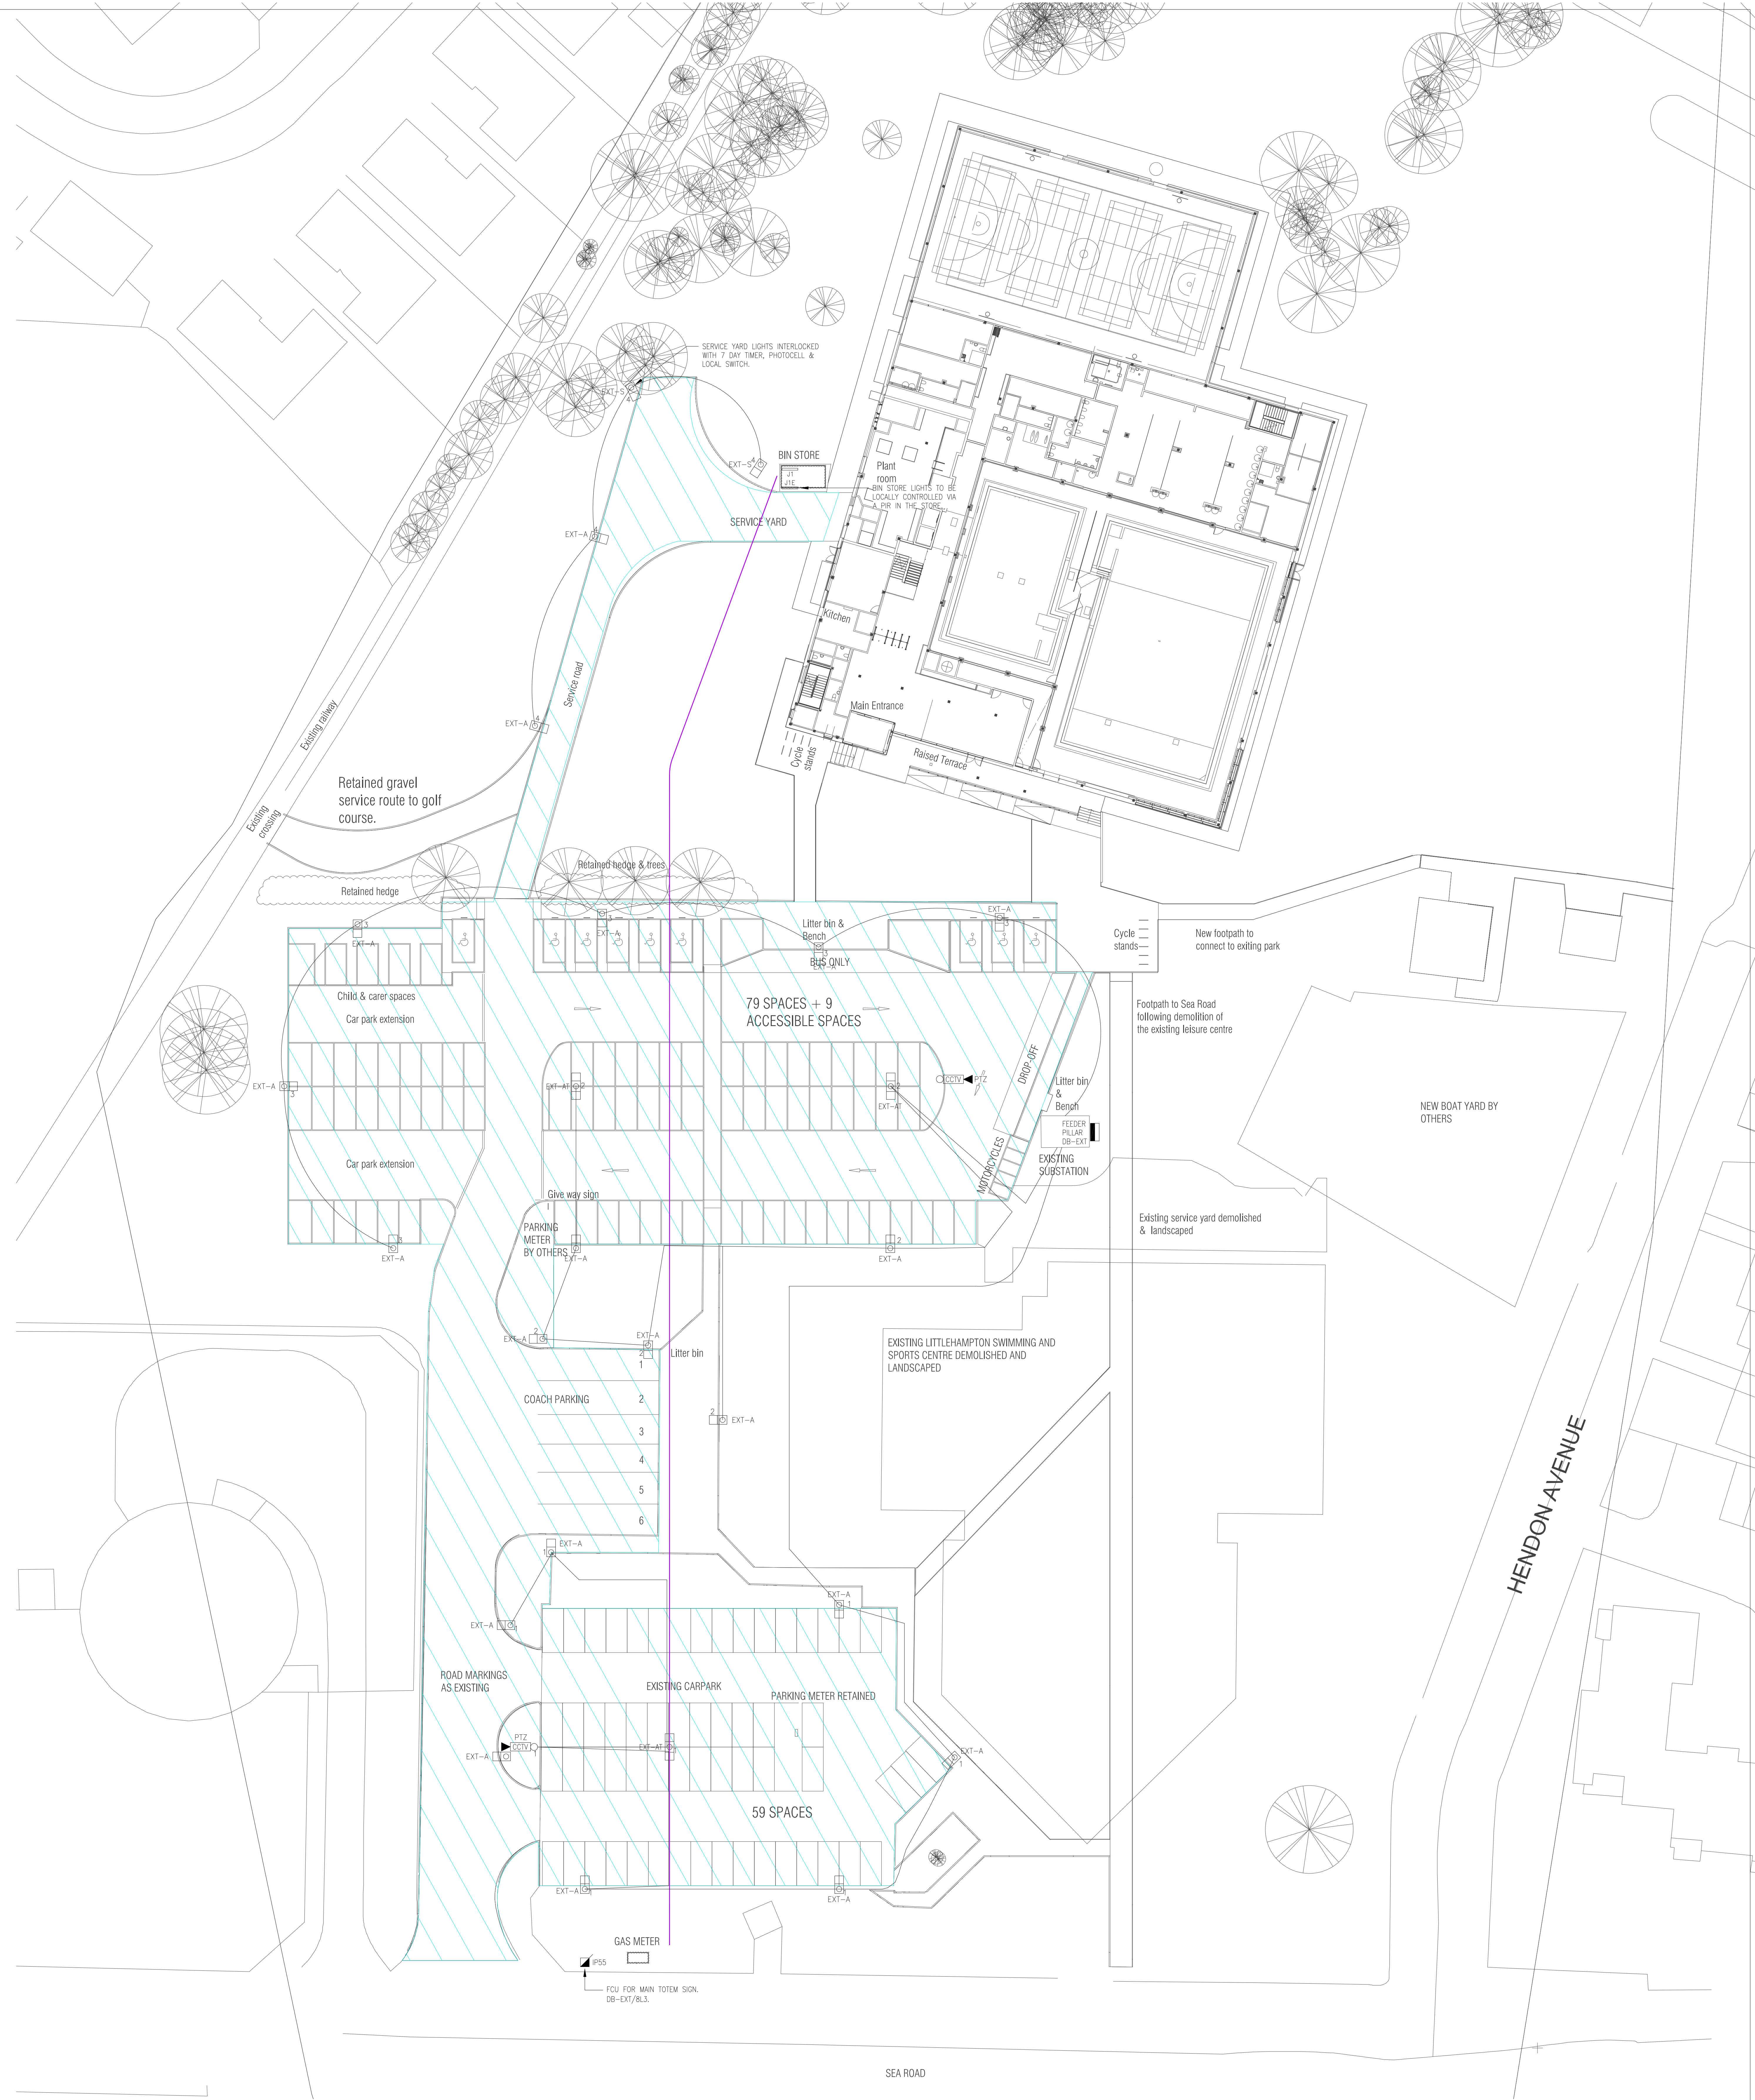

SYMBOL LEGEND & DESCRIPTION	
CCTV	EXTERNAL IP66 CCTV CAMERA
PTZ	PAN/TILT/ZOOM CAMERA MOUNTED ON 6M HIGH CCTV COLUMN
	CCTV COVERAGE ZONES, NOTE 3
EXT-A	COLUMN MOUNTED SINGLE HEAD LUMINAIRE, REFER TO M&E SPECIFICATION FOR FURTHER DETAILS.
EXT-AT	COLUMN MOUNTED TWIN HEAD LUMINAIRE, REFER TO M&E SPECIFICATION FOR FURTHER DETAILS.
EXT-B	WALL MOUNTED BULKHEAD LUMINAIRE
EXT-C	LED BOLLARD
OD	DOWNLIGHTER, IP66, MOUNTED IN SOFFIT
EXT-S	COLUMN MOUNTED SINGLE HEAD LUMINAIRE, REFER TO M&E SPECIFICATION FOR FURTHER DETAILS.
EXT-EXST1	EXISTING 8M LIGHTING COLUMN WITH SINGLE LANTERN.
EXT-EXST2	EXISTING 8M LIGHTING COLUMN WITH TWIN LANTERN.
	EXTERNAL FEEDER PILLAR (REFER TO M&E SPECIFICATION V40/500/0.031 FOR FEEDER PILLAR SPECIFICATION)
	MANHOLE / DRAW PIT
	FUSED CONNECTION UNIT, IP55.
	IP RATED THREE PHASE ISOLATOR.
	UNDERGROUND DUCTS FOR SERVICES

RD	RECORD DRAWING	04.03.19	RW/PV
REV	DESCRIPTION	DATE	BY

Client:

Maybourne & Russell
MECHANICAL & ELECTRICAL CONTRACTORS
Unit 5, Leigh Green Ind. Estate, Appledore Road, Tenterden, Kent TN30 7DE
Telephone: 01580 763264 Fax: 01580 765644
Email: enquiries@mandrgroup.com Web: www.maybourneandrussell.co.uk

This document is supplied in strict confidence and must not be lent, reproduced or disclosed to any third party without the prior consent of Maybourne & Russell.	
---	--

Drawing Title: EXTERNAL LIGHTING AND CCTV LAYOUT			
Project: LITTLEHAMPTON LEISURE CENTRE			
Drawn: LC	Date: 04.03.19	Scale: 1:50 @ A0	
Checked: RW	Approved: RW	Date: 04.03.19	
Drawing No: E531-M&R-V4-00-DR-E-0631			Revision: RD