


EXISTING GROUND FLOOR PLAN:

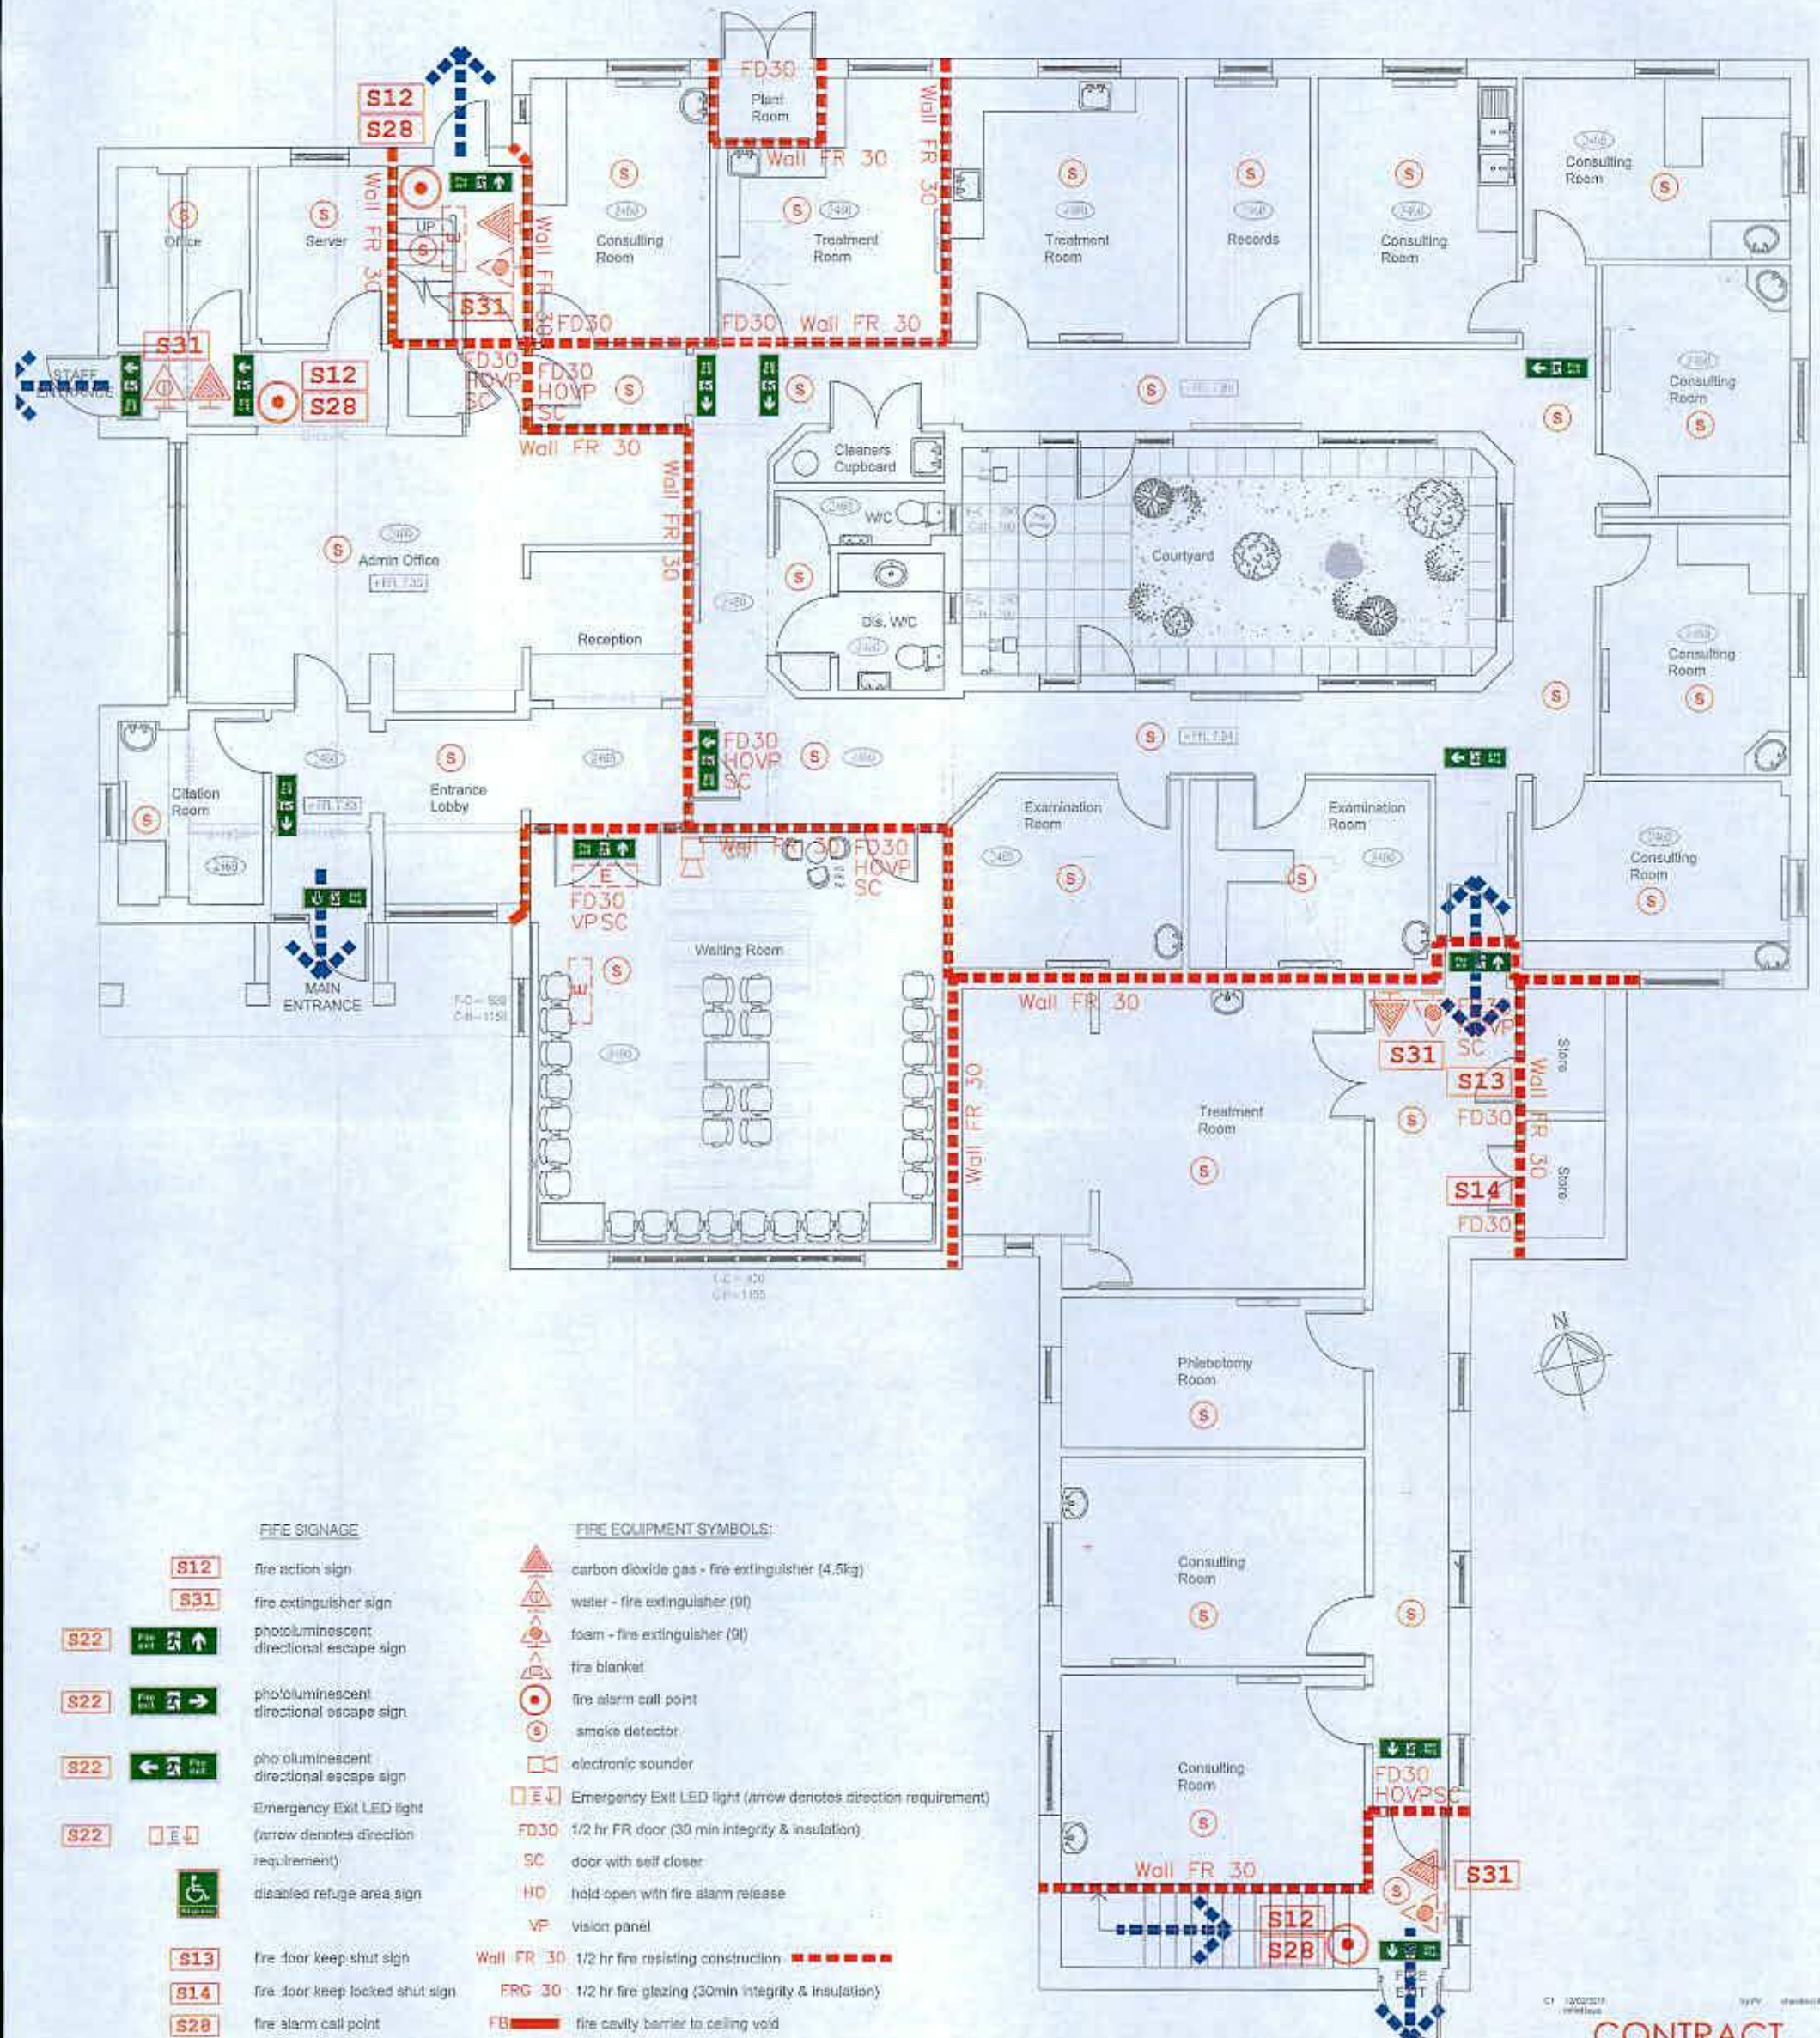

FIRE SIGNAGE

- S12** fire action sign
- S31** fire extinguisher sign
- S22** photoluminescent directional escape sign
- S22** photoluminescent directional escape sign
- S22** photoluminescent directional escape sign
- S22** photoluminescent directional escape sign
- S22** Emergency Exit LED light (arrow denotes direction requirement)
- S22** disabled refuge area sign
- S13** fire door keep shut sign
- S14** fire door keep locked shut sign
- S28** fire alarm call point

FIRE EQUIPMENT SYMBOLS:

- carbon dioxide gas - fire extinguisher (4.5kg)
- water - fire extinguisher (9l)
- foam - fire extinguisher (9l)
- fire blanket
- fire alarm call point
- smoke detector
- electronic sounder
- Emergency Exit LED light (arrow denotes direction requirement)
- FD30 1/2 hr FR door (30 min integrity & insulation)
- SC door with self closer
- HO hold open with fire alarm release
- VP vision panel
- Wall FR 30 1/2 hr fire resisting construction
- FRG 30 1/2 hr fire glazing (30min integrity & insulation)
- FB fire cavity barrier to ceiling void

C1 12/02/2019
revised
by PV
checked by

CONTRACT
studio four
architects ltd

Talpaia Road, Warbridge East, Romsey SO51 0HT
t: 01794 511255
info@studiofourarchitects.co.uk
www.studiofourarchitects.co.uk

client: Park Surgery
Littlehampton
project: New Consulting Rooms &
Waiting Area
date: Existing Ground Floor Plan

date	scale	drawn	checked	approved
Feb 19	1:50	AI	PV	PA
39020	100			C1

©: 39020_Park Surgery Layouts