


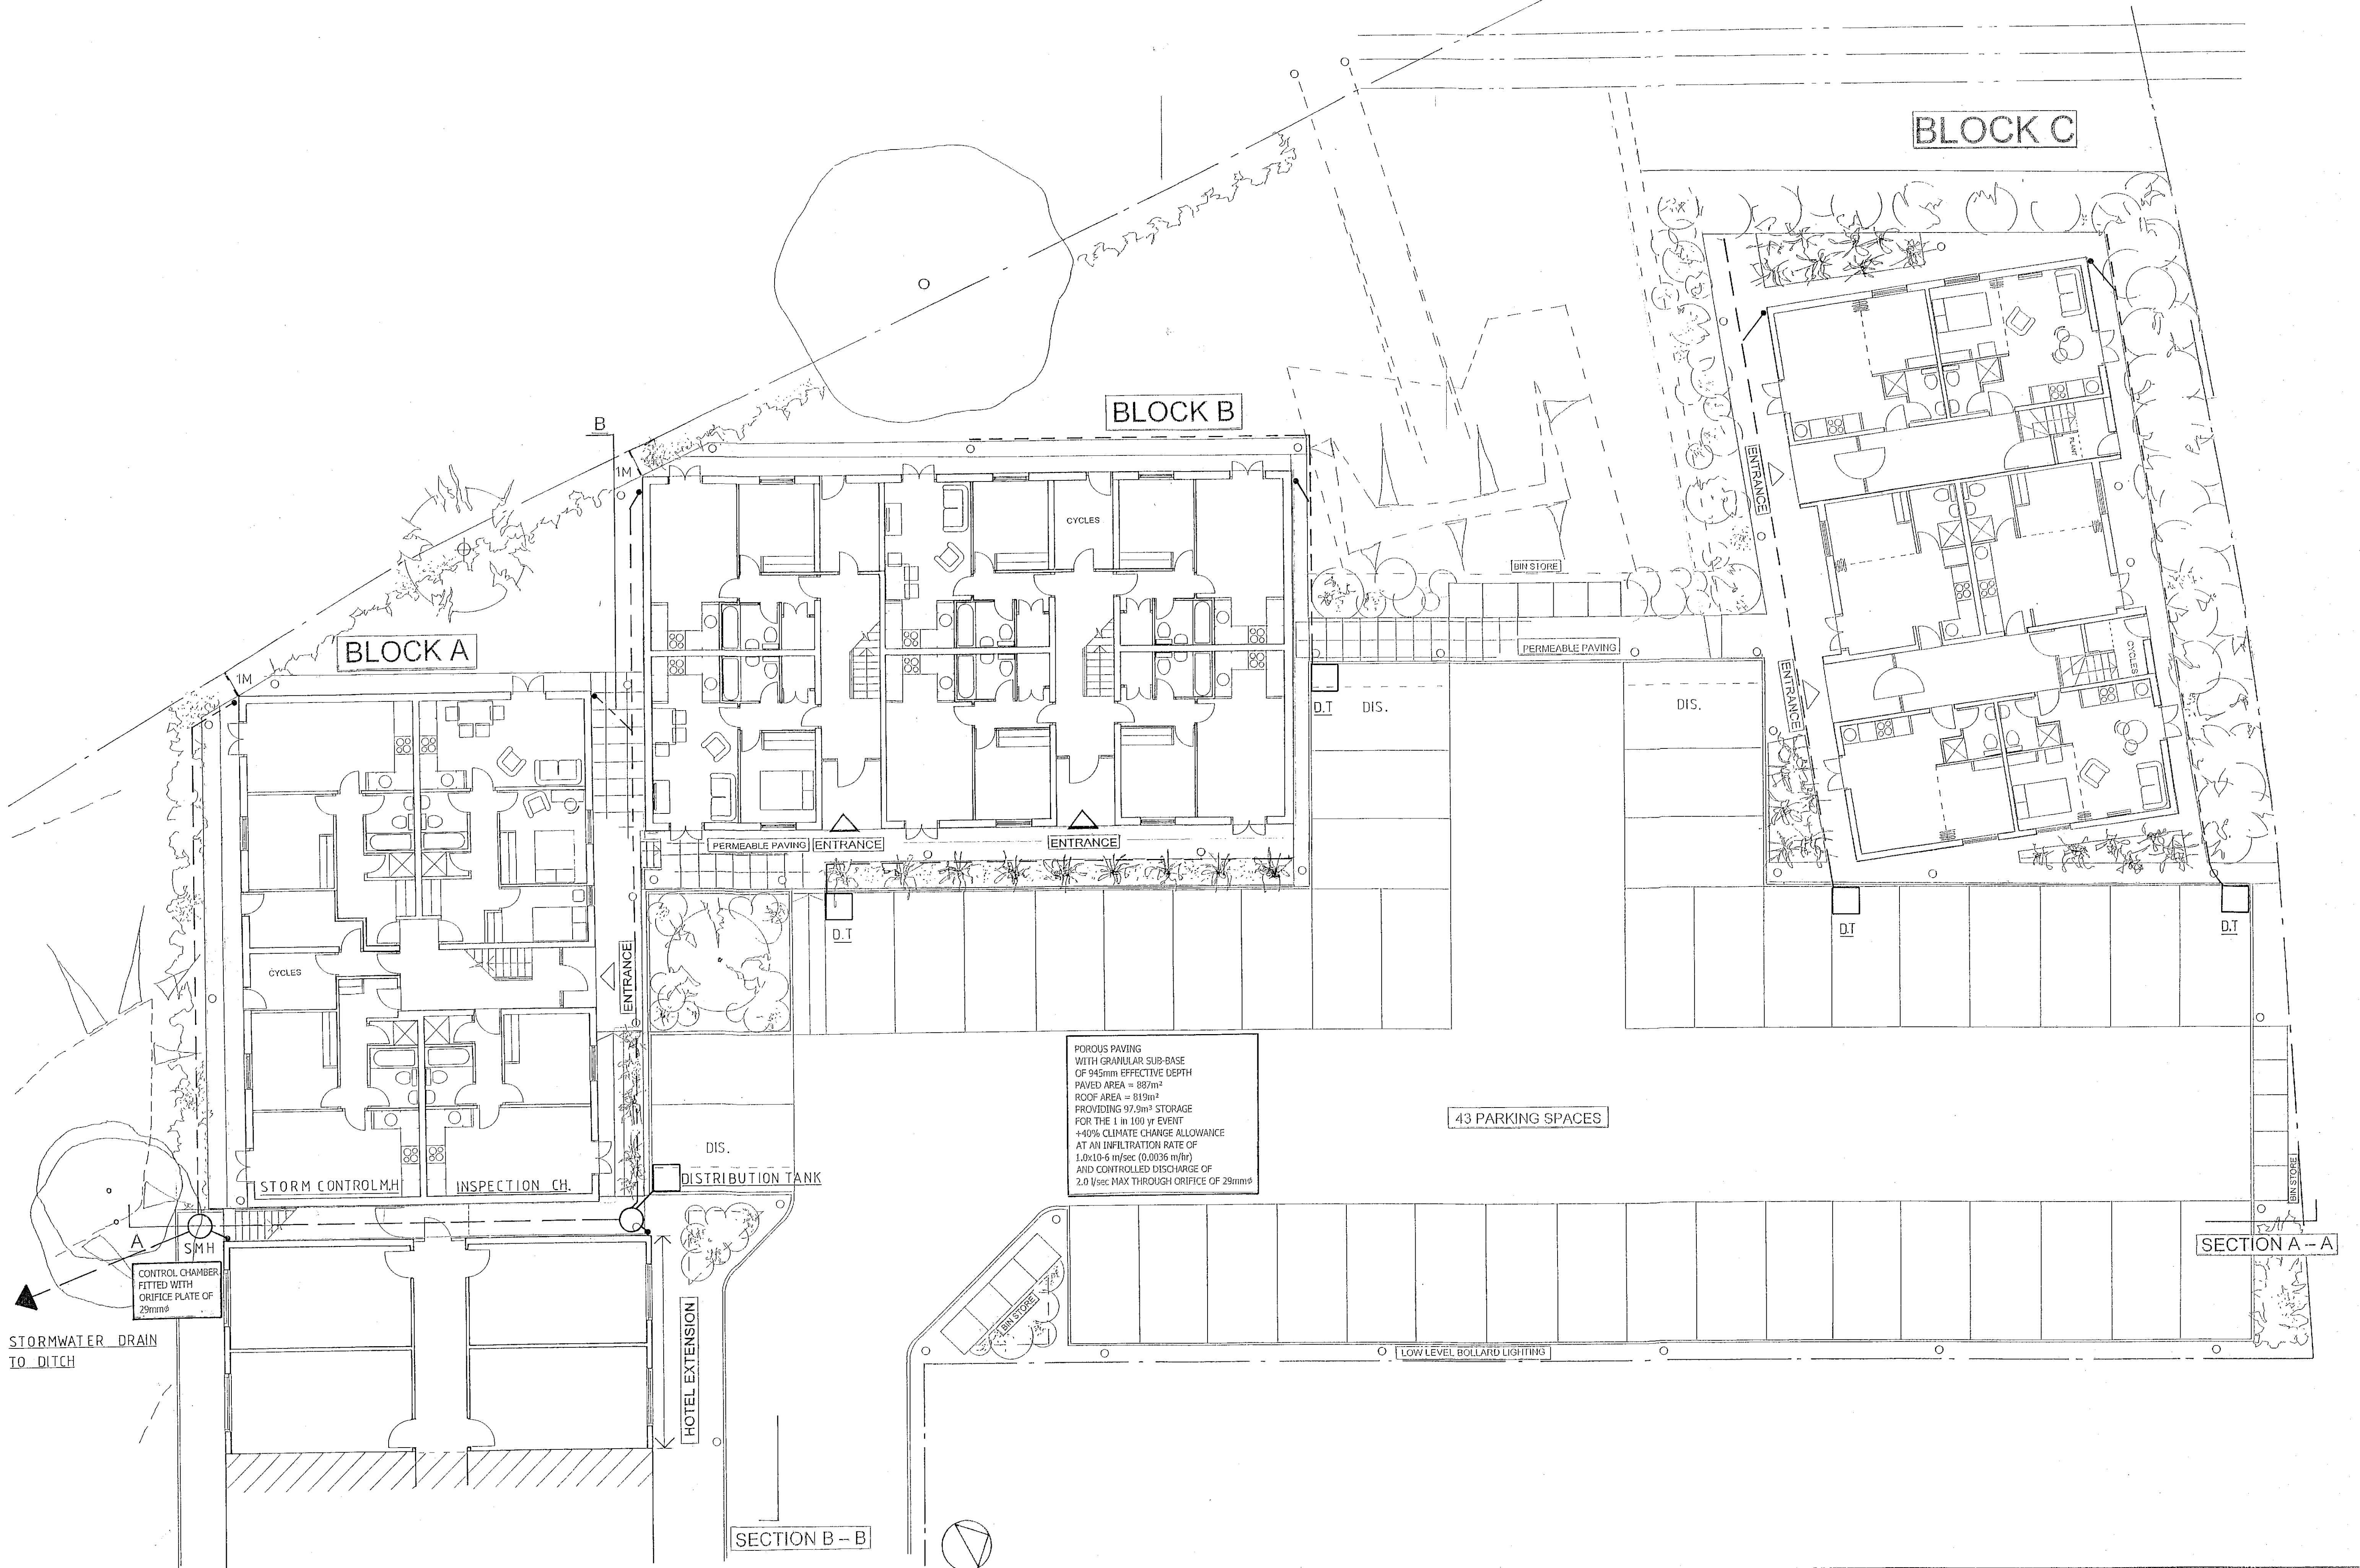

ATELIER CONSULTANTS

phone 07977 070 031

OLD RECTORY COTTAGE, 55C KINGSDOM LANE BN42 4SP

e-mail pete@atelierconsultants.co.uk

PROJECT: ARUNDEL RESIDENCE INN, CROSSBUSH, ARUNDEL

CLIENT:

Drawing Title: SITE STORMWATER DRAINAGE PLAN

Scale: 1:100 @ A1 Date: January 2019

Drawing Number: 095 / P / 50 Rev.