


Living Cottage

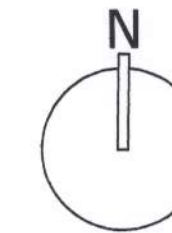

Levels as shown are draft and subject to confirmation on site.
Levels Based on Ordinary Datum using Sewer Records


Middleton House

GF
FFL 5.55

Veg Garden

Little Hazels

Legend (Scale 1:100)

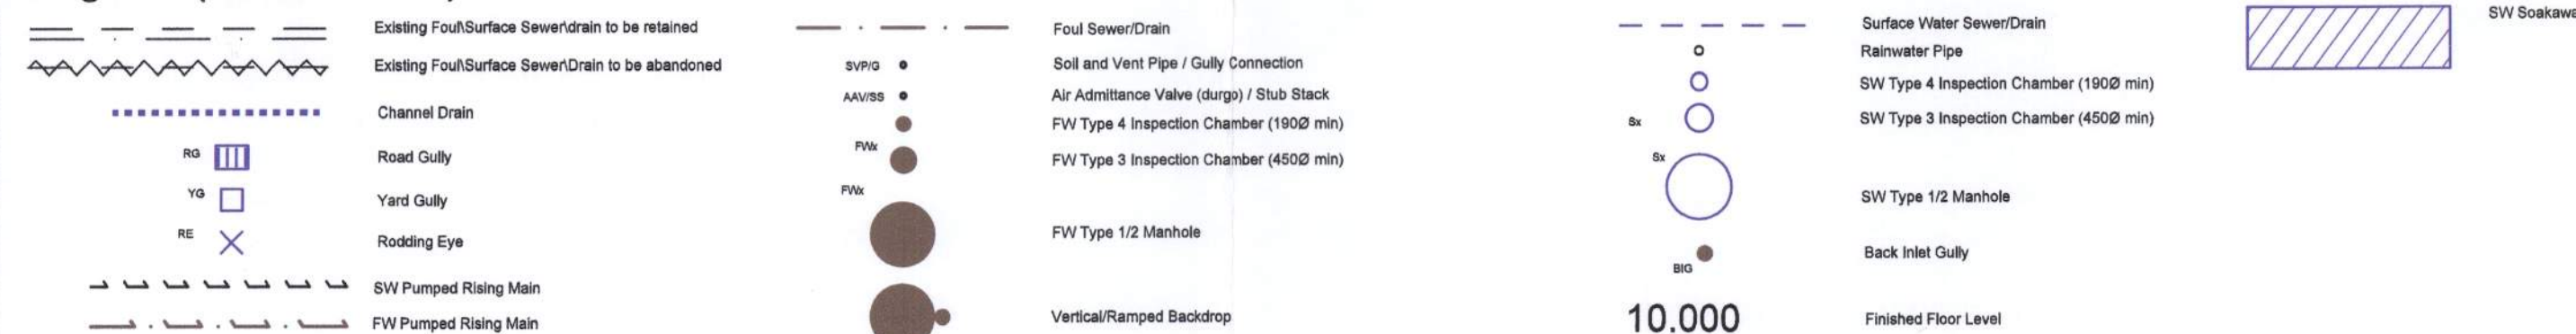

SAT1 - Trench Soakaway
Using Wavin Aquapanel EcoPlus Units with 1500 low flow maintenance channels
Min 0.50m cover Required
Wavin Ref: 500
CL: 5.35 bsc
PIL: 4.85 bsc
PUB/SOL: 4.45 bsc
Tank Size: 10.0 x 8.5 x 0.4m dp
Storage Required = 23.8m³
Storage Provided = 24.7m³
Area Drained = 300m² (Roof and Rear patio only)
SIR = 0.0144 m/hr = 4x10⁻⁴ m/s
FOS = 3
SRP = 100yrs + 40% CC (No Flooding)
= 10yrs + 40% CC (50% drain down)
= Lower than 1.2m BGL
GWL
SAT to be positioned min 5m from Exposed structures

NOTE THE FOLLOWING:

- SW Soakaway
 - 1.1. Refer to Wavin Design & Details dated 2018
 - 1.2. Drawn Ref: 2018
- SW DRAINAGE DESIGN BASED ON:
- Area Drained = 300m² (Roof and Rear patio only)
 - SIR = 0.0144 m/hr = 4x10⁻⁴ m/s
 - FOS = 3
 - GWL = Lower than 1.2m BGL
 - SRP = 100yrs + 40% CC (No Flooding)
 - = 10yrs + 40% CC (50% drain down)

NOTES

- This drawing is to be read in conjunction with drawing Nos. FC2780/01-25.
- Existing on-site drainage is shown on drawing FC2780/01-25.
- All adopted drainage and connections to the sewer system are to be constructed in accordance with 'Sewers for Adoption' 8/7th Edition or as stipulated in the Southern Water Addendum.
- Connections to the adopted drainage system are subject to the approval of Southern Water the Drainage Authority. Diverted, diverted, build close to sewer, and new sewers are subject to SW approval. All other drainage is to remain private.
- All pipes to be adopted, or connecting to adopted sewers, and/or situated under highway to be vitrified clay to BS EN 295 & BS65 (SWS only), or Concrete pipes to BS EN 1916 & BS5911:Part 1, or Thermoplastic Structured wall sewer pipes to WIS 4-35-01 (class B/N/A/m) and be capable of withstanding 4000 PSI jetting pressure.
- Cover levels shown are approximate. Covers and frames shall be set to finished ground levels and falls.
- All drainage to be constructed to BS EN 752:1999 and subject to the approval of Building Control/PA and the Environment Agency.
- Gully and channel drain positions are liable to amendment when the design levels have been determined.
- All downpipes are to be sealed, is connected directly to the stormwater drain. Access points to be provided 1m above ground level for external RWPs and 1m above FFL for internal RWPs.
- All below ground concrete to accord with ACEC site classification of AC-1 bsc, as per Geotechnical Report.
- Aco channel drain to be K100S with grade C250 Quicklock 'Heelguard' cast iron grating or equivalent, where adjacent to kerbing or within pedestrian areas. Elsewhere Aco channel drain to be Road Drain 100 Class F. All channel drain outlets to have oil traps.
- The Contractor should construct works in accordance with the Local Authority specification for the works they are to undertake.
- Road gully pipes are to be 150mm dia. with concrete surround and flexible joints. All other un-referenced pipes are assumed to be 100mm dia.
FW min gradient - 1 in 40 (100 dia) no WCs connected
FW min gradient - 1 in 80 (100 dia) min 1 WC connected
FW min gradient - 1 in 150 (150 dia) min 1 WCs
SW min gradient - 1 in 100 (100/150 dia)
- If any sub soil drainage systems are uncovered during the Works contact the Engineer for instructions. Generally sub soil drains affected are to be diverted around new Works and connected into the surface water drainage system. Pipe diameters and gradients are to be maintained.
- Before commencing construction the Contractor must check the invert levels of existing sewers to which connections are made. In addition the Contractor must locate and determine invert levels of the existing spurs to which connections are proposed. Additional spur/manhole connections are to be agreed with the relevant adopting authority. Any discrepancies are to be notified to the Engineer immediately, prior to construction.
- Road reinstatements are to be to the Highway Authority approval.
- No private areas are to drain onto adoptable areas and vice versa.
- All redundant drainage to be abandoned once the Contractor and Client have satisfied themselves that no connections remain live. Drains and sewers less than 1.5m deep which are in open ground should as far as is practicable be removed. Other pipes should be sealed at both ends and at any other point of connection and solidly filled at intervals not exceeding 25m with Class G3 or G4).

SUBJECT TO CONFIRMATION OF:
Proposed Ext levels
RWPs/CD positions
Landscaping
Wavin Design
ACEC site classification

SUBJECT TO THE APPROVAL OF:
LPA/LFA
BUILDING CONTROL/NHBC

B	Issued For BUDGET/APPROVAL ONLY	04/02/19
A	Issued For BUDGET/APPROVAL ONLY	17/10/18
-	Issued For BUDGET/APPROVAL ONLY	10/09/18
REV	DESCRIPTION	DATE

abmh
ABMH Civils Ltd
1 The Grove, Felpham, Bognor Regis, West Sussex PO22 7EY
Mark Mob: 07761 950000
Email: mark@abmh.co.uk / Web: www.abmh.co.uk

PROJECT	MIDDLETON HOUSE YAPTON ROAD MIDDLETON PO22 6DU
DRAWING	SW DRAINAGE LAYOUT OPTION 1 TRENCH SOAKAWAY
Proj No	FC2780/2.1
SCALE	1:100
DATE	SEPT 18
INITIAL	MH
CHKD	-
REV	B

This drawing is produced using AutoCAD. Only written dimensions are to be respected.
© ABMH Civils Ltd - Title to this drawing remains with ABMH Civils Ltd
Removal of the title block also removes all warranties and imprints copyright