 


SITE AREA PLAN



Reproduced by permission of Ordnance Survey on behalf of

NGR E: 497464 N: 100389



GOOGLE MAPS QR CODE

GOOGLE MAPS - <https://goo.gl/maps/kdfavffwtD1fMgVP8>

GOOGLE STREETVIEW - <https://goo.gl/maps/MGX2by6faqRXyPoM9>

1. ALL DIMENSIONS IN MM UNLESS OTHERWISE NOTED.

Site Provider's Property Boundary: 

Access Route To Site: 

Access Route: 

Master:	MBNL / EE / H3G:	Project:	Purpose of Issue:	Issue:
M002	MBNL	H3G UNILATERAL SW	Planning	B
Date:	24/06/2020	Revision / Upgrade Description:		
Drawn:	SPD	Minor amendments		
Checked:	H.Konieczek			
Approved:	A. Dobson			
Master:	MBNL / EE / H3G:	Project:	Purpose of Issue:	Issue:
M001	MBNL	H3G UNILATERAL SW	Planning	A
Date:	01/06/2020	Revision / Upgrade Description:		
Drawn:	SPD	First Issue		
Checked:	H.Konieczek			
Approved:	A. Dobson			

	Hutchison 3G UK Limited Sir Victor, 20 Grenville Road Maidenhead, SL6 1EH Tel: 01628 765 000 Fax: 01628 765 001		Hatfield Business Park Hatfield Hertfordshire AL10 9BW
H3G Base Station information line: 0845 6043000 Available 8am-6pm Monday to Friday		Tel: 01707 315000 Fax: 01707 319001	

MBNL Mobile Broadband Network Limited
Sixth Floor, Thames Tower, Station Road, Reading, RG1 1LX

Design Consultant & Principal Contractor:


CLARKE
telecom
Unit E, Madison Place, Northampton Road,
Manchester, M40 5AG
Tel: 0161 785 4500 Fax: 0161 785 4501
Web: www.clarke-telecom.com

Site Name:

ELMER ROAD

Site ID:

745837

Address:

ELMER ROAD
BOGNR REGIS
WEST SUSSEX
PO22 6DZ

Title:

002 SITE LOCATION PLAN

Project:

H3G UNILATERAL SW

	Purpose of Issue:

PLANNING

EE Cell ID: 71562	MBNL Cell ID: ARN008	3UK Cell ID: PO0276
-----------------------------	--------------------------------	-------------------------------

Master Drawing No:

745837 ARN008 71562 PO0276 M002

Issue:


D




3G / 4G Antenna ID	Existing 3G Bearing
uA1	0°
uB1	120°
uC1	240°

NOTES:

1. ALL DIMENSIONS IN MM UNLESS OTHERWISE NOTED.

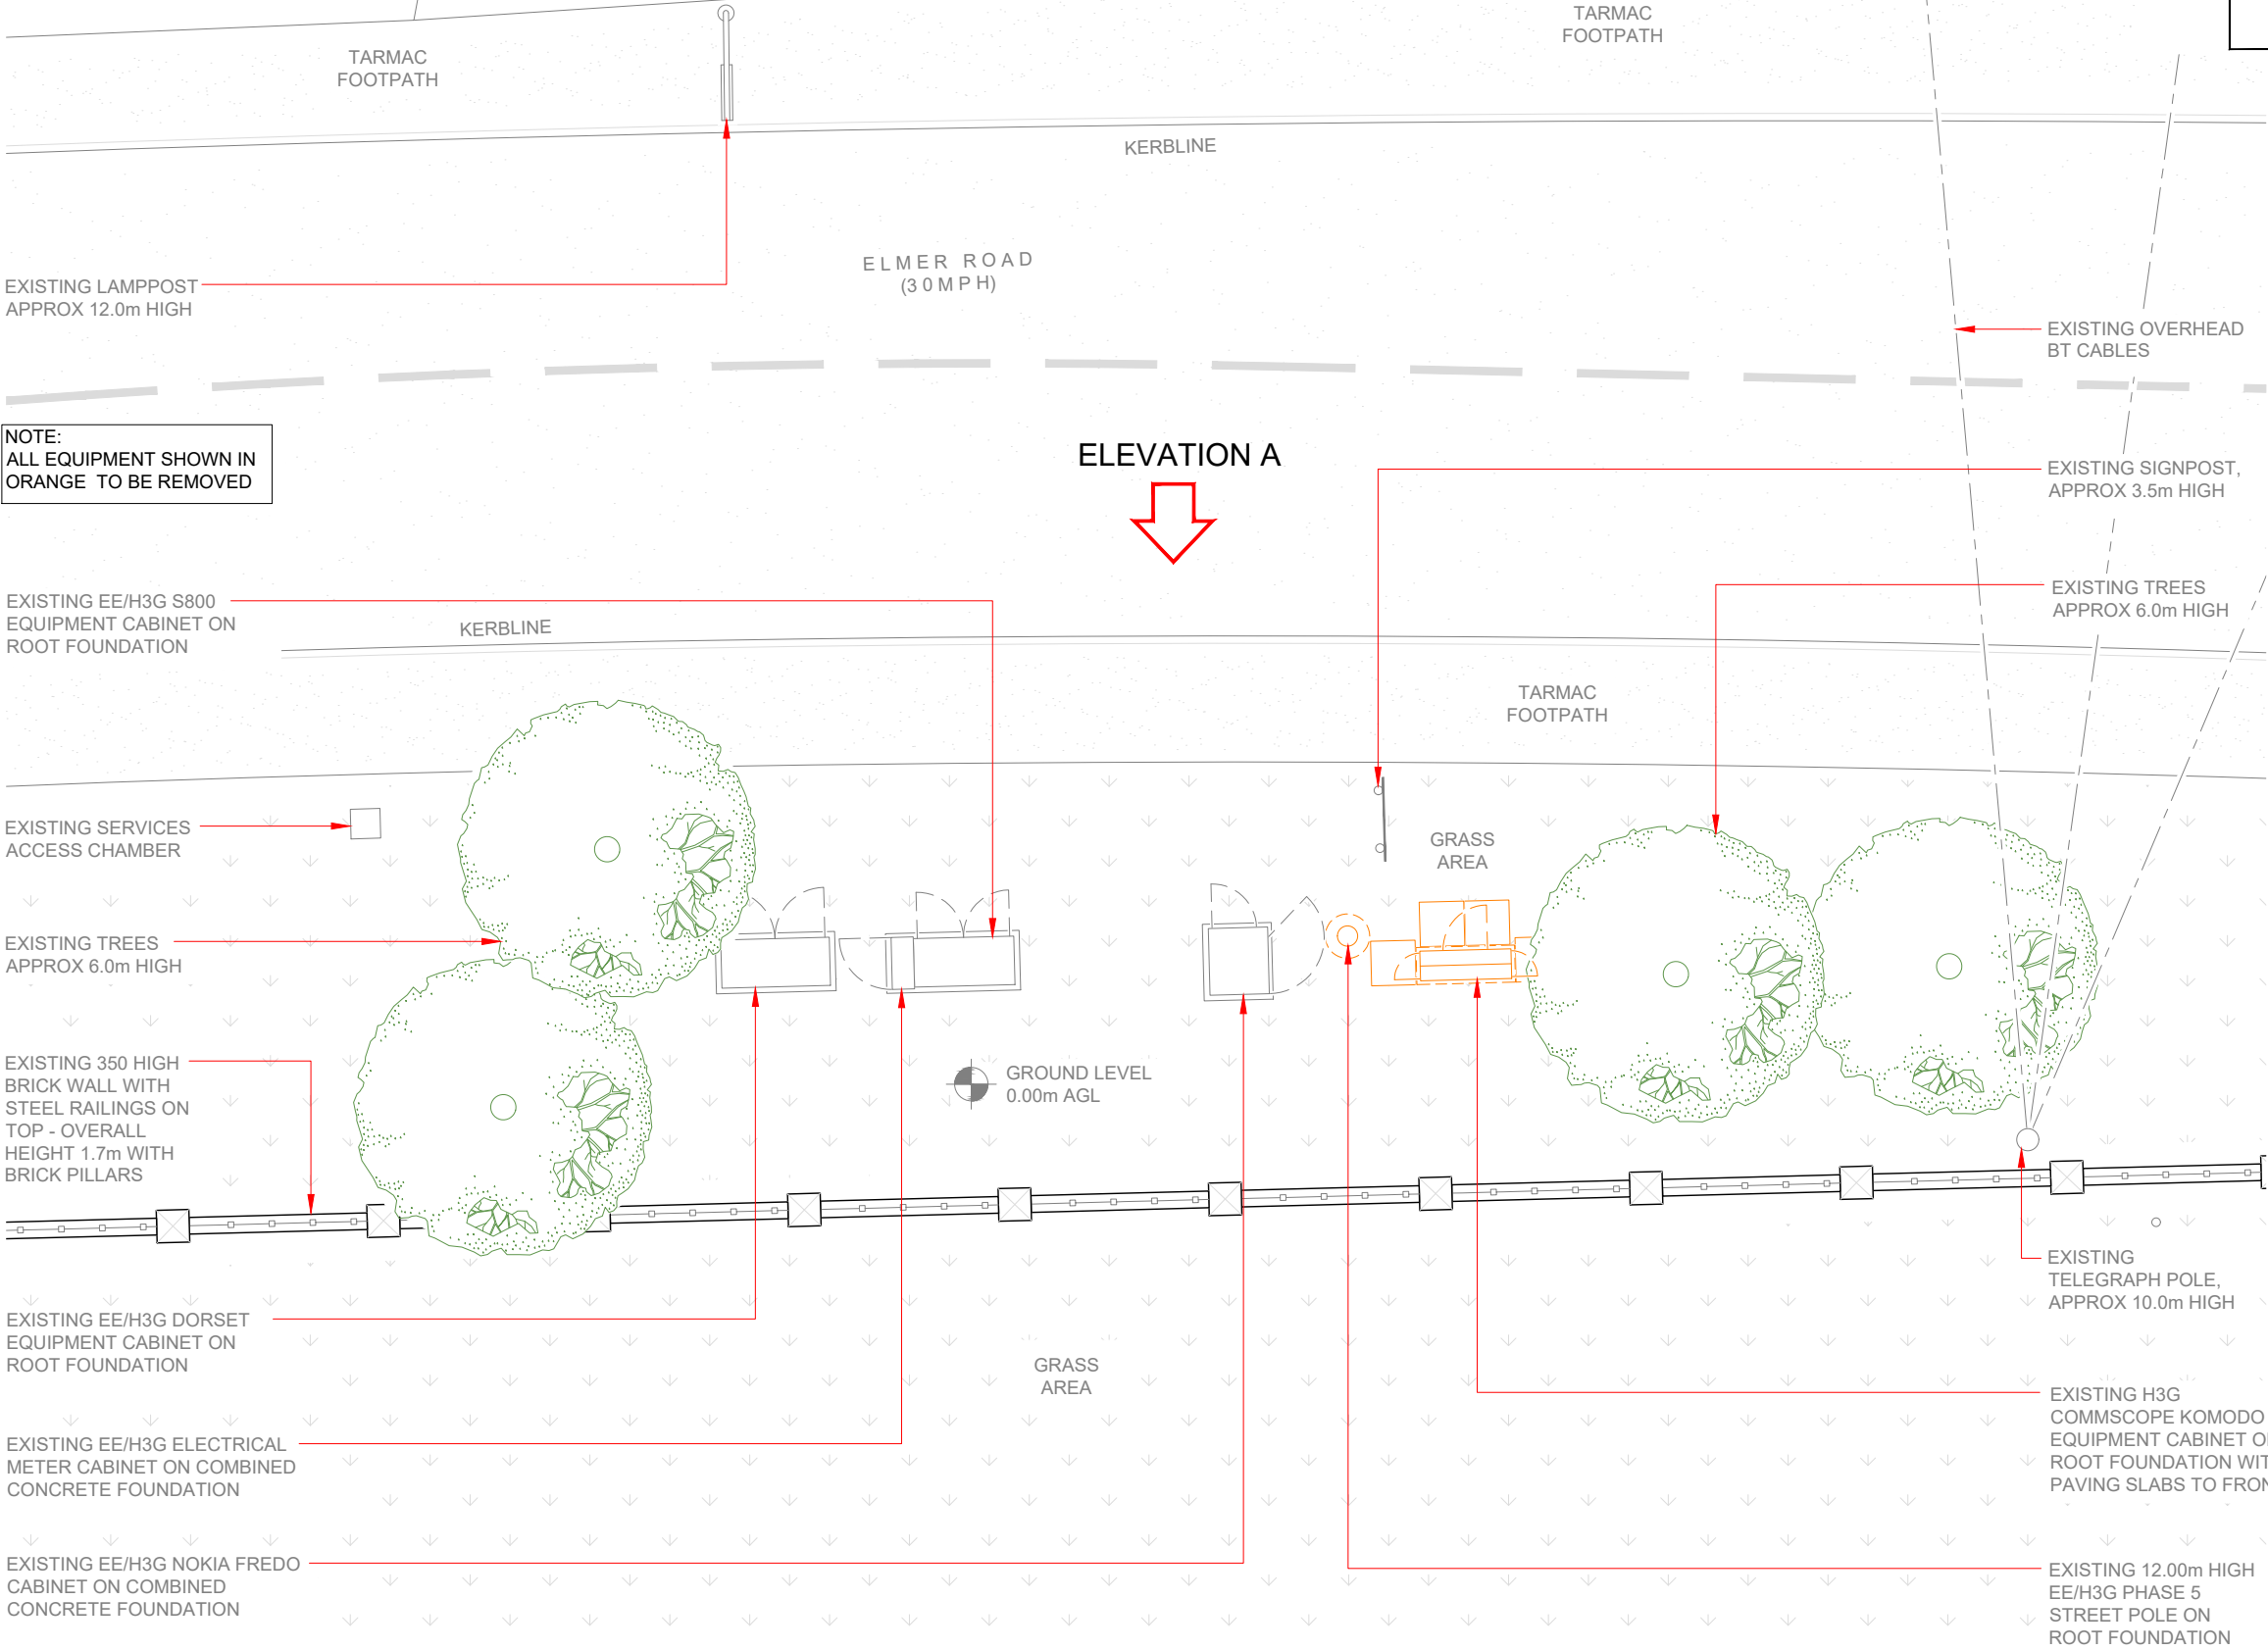

EXISTING SITE PLAN

 

Master:	MBNL / EE / H3G:	Project:	H3G UNILATERAL SW	Purpose of Issue:	Planning	Issue:	B
M002	MBNL	Revision / Upgrade Description:					
Date:	24/06/2020	Minor amendments					
Drawn:	SPD						
Checked:	H.Konieczek						
Approved:	A. Dobson						
Master:	MBNL / EE / H3G:	Project:	H3G UNILATERAL SW	Purpose of Issue:	Planning	Issue:	A
M001	MBNL	Revision / Upgrade Description:					
Date:	01/06/2020	First Issue					
Drawn:	SPD						
Checked:	H.Konieczek						
Approved:	A. Dobson						



Hutchison 3G UK Limited
Star House, 20 Grenfell Road
Maidenhead, SL6 1EH
Tel: 01628 765 900
Fax: 01628 765 901

H3G Base Station Information line:
0845 6043000
Available 8am-8pm Monday to Friday



Hatfield Business Park
Hatfield
Hertfordshire
AL10 9BW

Tel: 01707 315000
Fax: 01707 319001



Mobile Broadband Network Limited
Sixth Floor, Thames Tower, Station Road, Reading, RG1 1LX

Design Consultant & Principal Contractor:

CLARKE telecom

Unit E, Madison Place, Northampton Road,
Manchester, M40 5AG
Tel: 0161 785 4500 Fax: 0161 785 4501
Web: www.clarke-telecom.com

Site Name:	ELMER ROAD		
Site ID:	745837		
Address:	ELMER ROAD BOGNER REGIS WEST SUSSEX PO22 6DZ		
Title:	100 EXISTING SITE PLAN		
Project:	H3G UNILATERAL SW		
Purpose of Issue:	PLANNING		
EE Cell ID:	71562	MBNL Cell ID:	ARN008
		3UK Cell ID:	PO0276
Master Drawing No: 745837_ARN008_71562_PO0276_M002			Issue: B

100mm

150mm

10mm

EXISTING 12.00m HIGH
EE/H3G PHASE 5 STREET
POLE ON ROOT FOUNDATION

TOP OF EXISTING EE/H3G STREET POLE +12.00m AGL (+17.00m AMSL)

C/L OF EXISTING EE/H3G ANTENNAS +10.85m AGL (+15.85m AMSL)

EXISTING
TELEGRAPH POLE,
APPROX 10.0m HIGH

EXISTING SIGNPOST,
APPROX 3.5m HIGH

EXISTING H3G COMMSCOPE
KOMODO EQUIPMENT CABINET
ON ROOT FOUNDATION WITH
PAVING SLABS TO FRONT

EXISTING 350 HIGH BRICK WALL WITH
STEEL RAILINGS ON TOP - OVERALL
HEIGHT 1.7m WITH BRICK PILLARS

EXISTING EE/H3G NOKIA FREDO
CABINET ON COMBINED
CONCRETE FOUNDATION

NOTE:
ALL EQUIPMENT SHOWN IN
ORANGE TO BE REMOVED

EXISTING TREES HEIGHT
+12.00m AGL APPROX

EXISTING BUILDING HEIGHT
+12.00m AGL

EXISTING TREES HEIGHT
+6.00m AGL APPROX

 
G.L ±0.00m (+5.0m AMSL)

EXISTING EE/H3G DORSET
EQUIPMENT CABINET ON
ROOT FOUNDATION

EXISTING EE/H3G ELECTRICAL
METER CABINET ON COMBINED
CONCRETE FOUNDATION

EXISTING EE/H3G S800 EQUIPMENT
CABINET ON ROOT FOUNDATION

EXISTING ELEVATION A



3G / 4G Antenna ID	Existing 3G Bearing
uA1	0°
uB1	120°
uC1	240°

NOTES:
1. ALL DIMENSIONS IN MM UNLESS OTHERWISE NOTED.

Master:	MBNL / EE / H3G:	Project:	Purpose of Issue:	Issue:
M002	MBNL	H3G UNILATERAL SW	Planning	B
Date:	24/06/2020	Revision / Upgrade Description:		
Drawn:	SPD	Minor amendments		
Checked:	H.Konieczek			
Approved:	A. Dobson			
Master:	MBNL / EE / H3G:	Project:	Purpose of Issue:	Issue:
M001	MBNL	H3G UNILATERAL SW	Planning	A
Date:	01/06/2020	Revision / Upgrade Description:		
Drawn:	SPD	First Issue		
Checked:	H.Konieczek			
Approved:	A. Dobson			



Hutchison 3G UK Limited
Star House, 20 Grenfell Road
Maidenhead, SL6 1EH
Tel: 01628 765 500
Fax: 01628 765 501

H3G Base Station Information line:
0845 6043000
Available 8am-8pm Monday to Friday



Hatfield Business Park
Hatfield
Hertfordshire
AL10 9BW

Tel: 01707 315000
Fax: 01707 319001



Mobile Broadband Network Limited
Sixth Floor, Thames Tower, Station Road, Reading, RG1 1LX

Design Consultant & Principal Contractor:



Unit E, Madison Place, Northampton Road,
Manchester, M40 5AG
Tel: 0161 785 4500 Fax: 0161 785 4501
Web: www.clarke-telecom.com

Site Name:
ELMER ROAD

Site ID:
745837

Address:
ELMER ROAD
BOGNR REGIS
WEST SUSSEX
PO22 6DZ

Title:
150 EXISTING ELEVATION A

Project:
H3G UNILATERAL SW

Purpose of Issue:
PLANNING


EE Cell ID: 71562	MBNL Cell ID: ARN008	3UK Cell ID: PO0276
----------------------	-------------------------	------------------------

Master Drawing No: 745837_ARN008_71562_PO0276_M002	Issue: B
---	-------------




Antenna Aperture ID	Proposed 4G/5G Bearing	Operator: Shared/ EE/H3G
A1	0°	H3G
A2	0°	EE/H3G
B1	120°	H3G
B2	120°	EE/H3G
C2	240°	H3G
C3	240°	EE/H3G

- NOTES:
- ALL DIMENSIONS IN MM UNLESS OTHERWISE NOTED.

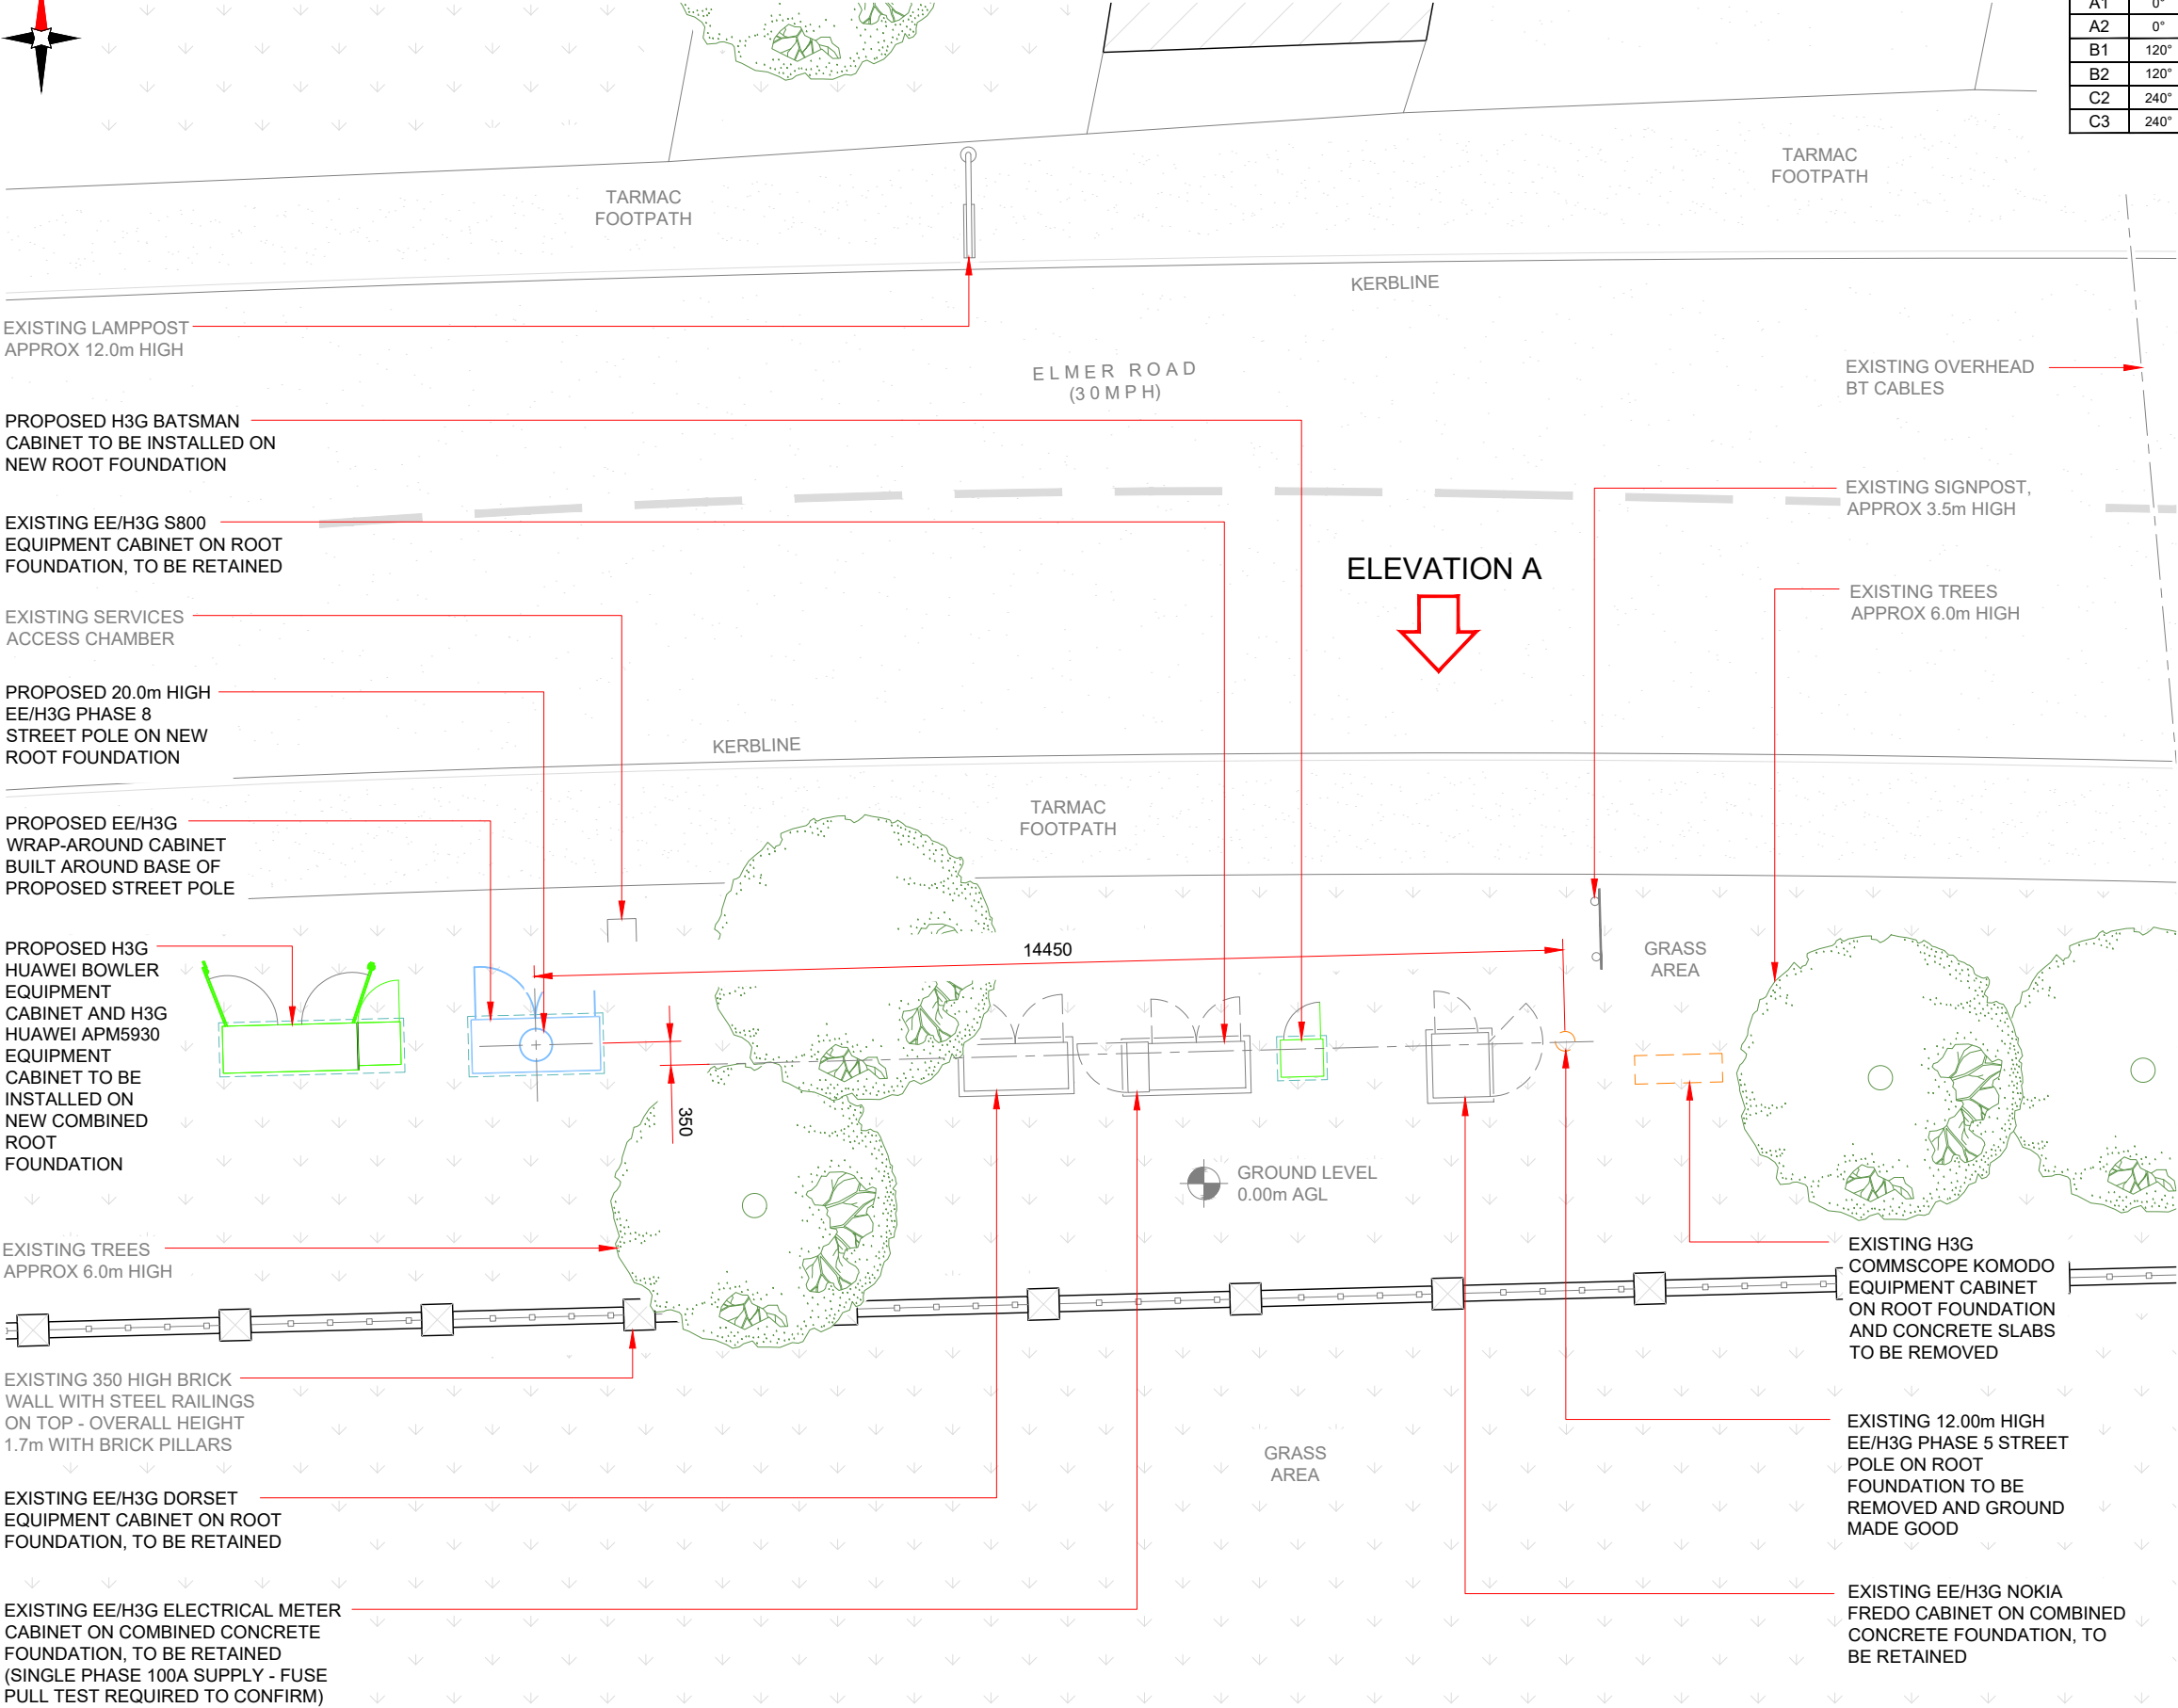

PROPOSED SITE PLAN

 

Master: M002	MBNL / EE / H3G	Project: H3G UNILATERAL SW	Purpose of Issue: Planning	Issue: B
Date: 24/06/2020	Drawn: SPD	Revision / Upgrade Description: Minor amendments		
Checked: H.Konieczek	Approved: A. Dobson			
Master: M001	MBNL / EE / H3G	Project: H3G UNILATERAL SW	Purpose of Issue: Planning	Issue: A
Date: 01/06/2020	Drawn: SPD	Revision / Upgrade Description: First Issue		
Checked: H.Konieczek	Approved: A. Dobson			

Hutchison 3G UK Limited
Star House, 20 Grenfell Road
Maidenhead, SL6 1EH
Tel: 01628 765 500
Fax: 01628 765 501
H3G Base Station Information line:
0845 6043000
Available 8am-8pm Monday to Friday

Hatfield Business Park
Hatfield
Hertfordshire
AL10 9BW
Tel: 01707 315000
Fax: 01707 319001

MBNL Mobile Broadband Network Limited
Sixth Floor, Thames Tower, Station Road, Reading, RG1 1LX

Design Consultant & Principal Contractor:


Unit E, Madison Place, Northampton Road,
Manchester, M40 5AG
Tel: 0161 785 4500 Fax: 0161 785 4501
Web: www.clarke-telecom.com

Site Name:	ELMER ROAD		
Site ID:	745837		
Address:	ELMER ROAD BOGNER REGIS WEST SUSSEX PO22 6DZ		
Title:	215 PROPOSED SITE PLAN		
Project:	H3G UNILATERAL SW		
Purpose of Issue:	PLANNING		
EE Cell ID:	MBNL Cell ID:	3UK Cell ID:	
71562	ARN008	PO0276	
Master Drawing No: 745837_ARN008_71562_PO0276_M002			
Issue: B			

100mm

50mm

10mm

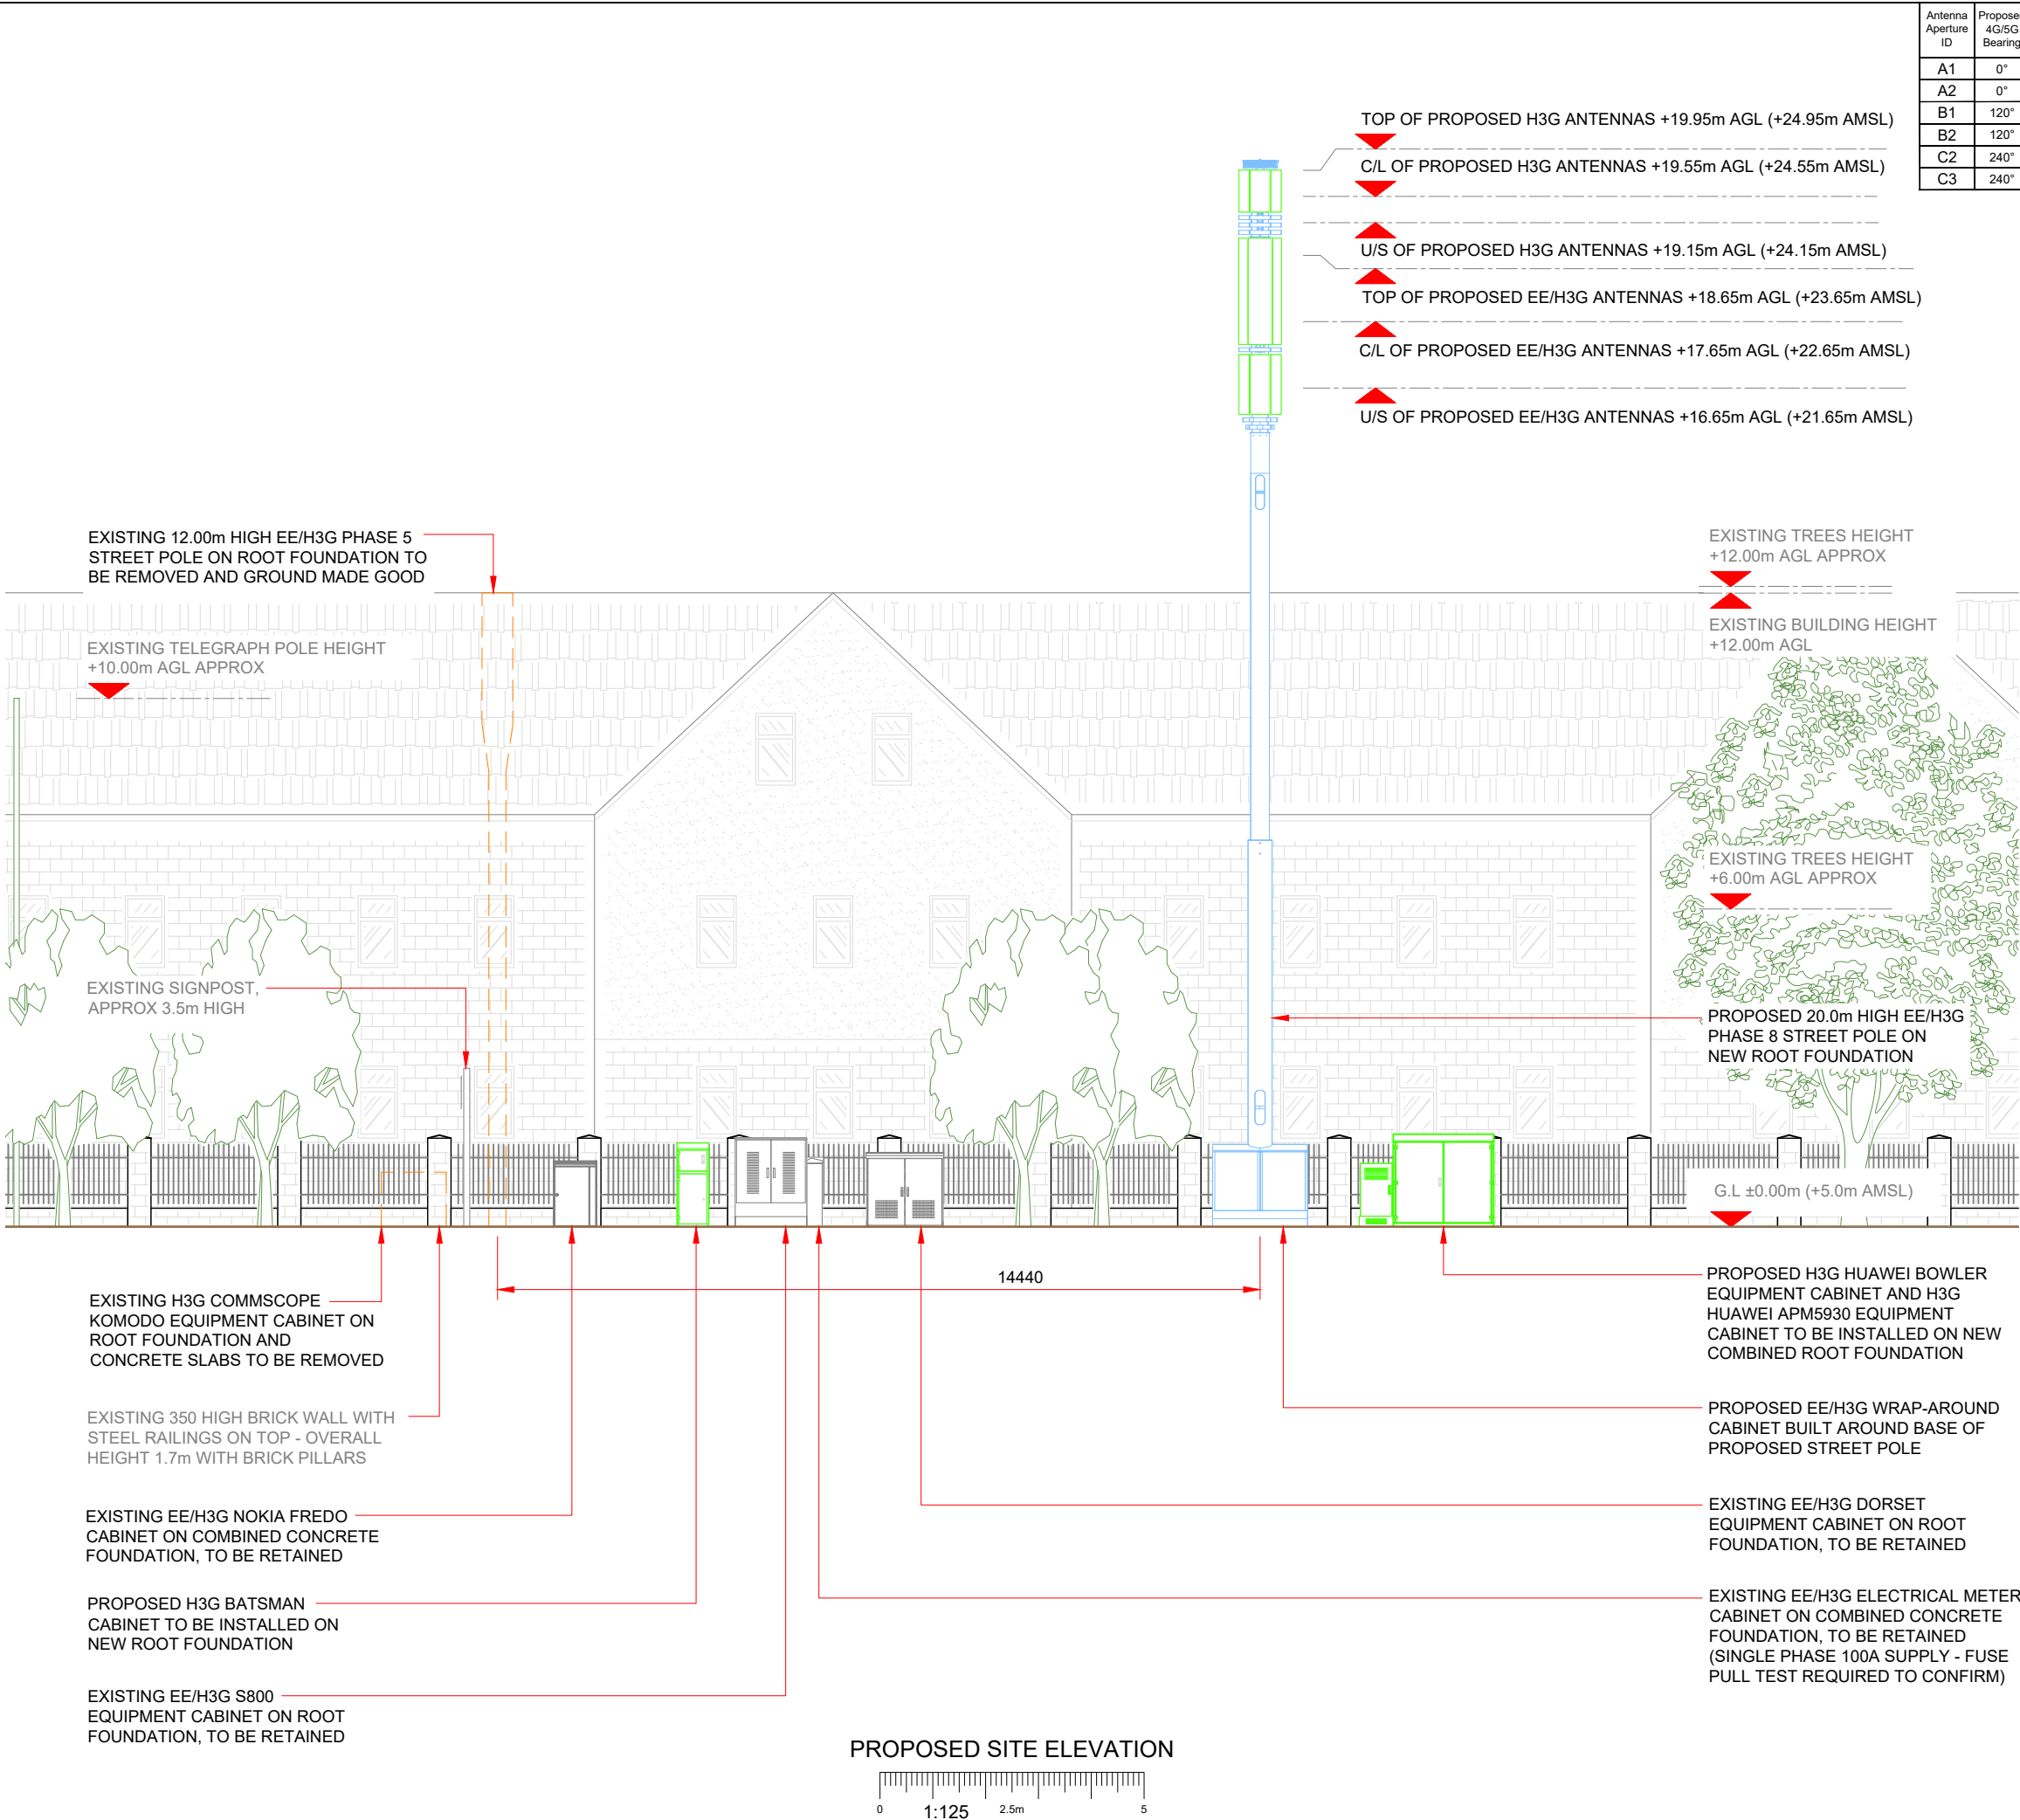

Antenna Aperture ID	Proposed 4G/5G Bearing	Operator: Shared/ EE/H3G
A1	0°	H3G
A2	0°	EE/H3G
B1	120°	H3G
B2	120°	EE/H3G
C2	240°	H3G
C3	240°	EE/H3G

- NOTES:
- ALL DIMENSIONS IN MM UNLESS OTHERWISE NOTED.

Master:	MBNL / EE / H3G:	Project:	H3G UNILATERAL SW	Purpose of Issue:	Planning	Issue:	B
M002	MBNL	Revision / Upgrade Description: Minor amendments					
Date:	24/06/2020						
Drawn:	SPD						
Checked:	H.Konieczek						
Approved:	A. Dobson						
Master:	MBNL / EE / H3G:	Project:	H3G UNILATERAL SW	Purpose of Issue:	Planning	Issue:	A
M001	MBNL	Revision / Upgrade Description: First Issue					
Date:	01/06/2020						
Drawn:	SPD						
Checked:	H.Konieczek						
Approved:	A. Dobson						



Hutchison 3G UK Limited
Star House, 20 Grenfell Road
Maidenhead, SL6 1EH
Tel: 01628 765 500
Fax: 01628 765 501

H3G Base Station Information line:
0845 6043000
Available 8am-8pm Monday to Friday



Hatfield Business Park
Hatfield
Hertfordshire
AL10 9BW
Tel: 01707 315000
Fax: 01707 319001



Mobile Broadband Network Limited
Sixth Floor, Thames Tower, Station Road, Reading, RG1 1LX

Design Consultant & Principal Contractor:

CLARKE
telecom
Unit E, Madison Place, Northampton Road,
Manchester, M40 5AG
Tel: 0161 785 4500 Fax: 0161 785 4501
Web: www.clarke-telecom.com

Site Name:
ELMER ROAD

Site ID:
745837

Address:
**ELMER ROAD
BOGNER REGIS
WEST SUSSEX
PO22 6DZ**

Title:
265 PROPOSED SITE ELEVATION

Project:
H3G UNILATERAL SW

Purpose of Issue:
PLANNING

EE Cell ID: 71562	MBNL Cell ID: ARN008	3UK Cell ID: PO0276
-----------------------------	--------------------------------	-------------------------------

Master Drawing No: 745837_ARN008_71562_PO0276_M002	Issue: B
--	--------------------