


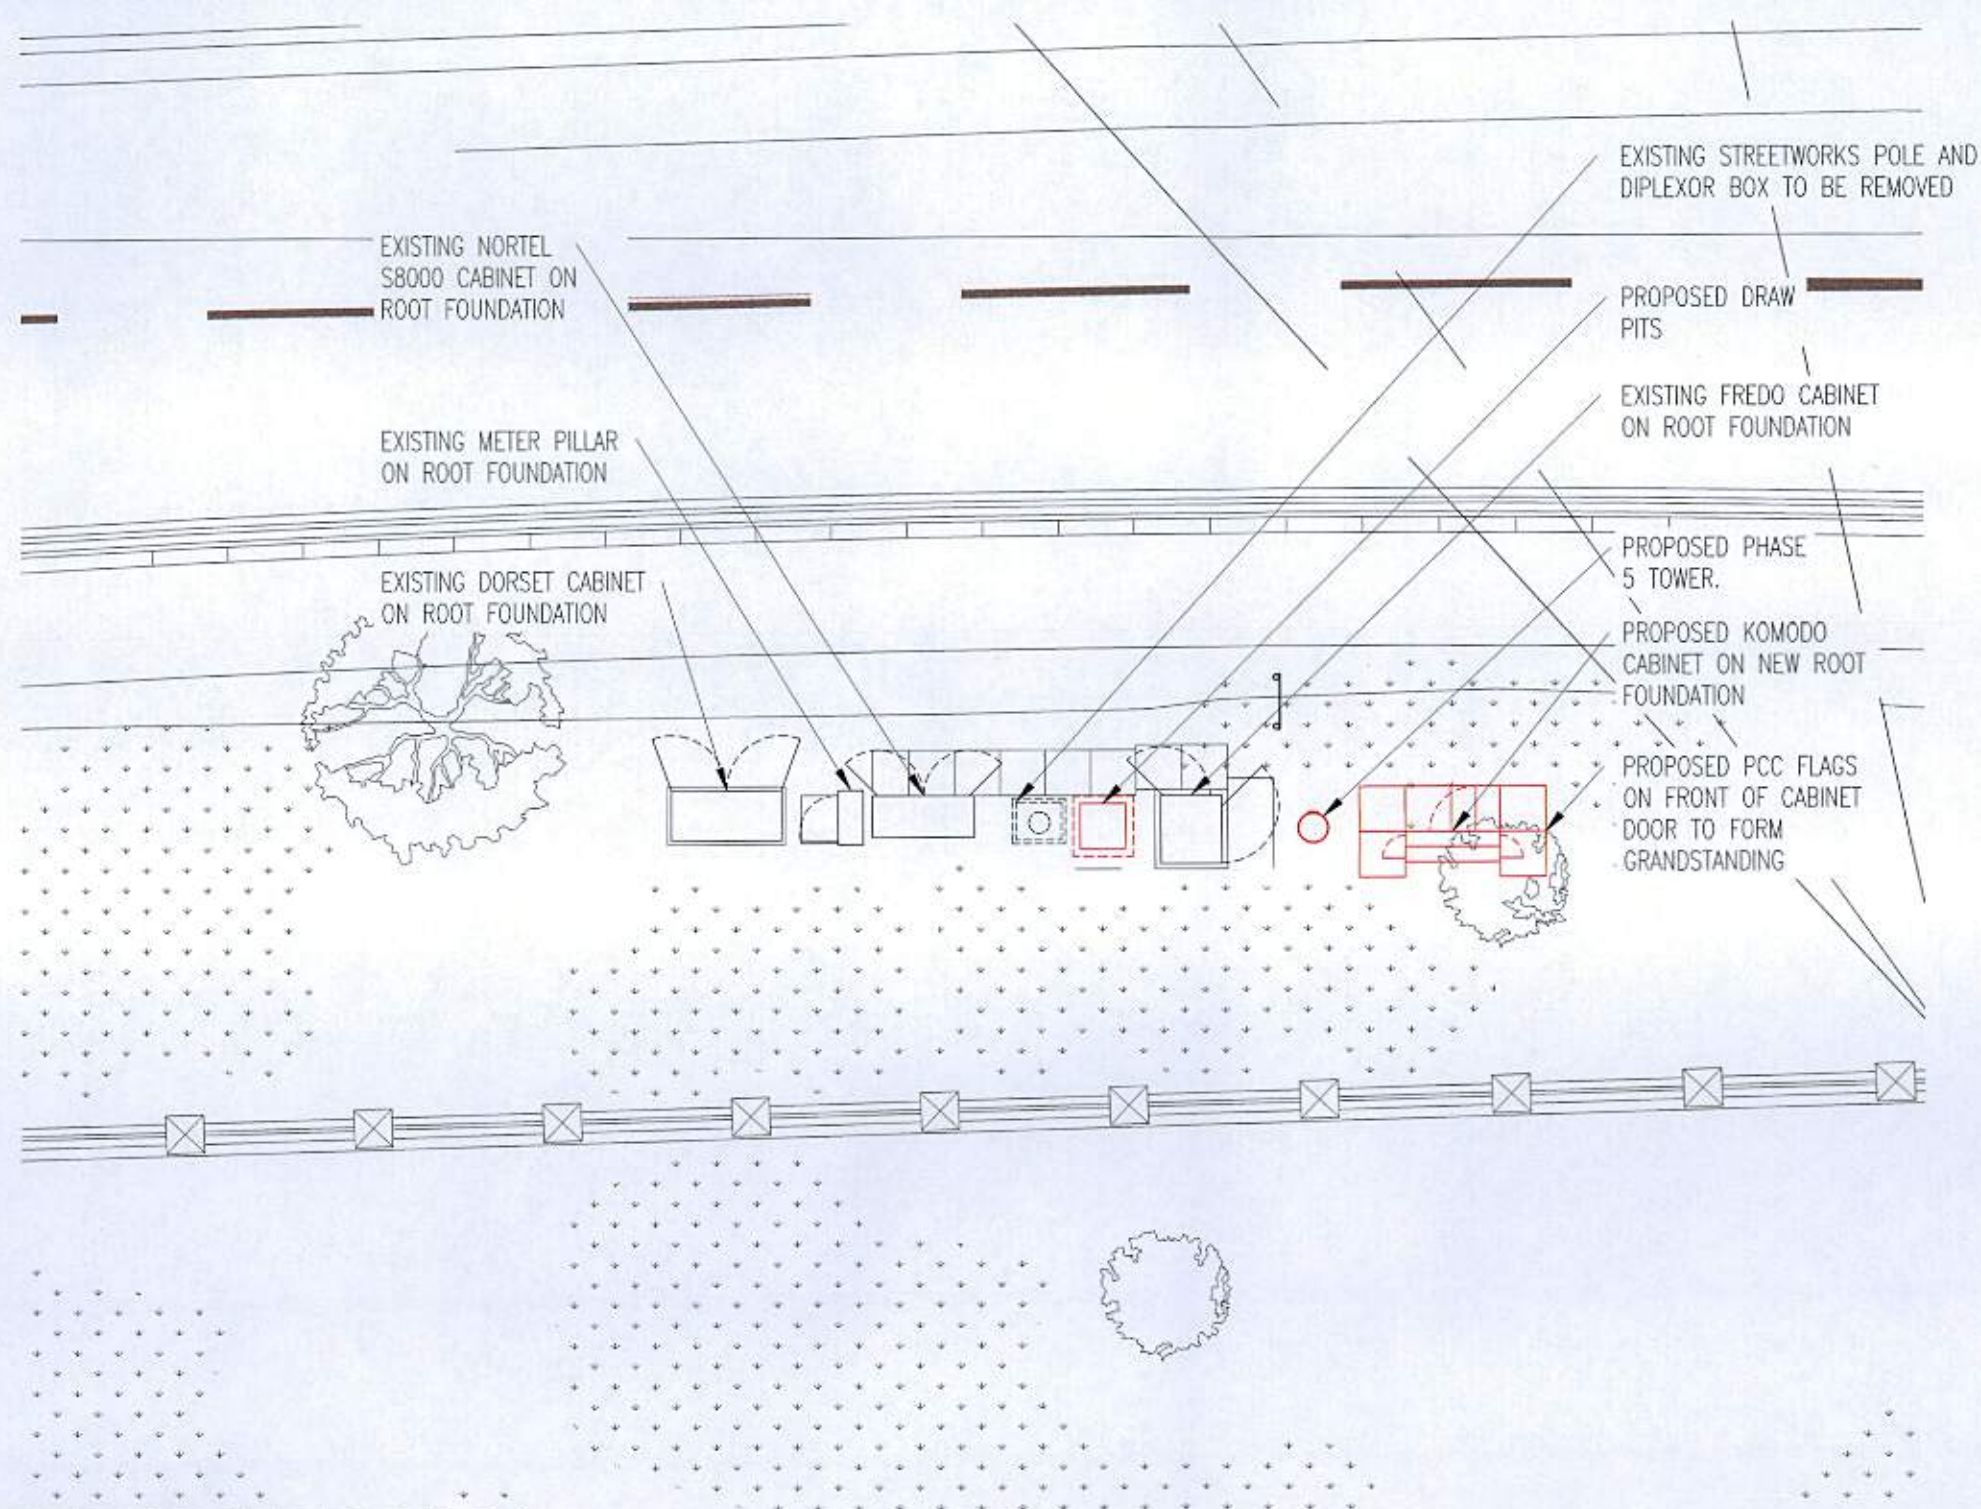

#### NOTE

1. STREETWORKS SAFETY SIGN ATTACHED TO TOWER 2000 BELOW ANTENNA ON ACCESS SIDE
2. ELECTRICAL SAFETY SIGN TO BE FITTED ON OUTSIDE OF METER CABINET DOOR
3. ENTRY SIGN TO BE FITTED ON INSIDE OF STREETWORKS CABINET DOORS
4. ANTENNA-1 SAFETY SIGN TO BE FITTED TO TOWER 200 BELOW EACH ANTENNA ON BORE SIGHT

### SITE PLAN

SCALE 1:100

LOCATION OF PROPOSED SAMSUNG CABINET:-  
DMS: 050:47:42.415N 00:37:03.786W

COVENTRY CONFIG.  
NON-SIMILAR

NOM/RDS DATE/REV.  
NOM. 30/04/2015

14/7/15

## SUBSTITUTION

|     |                                                                                                  |          |     |     |
|-----|--------------------------------------------------------------------------------------------------|----------|-----|-----|
| D   | EQUIPMENT LOCATION CORRECTED TO SUITE LPA COMMENTS                                               | 13.07.15 | MAS | REM |
| C   | CONSTRUCTION ISSUE                                                                               | 08.07.15 | IP  | REM |
| B   | PRELIMINARY ISSUE FOR PLANNING                                                                   | 07/07/15 | MAS | REM |
| A2  | SCHEME REVISED TO SHOW EXISTING UCU'S RETAINED FOR GSM/LIMITS & SPARE FEEDER TERMINATED IN TOWER | 06/07/15 | MAS | REM |
| A1  | PRELIMINARY ISSUE FOR APPROVAL                                                                   | 05/06/15 | MAS | REM |
| No. | Revision                                                                                         | Date     | By  | ckd |

# MBNL

6 Anglo Office Park  
67 White Lion Road  
Amersham  
HP7 9FB

Tel: 01494 762 923  
Email: info@mbnl.co.uk



**WHP Wilkinson Helsby**  
Unit 17B, Astley Way Industrial Estate  
Astley Lane, Swillington, Leeds  
LS26 8XT

Tel: 0113 3023550 Fax: 0113 2876834  
e-mail: info@wilkinson-helsby.co.uk

Site Name & Address:

ELMER ROAD BOGNOR REGIS WEST  
SUSSEX PO22 6DZ

Title:

PROPOSED TELECOMMUNICATIONS  
STREETWORKS UPGRADE  
SITE LAYOUT

Purpose of Issue:

CONSTRUCTION

Drawing No:

71562 - 02

Cell No:

71562

MBNL Ref:

ARN008

Issue:  
D

Scale: AS STATED  
Dm: MAS

Ch'd: REM  
App: REM

Date: 05/06/15  
Date: 05/06/15