 


SITE LOCATION



Reproduced by permission of Ordnance Survey on behalf of the Controller of Her Majesty's Stationery Office
All rights reserved. © Crown Copyright licence no. 100022432

SITE AREA PLAN




SITE PHOTOGRAPH



SITE LOCATION


EXISTING SITE LOCATION

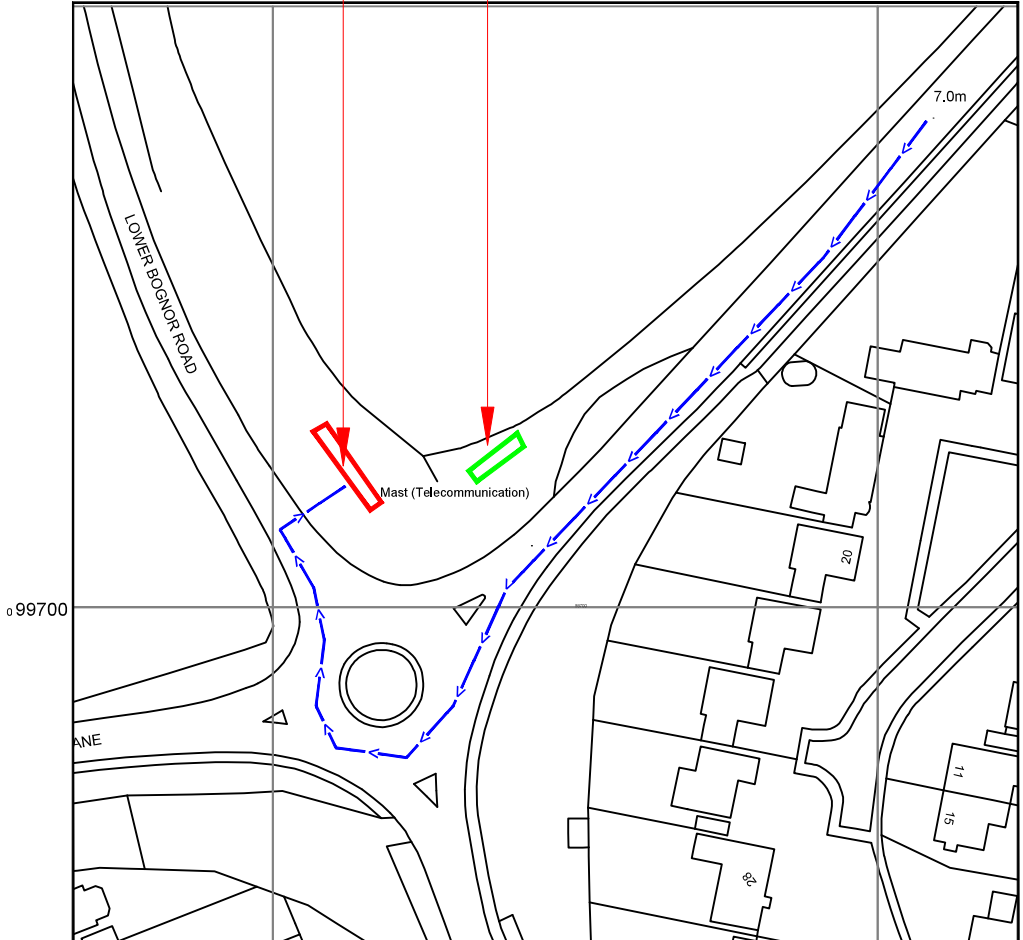

Reproduced by permission of Ordnance Survey on behalf of the Controller of Her Majesty's Stationery Office
All rights reserved. © Crown Copyright licence no. 100022432

NGR E: 491115 N: 099727

 SITE LOCATION PLAN



GOOGLE MAPS QR CODE


GOOGLE MAPS - Hyperlink to map of the site

GOOGLE MAPS - Hyperlink to STREETVIEW of the site

NOTES:

1. ALL DIMENSIONS IN MM UNLESS OTHERWISE NOTED.

DIRECTIONS TO SITE:
HEAD NORTH WEST ON M40.
AT JUNCTION 9 TAKE THE A34/A41 EXIT TO OXFORD/NEWBURY. AT THE
ROUNDBOUT TAKE THE 1ST EXIT ONTO A34. AFTER 5 MILES TAKE THE
A44 EXIT TOWARDS OXFORD. AT THE ROUNDBOUT TAKE THE 2ND EXIT
ONTO WOODSTOCK ROAD/A44. AT THE ROUNDBOUT TAKE THE 2ND EXIT
ONTO ELSFIELD WAY. AFTER 0.4 MILES TURN LEFT. SITE LOCATED ON
RIGHT HAND SDE.

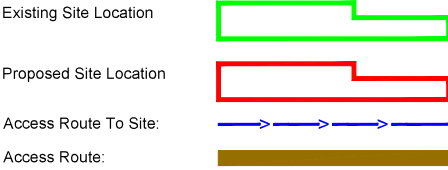

Master:	MBNL / EE / H3G:	Project:	Purpose of Issue:	Issue:
M004	MBNL	H3G UNILATERAL SW	Planning	B
Date:	12/01/2021	Revision / Upgrade Description:		
Drawn:	M.Williams	For Planning Approval		
Checked:	A.Dobson			
Approved:	A.Dobson			



Hutchison 3G UK Limited
Star House, 20 Greenfell Road
Maidenhead, SL6 1EH
Tel: 01628 785 500
Fax: 01628 785 501



Hatfield Business Park
Hatfield
Hertfordshire
AL10 9BW
Tel: 01707 315000
Fax: 01707 319001



Mobile Broadband Network Limited
Sixth Floor, Thames Tower, Station Road, Reading, RG1 1LX

Design Consultant & Principal Contractor:



Unit E, Madison Place, Northampton Road,
Manchester, M40 5AG
Tel: 0161 785 4500 Fax: 0161 785 4501
Web: www.clarke-telecom.com

Site Name: CHALCRAFT LANE

Site ID: 1107443

Address: CHALCRAFT LANE / LOWER BOGNOR ROAD
LOWER BOGNOR ROAD
BOGNOR REGIS
WEST SUSSEX
PO21 5QB

Title: 002 SITE LOCATION PLAN

Project: H3G UNILATERAL SW

Purpose of Issue: PLANNING


EE Cell ID:	MBNL Cell ID:	3UK Cell ID:
25535	ARN046	PO0166

Master Drawing No:	Issue:
1107443_25535_ARN046_PO0166_M004	B

100mm

50mm

10mm

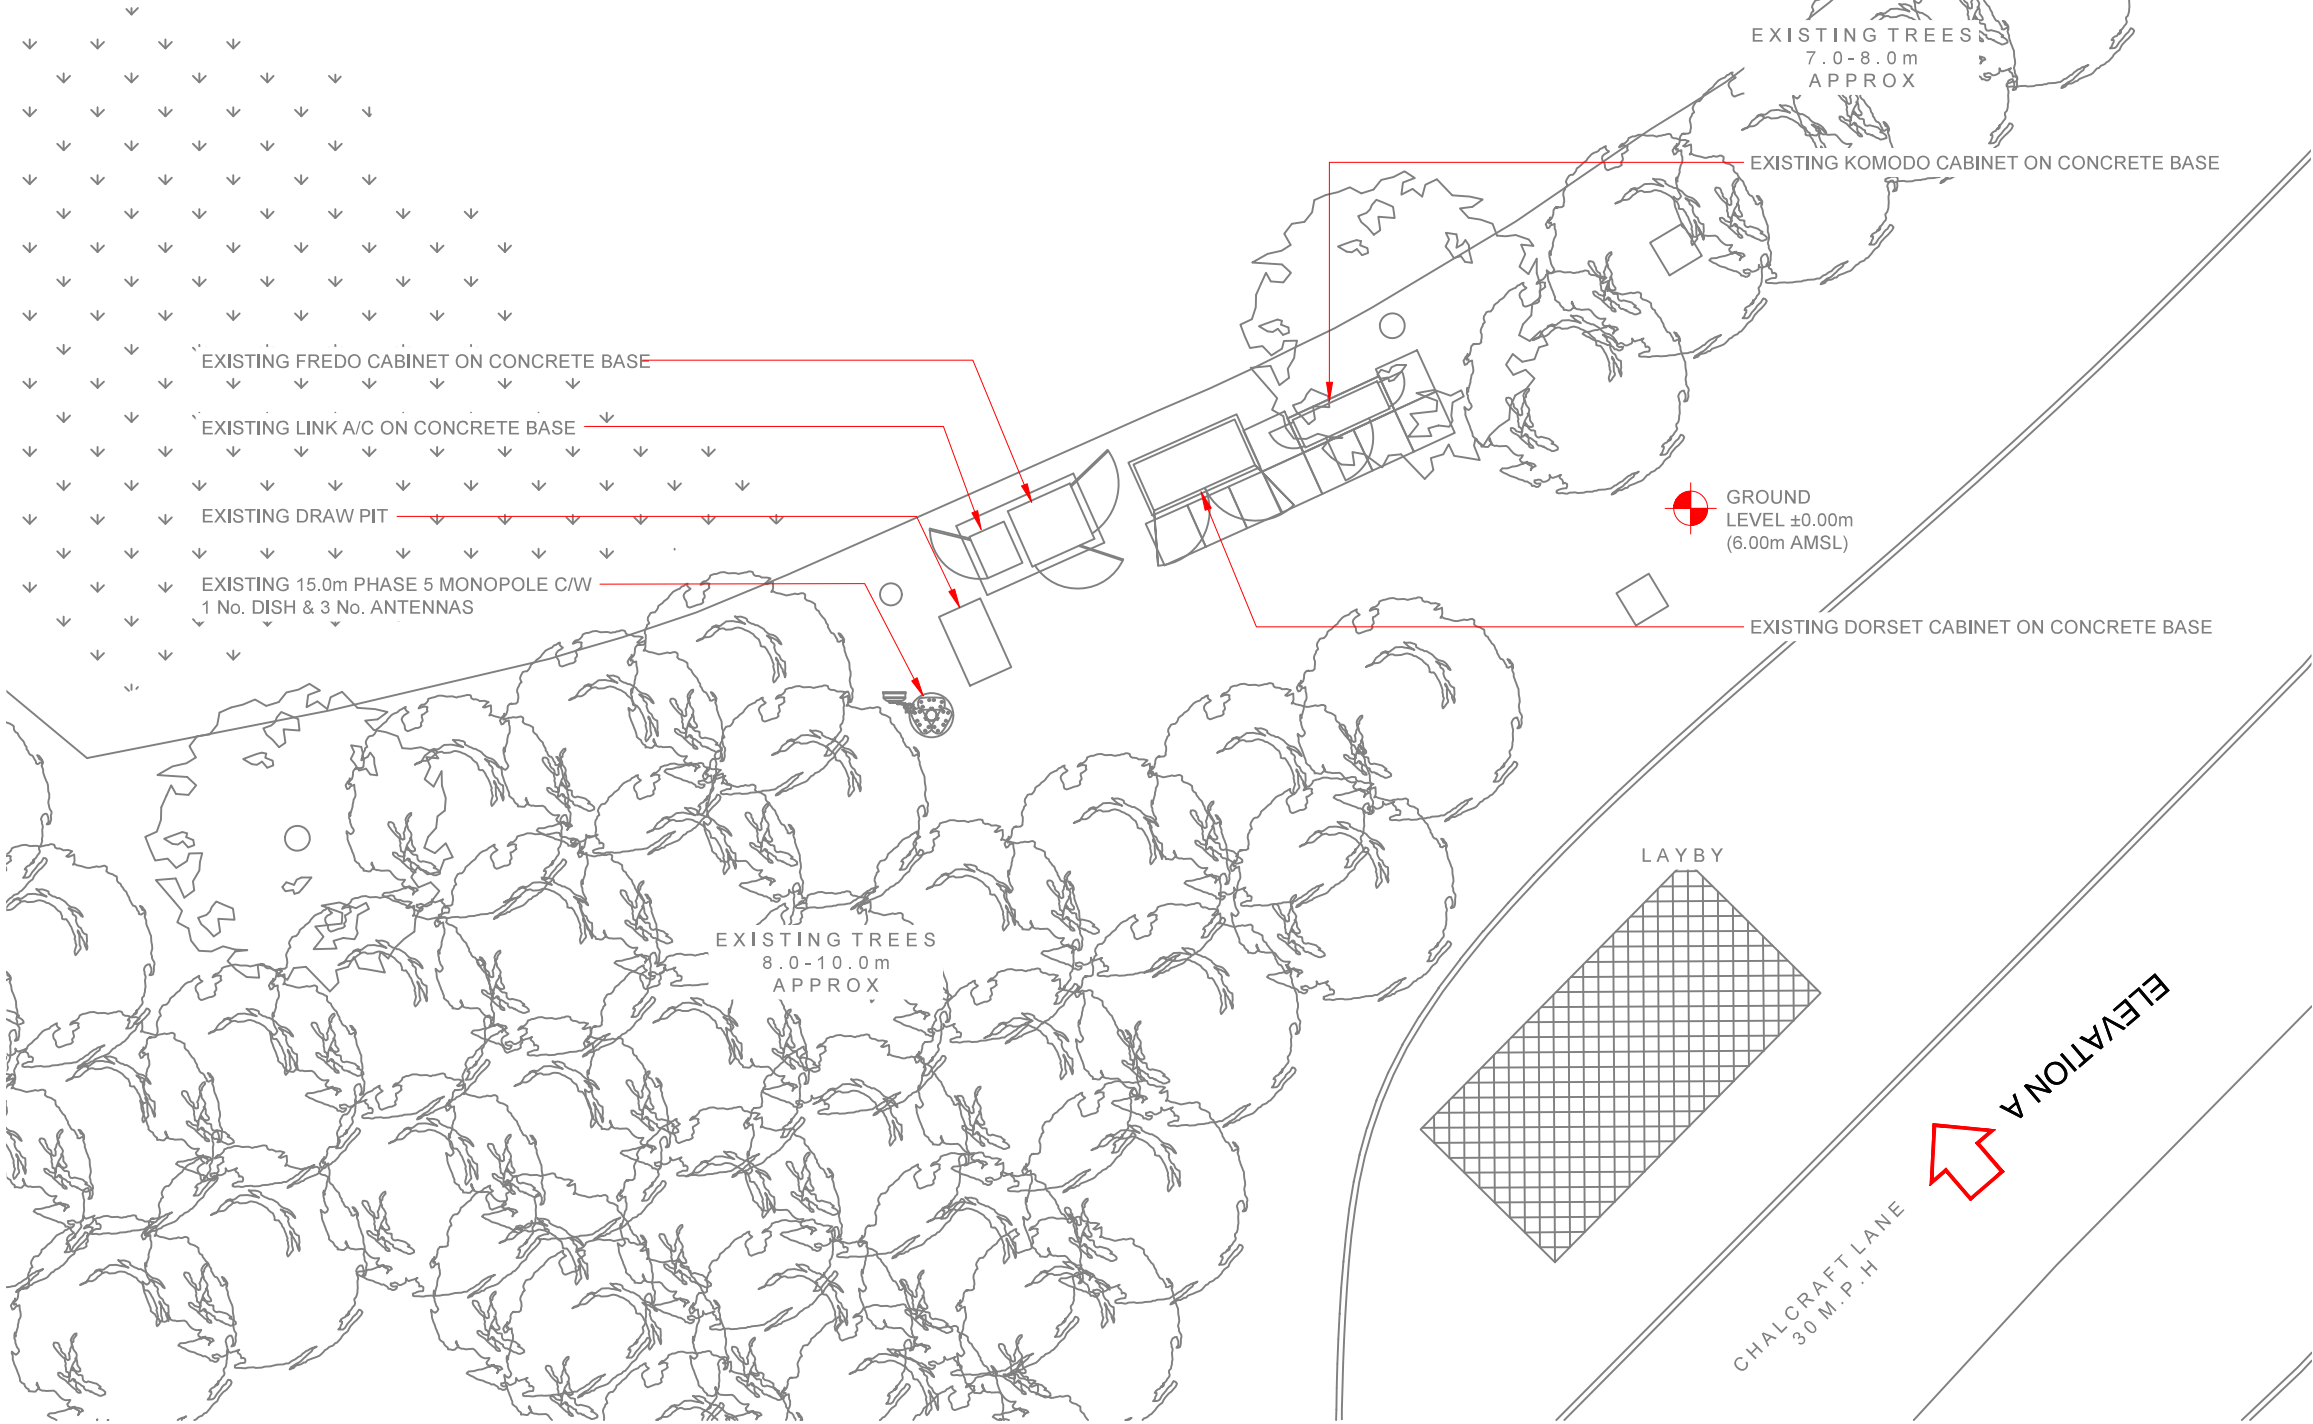

3G / 4G Antenna ID	Existing 3G Bearing
uA1	0°
uB1	120°
uC1	240°

NOTES:

1. ALL DIMENSIONS IN MM UNLESS OTHERWISE NOTED.

Master:	MBNL / EE / H3G:	Project:	Purpose of Issue:	Issue:
M004	MBNL	H3G UNILATERAL SW	Planning	B
Date:	12/01/2021	Revision / Upgrade Description:		
Drawn:	M.Williams	For Planning Approval		
Checked:	A.Dobson			
Approved:	A.Dobson			



Hutchison 3G UK Limited
Star House, 20 Grenfell Road
Maidenhead, SL6 1EH
Tel: 01628 785 500
Fax: 01628 785 501

H3G Base Station Information line:
0845 6043000
Available 9am-5pm Monday to Friday



Hatfield Business Park
Hatfield
Hertfordshire
AL10 9BW

Tel: 01707 315000
Fax: 01707 319001



Mobile Broadband Network Limited
Sixth Floor, Thames Tower, Station Road, Reading, RG1 1LX

Design Consultant & Principal Contractor:

CLARKE telecom

Unit E, Madison Place, Northampton Road,
Manchester, M40 5AG
Tel: 0161 785 4500 Fax: 0161 785 4501
Web: www.clarke-telecom.com

Site Name: CHALCRAFT LANE

Site ID: 1107443

Address: CHALCRAFT LANE / LOWER BOGNOR ROAD
LOWER BOGNOR ROAD
BOGNOR REGIS
WEST SUSSEX
PO21 5QB

Title: 100 EXISTING SITE PLAN


Project: H3G UNILATERAL SW

Purpose of Issue: PLANNING

EE Cell ID: 25535	MBNL Cell ID: ARN046	3UK Cell ID: PO0166
----------------------	-------------------------	------------------------

Master Drawing No: 1107443_25535_ARN046_PO0166_M004	Issue: B
--	-------------

 EXISTING SITE PLAN



100mm


50mm

10mm

3G / 4G Antenna ID	Existing 3G Bearing
uA1	0°
uB1	120°
uC1	240°

NOTES:

1. ALL DIMENSIONS IN MM UNLESS OTHERWISE NOTED.

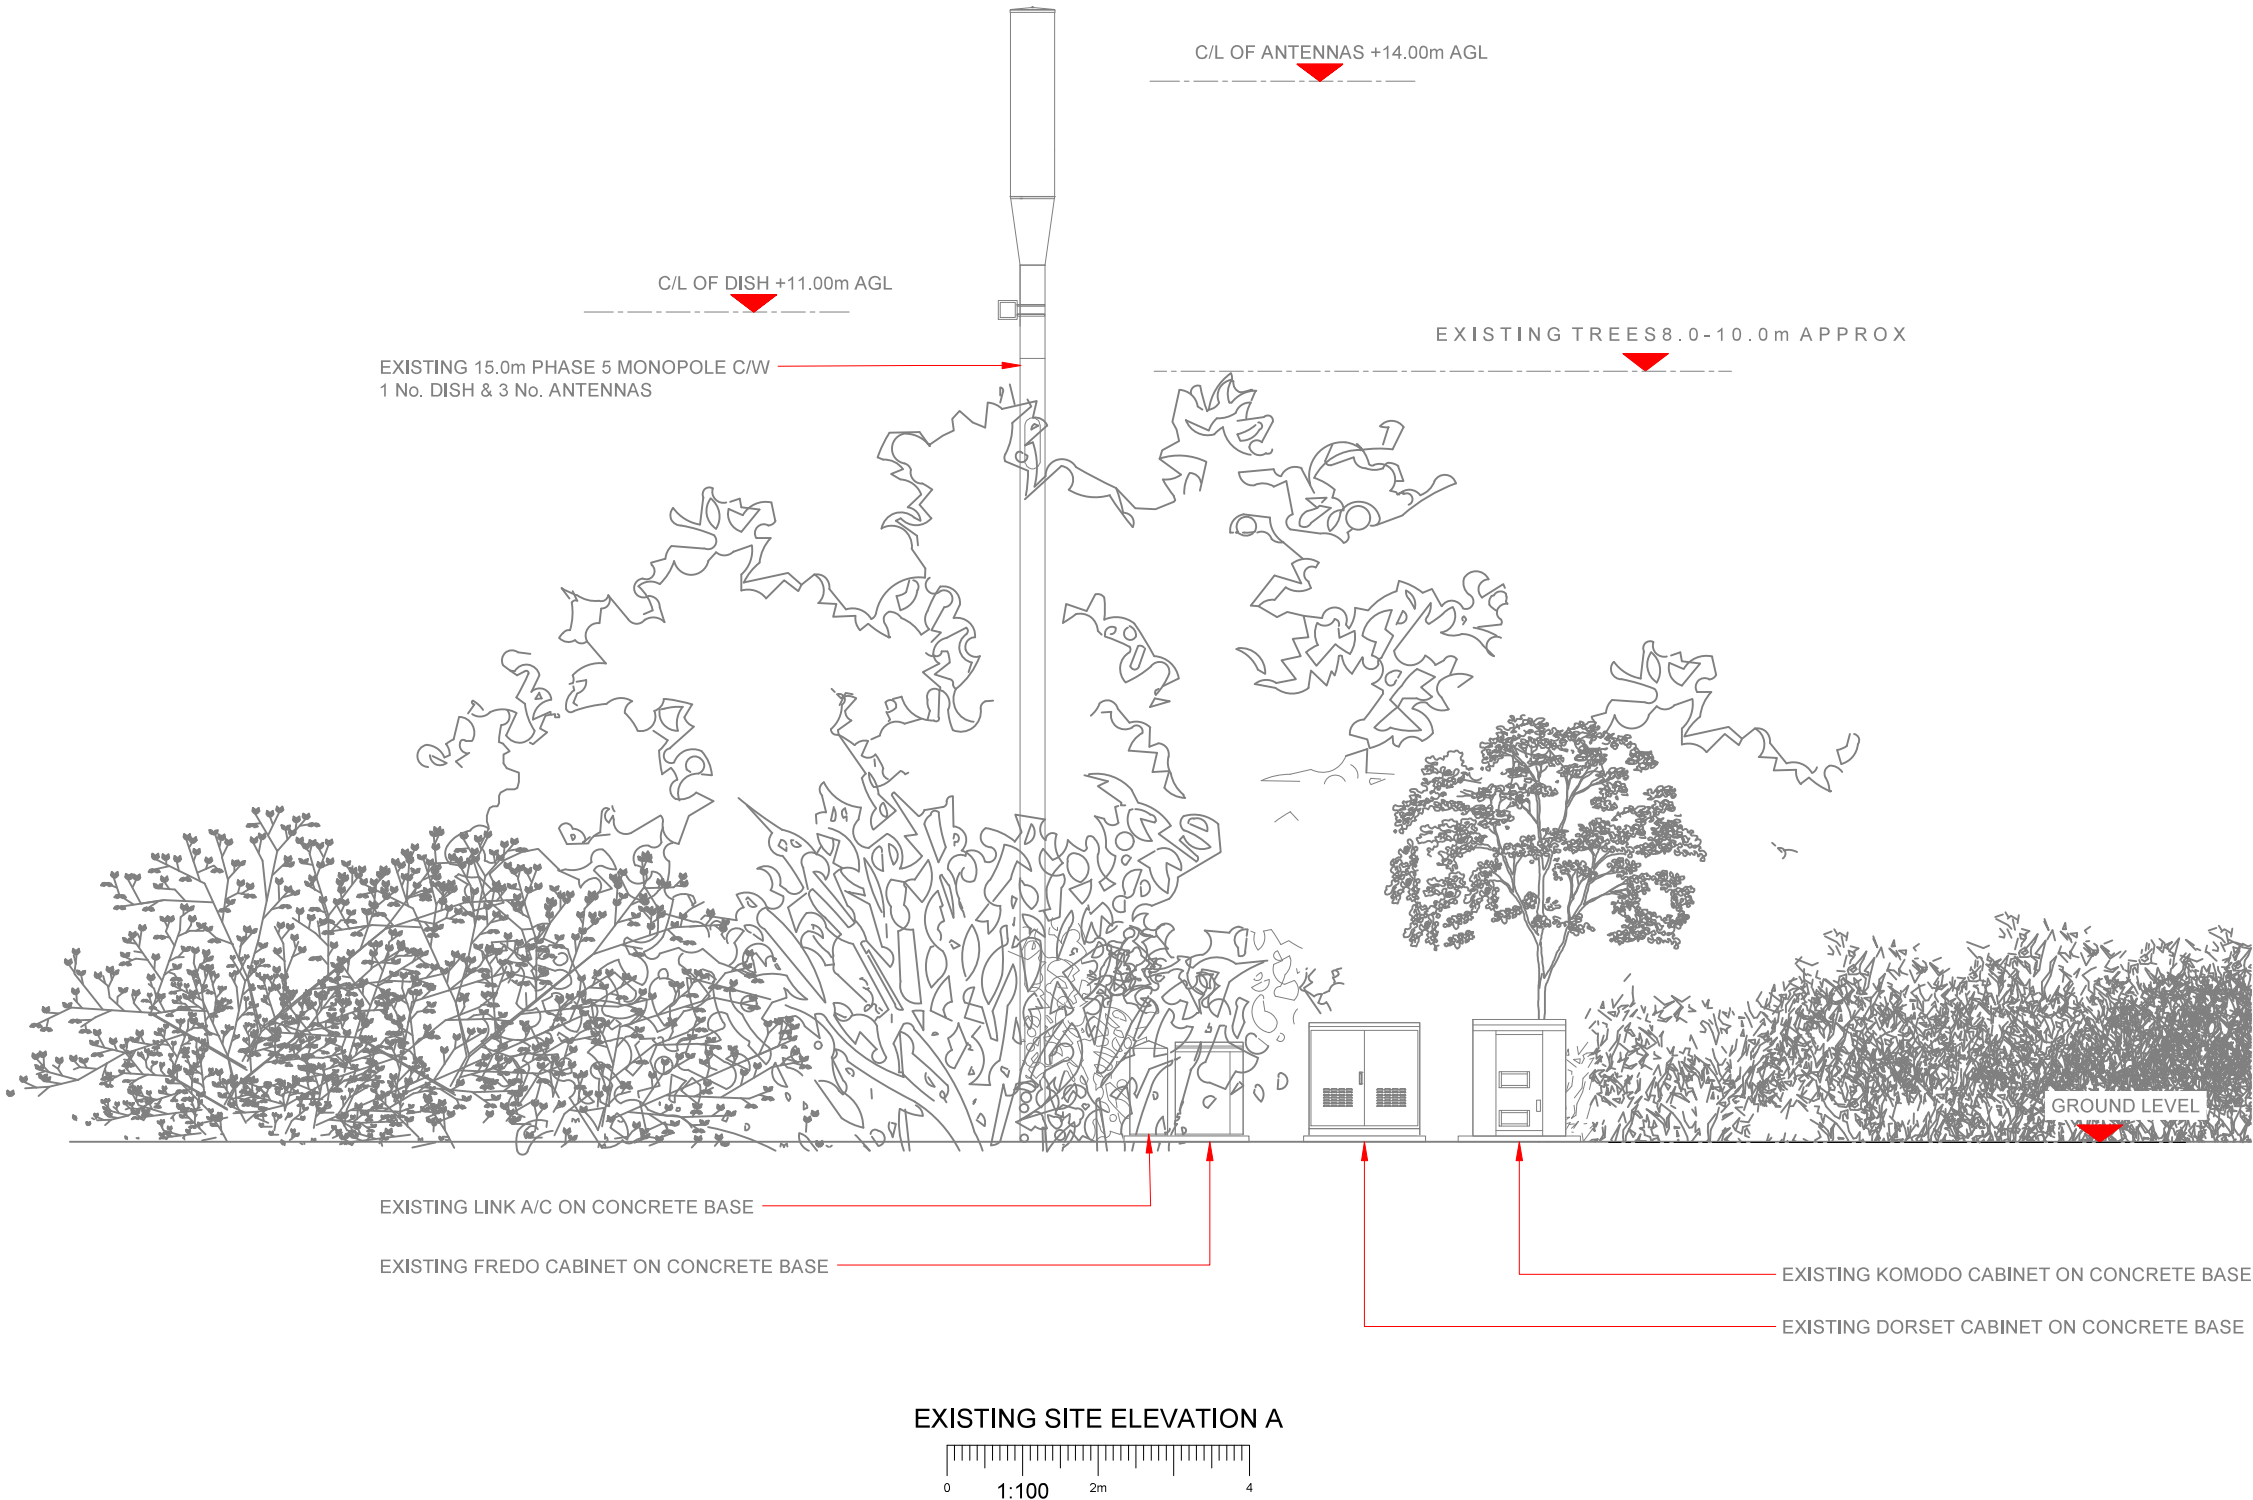

Master:	MBNL / EE / H3G:	Project:	Purpose of Issue:	Issue:
M004	MBNL	H3G UNILATERAL SW	Planning	B
Date:	12/01/2021	Revision / Upgrade Description:		
Drawn:	M.Williams	For Planning Approval		
Checked:	A.Dobson			
Approved:	A.Dobson			



Hutchison 3G UK Limited
Star House, 20 Greenfell Road
Maidenhead, SL6 1EH
Tel: 01628 785 000
Fax: 01628 785 001

H3G Base Station Information line:
0845 6043000
Available 9am-5pm Monday to Friday



Hatfield Business Park
Hatfield
Hertfordshire
AL10 9BW
Tel: 01707 315000
Fax: 01707 319001



Mobile Broadband Network Limited
Sixth Floor, Thames Tower, Station Road, Reading, RG1 1LX

Design Consultant & Principal Contractor:

CLARKE
telecom

Unit E, Madison Place, Northampton Road,
Manchester, M40 5AG
Tel: 0161 785 4500 Fax: 0161 785 4501
Web: www.clarke-telecom.com

Site Name: CHALCRAFT LANE

Site ID: 1107443

Address: CHALCRAFT LANE / LOWER BOGNOR ROAD
LOWER BOGNOR ROAD
BOGNOR REGIS
WEST SUSSEX
PO21 5QB


Title: 150 EXISTING SITE ELEVATION A


Project: H3G UNILATERAL SW

Purpose of Issue: PLANNING

EE Cell ID:	MBNL Cell ID:	3UK Cell ID:
25535	ARN046	PO0166

Master Drawing No:	Issue:
1107443_25535_ARN046_PO0166_M004	B

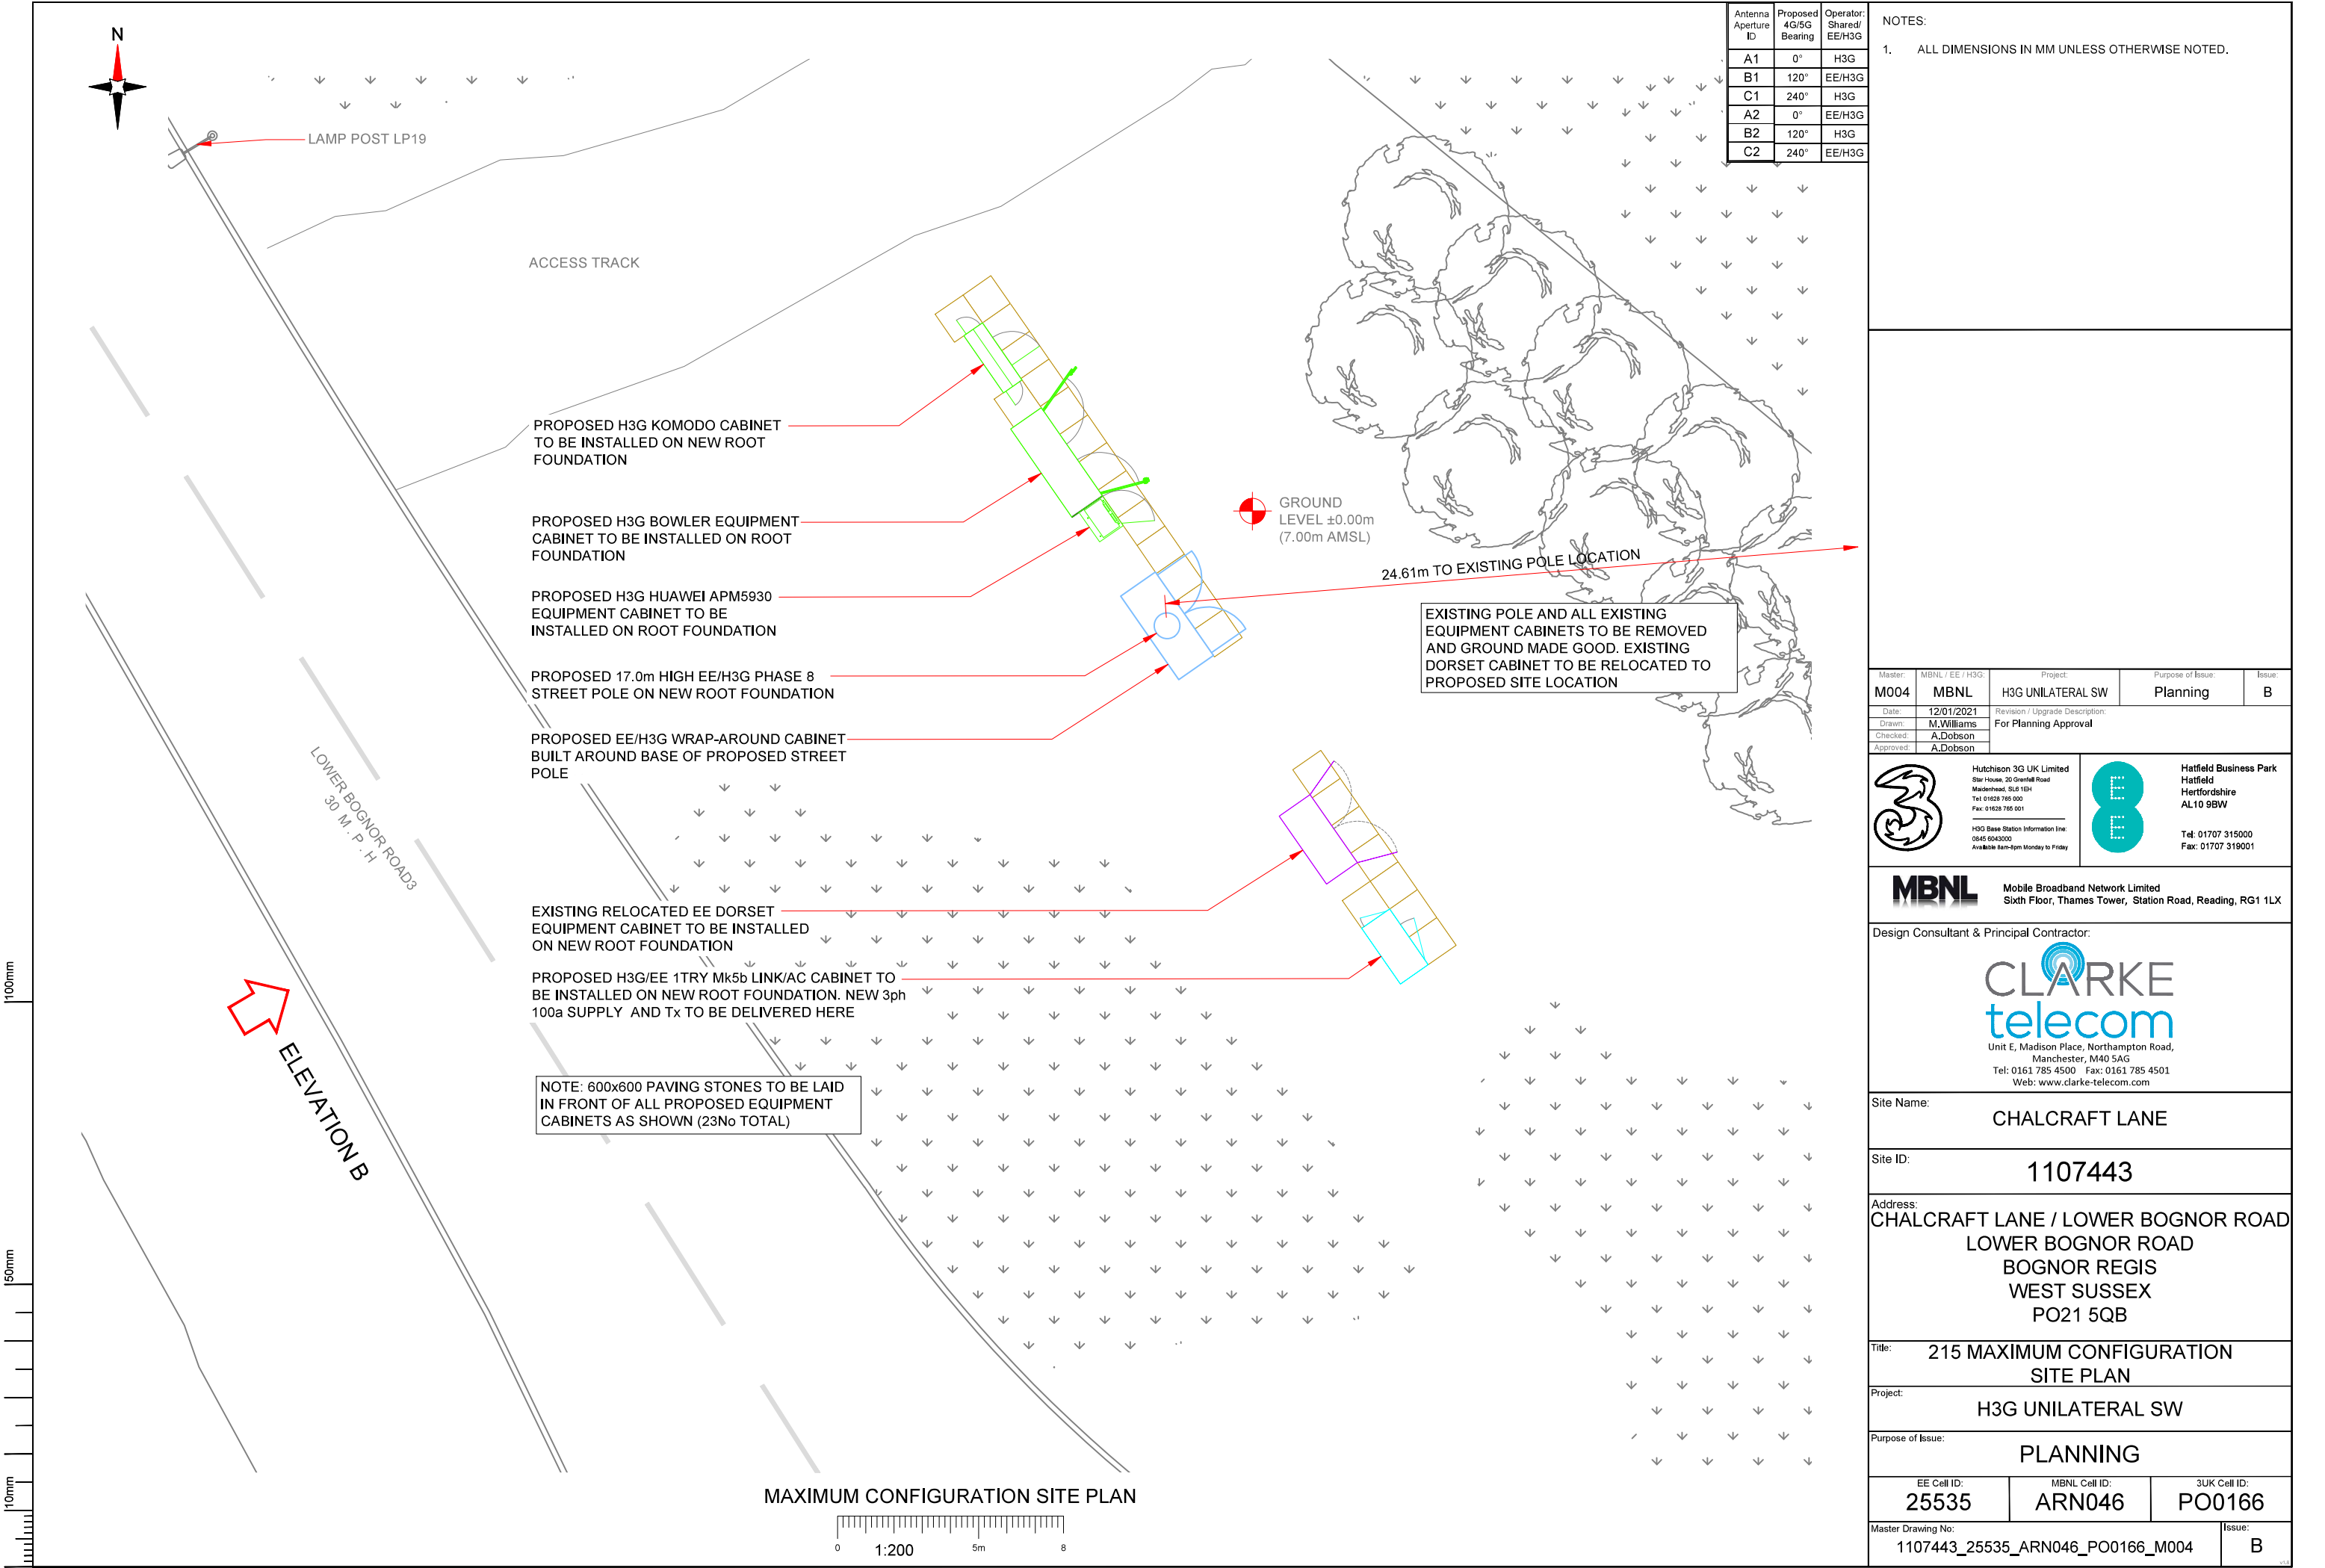

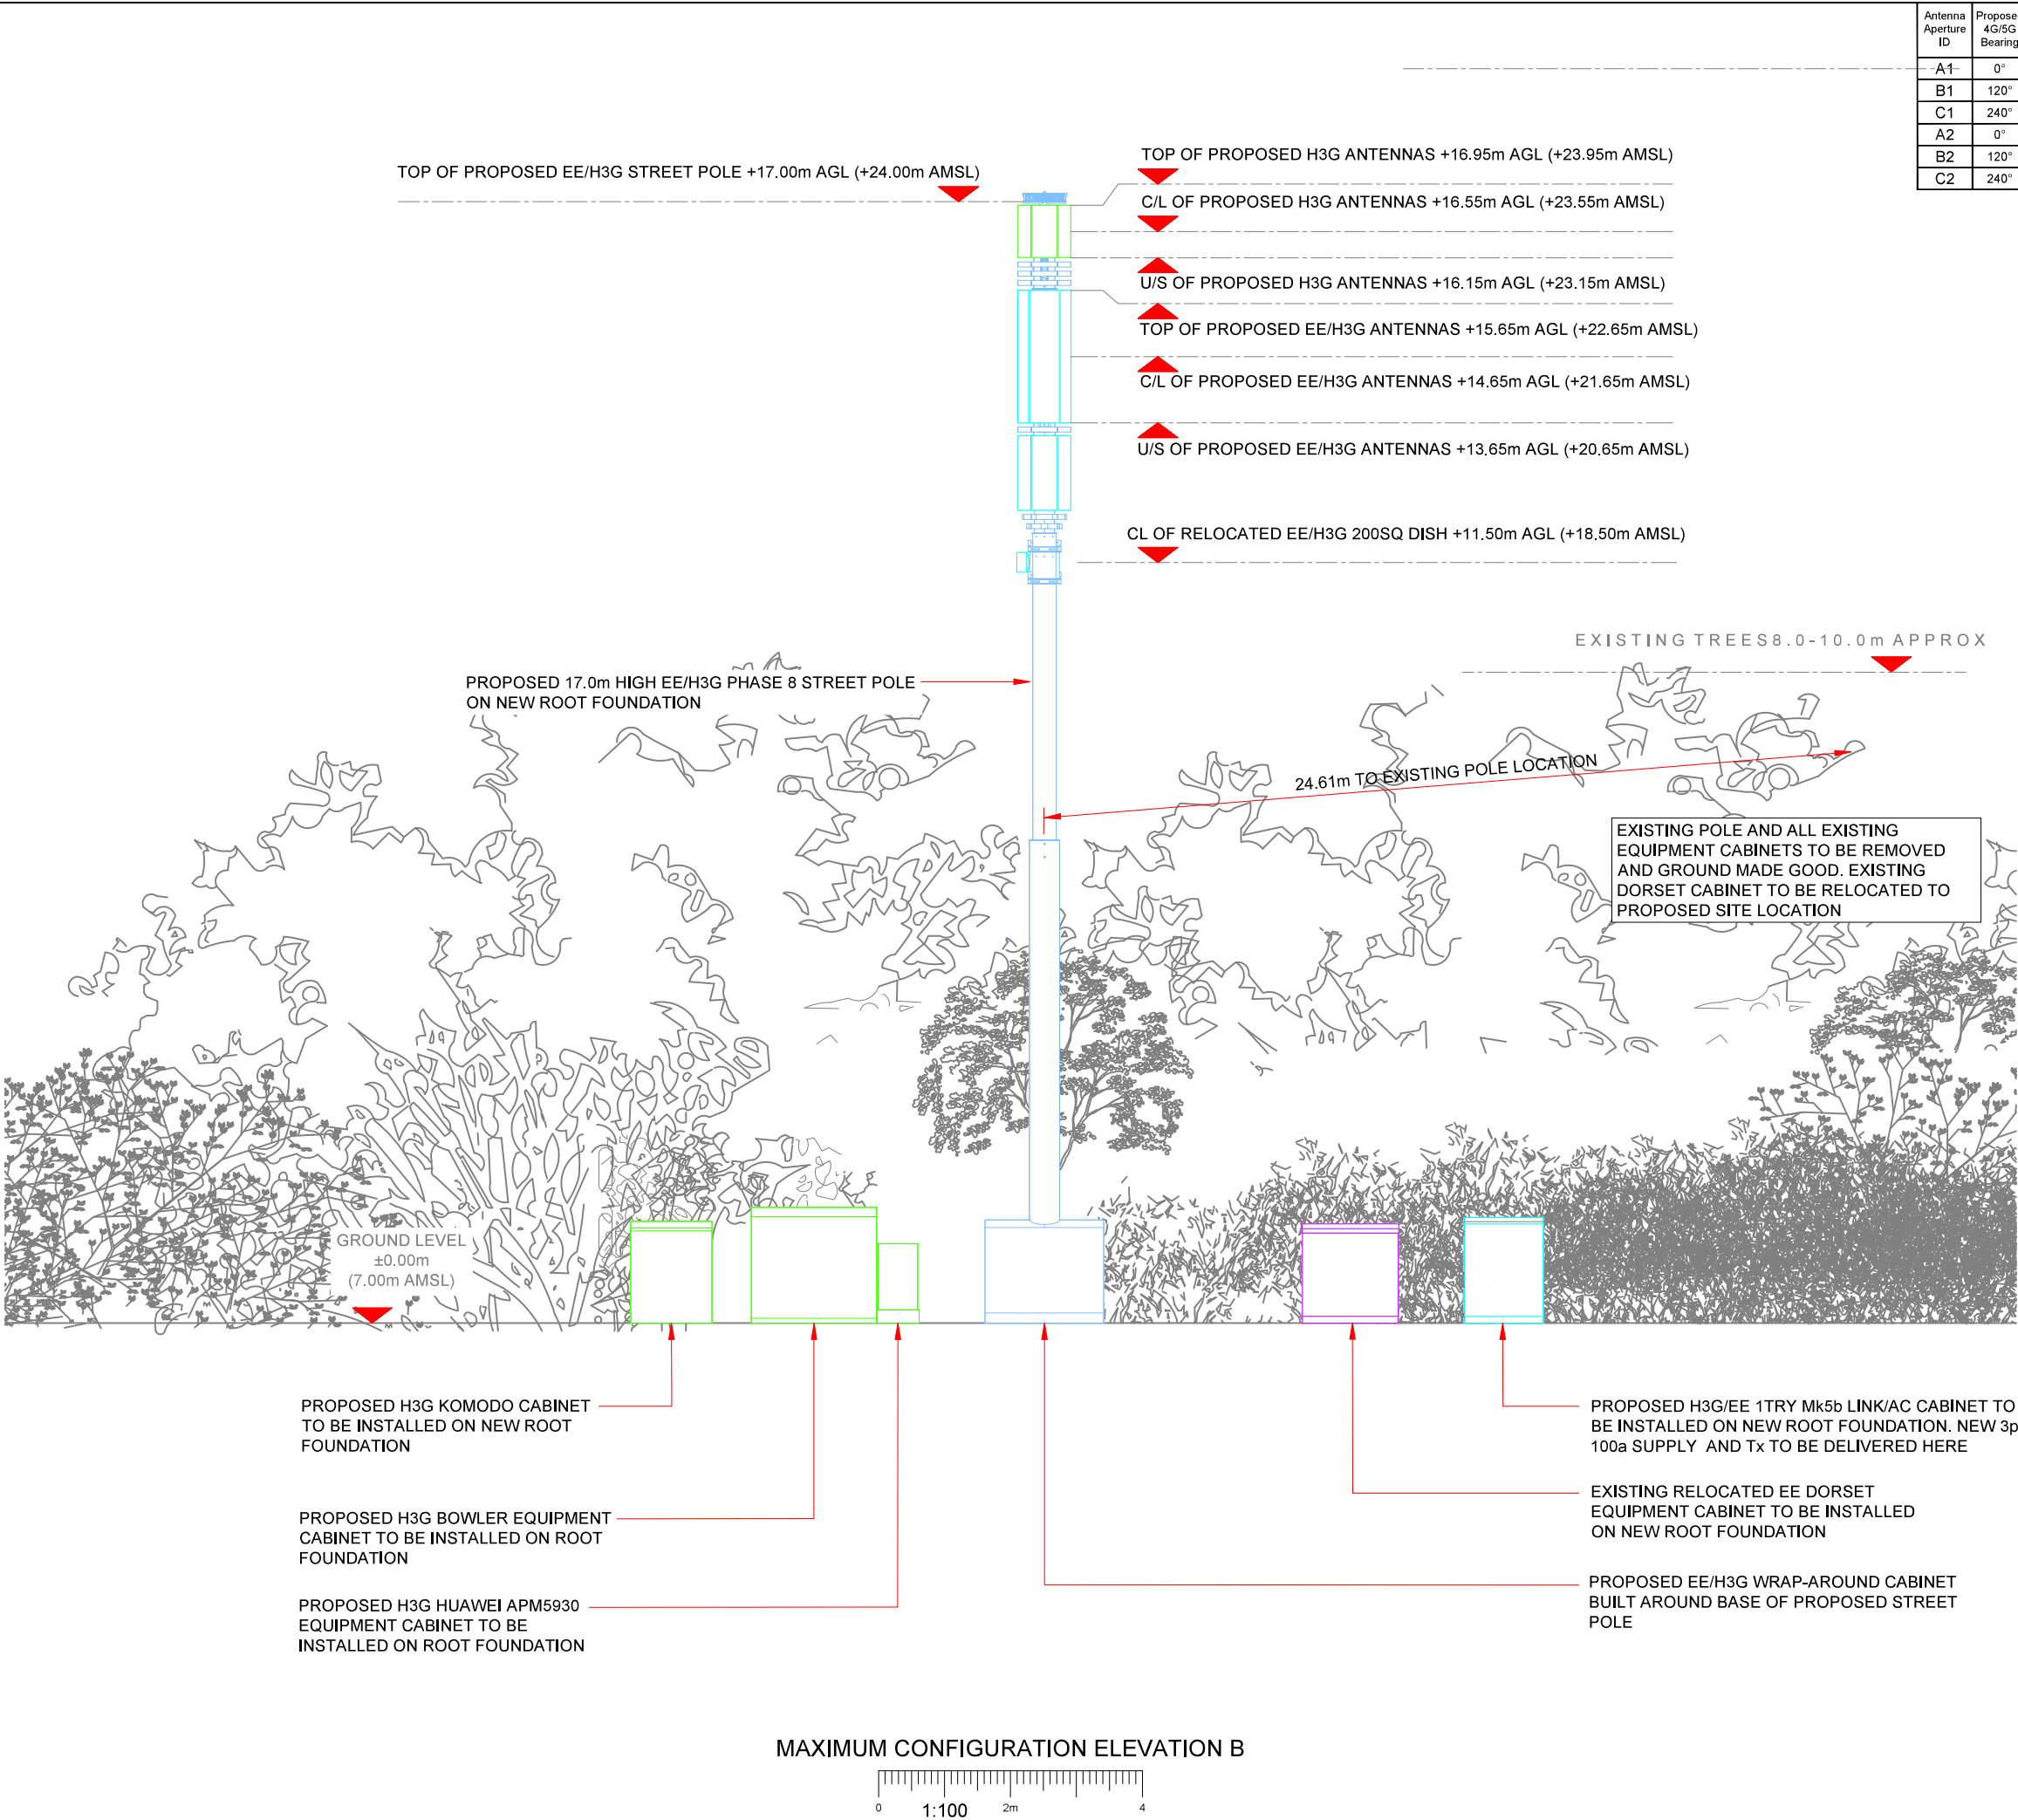

Antenna Aperture ID	Proposed 4G/5G Bearing	Operator: Shared/ EE/H3G
A1	0°	H3G
B1	120°	EE/H3G
C1	240°	H3G
A2	0°	EE/H3G
B2	120°	H3G
C2	240°	EE/H3G

NOTES:

1. ALL DIMENSIONS IN MM UNLESS OTHERWISE NOTED.

Master:	MBNL / EE / H3G:	Project:	Purpose of Issue:	Issue:
M004	MBNL	H3G UNILATERAL SW	Planning	B
Date:	12/01/2021	Revision / Upgrade Description:		
Drawn:	M.Williams	For Planning Approval		
Checked:	A.Dobson			
Approved:	A.Dobson			



Hutchison 3G UK Limited
Star House, 20 Greenfell Road
Maidenhead, SL6 1EH
Tel: 01628 785 500
Fax: 01628 785 501



Hatfield Business Park
Hatfield
Hertfordshire
AL10 9BW
Tel: 01707 315000
Fax: 01707 319001



Mobile Broadband Network Limited
Sixth Floor, Thames Tower, Station Road, Reading, RG1 1LX

Design Consultant & Principal Contractor:

CLARKE telecom

Unit E, Madison Place, Northampton Road,
Manchester, M40 5AG
Tel: 0161 785 4500 Fax: 0161 785 4501
Web: www.clarke-telecom.com

Site Name: **CHALCRAFT LANE**

Site ID: **1107443**

Address: **CHALCRAFT LANE / LOWER BOGNOR ROAD
LOWER BOGNOR ROAD
BOGNOR REGIS
WEST SUSSEX
PO21 5QB**

Title: **265 MAXIMUM CONFIGURATION
ELEVATION B**

Project: **H3G UNILATERAL SW**

Purpose of Issue: **PLANNING**

EE Cell ID: 25535	MBNL Cell ID: ARN046	3UK Cell ID: PO0166
-----------------------------	--------------------------------	-------------------------------

Master Drawing No: 1107443_25535_ARN046_PO0166_M004	Issue: B
---	--------------------