


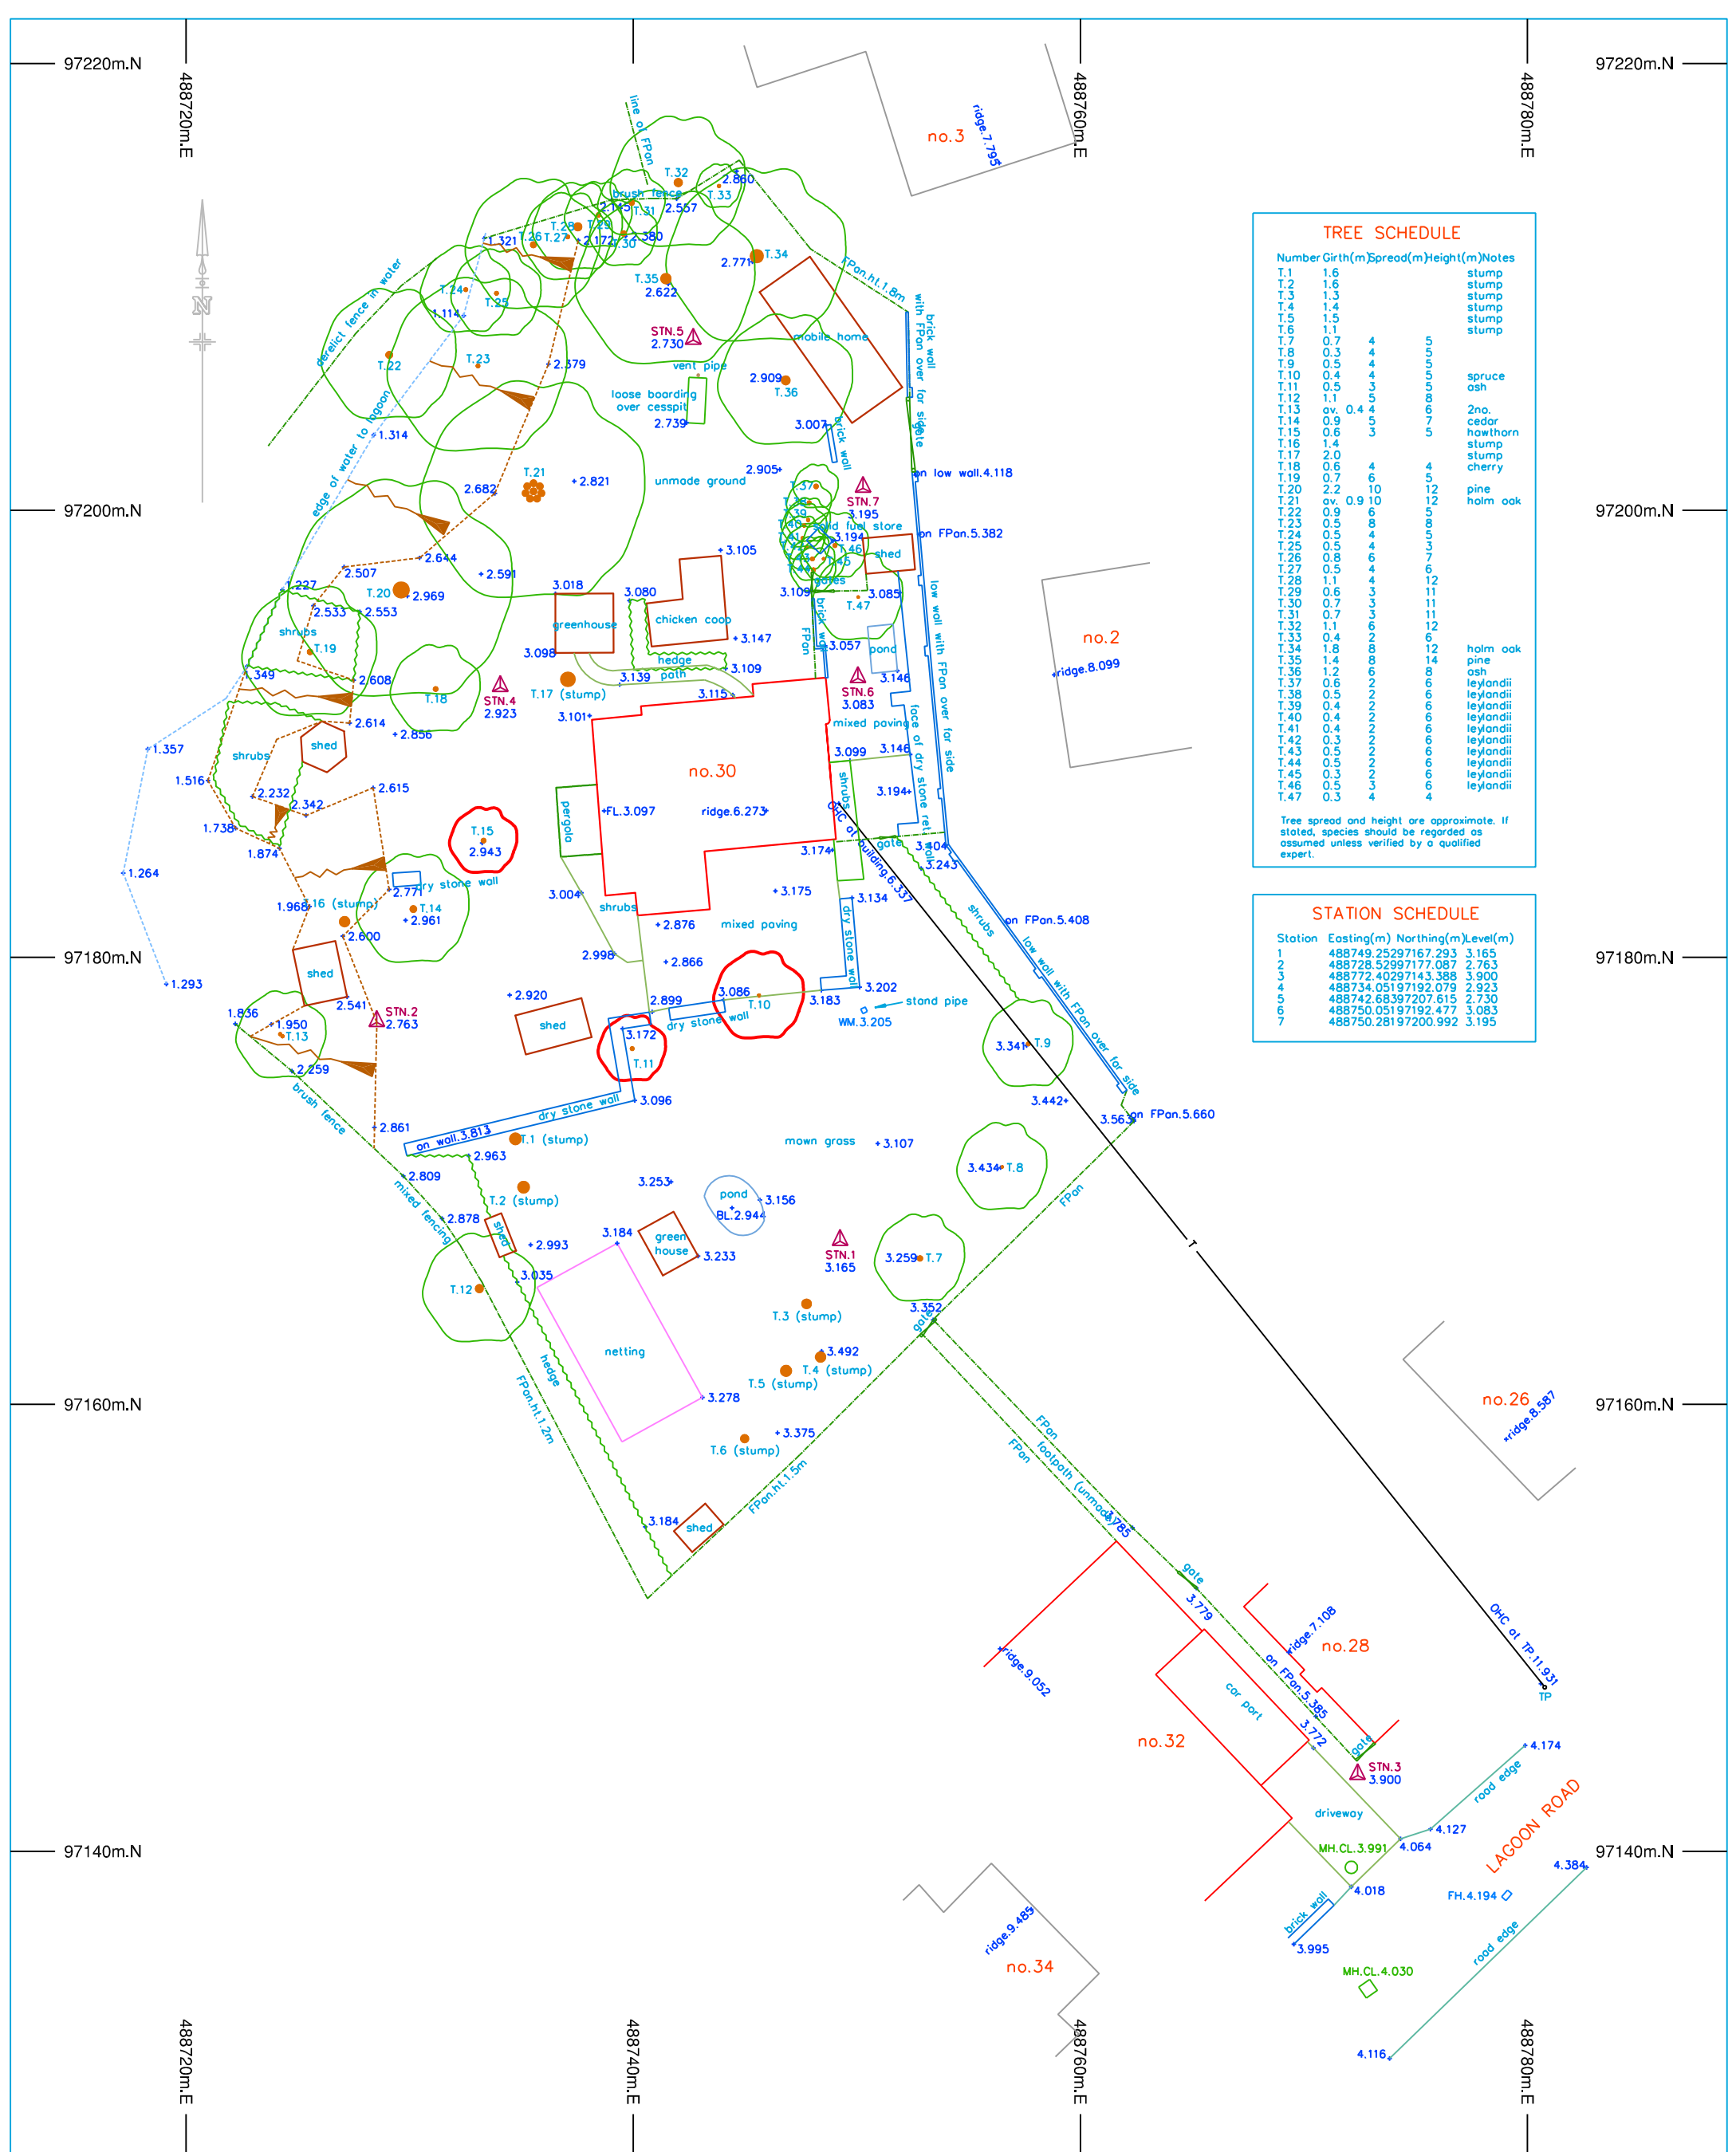

TREE SCHEDULE

Number	Girth(m)	Spread(m)	Height(m)	Notes
T.1	1.6			stump
T.2	1.6			stump
T.3	1.3			stump
T.4	1.4			stump
T.5	1.5			stump
T.6	1.1			stump
T.7	0.7	4	5	
T.8	0.3	4	5	
T.9	0.5	4	5	
T.10	0.4	4	5	spruce
T.11	0.5	3	5	ash
T.12	1.1	5	8	
T.13	av. 0.4	4	6	2nd.
T.14	0.9	5	7	cedar
T.15	0.6	3	5	hawthorn
T.16	1.4			stump
T.17	2.0			stump
T.18	0.6	4	4	cherry
T.19	0.7	6	5	
T.20	2.2	10	12	pine
T.21	av. 0.9	10	12	holm oak
T.22	0.9	6	5	
T.23	0.5	8	8	
T.24	0.5	4	8	
T.25	0.5	4	3	
T.26	0.8	6	7	
T.27	0.5	4	6	
T.28	1.1	4	12	
T.29	0.6	3	11	
T.30	0.7	3	11	
T.31	0.7	3	11	
T.32	1.1	6	12	
T.33	0.4	2	6	
T.34	1.8	8	12	holm oak
T.35	1.4	8	14	pine
T.36	1.2	6	8	ash
T.37	0.6	2	6	leylandii
T.38	0.5	2	6	leylandii
T.39	0.4	2	6	leylandii
T.40	0.4	2	6	leylandii
T.41	0.4	2	6	leylandii
T.42	0.3	2	6	leylandii
T.43	0.5	2	6	leylandii
T.44	0.5	2	6	leylandii
T.45	0.3	2	6	leylandii
T.46	0.5	3	6	leylandii
T.47	0.3	4	4	

Tree spread and height are approximate. If stated, species should be regarded as assumed unless verified by a qualified expert.

STATION SCHEDULE

Station	Easting(m)	Northing(m)	Level(m)
1	488749.25297167	293	3.165
2	488728.52997177	083	2.763
3	488772.40297143	388	3.900
4	488734.05197192	079	2.923
5	488742.68397207	615	2.730
6	488750.05197192	477	3.083
7	488750.28197200	992	3.195

 Chartered Surveyors Copyright ? 2017 Offington Land Surveys Ltd 29 Offington Drive Worthing West Sussex BN14 9PW Tel/fax 01903 267883 surveys@offington.com	Job 30 LAGOON ROAD PAGHAM, BOGNOR REGIS WEST SUSSEX PO21 4TJ Drawing No. 15180317 Site Plan Client Lambda Construction & Refurbishment Ltd Survey Date(s): 06/03/2017 Surveyor: ST Drafted by: JW Checked by: ST	STANDARD REFERENCE Datum Used <u>Newlyn</u> <u>Survey translated to ODN & OSGB36(15) by non-scaled best fit</u> <u>to GNSS RTK of controls (GNSS accuracy +/- 50mm r.m.sse).</u> Survey Station Shown Thus:  Foul Water Drainage  Storm Water Drainage  Water Mains  Gas Mains  Electricity Cable  British Telecom Cable  True north direction shown is indicative only. The details shown hereon relating to all underground services are as obtained by normal above-ground survey observation and methods. Although all reasonable efforts have been made no guarantee is given for the completeness or accuracy of this information. Neighbouring building footprints transposed from Ordnance map for context for ridge spot levels (except 28 & 32)	ABBREVIATIONS <table border="0"> <tr> <td>AV</td><td>Air Valve</td> <td>IL</td><td>Invert Level</td> </tr> <tr> <td>LP</td><td>Lamp Post</td> <td>LP</td><td>Lamp Post</td> </tr> <tr> <td>BT</td><td>British Telecom</td> <td>MP</td><td>Manhole</td> </tr> <tr> <td>CATV</td><td>Television Cable Pit</td> <td>MP</td><td>Marker Post</td> </tr> <tr> <td>CB</td><td>Concrete Bollard</td> <td>OHC</td><td>Overhead Cable</td> </tr> <tr> <td>CE</td><td>Cleaning Eye</td> <td>PVM</td><td>Permit Vending Machine</td> </tr> <tr> <td>CL</td><td>Cover Level</td> <td>RG</td><td>Road Gully</td> </tr> <tr> <td>CM</td><td>Cable Marker</td> <td>RS</td><td>Road Sign</td> </tr> <tr> <td>CP</td><td>Catch Pit</td> <td>RWP</td><td>Rain Water Pipe</td> </tr> <tr> <td>dc</td><td>Depth</td> <td>SC</td><td>Stop Cock</td> </tr> <tr> <td>ECP</td><td>Electricity Cable Pit</td> <td>SH</td><td>Service Housing</td> </tr> <tr> <td>EP</td><td>Electricity Pole</td> <td>SV</td><td>Stop Valve</td> </tr> <tr> <td>ER</td><td>Earth Rod</td> <td>SVP</td><td>Soil & Vent Pipe</td> </tr> <tr> <td>FA</td><td>Fire Alarm</td> <td>SW</td><td>Storm Water</td> </tr> <tr> <td>FH</td><td>Fire Hydrant</td> <td>TP</td><td>Telegraph Pole</td> </tr> <tr> <td>FL</td><td>Floor Level</td> <td>VP</td><td>Vent Pipe</td> </tr> <tr> <td>FP</td><td>Footpath</td> <td>WM</td><td>Water Meter</td> </tr> <tr> <td>G</td><td>Gully</td> <td>WO</td><td>Water Wash Out</td> </tr> <tr> <td>IC</td><td>Inspection Cover</td> <td></td><td></td> </tr> </table>	AV	Air Valve	IL	Invert Level	LP	Lamp Post	LP	Lamp Post	BT	British Telecom	MP	Manhole	CATV	Television Cable Pit	MP	Marker Post	CB	Concrete Bollard	OHC	Overhead Cable	CE	Cleaning Eye	PVM	Permit Vending Machine	CL	Cover Level	RG	Road Gully	CM	Cable Marker	RS	Road Sign	CP	Catch Pit	RWP	Rain Water Pipe	dc	Depth	SC	Stop Cock	ECP	Electricity Cable Pit	SH	Service Housing	EP	Electricity Pole	SV	Stop Valve	ER	Earth Rod	SVP	Soil & Vent Pipe	FA	Fire Alarm	SW	Storm Water	FH	Fire Hydrant	TP	Telegraph Pole	FL	Floor Level	VP	Vent Pipe	FP	Footpath	WM	Water Meter	G	Gully	WO	Water Wash Out	IC	Inspection Cover			SCALE Plot Scale: 1:200 Sheet Size: A2 Portrait Sheet: 1 of 1 If printing a PDF version, to retain scale please ensure print options are selected for 100% original size / no scaling / no shrink to fit, as appropriate.  SCALE BAR
	AV	Air Valve	IL	Invert Level																																																																												
LP	Lamp Post	LP	Lamp Post																																																																													
BT	British Telecom	MP	Manhole																																																																													
CATV	Television Cable Pit	MP	Marker Post																																																																													
CB	Concrete Bollard	OHC	Overhead Cable																																																																													
CE	Cleaning Eye	PVM	Permit Vending Machine																																																																													
CL	Cover Level	RG	Road Gully																																																																													
CM	Cable Marker	RS	Road Sign																																																																													
CP	Catch Pit	RWP	Rain Water Pipe																																																																													
dc	Depth	SC	Stop Cock																																																																													
ECP	Electricity Cable Pit	SH	Service Housing																																																																													
EP	Electricity Pole	SV	Stop Valve																																																																													
ER	Earth Rod	SVP	Soil & Vent Pipe																																																																													
FA	Fire Alarm	SW	Storm Water																																																																													
FH	Fire Hydrant	TP	Telegraph Pole																																																																													
FL	Floor Level	VP	Vent Pipe																																																																													
FP	Footpath	WM	Water Meter																																																																													
G	Gully	WO	Water Wash Out																																																																													
IC	Inspection Cover																																																																															
		VERSION HISTORY <table border="1"> <thead> <tr> <th>Version</th> <th>Date</th> <th>Description</th> </tr> </thead> <tbody> <tr> <td>1.0</td> <td>07/03/2017</td> <td>Original Version</td> </tr> </tbody> </table>	Version	Date	Description	1.0	07/03/2017	Original Version																																																																								
Version	Date	Description																																																																														
1.0	07/03/2017	Original Version																																																																														